
 



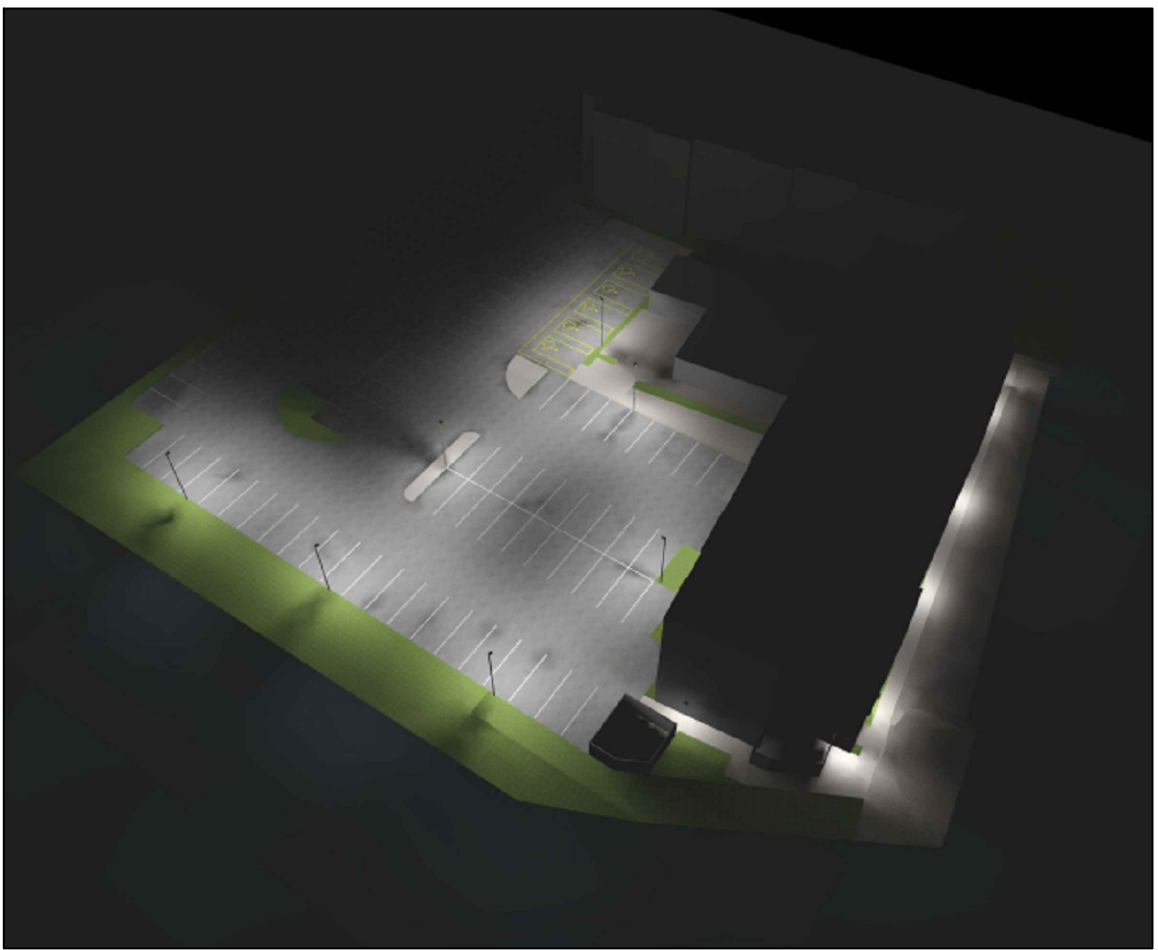

SITE PLAN (1:200)
EXTERNAL LIGHTING LAYOUT



HOTEL EXTENSION CARPARK - ILLUMINATION VIEW N.T.S

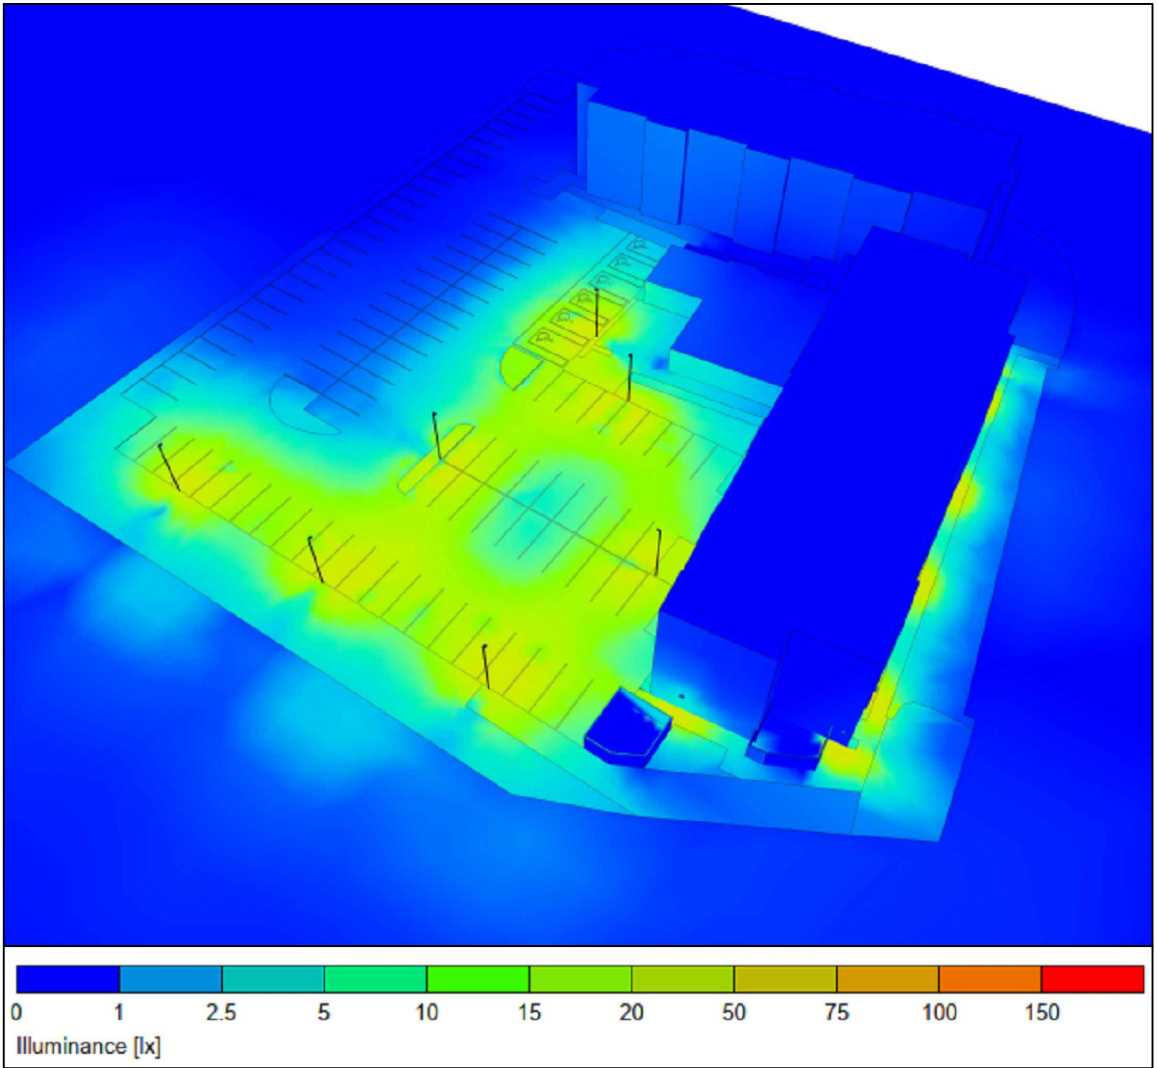

HOTEL EXTENSION CARPARK - PSEUDO COLOURS VIEW N.T.S


SYMBOL	DESCRIPTION	LAMP	MANUFACTURER REF
A	EXTERNAL LED 8m COLUMN MOUNTED LAMP	27W 3074lm 120lm/W	ANSELL LIGHTING REF: AONLED/2
B	EXTERNAL SURFACE MOUNTED LED LAMP WITH INTEGRAL EMERGENCY BACKUP	4.4W 500lm 127lm/W	WHITECROFT REF: ATRA

A - ANSELL AONIX LED/2

SYMBOL	DESCRIPTION	LAMP	MANUFACTURER REF
B	EXTERNAL SURFACE MOUNTED LED LAMP WITH INTEGRAL EMERGENCY BACKUP	4.4W 500lm 127lm/W	WHITECROFT REF: ATRA

B - WHITECROFT ATRA

SYMBOL	DESCRIPTION
---	EXISTING UNDERGROUND HIGH VOLTAGE ELECTRICITY CABLE ROUTE 600mm BELOW GROUND LEVEL
---	PROPOSED UNDERGROUND HIGH VOLTAGE ELECTRICITY CABLE ROUTE 600mm BELOW GROUND LEVEL
---	EXISTING UNDERGROUND LOW VOLTAGE ELECTRICITY CABLE ROUTE 450mm BELOW GROUND LEVEL
---	PROPOSED UNDERGROUND LOW VOLTAGE ELECTRICITY CABLE ROUTE 450mm BELOW GROUND LEVEL
---	EXISTING UNDERGROUND LV CABLE ROUTE FOR EXTERNAL LIGHTING COLUMNS
---	PROPOSED UNDERGROUND LV CABLE ROUTE FOR EXTERNAL LIGHTING COLUMNS
---	EXISTING UNDERGROUND MAINS COLD WATER PIPE ROUTE 750mm BELOW GROUND LEVEL
---	PROPOSED UNDERGROUND MAINS COLD WATER PIPE ROUTE 750mm BELOW GROUND LEVEL

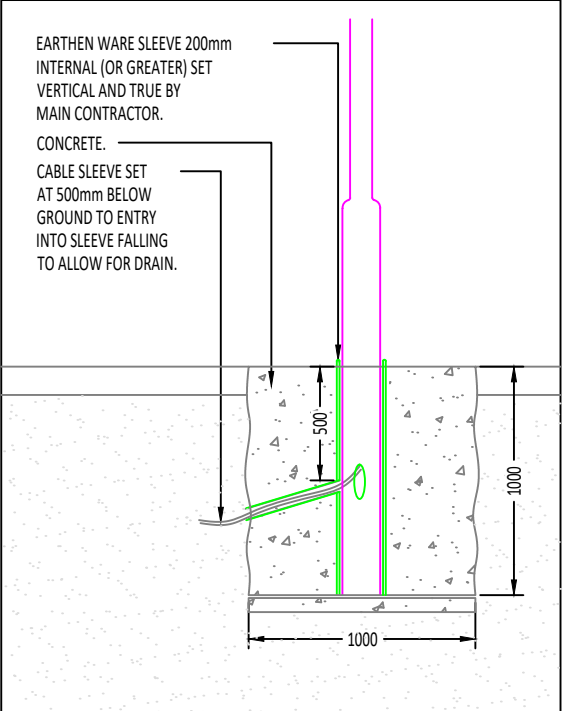

TYPICAL COLUMN INSTALLATION DETAIL N.T.S

THIS DRAWING IS PROTECTED UNDER COPYRIGHT AND AT NO TIME MUST ANY PORTION OF THIS DRAWING BE REPRODUCED OR COPIED IN ANYWAY WITHOUT THE WRITTEN CONSENT OF THORNLEY & LUMB PARTNERSHIP LIMITED.

ALL DIMENSIONS ARE IN MILLIMETRES UNLESS STATED OTHERWISE AND MUST BE CHECKED ON SITE AND NOT SCALED FROM THIS DRAWING. THIS DRAWING IS TO BE READ IN ACCORDANCE WITH ALL RELEVANT SPECIFICATIONS AND ROOM DATA DOCUMENTS.

- NOTES
- LIGHTING DESIGN
- WITHIN THE PROPOSED SCHEME, THERE IS A REQUIREMENT FOR LIGHTING TO THE CAR PARK OF THE CONTINENTAL APPROACH, THEREFORE THE FOLLOWING WORKS WILL BE REQUIRED:
- DUE TO THE NEW PROPOSED EXTENSION CAR PARK, 7x NEW LIGHTING COLUMNS & 7x NEW BUILDING MOUNTED LUMINAIRES ARE REQUIRED TO ACHIEVE THE REQUIRED LIGHTING LEVELS. SEE SITE LAYOUT FOR DETAILS.
 - ALL EXTERNAL LIGHTING COLUMNS ARE TO BE CONTROLLED VIA A 24/7 TIME CLOCK IN CONJUNCTION WITH A PHOTOCELL. BUILDING MOUNTED ESCAPE ROUTE LIGHTS ARE TO BE CONTROLLED VIA A PI SENSOR IN CONJUNCTION WITH A 24/7 TIME CLOCK & PHOTOCELL.
 - WITH RESPECT TO THE OVERALL ASSESSMENT AND CALCULATIONS CARRYOUT, THE EXTERNAL LIGHTING INDICATED AND POLLUTION LEVELS ARE NOT INFLUENCED BY THE PROPOSED NUMBER AND LOCATIONS OF LIGHTING COLUMNS.
 - IN SUMMARY IT'S OUR CONSIDERED OPINION THAT THE NEW LIGHTING WILL HAVE MINIMAL LIGHTING IMPACT TO THE SURROUNDING AREAS.

BS5489 PROVIDE GUIDELINES FOR LIGHTING PERFORMANCE CRITERIA. THE FOLLOWING ASSUMPTIONS ARE MADE:

- THE AREA TO BE ILLUMINATED IS CLASSIFIED AS A MIXED VEHICULAR AND PEDESTRIAN AREA ON THE SAME SURFACE

NOTE - THE LIGHTING SCHEME IS TO COMPLY WITH THE ILP GUIDANCE FOR THE REDUCTION OF OBSTRUCTIVE LIGHT GN01.2021



TLP LAYOUTS FOR TENDER PURPOSES ONLY
CONSTRUCTION DRAWINGS TO BE PROVIDED
BY THE M&E CONTRACTOR.

REV	DESCRIPTION	DRN	CHK	DATE
T3	UPDATED TO SUIT ECOLOGY SCHEME & LATEST SITE PLAN	LM	PDB	02.04.26
T2	UPDATED TO SUIT LATEST ARCHITECT LAYOUT	PDB	JH	17.11.25
T1	STAGE 4 ISSUE	LM	JH	13.08.25

STAGE 4

Client
Whitbread PLC
Whitbread Court
Houghton Hall Business Park
Porz Avenue
Dunstable
LU5 5XE

Architect
Axiom Architects
1 Brooklands Yard Southover
High Street LewesEast Sussex
BN7 1HU
Tel.01273 479434
www.axiomarchitects.co.uk

Thornley & Lumb
Building Services Consultants
Head Office:
Century House, 257 Cutler Heights Lane
Bradford, West Yorkshire, BD4 9JG
Telephone: +44(0)12 7468 7755
Southern Office:
2nd Floor, 238 Tower Bridge Road
London, SE1 2UP
Telephone: +44(0)12 7468 7755
www.thornleylumb.co.uk info@thornleylumb.co.uk

TLP Project No: C8867
Project Name: Premier Inn Burgess Hill
Charles Ave, Burgess Hill RH15 9TQ

Drawing Title
Site Plan
External Lighting Layout

Engineer: LM
Checked by: JH
Drawn By: LM

Date: 26.03.25
Scale: 1:200
Size: A1

Drawing Number
Project: C8867
Originator: TLP
Volume: 00
Level: -XX-
Type: DR
Role: E
Number: 901
Revision: T3