 



• THIS DOCUMENT IS COPYRIGHT OF THE ORIGINATOR AND MUST BE TREATED AS CONFIDENTIAL.
• THIS DOCUMENT MUST NOT BE ALTERED, REPRODUCED OR DISTRIBUTED WITHOUT PRIOR WRITTEN CONSENT OF THE ORIGINATOR.
• DO NOT SCALE THIS DOCUMENT. ALL DIMENSIONS MUST BE CHECKED ON SITE PRIOR TO COMMENCEMENT OF ANY RELATED WORKS.
• THIS DOCUMENT MUST BE READ IN CONJUNCTION WITH ALL SUPPORTING DOCUMENTS PRODUCED BY THE ORIGINATOR.
• USERS OF THIS DOCUMENT ARE RESPONSIBLE FOR CHECKING WHICH REVISION IS CURRENT.

Notes & Symbols:

KEY	
	LED batten
	Spot light (spec. TBC)
	Pendant
	x
	Wall light
	LED strip lighting

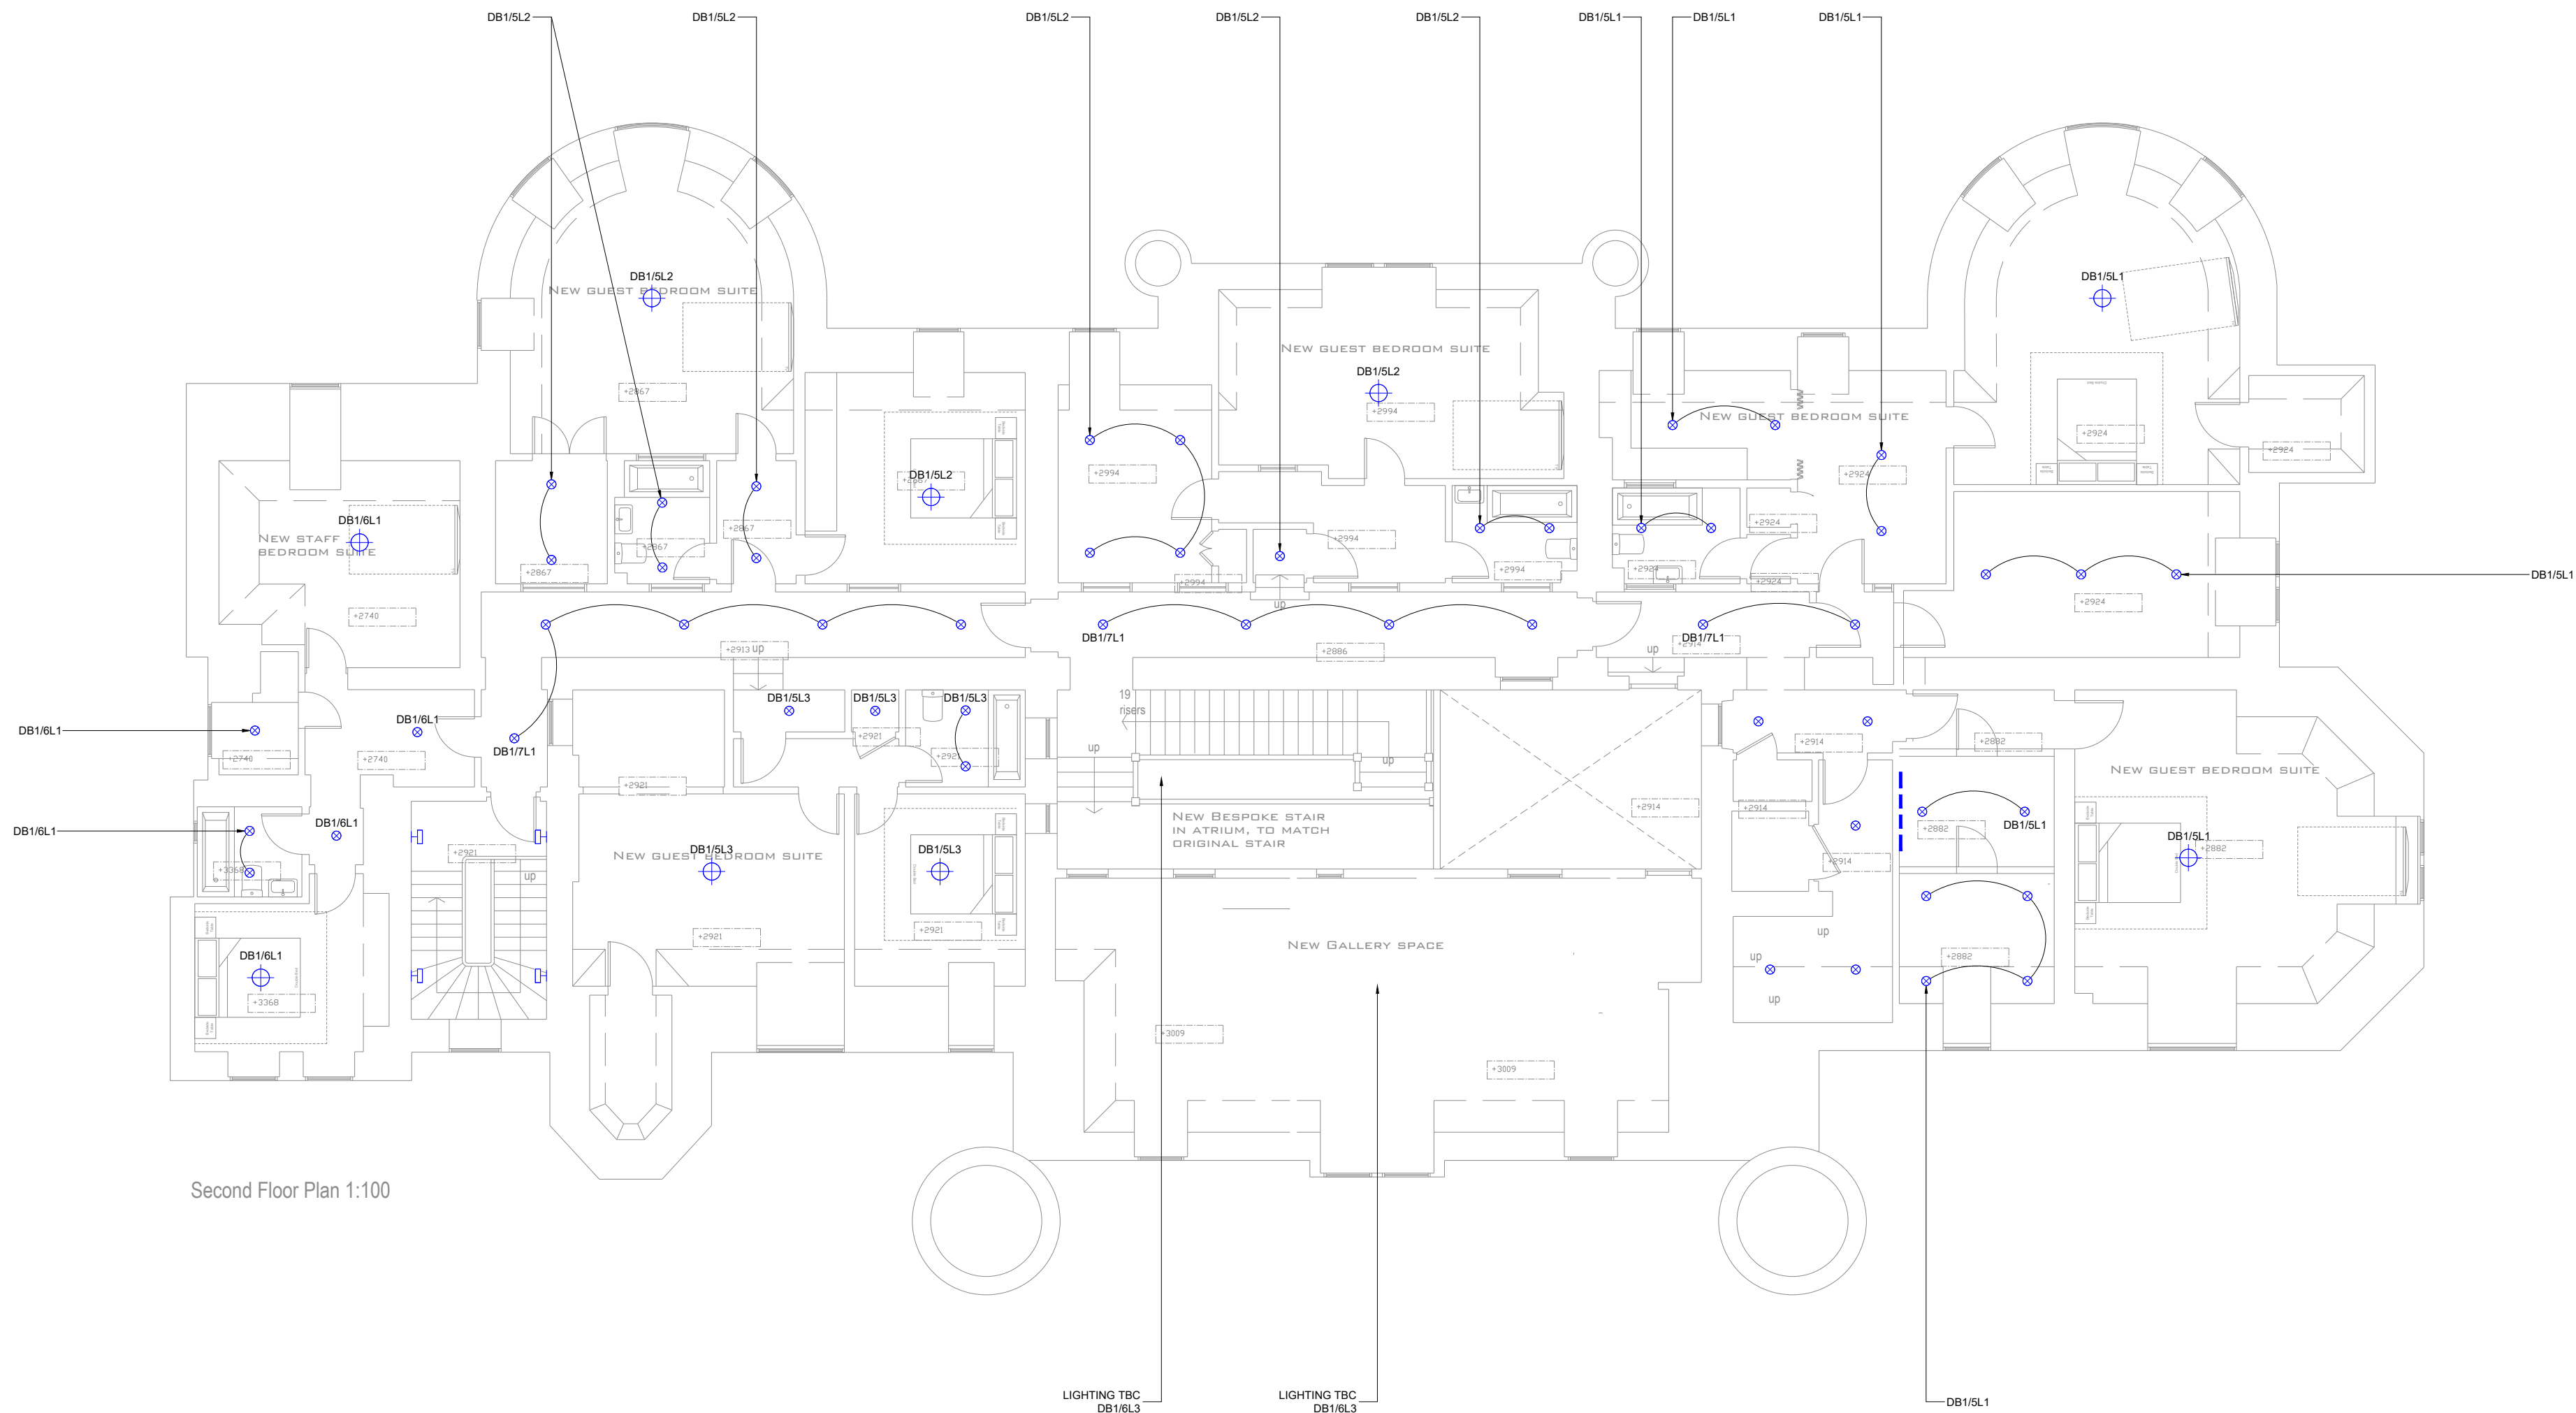

Rev.	Date.	Description.
		
Project: WYKEHURST PLACE		
Drawing Title: SECOND FLOOR LIGHTING LAYOUT		
Scale: 1:100@A1		Date: 14/04/25
Drawing Status: PROPOSED		
Drawing No. 07		Revision: 07