


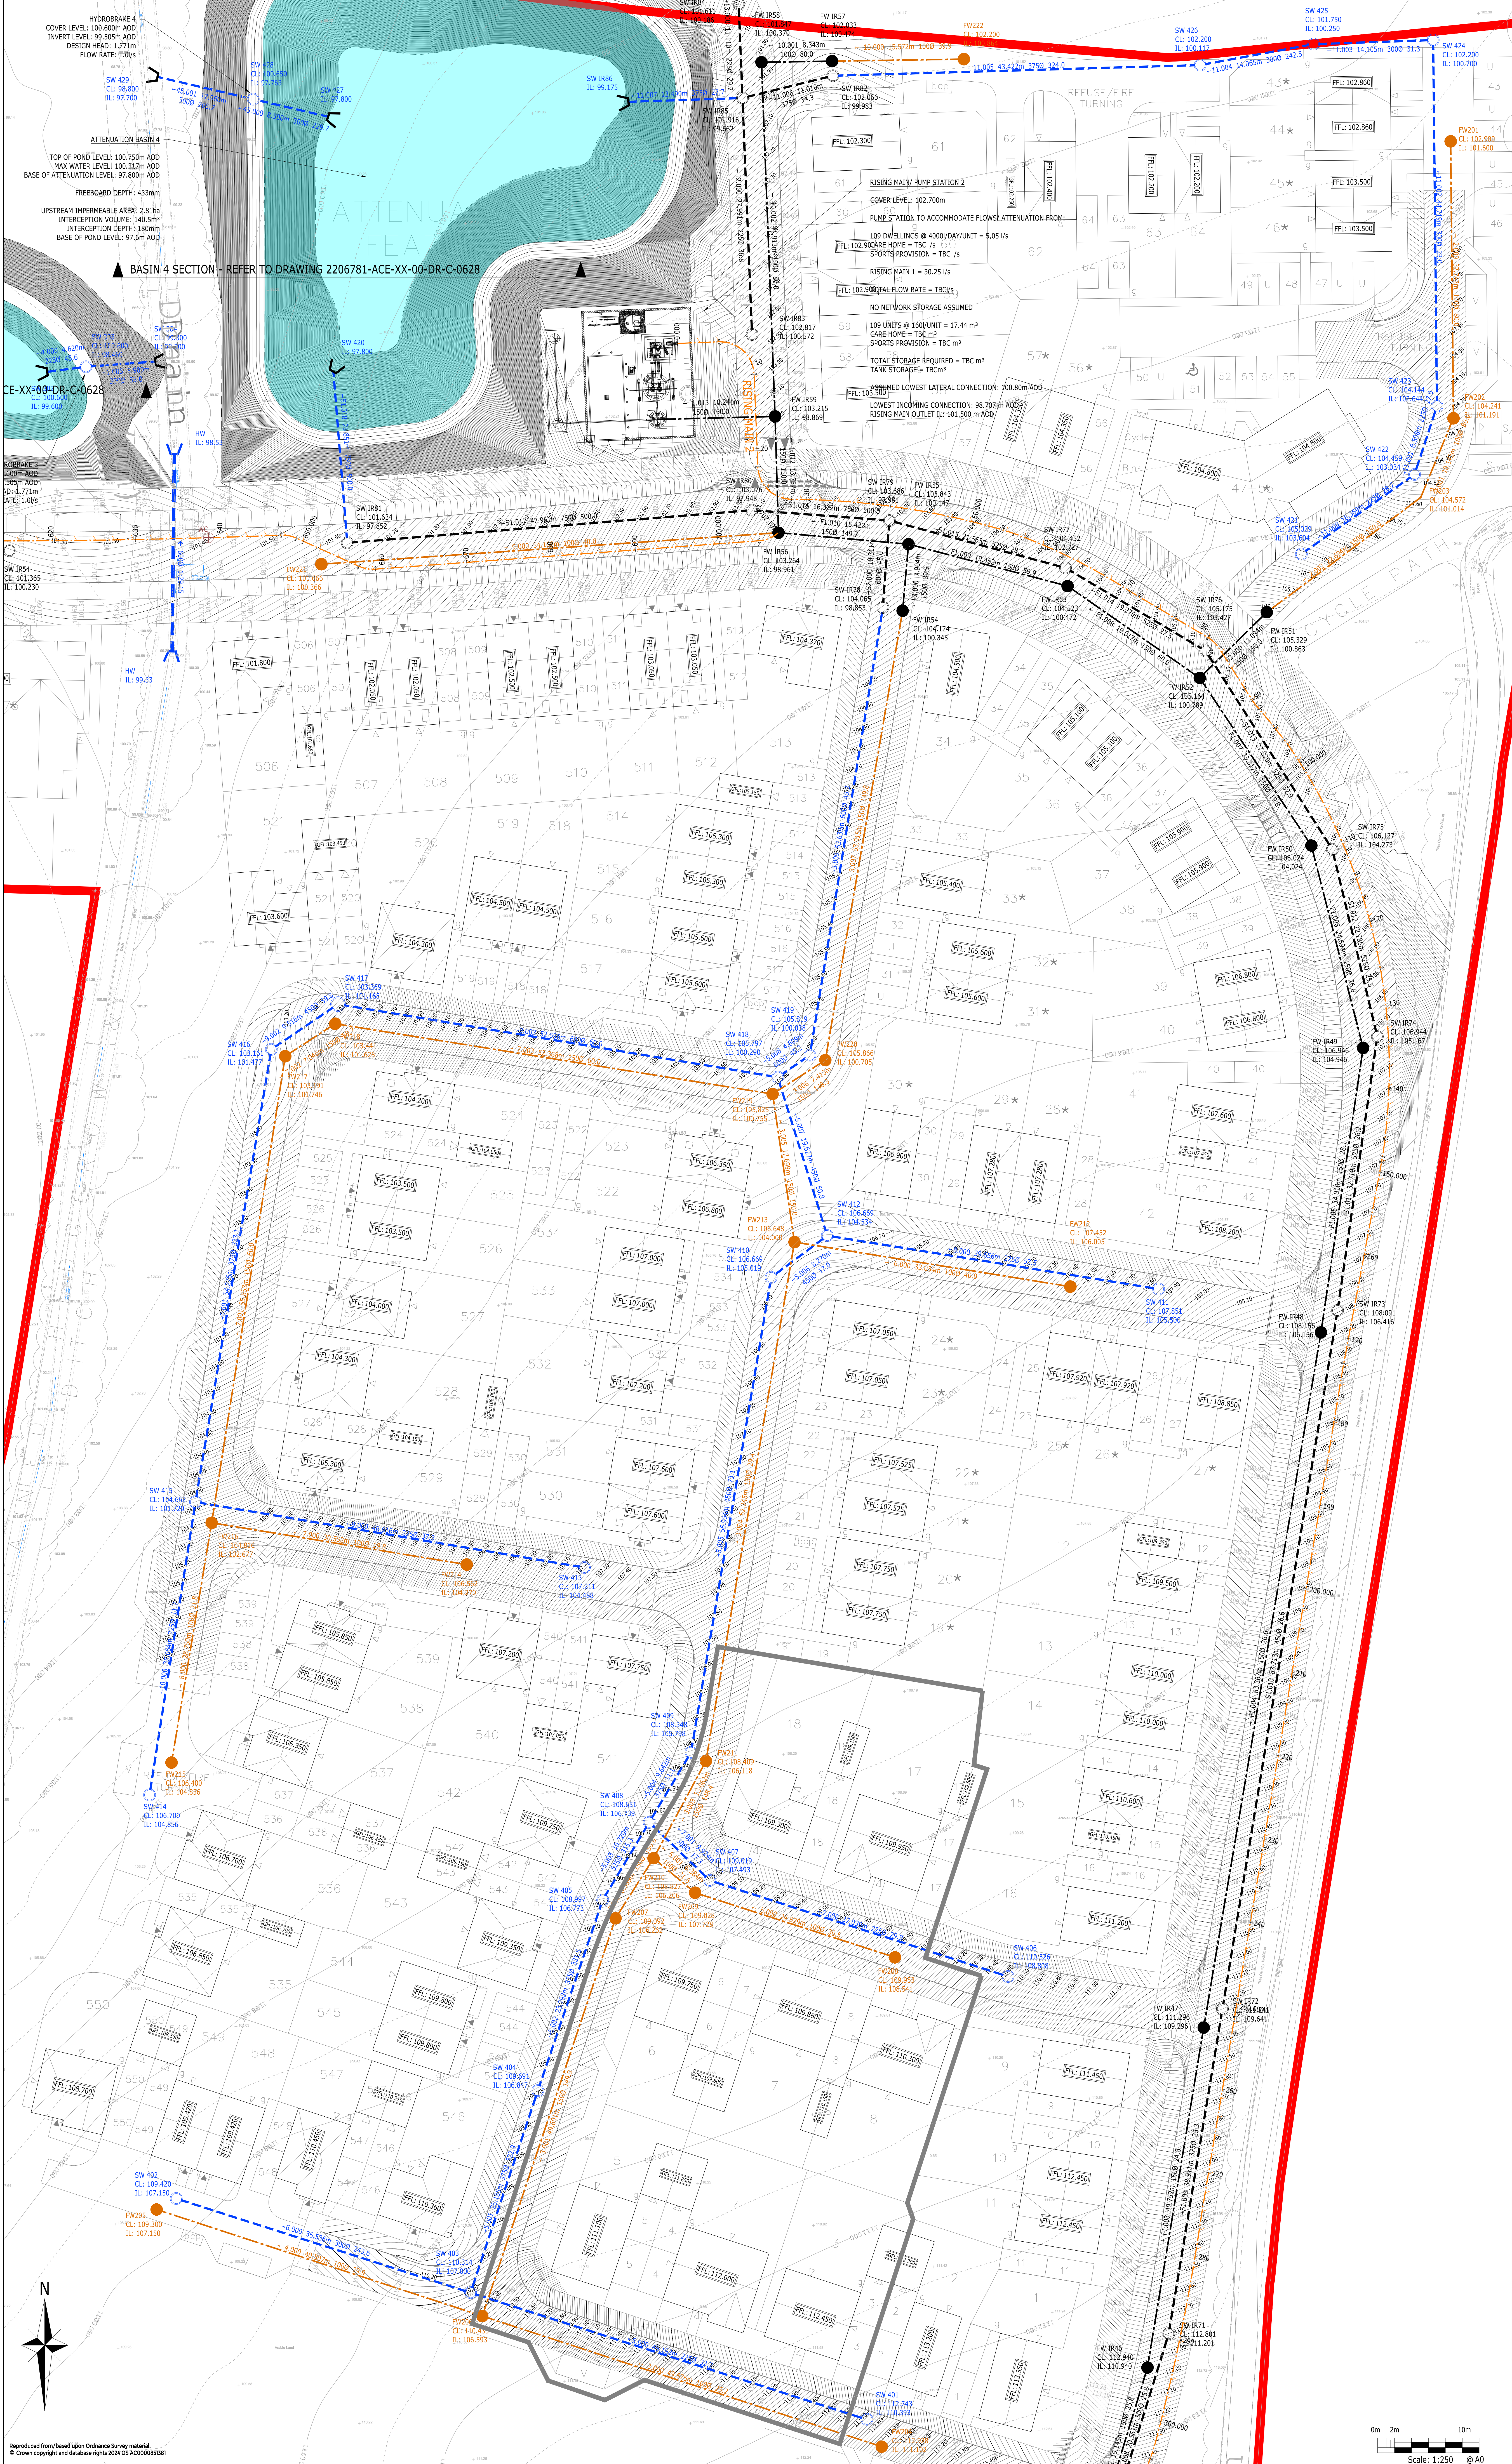

ENGINEERING KEY

- SITE BOUNDARY
- SURFACE WATER APPROVED UNDER INFRASTRUCTURE APPLICATION
- FOUL WATER APPROVED UNDER INFRASTRUCTURE APPLICATION
- PROPOSED ADAPTABLE SURFACE WATER SEWER
- PROPOSED ADAPTABLE FOUL WATER SEWER
- PROPOSED ATTENUATION CRATES
- PROPOSED DETENTION BASIN WITH POZIDRAIN UNDERLAY

NOTES:

- THIS DRAWING IS TO BE READ IN CONJUNCTION WITH THE RELEVANT SPECIFICATION, INC. RISK ASSESSMENTS AND ALL OTHER RELATED DRAWINGS ISSUED BY THE ENGINEER.
- DO NOT SCALE FROM THIS DRAWING. WORK FROM FIGURED DIMENSIONS ONLY.
- ALL DIMENSIONS SHOWN ON THIS DRAWING ARE IN METRES UNLESS OTHERWISE STATED.
- ALL DIMENSIONING, LEVELS AND SURVEY GRID CO-ORDINATES ARE TO BE CHECKED ON SITE AND THE ENGINEER NOTIFIED IMMEDIATELY OF ANY DISCREPANCIES PRIOR TO THE COMMENCEMENT OF THE WORKS.
- NO DEVIATION FROM THE DETAILS SHOWN ON THIS DRAWING IS PERMITTED WITHOUT PRIOR PERMISSION FROM THE ENGINEER.
- ANY WORKS OUTSIDE RED SITE BOUNDARY ARE FOR INFORMATION PURPOSES ONLY UNLESS SPECIFICALLY NOTED. ALL WORKS OUTSIDE THE SITE BOUNDARY WILL BE UNDERTAKEN BY OTHERS UNDER A SEPARATE CONTRACT.

KEYPLAN

P1	UPDATED BASED ON LIAISON COMMENTS	AMC	AMC	MR	23-03-24
P2	UPDATED TO SUIT NEW LAYOUT	ADS	CC	AD	18-02-25
P1	FIRST ISSUE	AMC	AMC	AMC	28-11-25

Rev	Description	Dwn	Chk	App	Date

PRELIMINARY

NOT YET APPROVED

ARDENT CONSULTING ENGINEERS

AN EMPLOYEE OWNED COMPANY

Third Floor
The Hallmark Building
52-56 Leadenhall Street
London
EC3M 5JE

Tel: 020 7680 4088
Web: www.ardent-ce.co.uk
E-mail: enquiries@ardent-ce.co.uk

Client

VISTRY SOUTH EAST

Project Title:

IMBERHORNE FARM, EAST GRINSTEAD

Drawing Title:

PROPOSED DRAINAGE SHEET 6

Drawn by	Checked by	Approved by	Revision
AMC	AMC	AD	

Scale: 1:250 @ A0 Date: 28-11-25

Drawing Number: **2206781-ACE-XX-XX-DR-C-0626**

Scale: 1:250 @ A0

0m 2m 10m

Reproduced from/based upon Ordnance Survey material.
© Crown copyright and database rights 2024 OS AC0000801881

File location: y:\wvnet\projects\2206781 - Imberhorne Farm, new grassland for updated technical and landscaping\2206781-XX-XX-DR-C-0626 - Drainage layout.dwg