


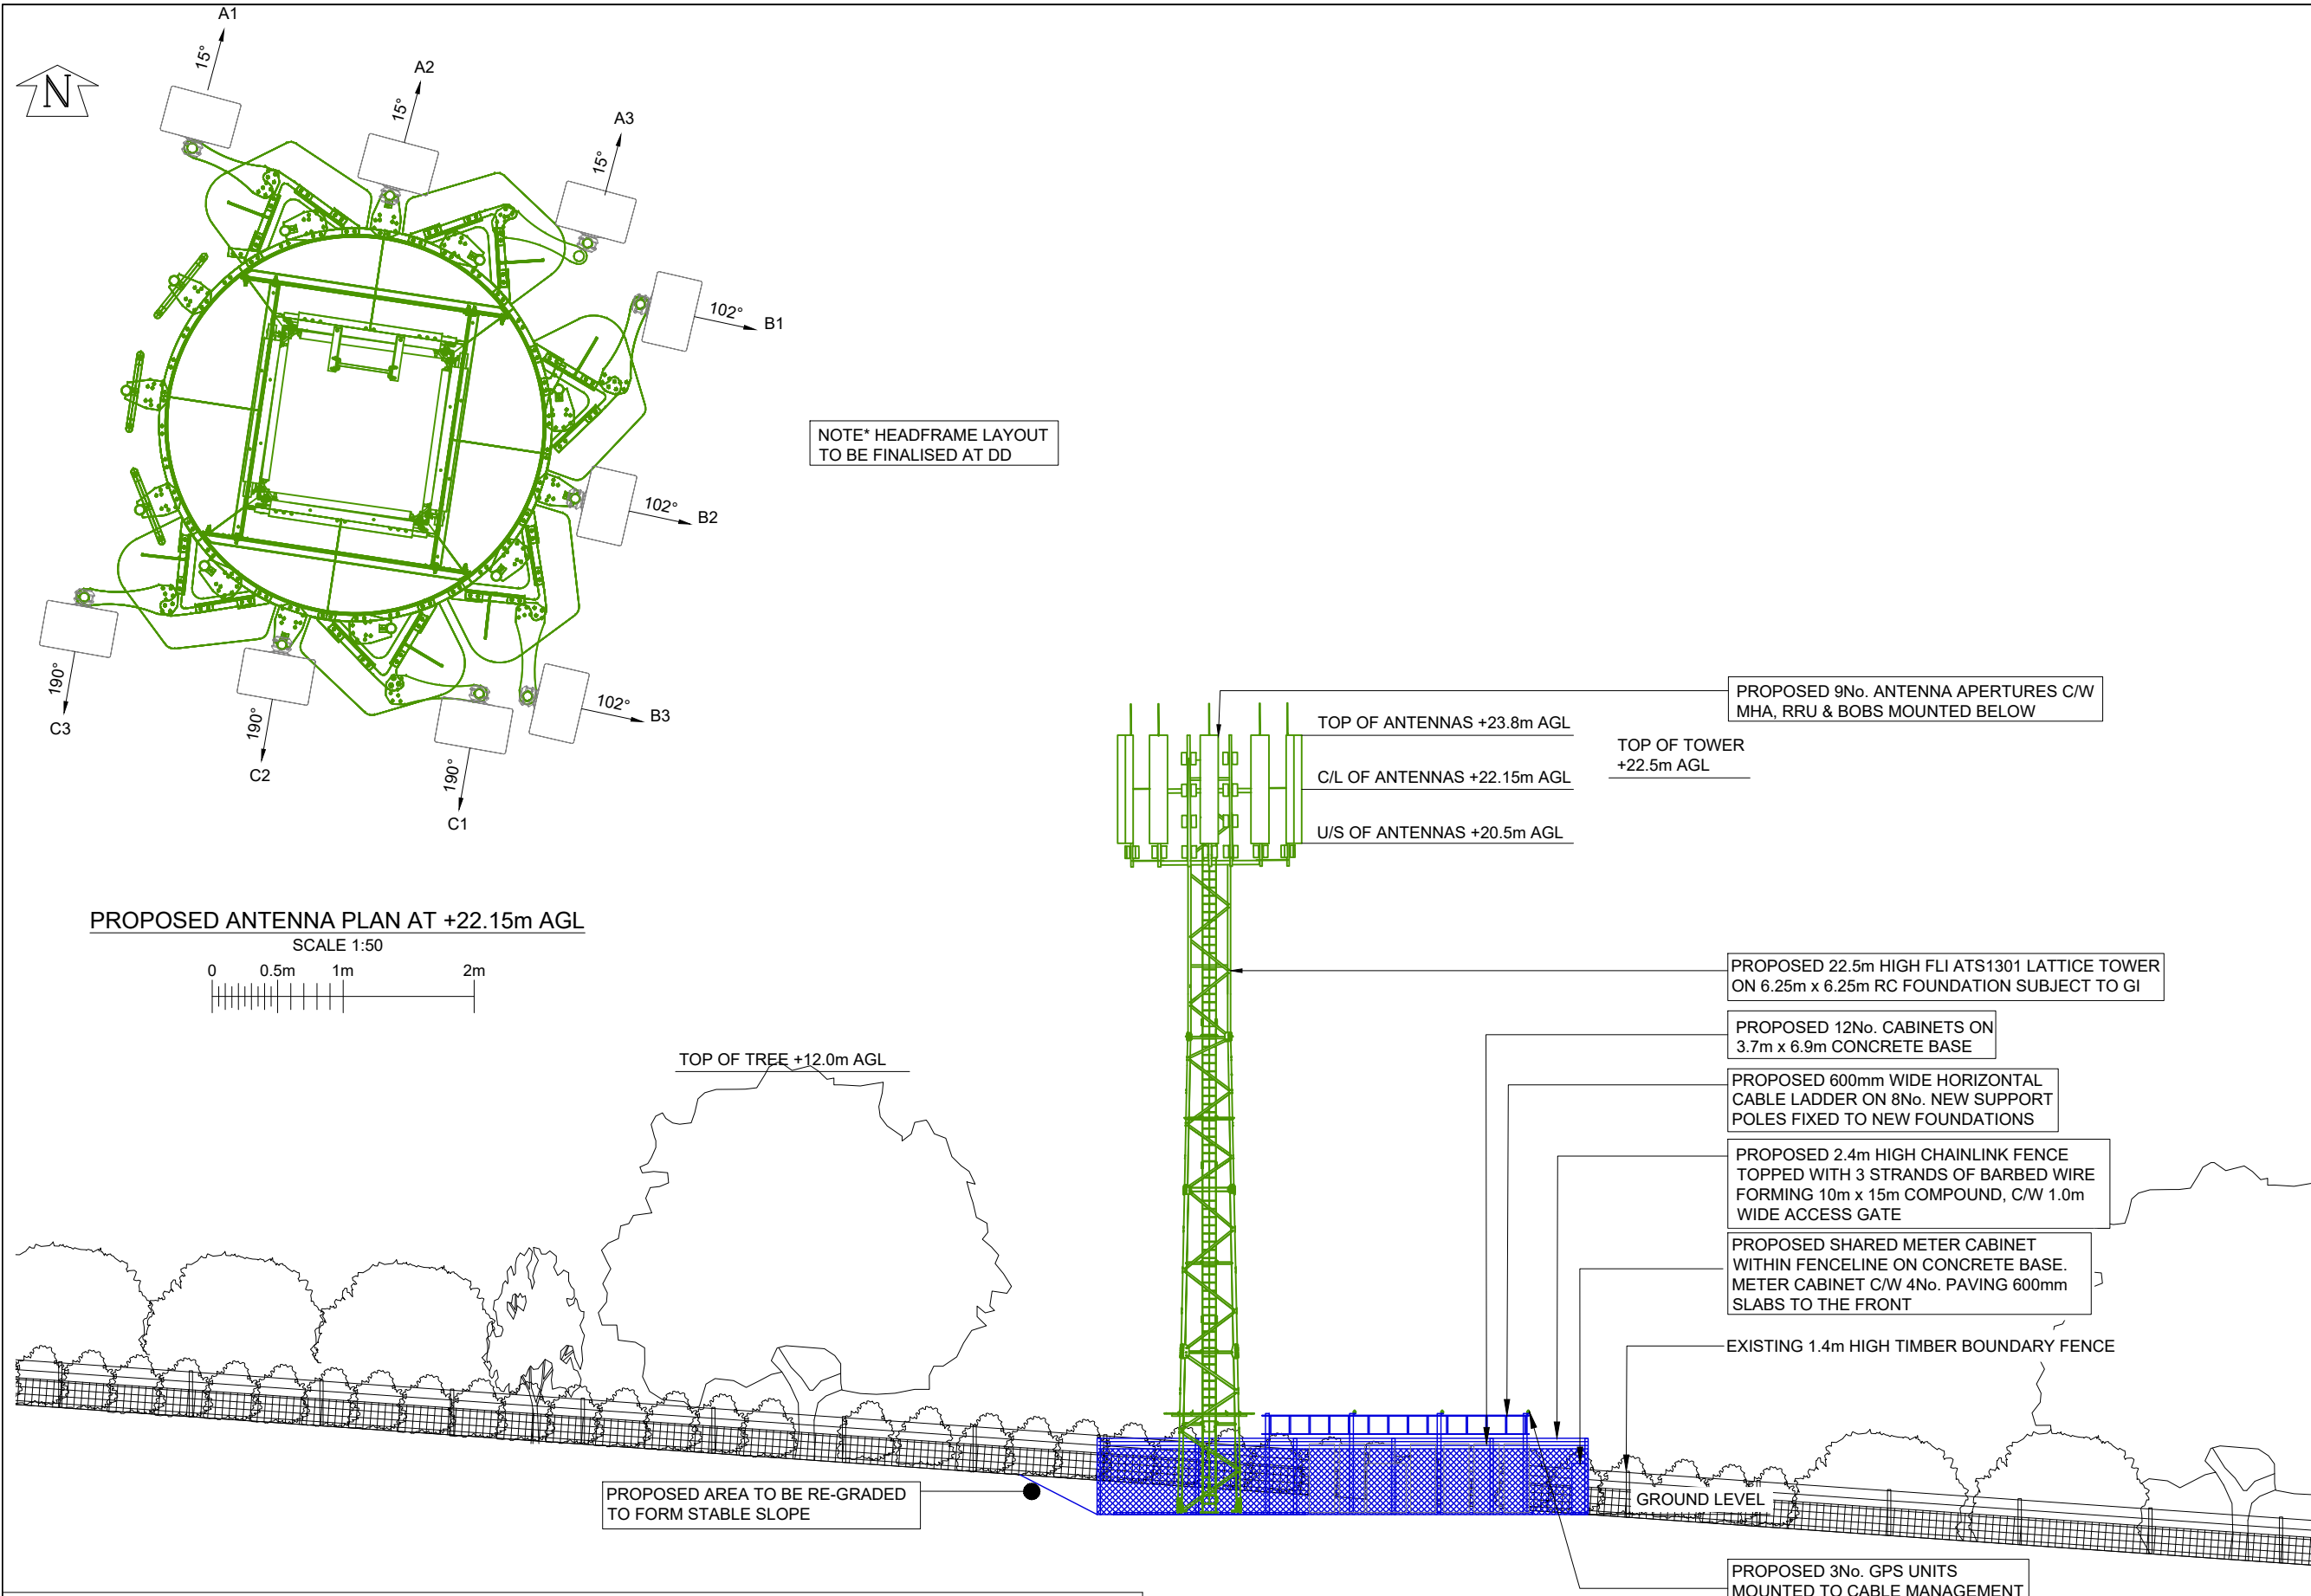

EQUIPMENT CABINET SCHEDULE							
ID No	EQUIPMENT	MANUFACTURER	DIMENSIONS (WxDxH) mm	COLOUR	LOCATION	STATUS	COMMENTS
CAB 1	PSU CABINET (x2)	TBC	770x770x2100	GREY	PAD FOUNDATION	PROPOSED	
CAB 2	TX CABINET (x2)	TBC	1500x600x1200	GREY	PAD FOUNDATION	PROPOSED	
CAB 3	RADIO CABINET (x7)	TBC	770x770x2100	GREY	PAD FOUNDATION	PROPOSED	
CAB 4	POWER & TX CAB (x1)	TBC	770x770x2100	GREY	PAD FOUNDATION	PROPOSED	
CAB 5	SMC (x1)	TBC	1873x560x588	GREY	FENCELINE	PROPOSED	

©2020 Cellnex
All rights reserved. No part of this publication may be reproduced, stored in a retrieval system or transmitted in any form or by any means (Electronic, Mechanical, Photocopying, Recording or otherwise), without the prior written consent of the Company.

NOTES

CELL No.	S5_11e			
4	COL.MOD.UK.0002684 BNG REMOVED	06/05/25	CIR	CIR
3	COL.MOD.UK.0002684 PLANNING AMENDS	31/10/24	CIR	CIR
2	COL.MOD.UK.0002684 COMPOUND MOVED	23/03/23	RST	MK
1	PLANNING	27/04/22	RTL	RST
ISS	REVISION	DATE	DRN	APP

cellnex
driving telecom connectivity

CELLNEX UK
R+, 4TH FLOOR, 2 BLAGRAVE STREET, READING, RG1 1AZ
Tel. 020 4526 8553

SITE No **S5-11**
LAND ADJACENT TO ROCKY LANE
ARABLE FIELD ADJACENT TO ROCKY LANE
SANDROCKS
ANSTY AND STAPLEFIELD
RH16 4TW

NGR **TQ 32514 22168**
OS GRID **532514 122168**

TITLE
**WEST ELEVATION
PROPOSED**

SCALE **1:200 UNO**

DRAWN	GV	31/03/22
APPROVED	CIR	06/05/25

DRG No.	Sheet 1 of 1	Rev
S5-11-00-003-MD004		4