


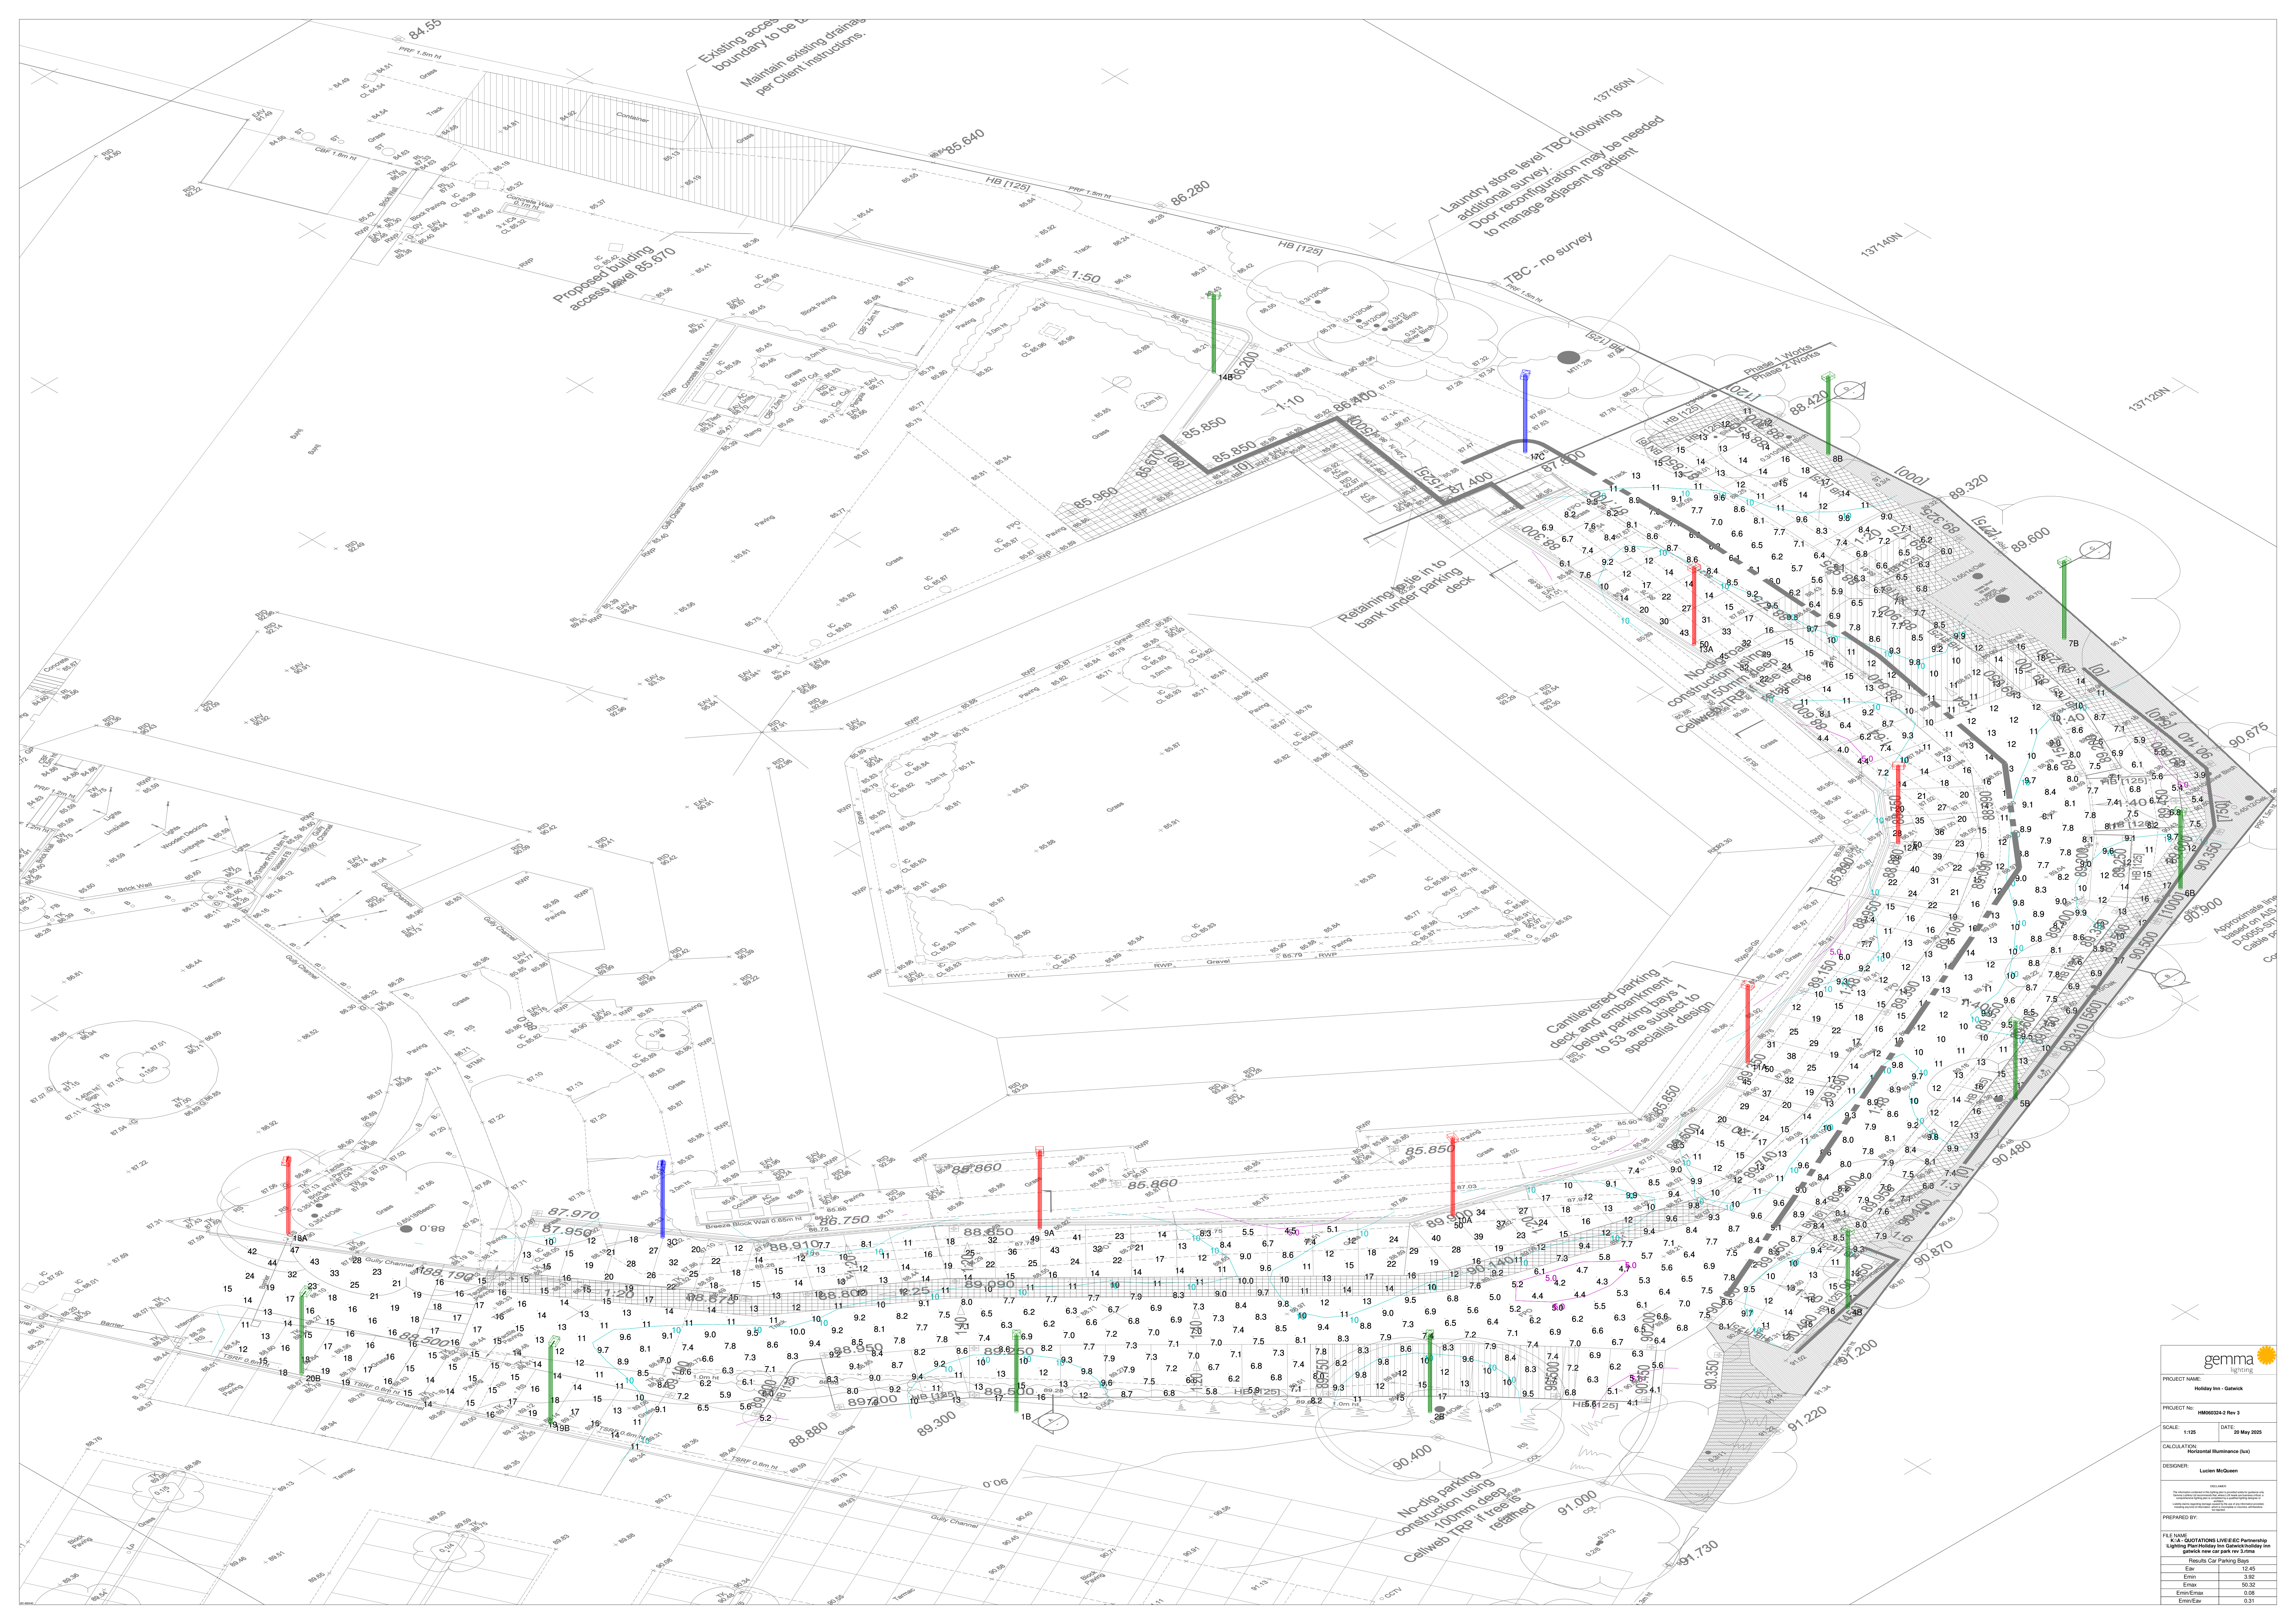

PROJECT NAME:
Holiday Inn - Garsick

PROJECT No: HMM00254-2 Rev 3

SCALE: 1:125

DATE: 20 May 2025

CALCULATION:
Horizontal Illuminance (lux)

DESIGNER:
Lucien McQueen

FILE NAME:
K.A. - QUOTATIONS LIVE:EC Partnership
Lighting Plan Holiday Inn Garsick Building 1m
Results Car Parking Bay 1

PREPARED BY:

Eav	12.45
Emm	3.92
Emm/Emax	0.32
Emm/Emax	0.08
Emm/Eav	0.31