

Notes

 
Do not scale from this drawing except for planning purposes. All dimensions must be checked on site before any work begins.

All goods, materials, and workmanship must comply with current Building Regulations, British Standards, and relevant Codes of Practice.

© Ecotecture Ecological Design Limited.

All rights reserved. This drawing and its design are the property of Ecotecture Ecological Design Limited and may not be reproduced, copied, or used for any purpose other than that for which they were issued, without prior written consent.

Drawing to be printed A1



Scale 1-100


FIRE ALARM SYSTEM LEGEND

- MANUAL CALLPOINT
- SMOKE DETECTOR
- SMOKE DETECTOR C.W. SOUNDER BASE
- HEAT DETECTOR
- HEAT DETECTOR C.W. SOUNDER BASE
- FIRE ALARM CONTROL PANEL

Install carbon monoxide alarms in appropriate locations on each level where fuel-burning appliances are present, including near fireplaces, the boiler cupboard and staff sleeping areas.

All detectors, alarms and call points to be battery-operated, surface-mounted and reversible. No penetrations to historic structure.

All new fire exit signage and emergency lighting units (ELU) to be battery-operated, surface-mounted and reversible. No penetrations to historic structure.

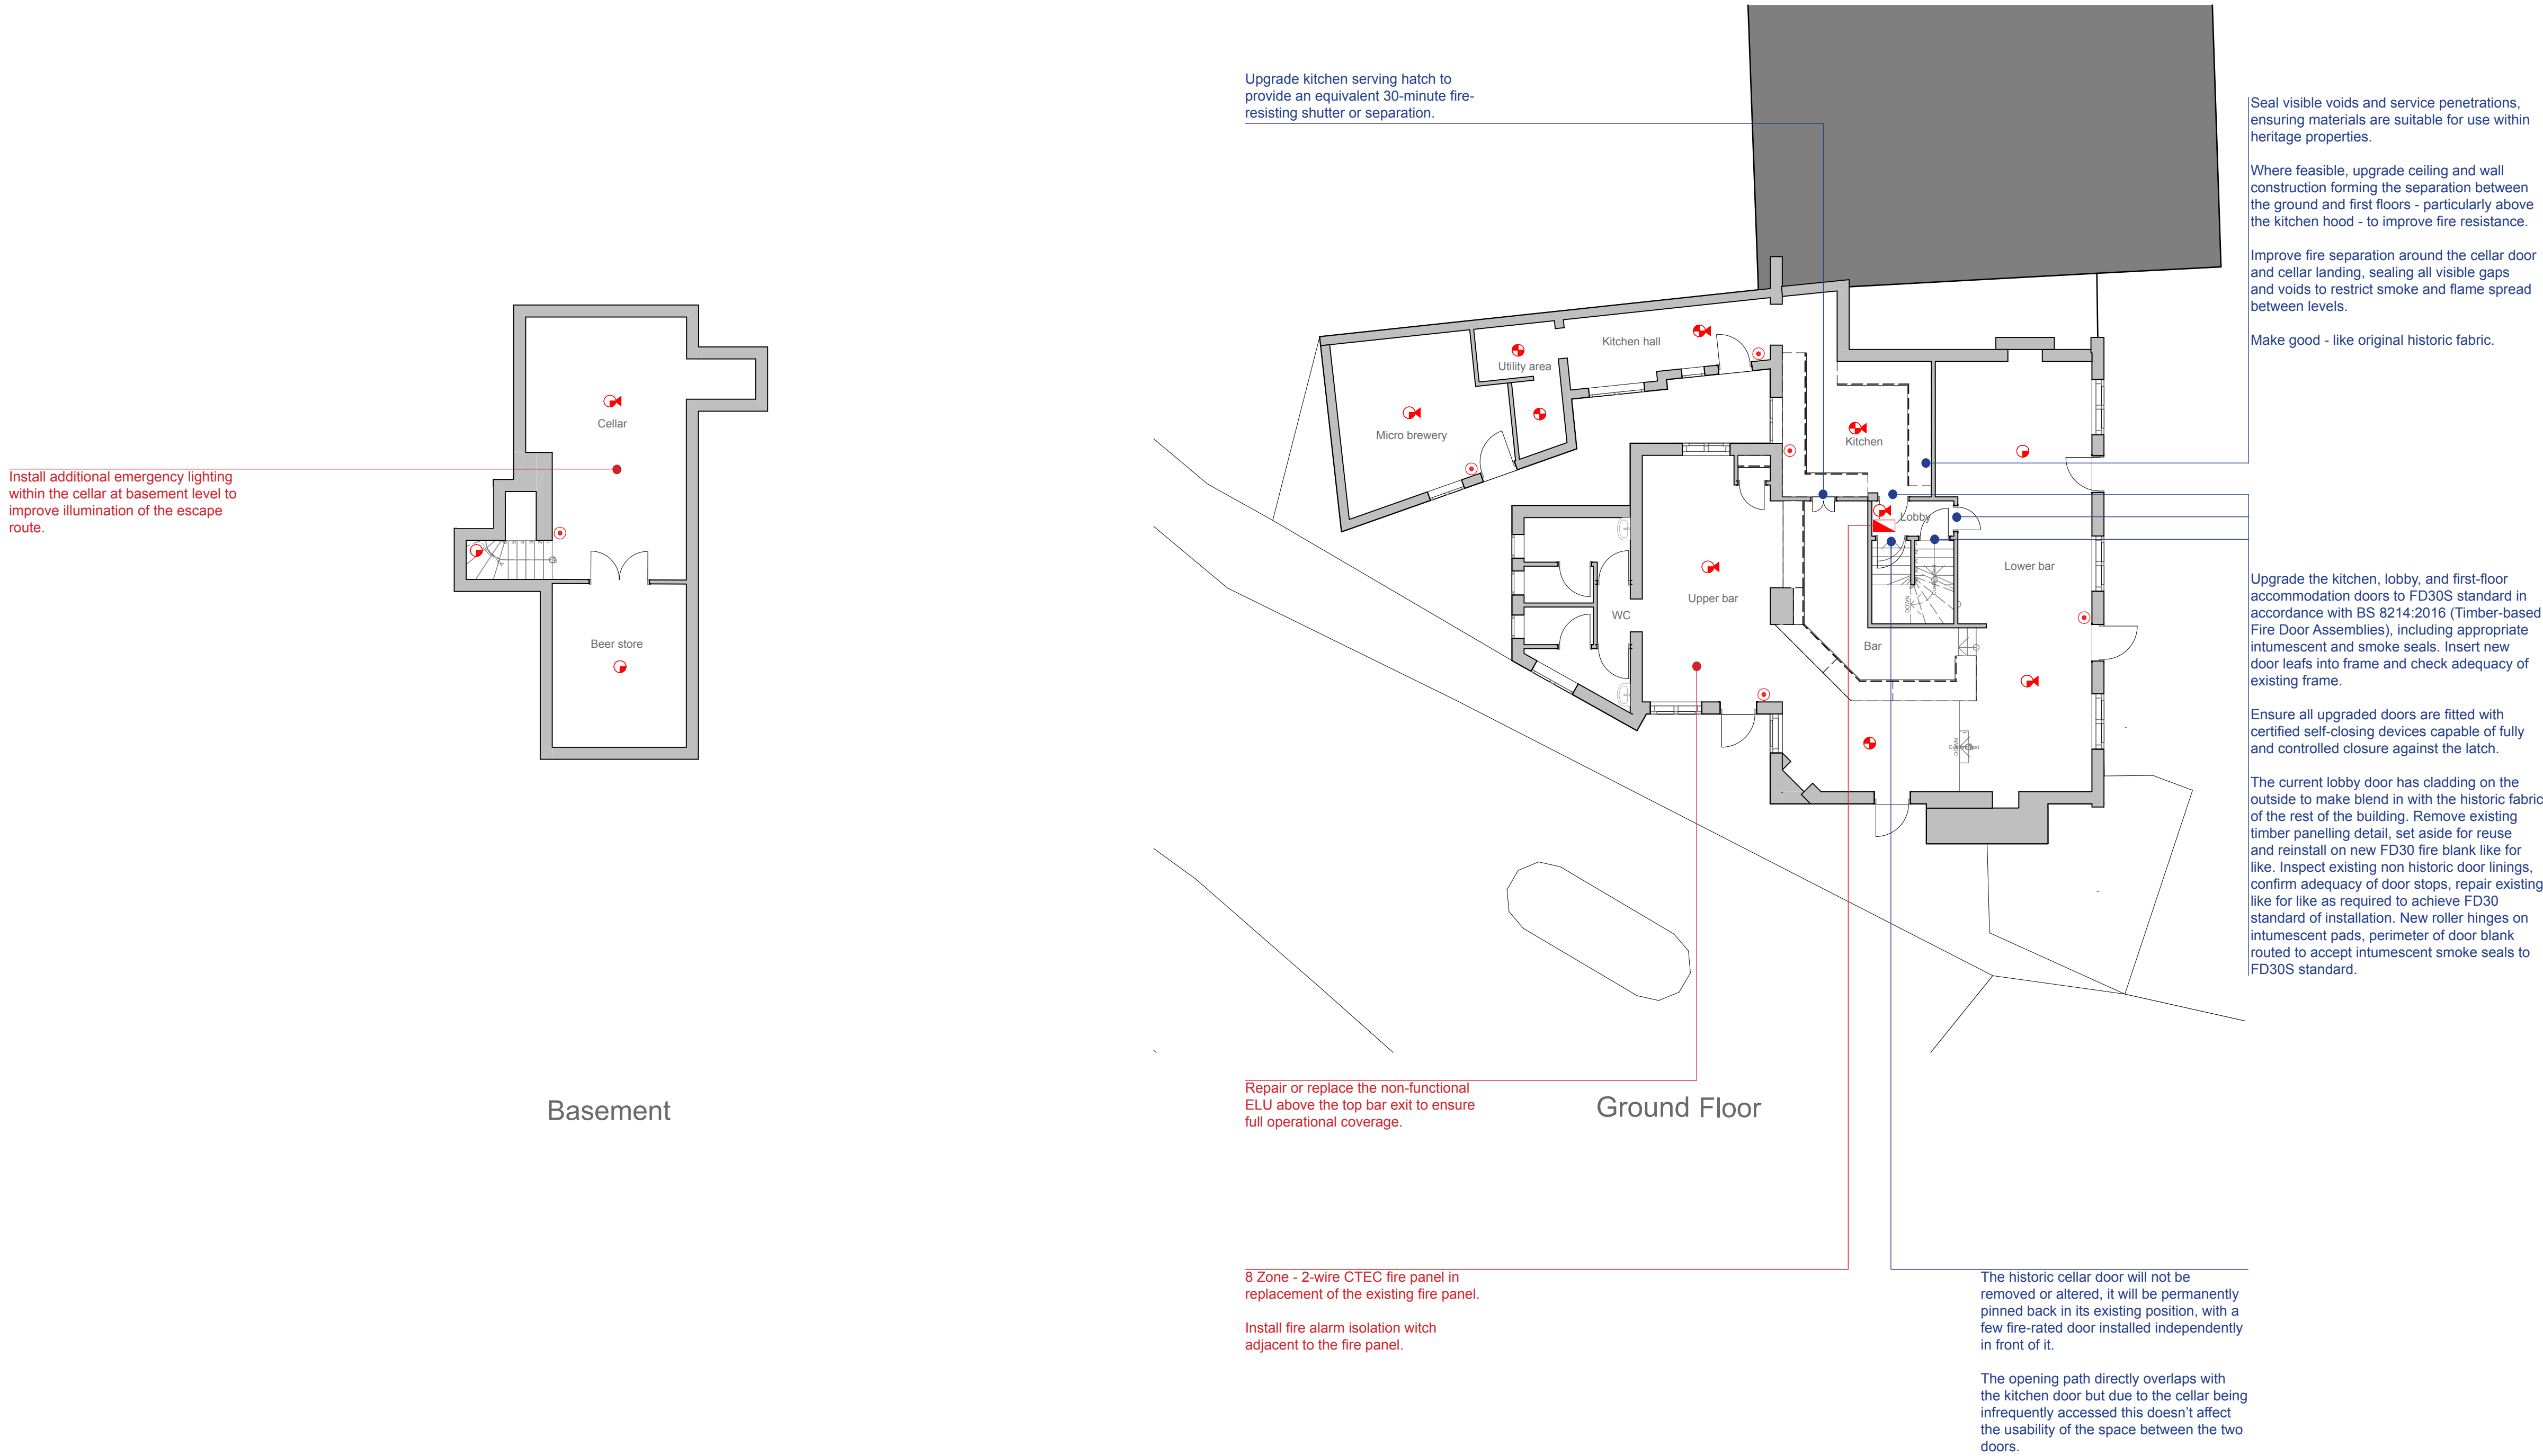

RevID	Transmitted By	Transmittal Set Date	Layout Comment
-------	----------------	----------------------	----------------

PLANNING



01444 416745	info@ecotecture.co.uk www.ecotecture.co.uk
31 Sussex Road West Sussex	Haywards Heath RH16 4DZ
Client:	Half Moon Community Pub

Address:	The Half Moon Inn, Balcombe, Balcombe, RH17 6PA
----------	--

Description: Proposed Plans

Scale: 1:100	Date: Jan 26
Drawn: JM	Checked: JS

Drawing No: 868 /301 A