


Unit Type ID	Count	Status	Mounting Height	Column Type	Column Material	Column Colour	Installation Type	Root Length	Mounting	Luminaire	Optic Setting	Output (klm)	Colour Temperature	Wattage	Luminaire Weight	Windage	Control Unit	Switching Unit	Isolator	Luminaire Elexon Code	Control Gear Elexon Code
A	69	Proposed column	6 metres	Stepped tubular	Galvanised steel	BS00A01 (Silver)	Planted	Factory standard	Post top	Urbis Schröder Lighting Axia 3.1	5266 (with rear louvre)	2.59 (16 no. LEDs)	Warm white (727)	26W (@500mA)	3.6kg	0.03m²	Electronic DALI enabled ballast	Mayflower External node	Tofco DPI range	42 0026 0000 100	98 0001 0010 100
B	32	Proposed column	6 metres	Stepped tubular	Galvanised steel	BS00A01 (Silver)	Planted	Factory standard	Post top	Urbis Schröder Lighting Axia 3.1	5267 (with rear louvre)	2.73 (16 no. LEDs)	Warm white (727)	31W (@500mA)	3.6kg	0.03m²	Electronic DALI enabled ballast	Mayflower External node	Tofco DPI range	42 0031 0000 100	98 0001 0010 100
C	9	Proposed column	6 metres	Stepped tubular	Galvanised steel	BS00A01 (Silver)	Planted	Factory standard	Post top	Urbis Schröder Lighting Axia 3.1	5296 (with rear louvre)	1.62 (16 no. LEDs)	Warm white (727)	16W (@300mA)	3.6kg	0.03m²	Electronic DALI enabled ballast	Mayflower External node	Tofco DPI range	42 0016 0000 100	98 0001 0010 100
D	10	Proposed column	6 metres	Mid-hinged raise and lower stepped tubular	Galvanised steel	BS00A01 (Silver)	Planted	Factory standard	Post top	Urbis Schröder Lighting Axia 3.1	5296 (with rear louvres)	0.81 (8 no. LEDs)	Warm white (727)	8W (@300mA)	3.6kg	0.03m²	Electronic DALI enabled ballast	Mayflower External Node	Tofco DPI range	42 0008 0000 100	98 0001 0010 100

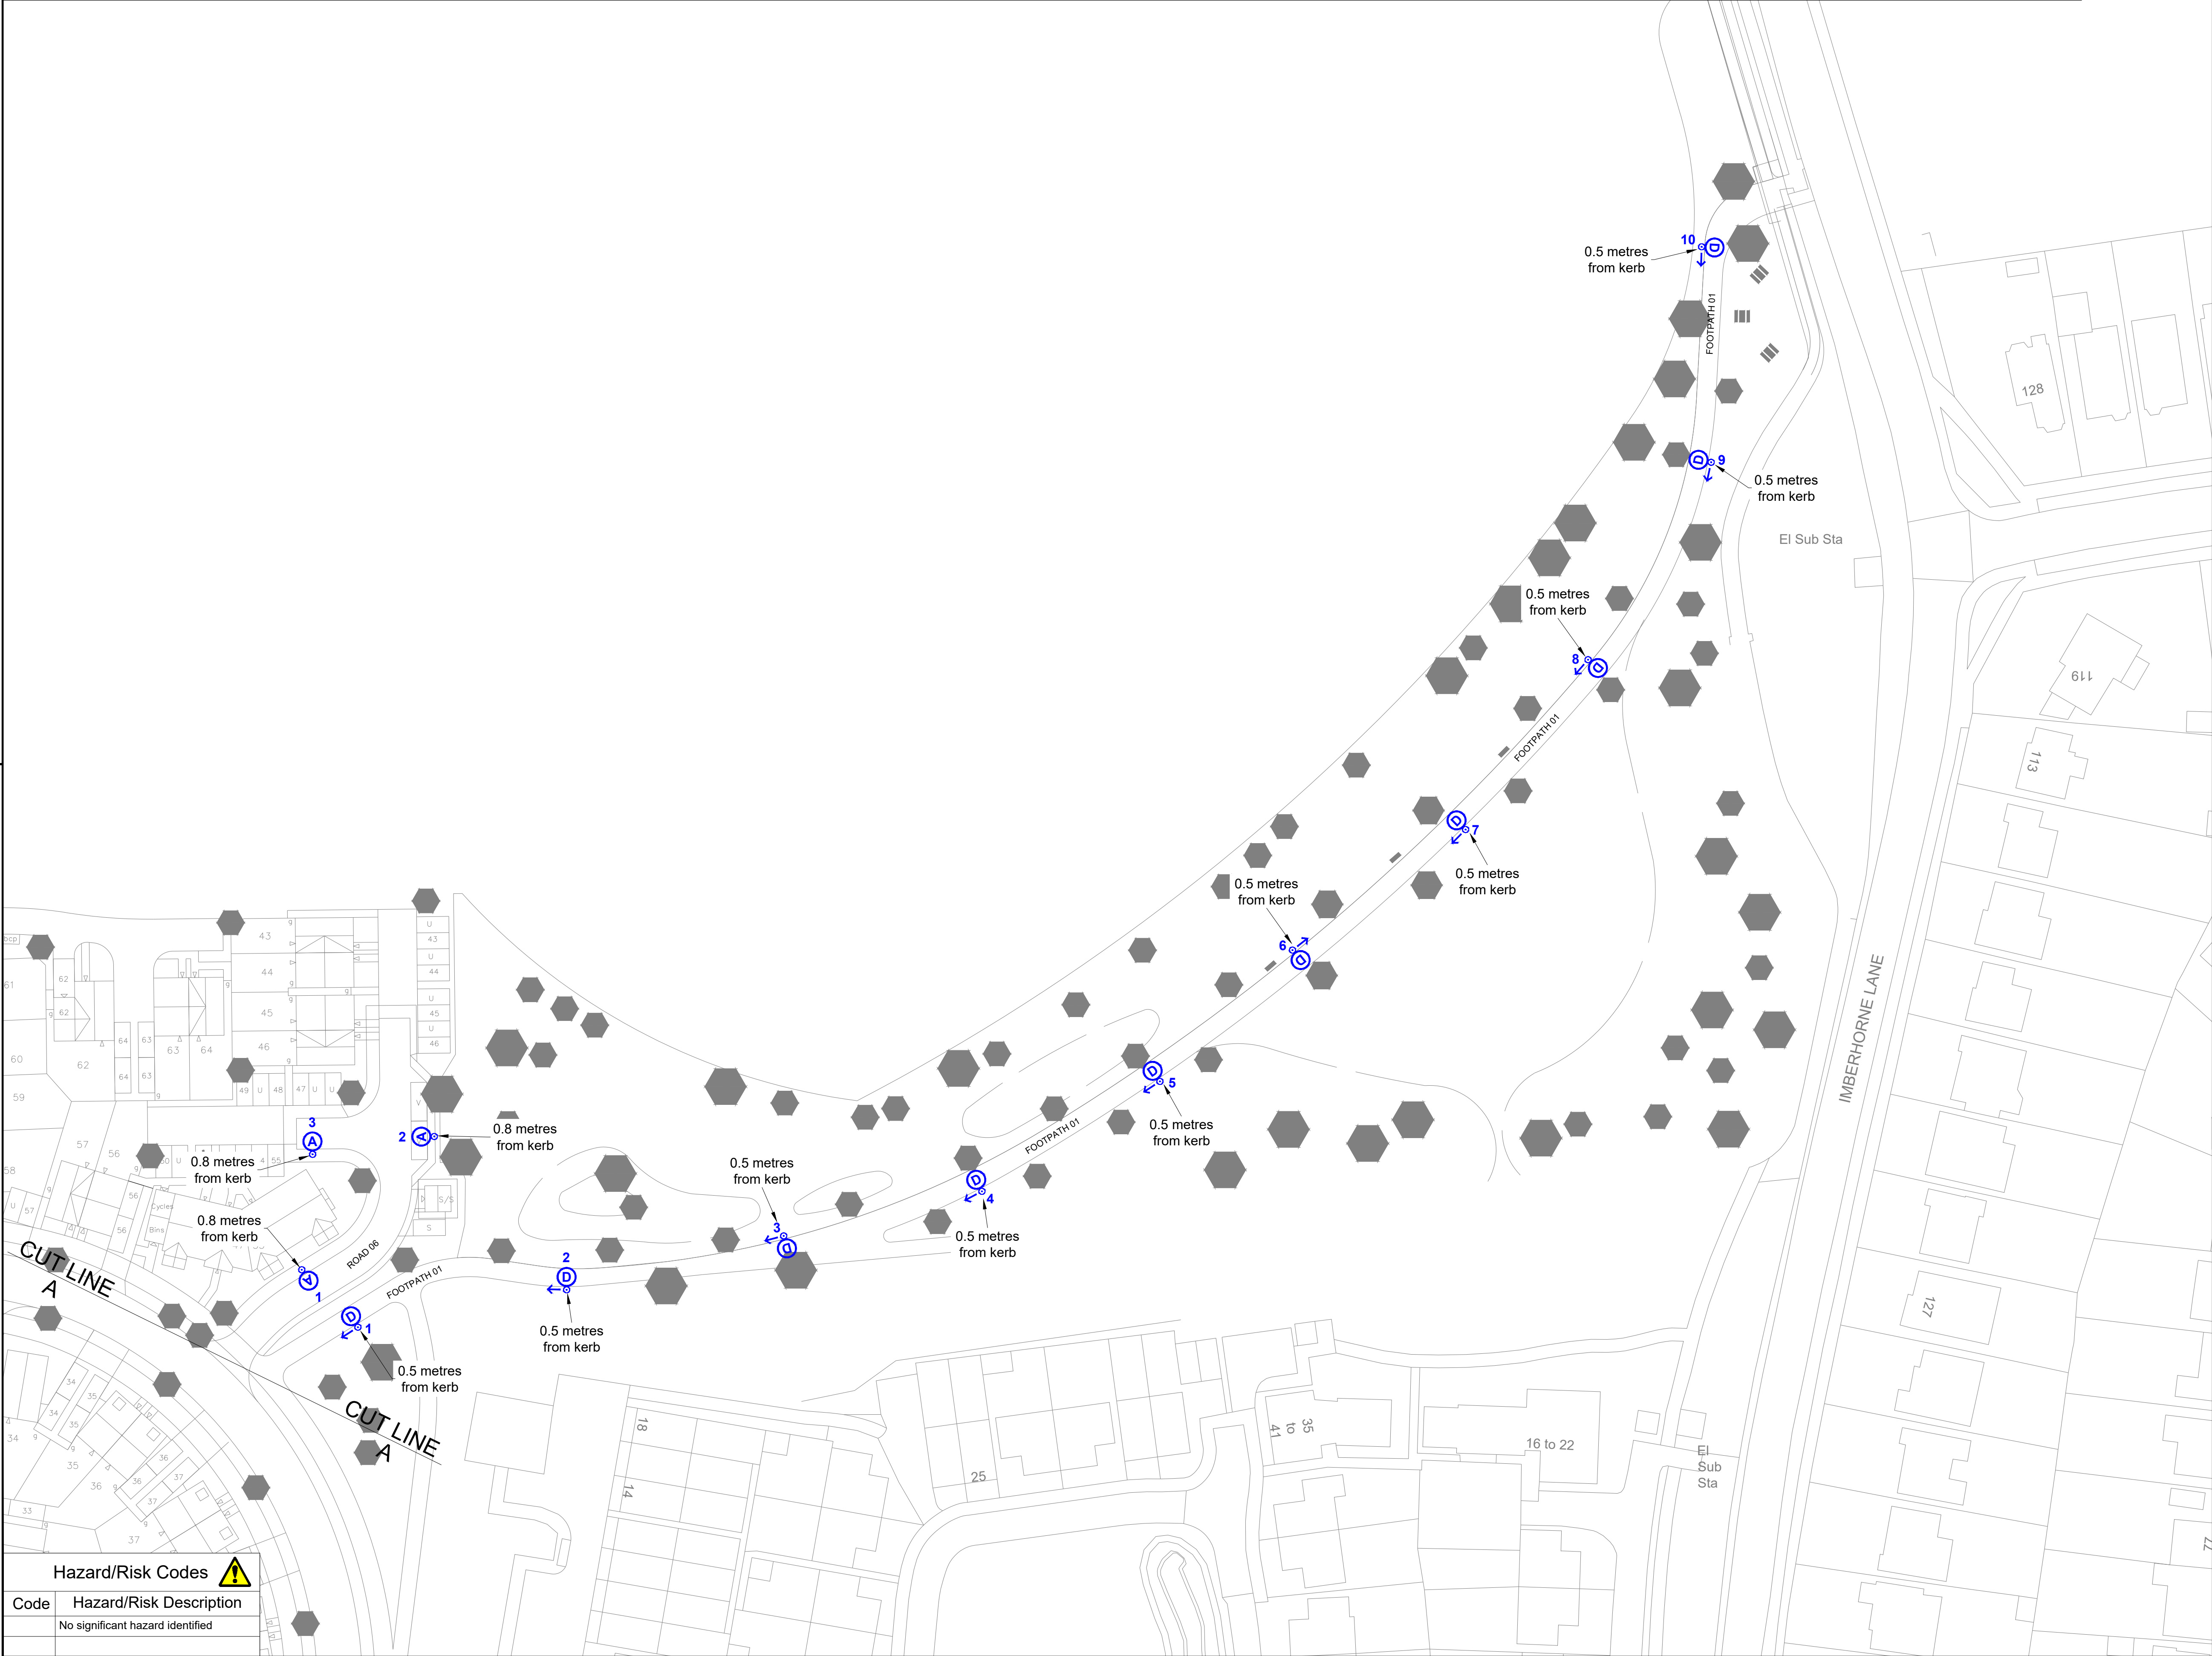

Hazard/Risk Codes 	
Code	Hazard/Risk Description
	No significant hazard identified

Key

 Proposed street lighting column (Unit Type ID displayed inside symbol. Unit reference number displayed outside symbol).

 Proposed raise and lower street lighting column (Unit Type ID displayed inside symbol. Unit reference number displayed outside symbol).

 Highway boundary

 Easement - easement size shall be a minimum 1.0m radius of the column and connected to the highway.

Lighting Classes (BS5489-1:2020)		
All roads	P4	Part-night
Footpath	P5	Part-night

- Notes
- Do not scale from drawing if not printed at original paper size.
 - All street lighting equipment and works to be carried out in accordance with current West Sussex County Council specification. All references of standard drawings; refer to West Sussex County Council specification document unless otherwise stated.
 - Any inaccuracies are to be reported to the Overseeing Organisation immediately.
 - Contractor to confirm position of statutory undertakers plant before commencement of the works. For statutory undertaker's information visit www.linsearchbeforeudig.co.uk.
 - During works all traffic management to be in accordance with Chapter 8 of the Traffic Signs Manual.
 - Columns are to be designed in accordance with BSEN40 and PD6547.
 - Lighting columns to be fed by DNO supply unless otherwise shown.
 - The contractor shall liaise with the DNO in relation to the programming and coordination of any works associated with the connection and disconnection of street lighting equipment.
 - It should be assumed by the contractor that not all services have been identified during the design period. It is the responsibility of the contractor to ensure that all unidentified services are carefully located and reported.
 - Each luminaire to be fitted with a 7 pin NEMA socket.
 - Maintenance numbers as shown on the drawing are to be confirmed by WSCC.
 - Columns to be numbered using adhesive labels suitable for exterior use. Letters and numerals shall be 50mm high black on a white background.
 - Columns are to be factory painted
 - One Mayflower Complete lighting control DALI sub-master unit to be installed to control nodes and link central management system.
 - Prior to the installation of Mayflower nodes & submasters, all luminaires to be fitted with NEMA 35/18 all night photocells.
 - All apparatus are to be new at the time of installation and be supported by relevant manufacturer's guarantees.
 - All apparatus shall be sited so as to minimise, in so far as is reasonable and practical, nuisance, danger and obstruction to all residents, businesses and users of the highway.
 - All illuminated apparatus must be installed and tested in compliance with BS7671 at the time of adoption.
 - Trees or any other foliage on the site must not interfere with the lighting.
 - This detailed design has been prepared in accordance with the HEA-HEMSA guidance note - CDM2015 regulations, issue 1.1, dated 09/04/15 Procedure 3: information has been supplied by the client or another Designer or the Principal Designer which forms the basis of this lighting scheme design and includes the hazards identified by others on their hazard elimination and management list.

A	ORIGINAL ISSUE	15/12/25	MWG
REV	DESCRIPTION	DATE	BY



ENERVEO - STREET LIGHTING
34 Palmerston Drive, Fareham, Hampshire PO14 1DJ
Email: lightingdesign@enerveo.com Tel: 01133 853129

TITLE

STREET LIGHTING LAYOUT DRAWING

FOOTPATH

PROJECT

IMBERHORNE FARM
EAST GRINSTEAD - RESERVE MATTERS

SCALE	DATE	15/12/25	
1:500 @ A1	DRAWN	MWG	
	CHECKED	RHJ	
PAPER SIZE	A1	APPROVED	SAB

DRAWING NUMBER	REVISION
EVO20033126-LD-018	A