


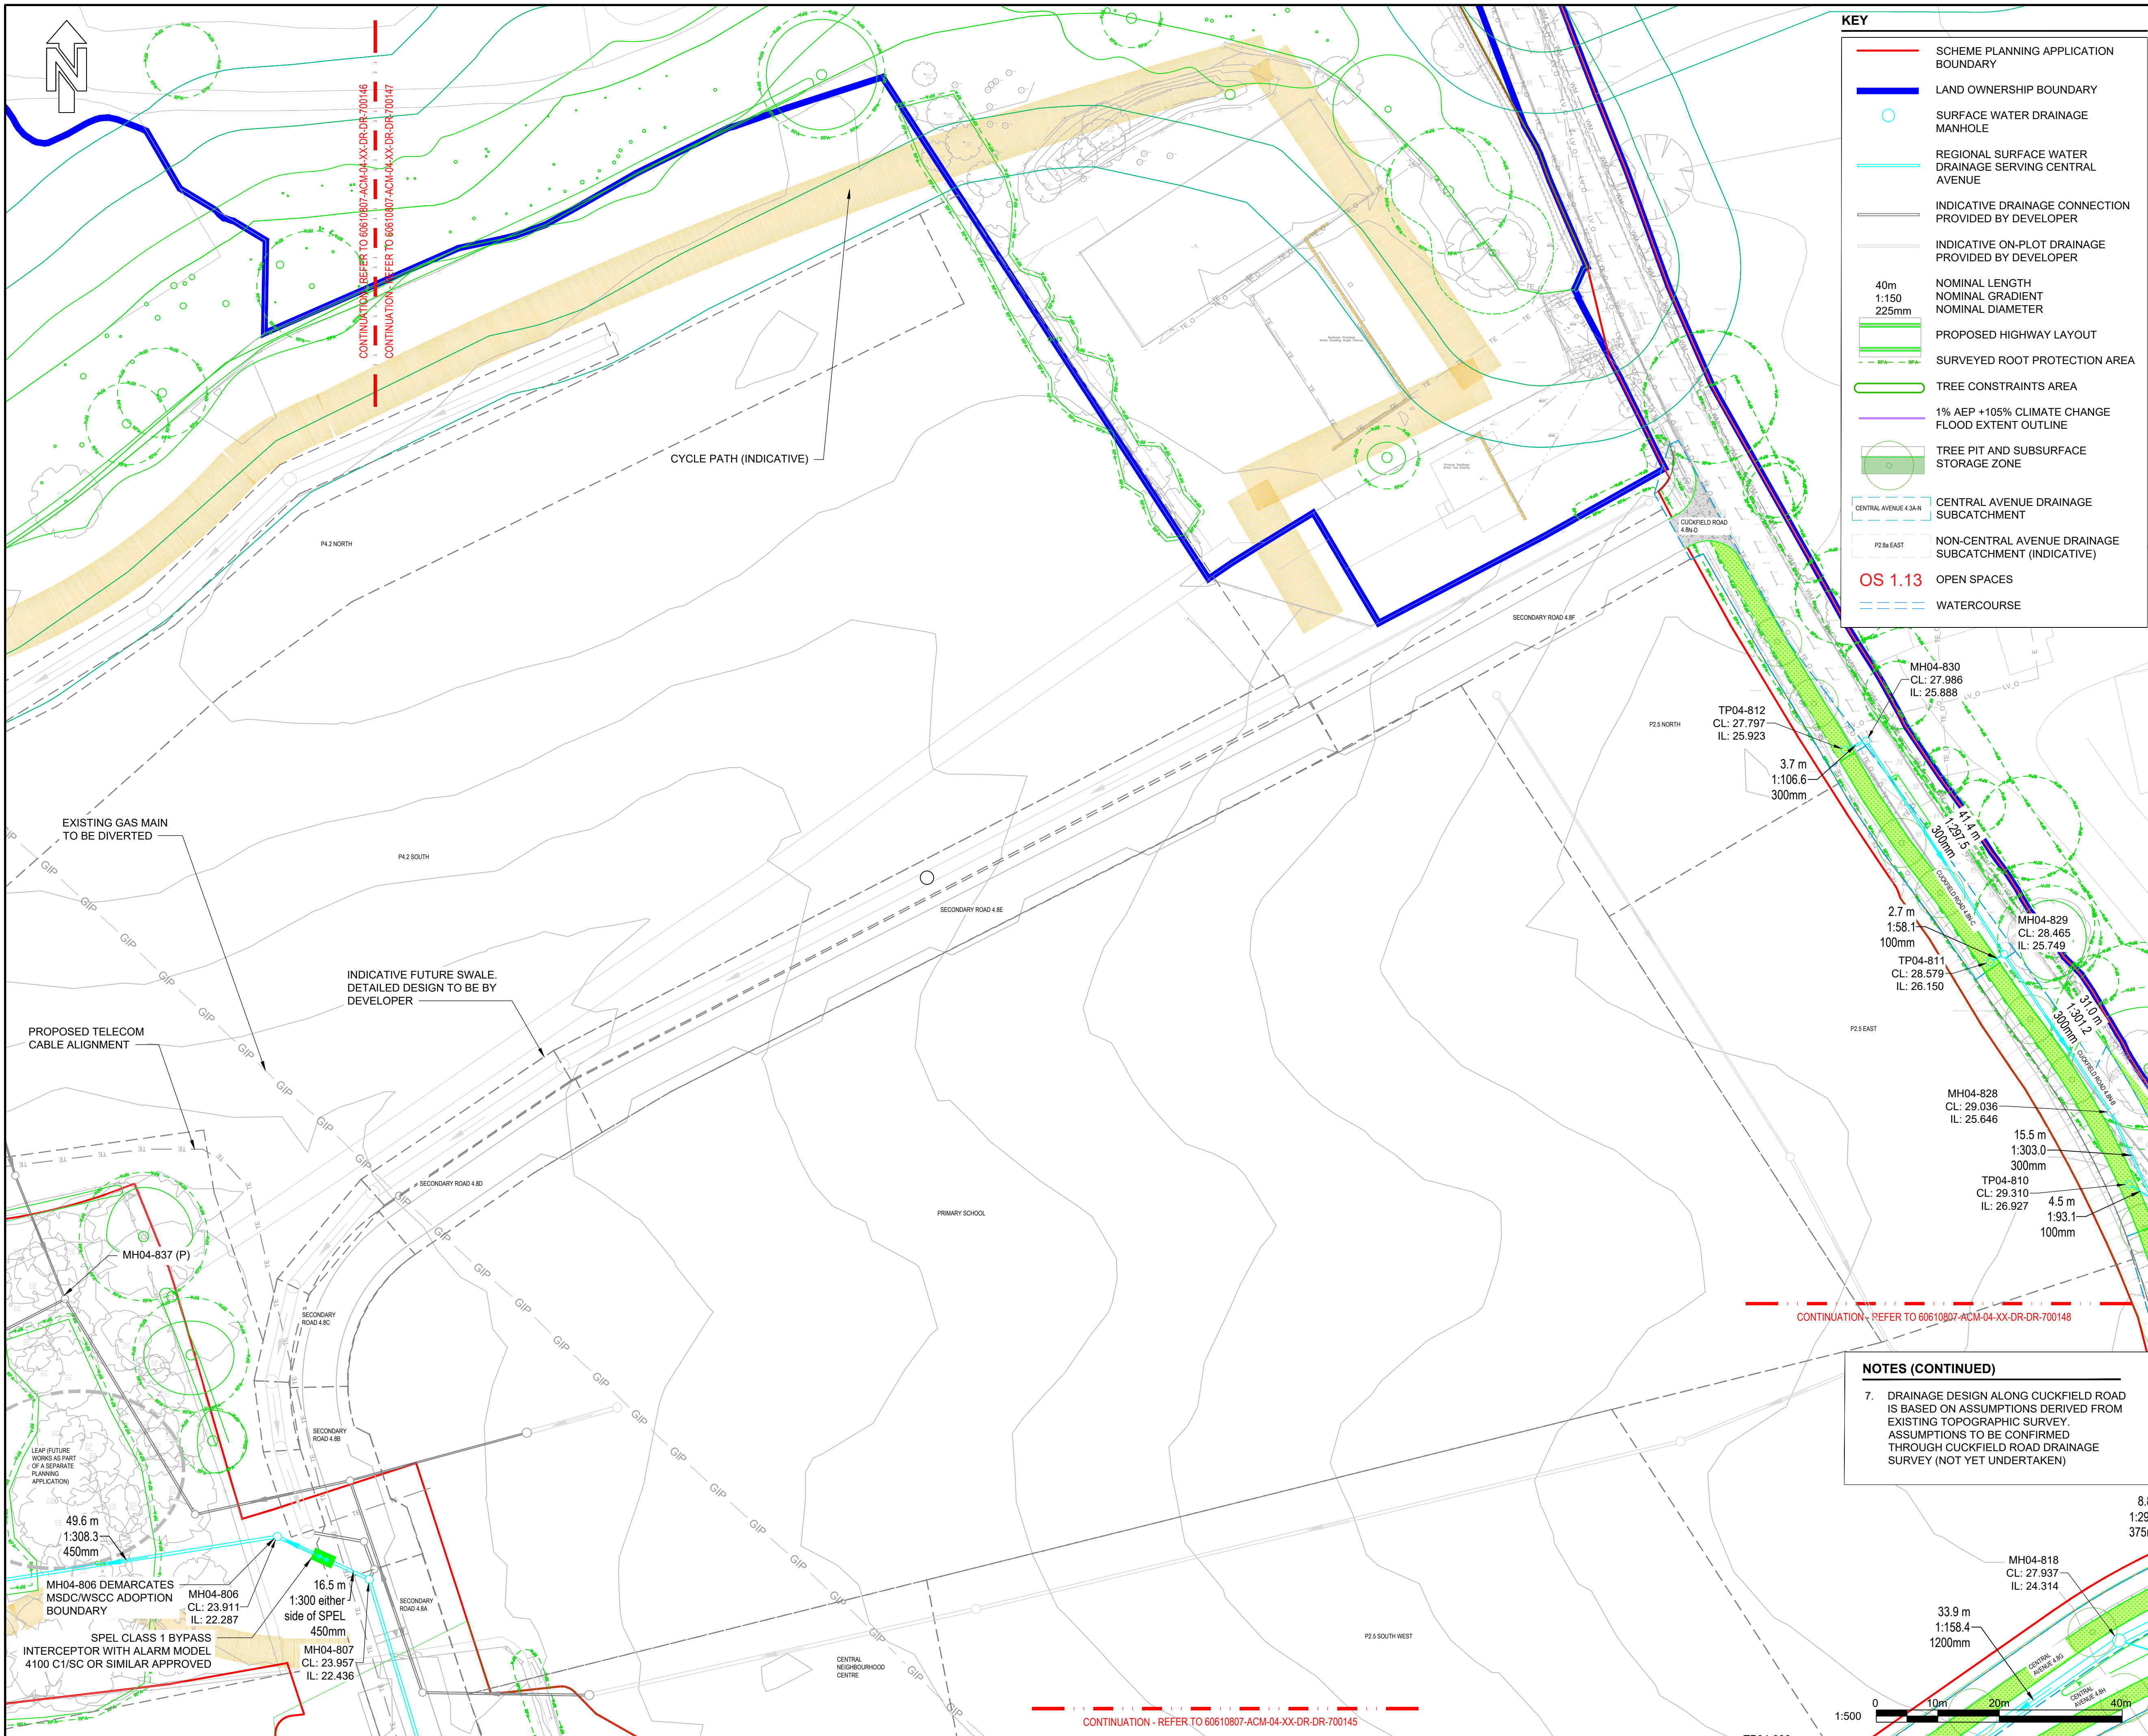

PROJECT

Brookleigh -
Northern Arc avenue
Central Section

CLIENT

Homes England

CONSULTANT

AECOM
Aldgate Tower
2 Lemn Street
London, E1 8FA
United Kingdom

T +44 (0)2076 452000
www.aecom.com

NOTES

1. Do not scale from the drawing.
2. All levels shown are in metres above ordnance datum (mAOD) unless stated otherwise.
3. Drawing is to be read in conjunction with the following:
60610807-ACM-04-XX-DR-DR-700145 to 700148.
4. For drainage long sections refer to drawings
60610807-ACM-04-XX-DR-DR-700245 to 700251.
For manhole schedule refer to
60610807-ACM-04-XX-DR-DR-700545
For pond and detention basin general arrangements refer to
60610807-ACM-04-XX-DR-DR-701120 and 701130.
For typical details including tree pit detail refer to
60610807-ACM-XX-XX-DR-DR-702000 to 702008.
For drainage specification refer to document
60610807-ACM-XX-XX-RP-DR-700000
5. Contributing drainage areas have been estimated from finished topography and assigned to a manhole within the drainage model.
6. Attenuation volumes are from Microdrainage model
60610807-ACM-04-XX-CU-DR-700048.


SUITABILITY

S3 FOR REVIEW & COMMENT

ISSUE/REVISION

P02	20.12.2024	SECOND ISSUE
P01	12.01.2024	FIRST ISSUE
I/R	DATE	DESCRIPTION

KEY PLAN

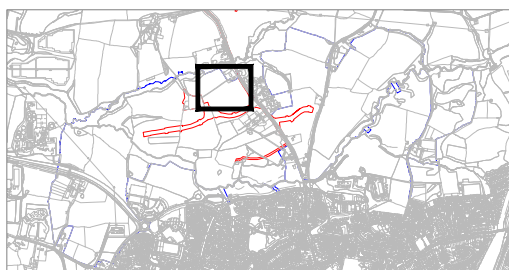

PROJECT NUMBER

60610807

SHEET TITLE

DRAINAGE AREA 4.8
HIGHWAY DRAINAGE LAYOUT PLAN
SHEET 3 OF 4

SHEET NUMBER

60610807-ACM-04-XX-DR-DR-700147