

 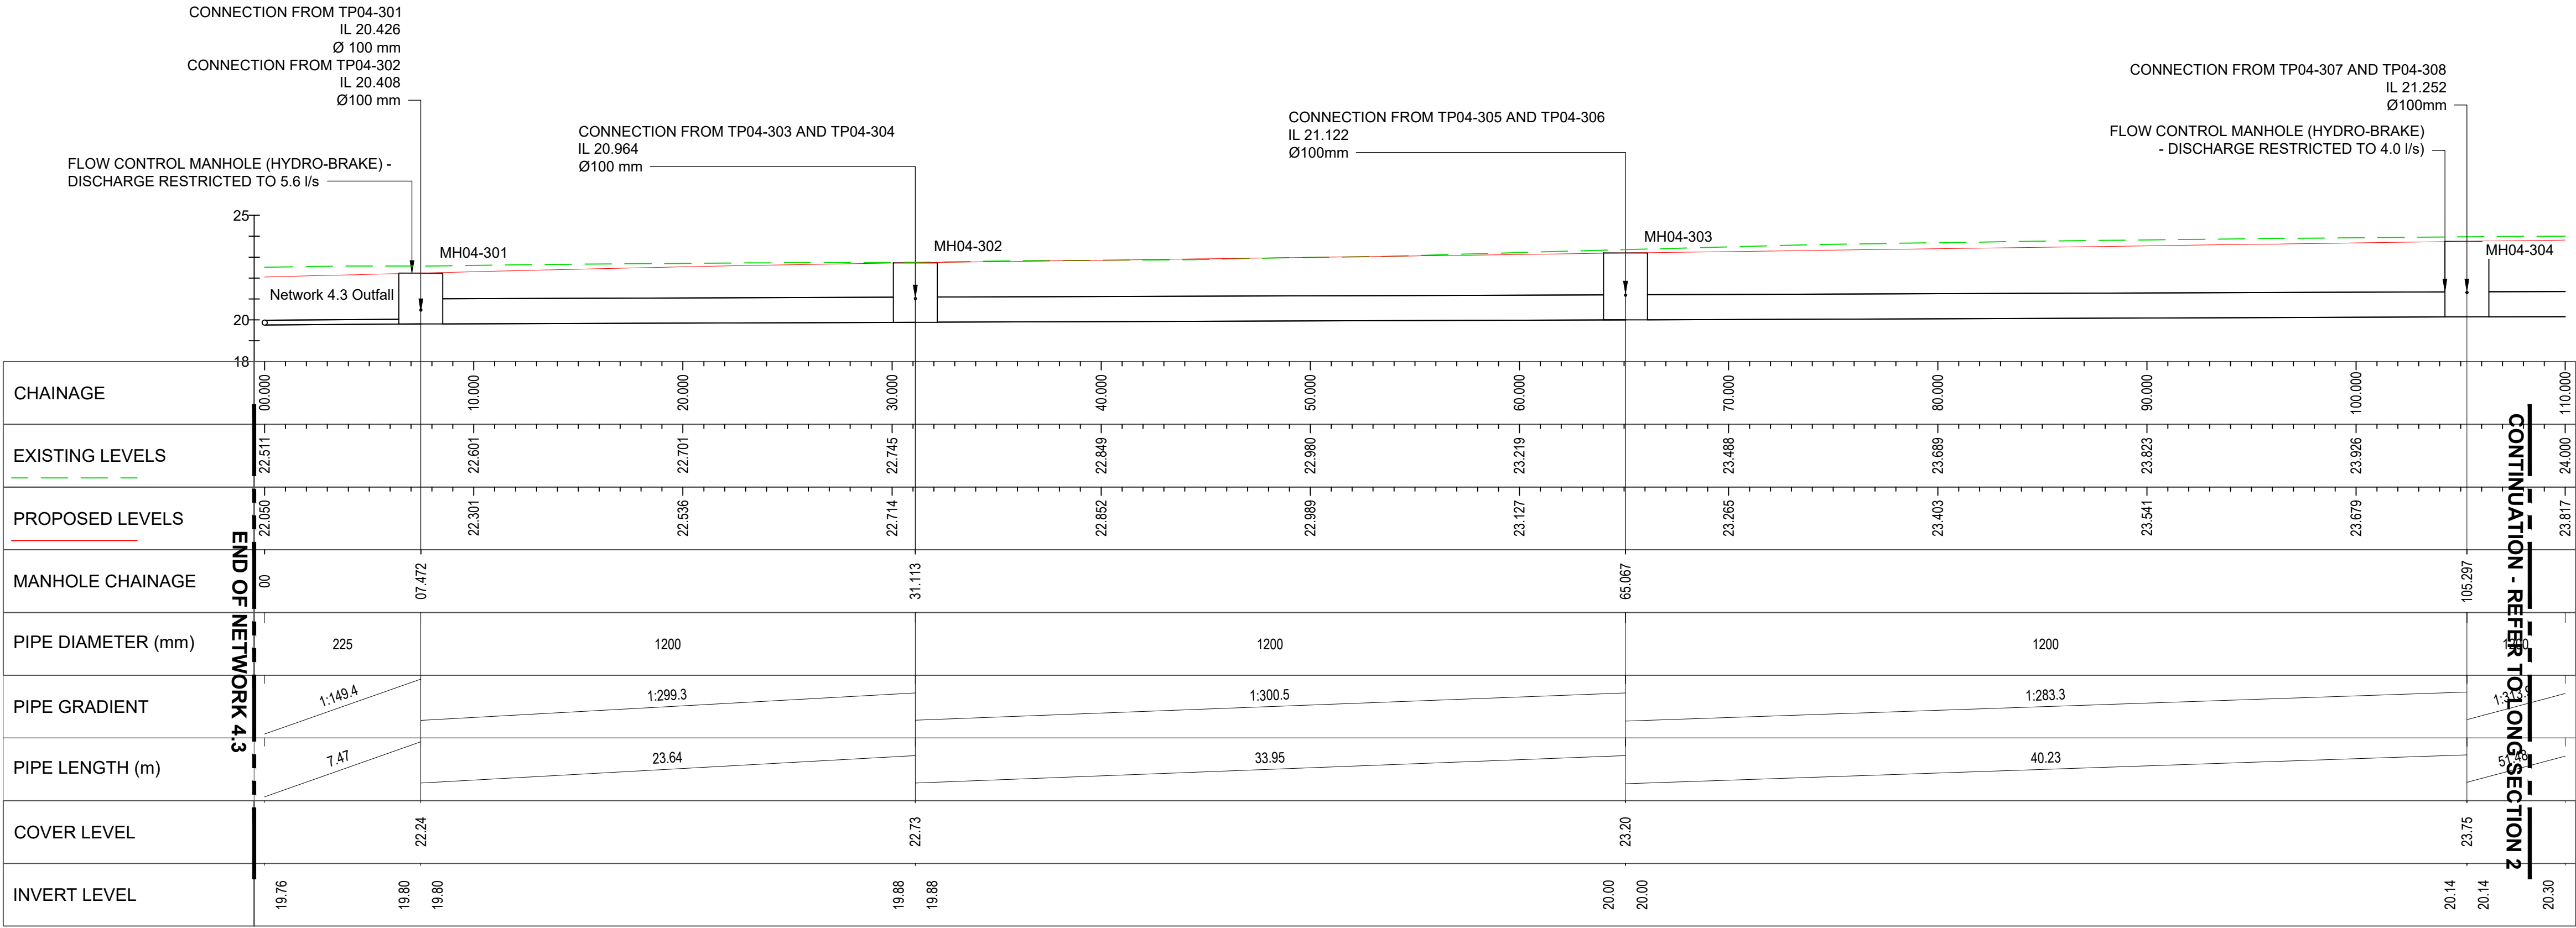


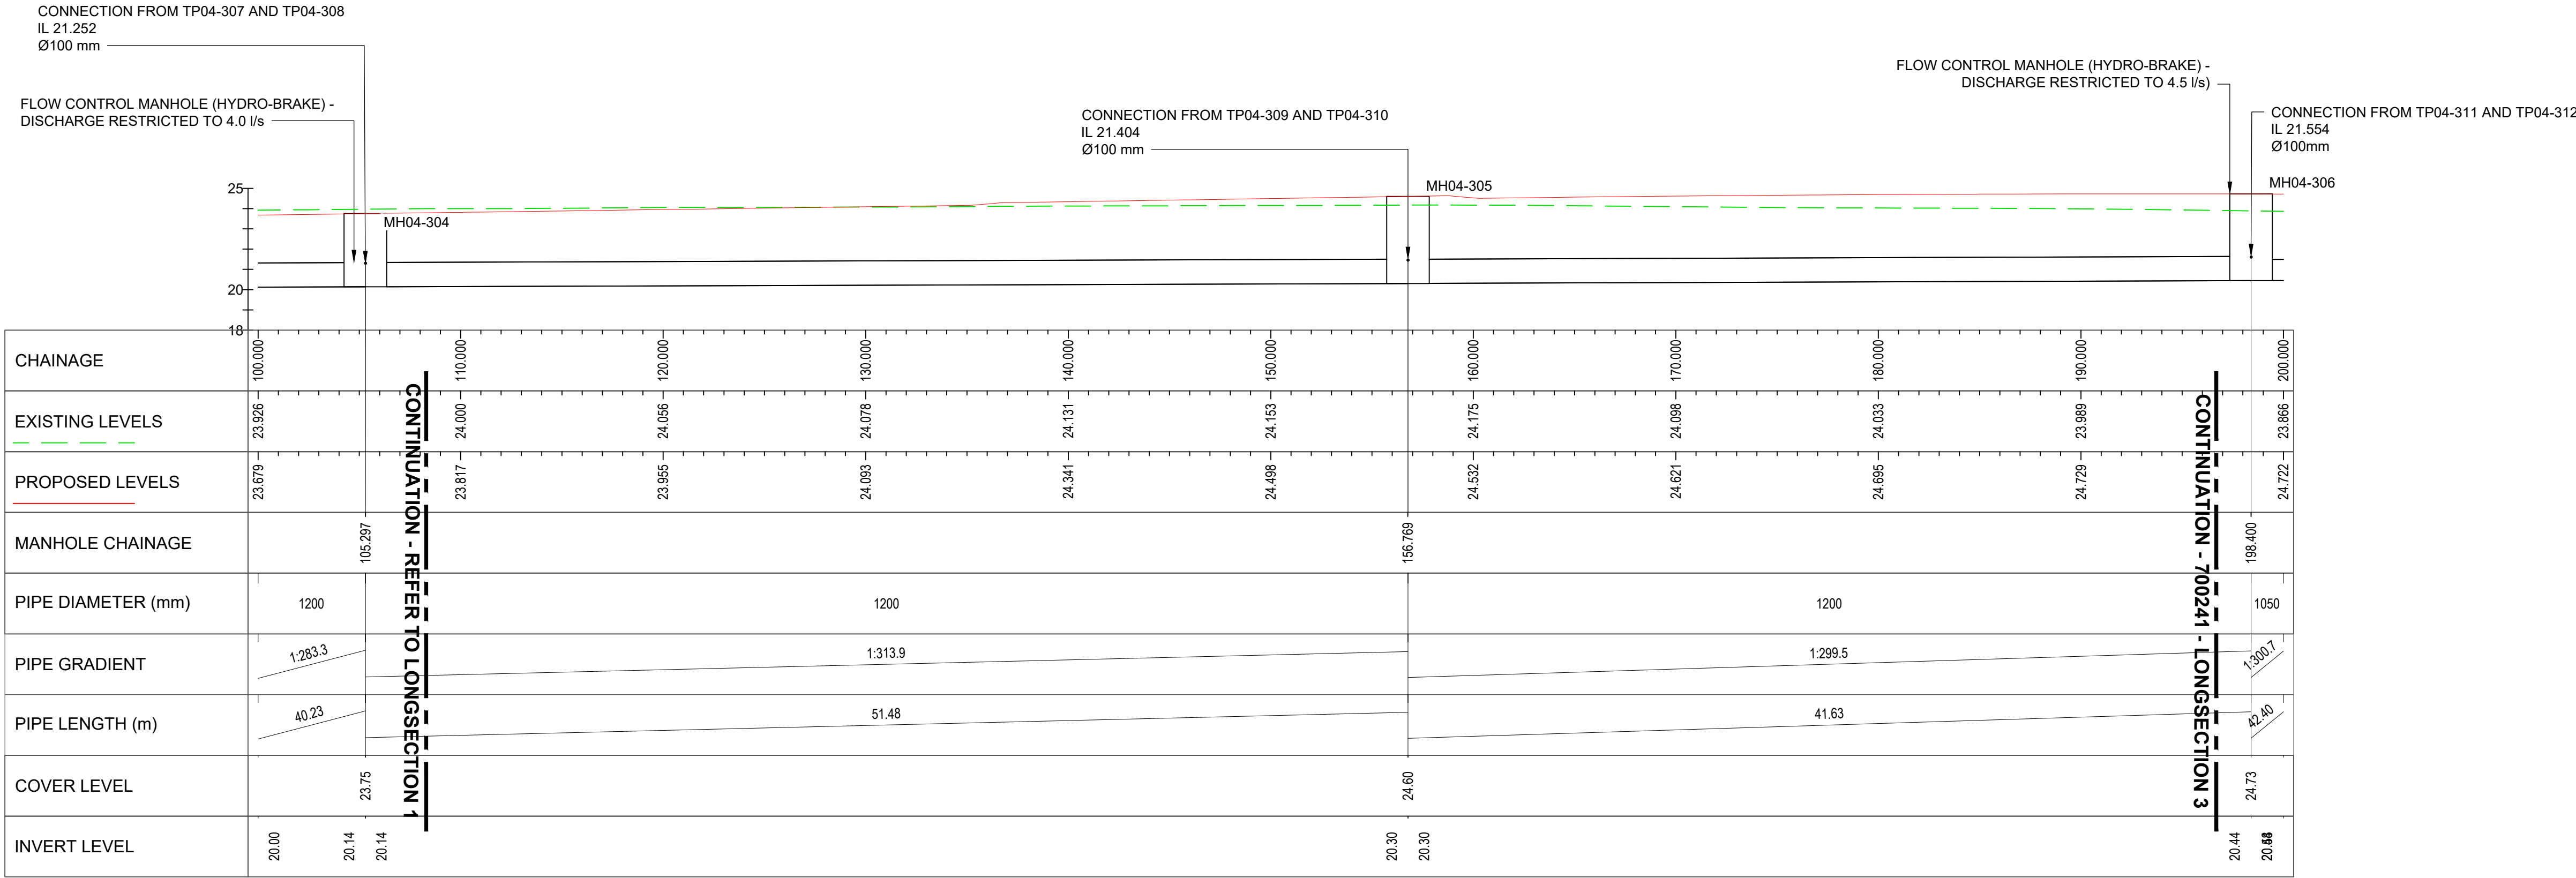


NETWORK 4.3 LONGSECTION 1 - CHAINAGE 0.000 TO 110.000

Scale 1:200



NETWORK 4.3 LONGSECTION 2 - CHAINAGE 100.000 TO 200.000

 Scale 1:200



PROJECT

Brookleigh -
Northern Arc avenue
Central Section

CLIENT

Homes England

CONSULTANT

AECOM
Aldgate Tower
2 Leman Street
London, E1 8FA
United Kingdom

T +44 (0)2076 452000
www.aecom.com

NOTES

- Do not scale from the drawing.
- All levels are shown in metres above ordnance datum (mAOD) unless stated otherwise.
- Drawing is to be read in conjunction with the following:
60610807-ACM-04-XX-DR-DR-700241
Project specification Appendix 5/1
- Regional SuDS are shown indicatively.
- Existing ground levels are based on existing topographic survey.
- For network 4.3 drainage layouts refer to the following:
60610807-ACM-04-XX-DR-DR-700140
60610807-ACM-04-XX-DR-DR-700141
- Attenuation volumes are from Microdrainage model
60610807-ACM-04-XX-CU-DR-700043.

KEY

- EXISTING GROUND
- PROPOSED GROUND
- CONNECTING PIPE
- PIPES
- MANHOLE

SUITABILITY

S3 FOR REVIEW & COMMENT

ISSUE/REVISION

P02	20.12.2024	SECOND ISSUE
P01	12.01.2024	FIRST ISSUE
I/R	DATE	DESCRIPTION

PROJECT NUMBER

60610807

SHEET TITLE

DRAINAGE NETWORK 4.3
LONGSECTION
SHEET 1 OF 2

SHEET NUMBER

60610807-ACM-04-XX-DR-DR-700240

This drawing has been prepared for the use of AECOM's client. It may not be used, modified, reproduced or relied upon by third parties, except as agreed by AECOM or as required by law. AECOM accepts no responsibility and denies any liability whatsoever to any party that uses or relies on this drawing without AECOM's express written consent. Do not scale this document. All measurements must be obtained from the stated dimensions.