

 
 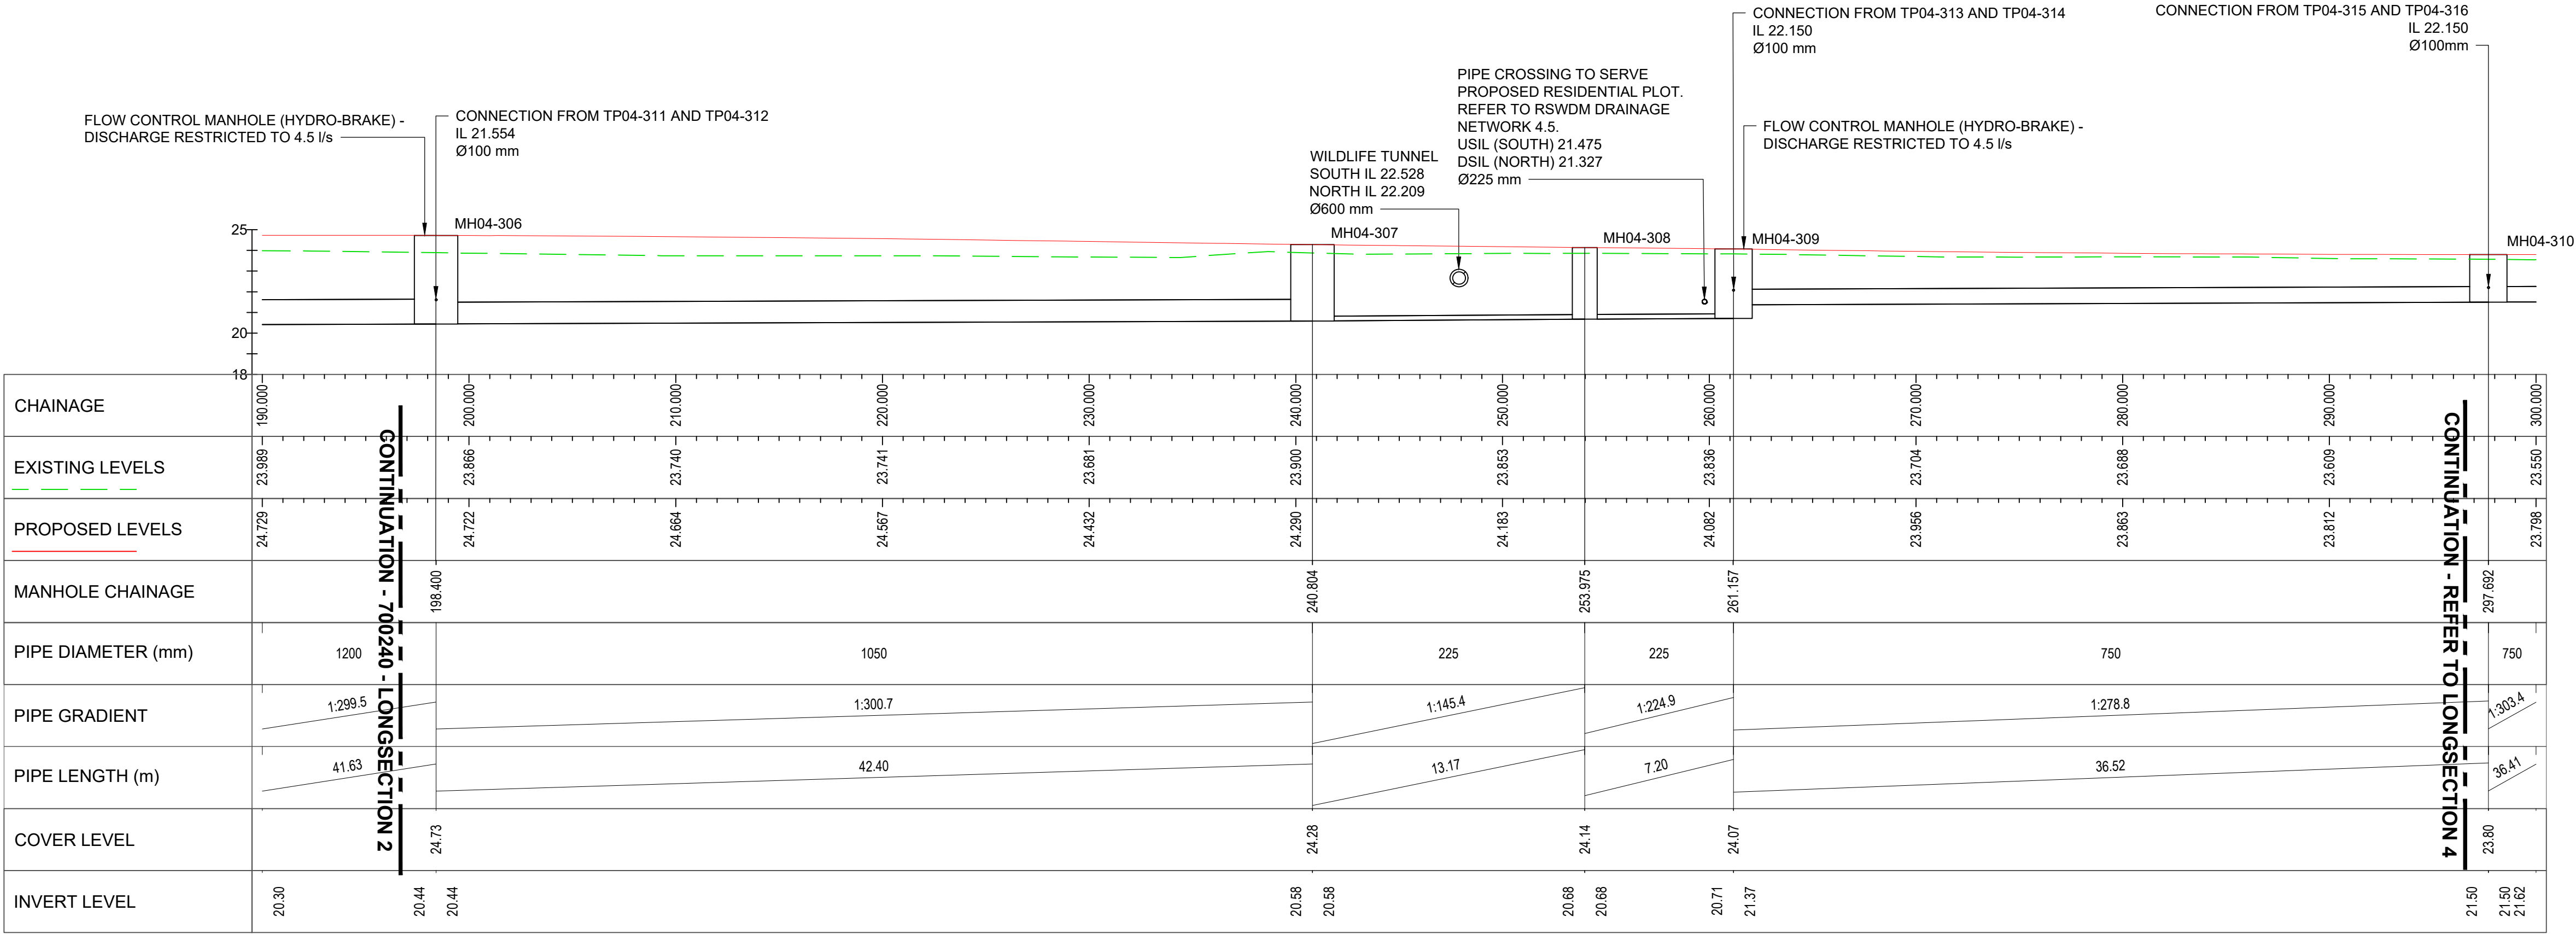


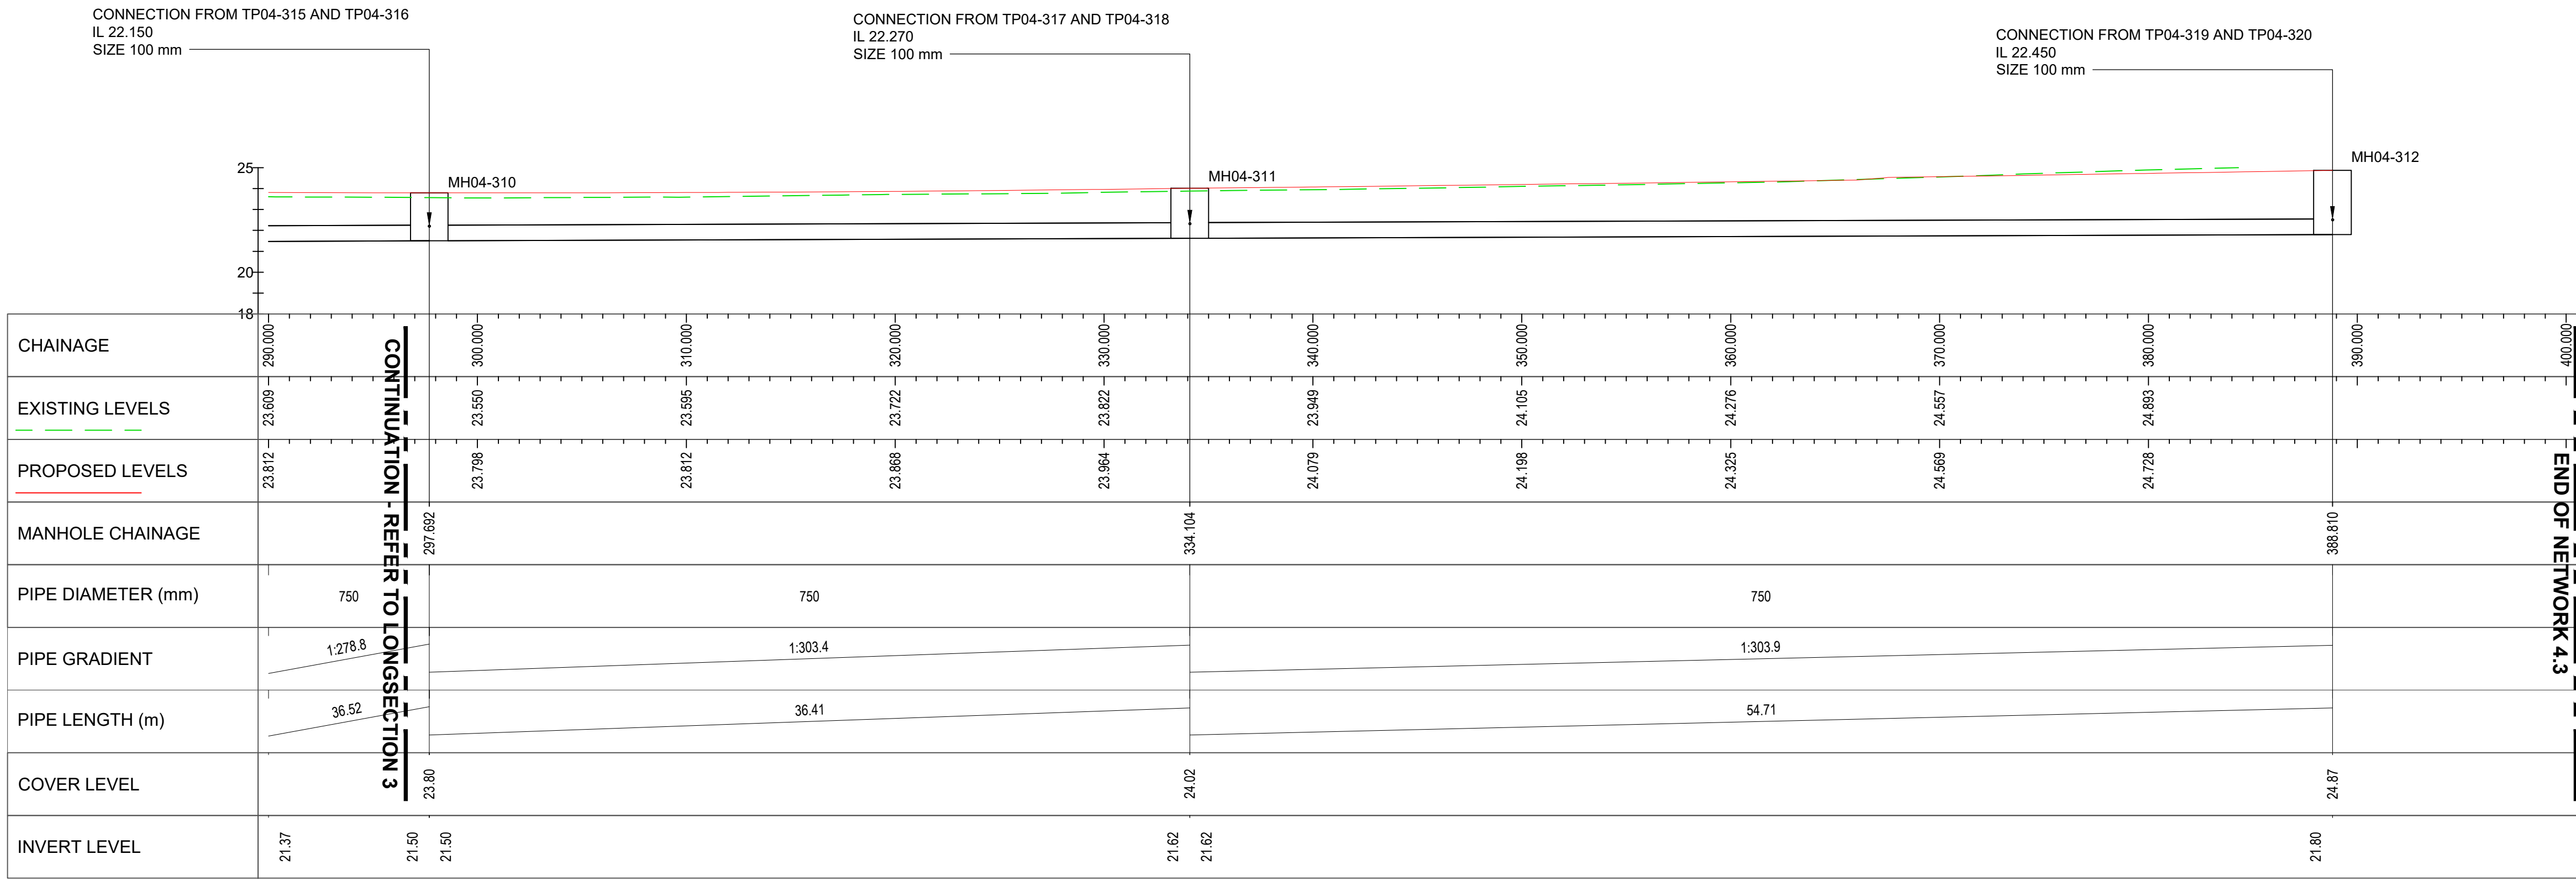

NETWORK 4.3 LONGSECTION 3 - CHAINAGE 190.000 TO 300.000
Scale 1:200



NETWORK 4.3 LONGSECTION 4 - CHAINAGE 290.000 TO 400.000
Scale 1:200



PROJECT

Brookleigh -
Northern Arc avenue
Central Section

CLIENT

Homes England

CONSULTANT

AECOM
Aldgate Tower
2 Leman Street
London, E1 8FA
United Kingdom

T +44 (0)2076 452000
www.aecom.com

NOTES

- Do not scale from the drawing.
- All levels are shown in metres above ordnance datum (mAOD) unless stated otherwise.
- Drawing is to be read in conjunction with the following:
60610807-ACM-04-XX-DR-DR-700240
Project specification Appendix 5/1.
- Regional SuDS are shown indicatively.
- Existing ground levels are based on existing topographic survey.
- For network 4.3 drainage layouts refer to the following:
60610807-ACM-04-XX-DR-DR-700140
60610807-ACM-04-XX-DR-DR-700141
- Attenuation volumes are from Microdrainage model
60610807-ACM-04-XX-CU-DR-700043.

KEY

- EXISTING GROUND
- PROPOSED GROUND
- CONNECTING PIPE
- PIPES
- MANHOLE

SUITABILITY

S3 FOR REVIEW & COMMENT

ISSUE/REVISION

P02	20.12.2024	SECOND ISSUE
P01	12.01.2024	FIRST ISSUE
I/R	DATE	DESCRIPTION

PROJECT NUMBER

60610807

SHEET TITLE

DRAINAGE NETWORK 4.3
LONGSECTION
SHEET 2 OF 2

SHEET NUMBER

60610807-ACM-04-XX-DR-DR-700241