



PROJECT

Brookleigh -
Northern Arc avenue
Central Section

CLIENT

Homes England

CONSULTANT

AECOM
Aldgate Tower
2 Leman Street
London, E1 8FA
United Kingdom

T +44 (0)2076 452000
www.aecom.com

NOTES

- DO NOT SCALE FROM THE DRAWING.
- ALL LEVELS ARE SHOWN IN METRES ABOVE ORDNANCE DATUM (mAOD) UNLESS STATED OTHERWISE.
- DRAWING IS TO BE READ IN CONJUNCTION WITH THE FOLLOWING:
60610807-ACM-04-XX-DR-DR-700246
60610807-ACM-04-XX-DR-DR-700247
60610807-ACM-04-XX-DR-DR-700248
60610807-ACM-04-XX-DR-DR-700249
60610807-ACM-04-XX-DR-DR-701120
60610807-ACM-04-XX-DR-DR-701130
PROJECT SPECIFICATION APPENDIX 5/1
- REGIONAL SUDS ARE SHOWN INDICATIVELY.
- EXISTING GROUND LEVELS ARE BASED ON EXISTING TOPOGRAPHIC SURVEY.
- FOR NETWORK 4.8 DRAINAGE LAYOUTS REFER TO THE FOLLOWING:
60610807-ACM-04-XX-DR-DR-700145
60610807-ACM-04-XX-DR-DR-700146
60610807-ACM-04-XX-DR-DR-700147
60610807-ACM-04-XX-DR-DR-700148
- ATTENUATION VOLUMES ARE FROM MICRODRAINAGE MODEL
60610807-ACM-04-XX-CU-DR-700048

KEY

- EXISTING GROUND
- PROPOSED GROUND
- TREE PITS
- PIPES
- MANHOLE

SUITABILITY

S3 FOR REVIEW & COMMENT

ISSUE/REVISION

	DATE	DESCRIPTION
P02	20.12.2024	SECOND ISSUE
P01	12.01.2024	FIRST ISSUE
I/R	DATE	DESCRIPTION

PROJECT NUMBER


60610807

SHEET TITLE

DRAINAGE NETWORK 4.8
LONGSECTION
SHEET 1 OF 5



SHEET NUMBER

60610807-ACM-04-XX-DR-DR-700245

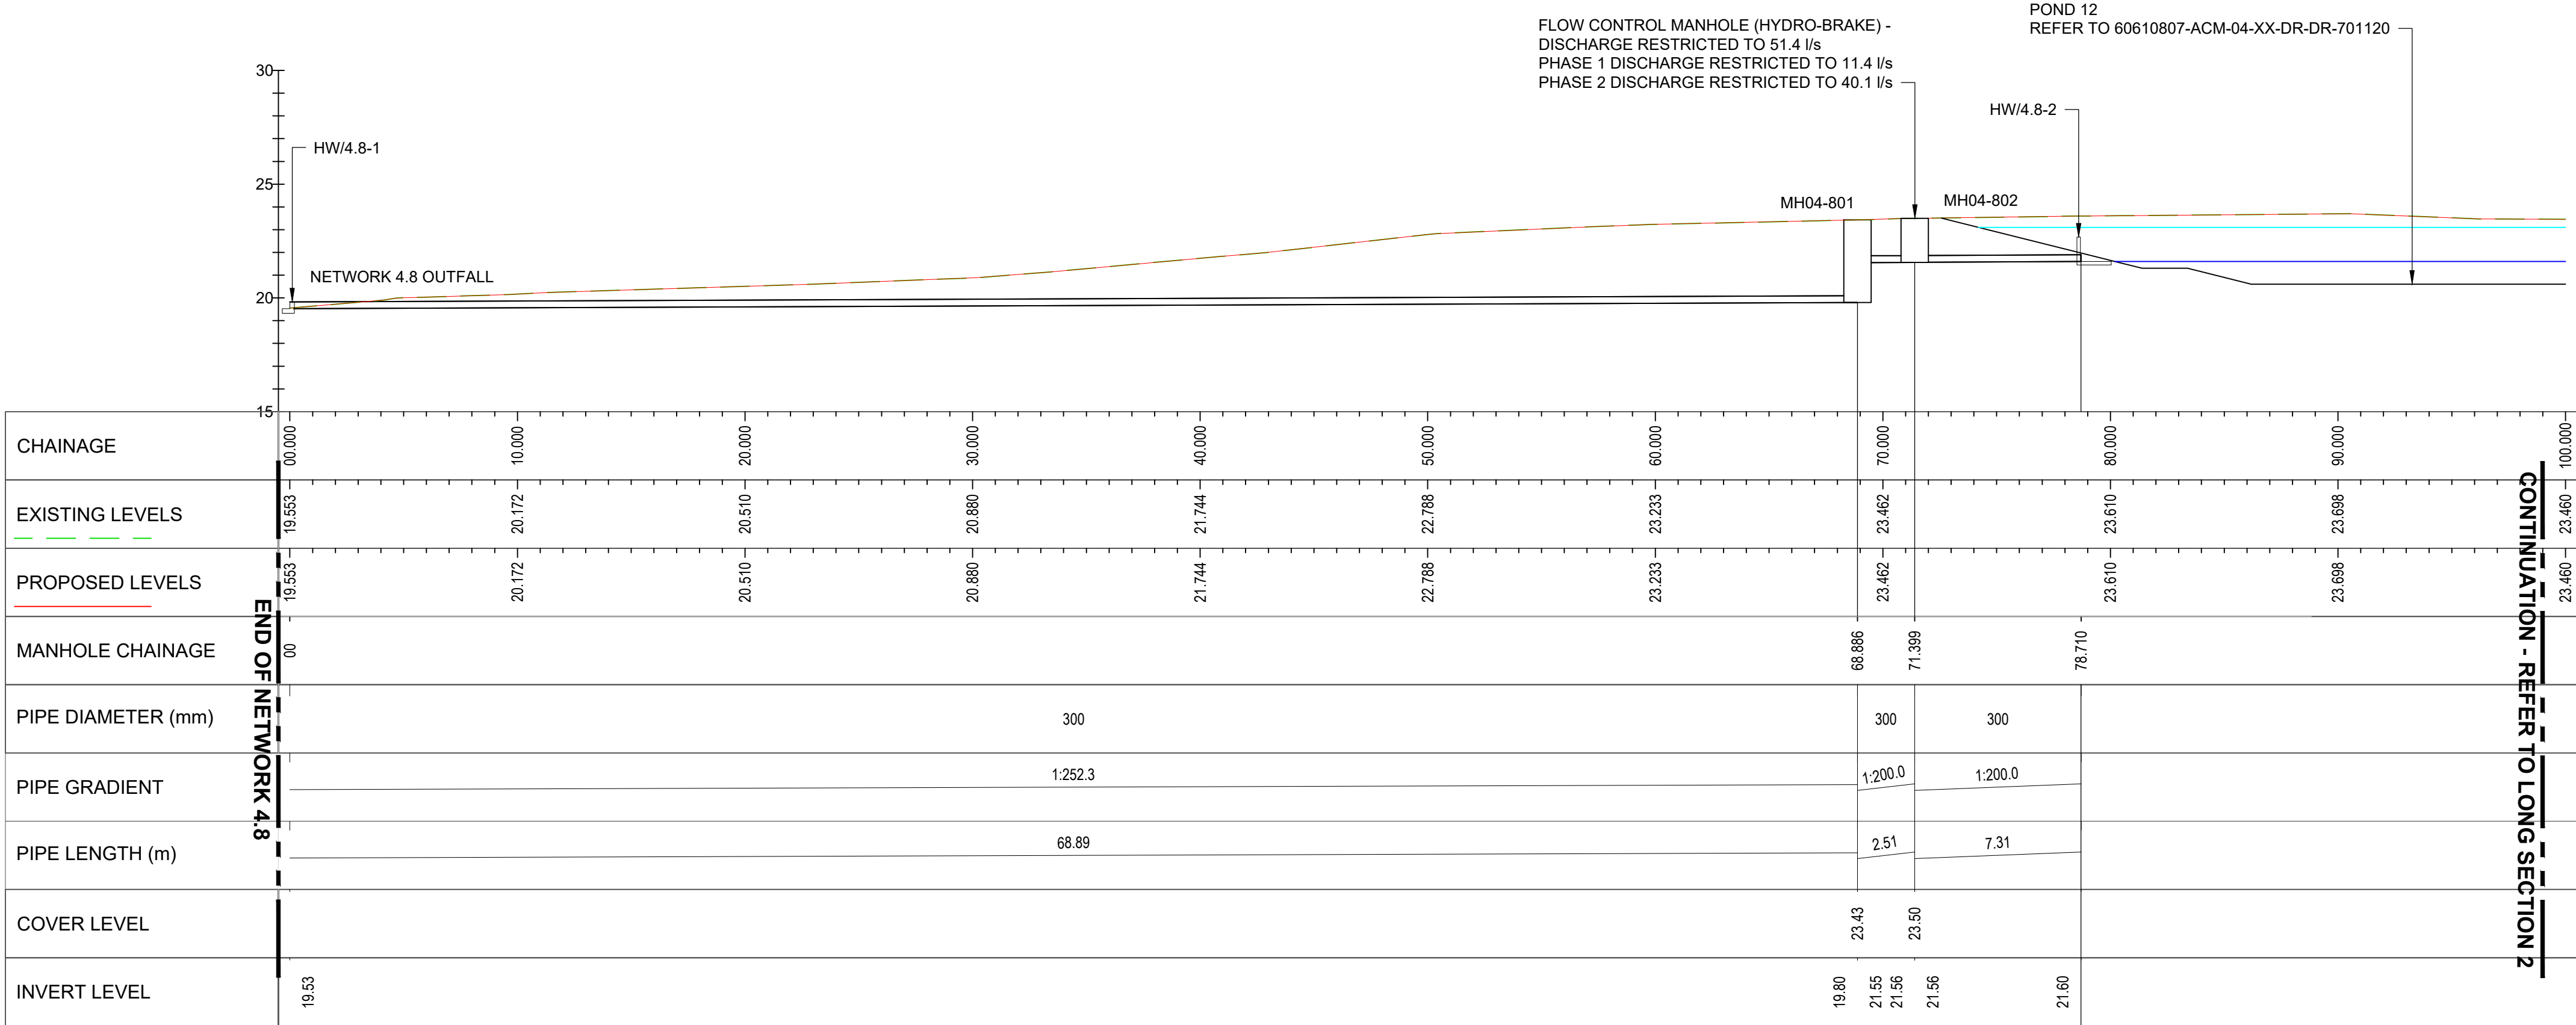

NETWORK 4.8 LONGSECTION 1 - CHAINAGE 0.000 TO 100.000

 Scale 1:200

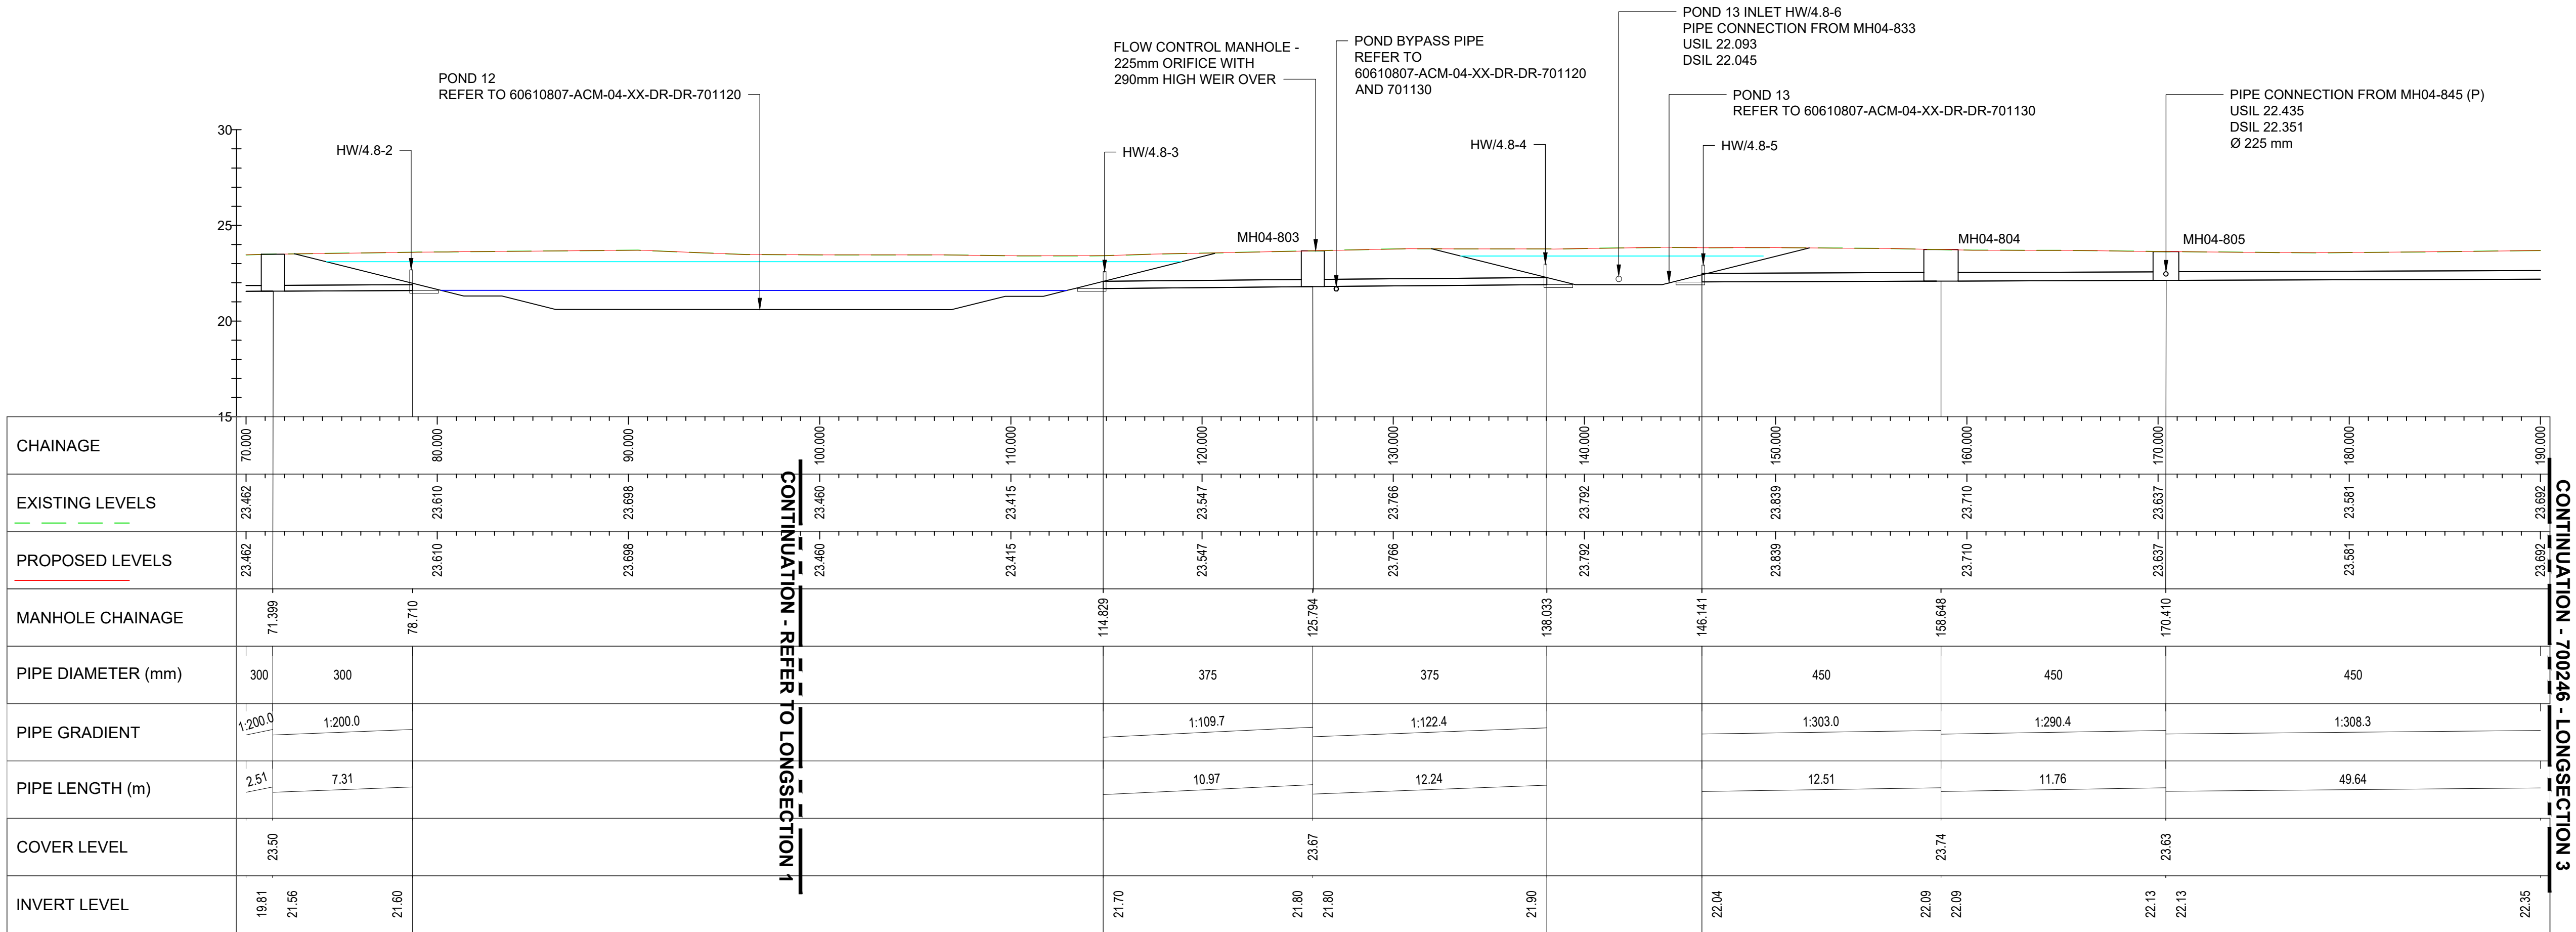

NETWORK 4.8 LONGSECTION 2 - CHAINAGE 70.000 TO 190.000

Scale 1:200

