



PROJECT

Brookleigh -
Northern Arc avenue
Central Section

CLIENT

Homes England

CONSULTANT

AECOM
Aldgate Tower
2 Leman Street
London, E1 8FA
United Kingdom

T +44 (0)2076 452000
www.aecom.com

NOTES

- DO NOT SCALE FROM THE DRAWING.
- ALL LEVELS ARE SHOWN IN METRES ABOVE ORDNANCE DATUM (mAOD) UNLESS STATED OTHERWISE.
- DRAWING IS TO BE READ IN CONJUNCTION WITH THE FOLLOWING:
60610807-ACM-04-XX-DR-DR-700245
60610807-ACM-04-XX-DR-DR-700246
60610807-ACM-04-XX-DR-DR-700247
60610807-ACM-04-XX-DR-DR-700248
PROJECT SPECIFICATION APPENDIX 5/1
- REGIONAL SUDS ARE SHOWN INDICATIVELY.
- EXISTING GROUND LEVELS ARE BASED ON EXISTING TOPOGRAPHIC SURVEY.
- FOR NETWORK 4.8 DRAINAGE LAYOUTS REFER TO THE FOLLOWING:
60610807-ACM-04-XX-DR-DR-700145
60610807-ACM-04-XX-DR-DR-700146
60610807-ACM-04-XX-DR-DR-700147
60610807-ACM-04-XX-DR-DR-700148
- ATTENUATION VOLUMES ARE FROM MICRODRAINAGE MODEL
60610807-ACM-04-XX-CU-DR-700048

KEY

- EXISTING GROUND
- PROPOSED GROUND
- TREE PITS
- PIPES
- MANHOLE

SUITABILITY

S3 FOR REVIEW & COMMENT

ISSUE/REVISION

P02	20.12.2024	SECOND ISSUE
P01	12.01.2023	FIRST ISSUE
I/R	DATE	DESCRIPTION

PROJECT NUMBER

60610807


SHEET TITLE

DRAINAGE NETWORK 4.8
LONGSECTION
SHEET 5 OF 5

SHEET NUMBER


60610807-ACM-04-XX-DR-DR-700249

This drawing has been prepared for the use of AECOM's client. It may not be used, modified, reproduced or relied upon by third parties, except as agreed by AECOM or as required by law. AECOM accepts no responsibility and denies any liability whatsoever to any party that uses or relies on this drawing without AECOM's express written consent. All measurements must be obtained from the stated dimensions.

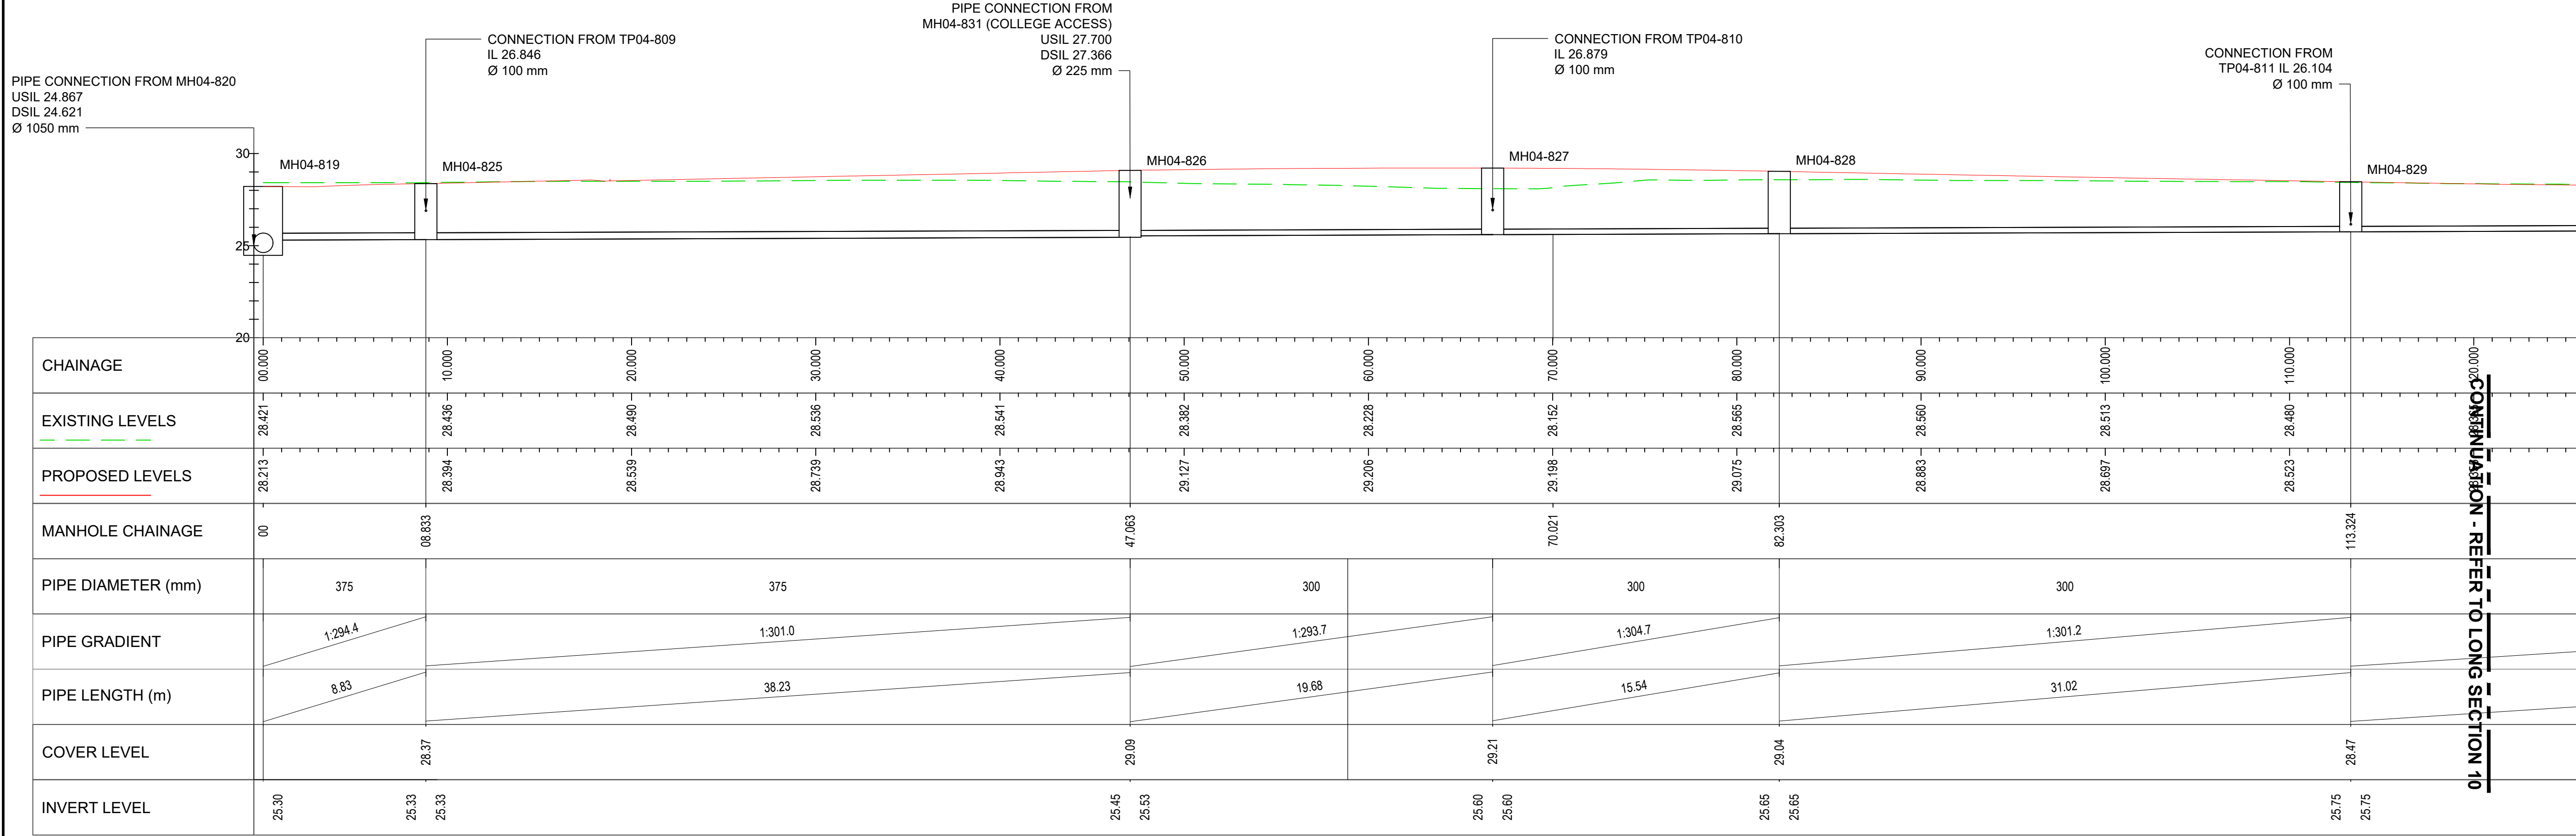


NETWORK 4.8 LONGSECTION 9 - FROM MH04-819 TO MH04-829

Scale 1:200

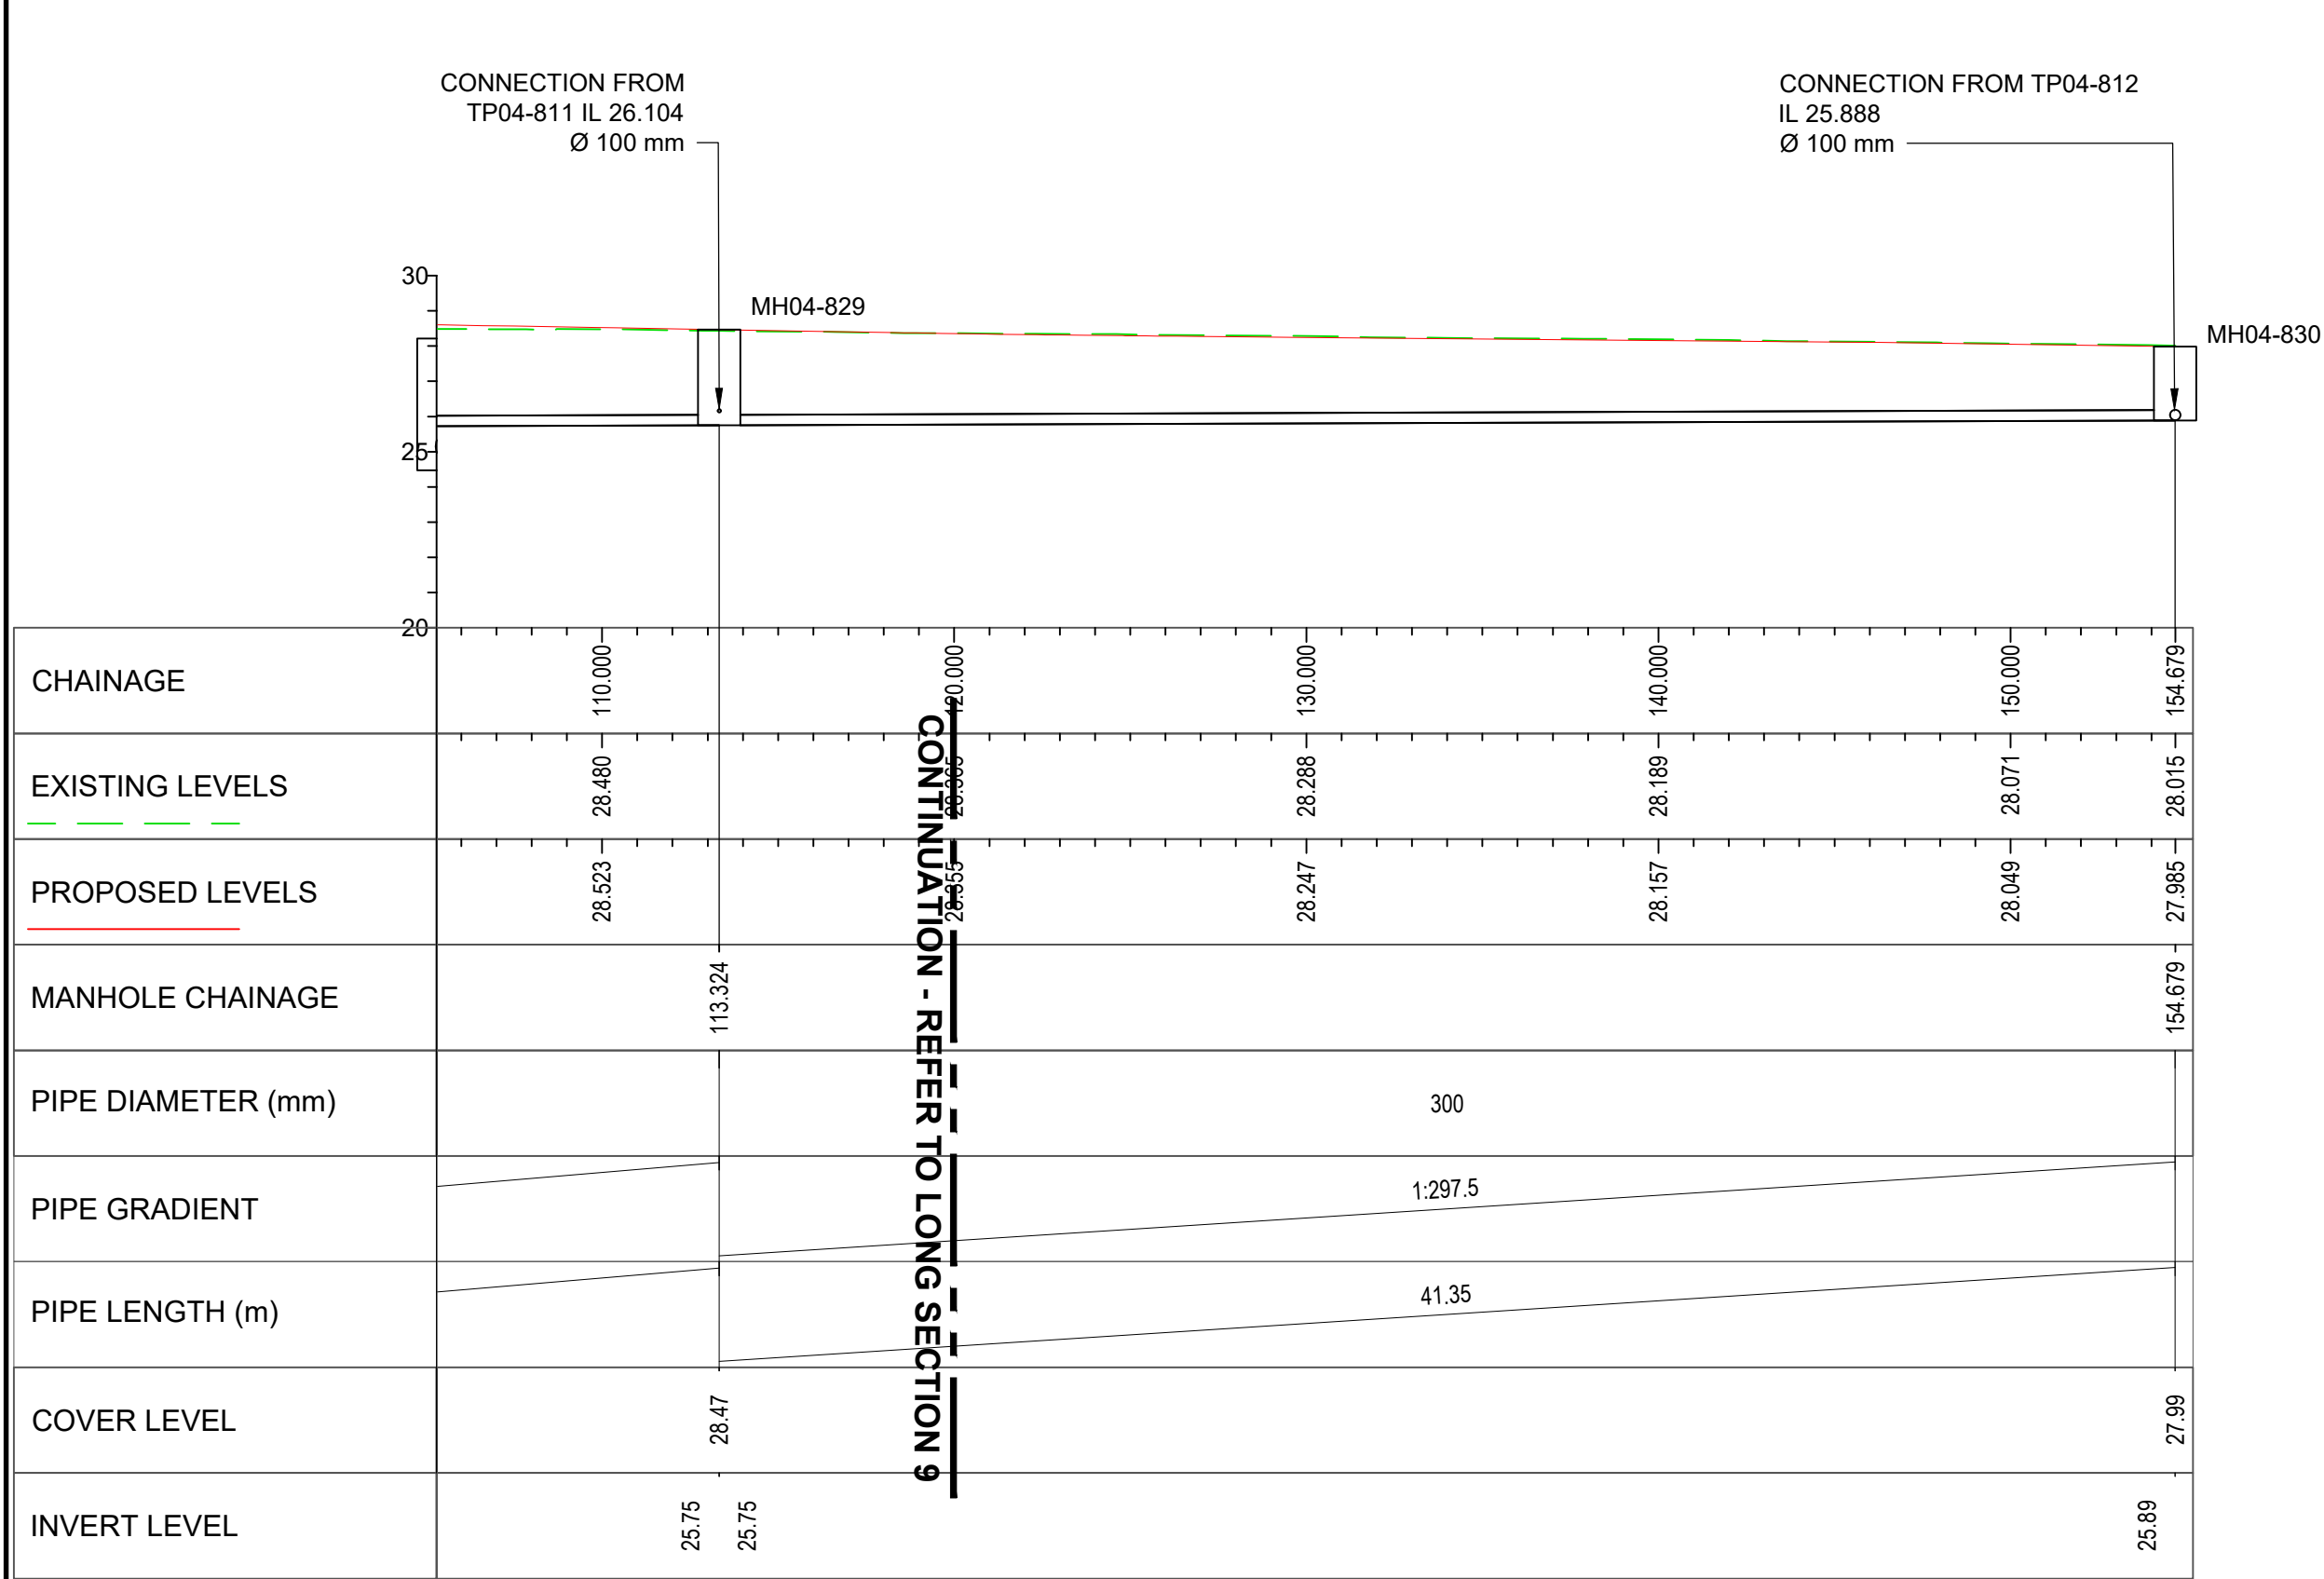

NETWORK 4.8 LONGSECTION 10 - FROM MH04-829 TO MH04-830

Scale 1:200

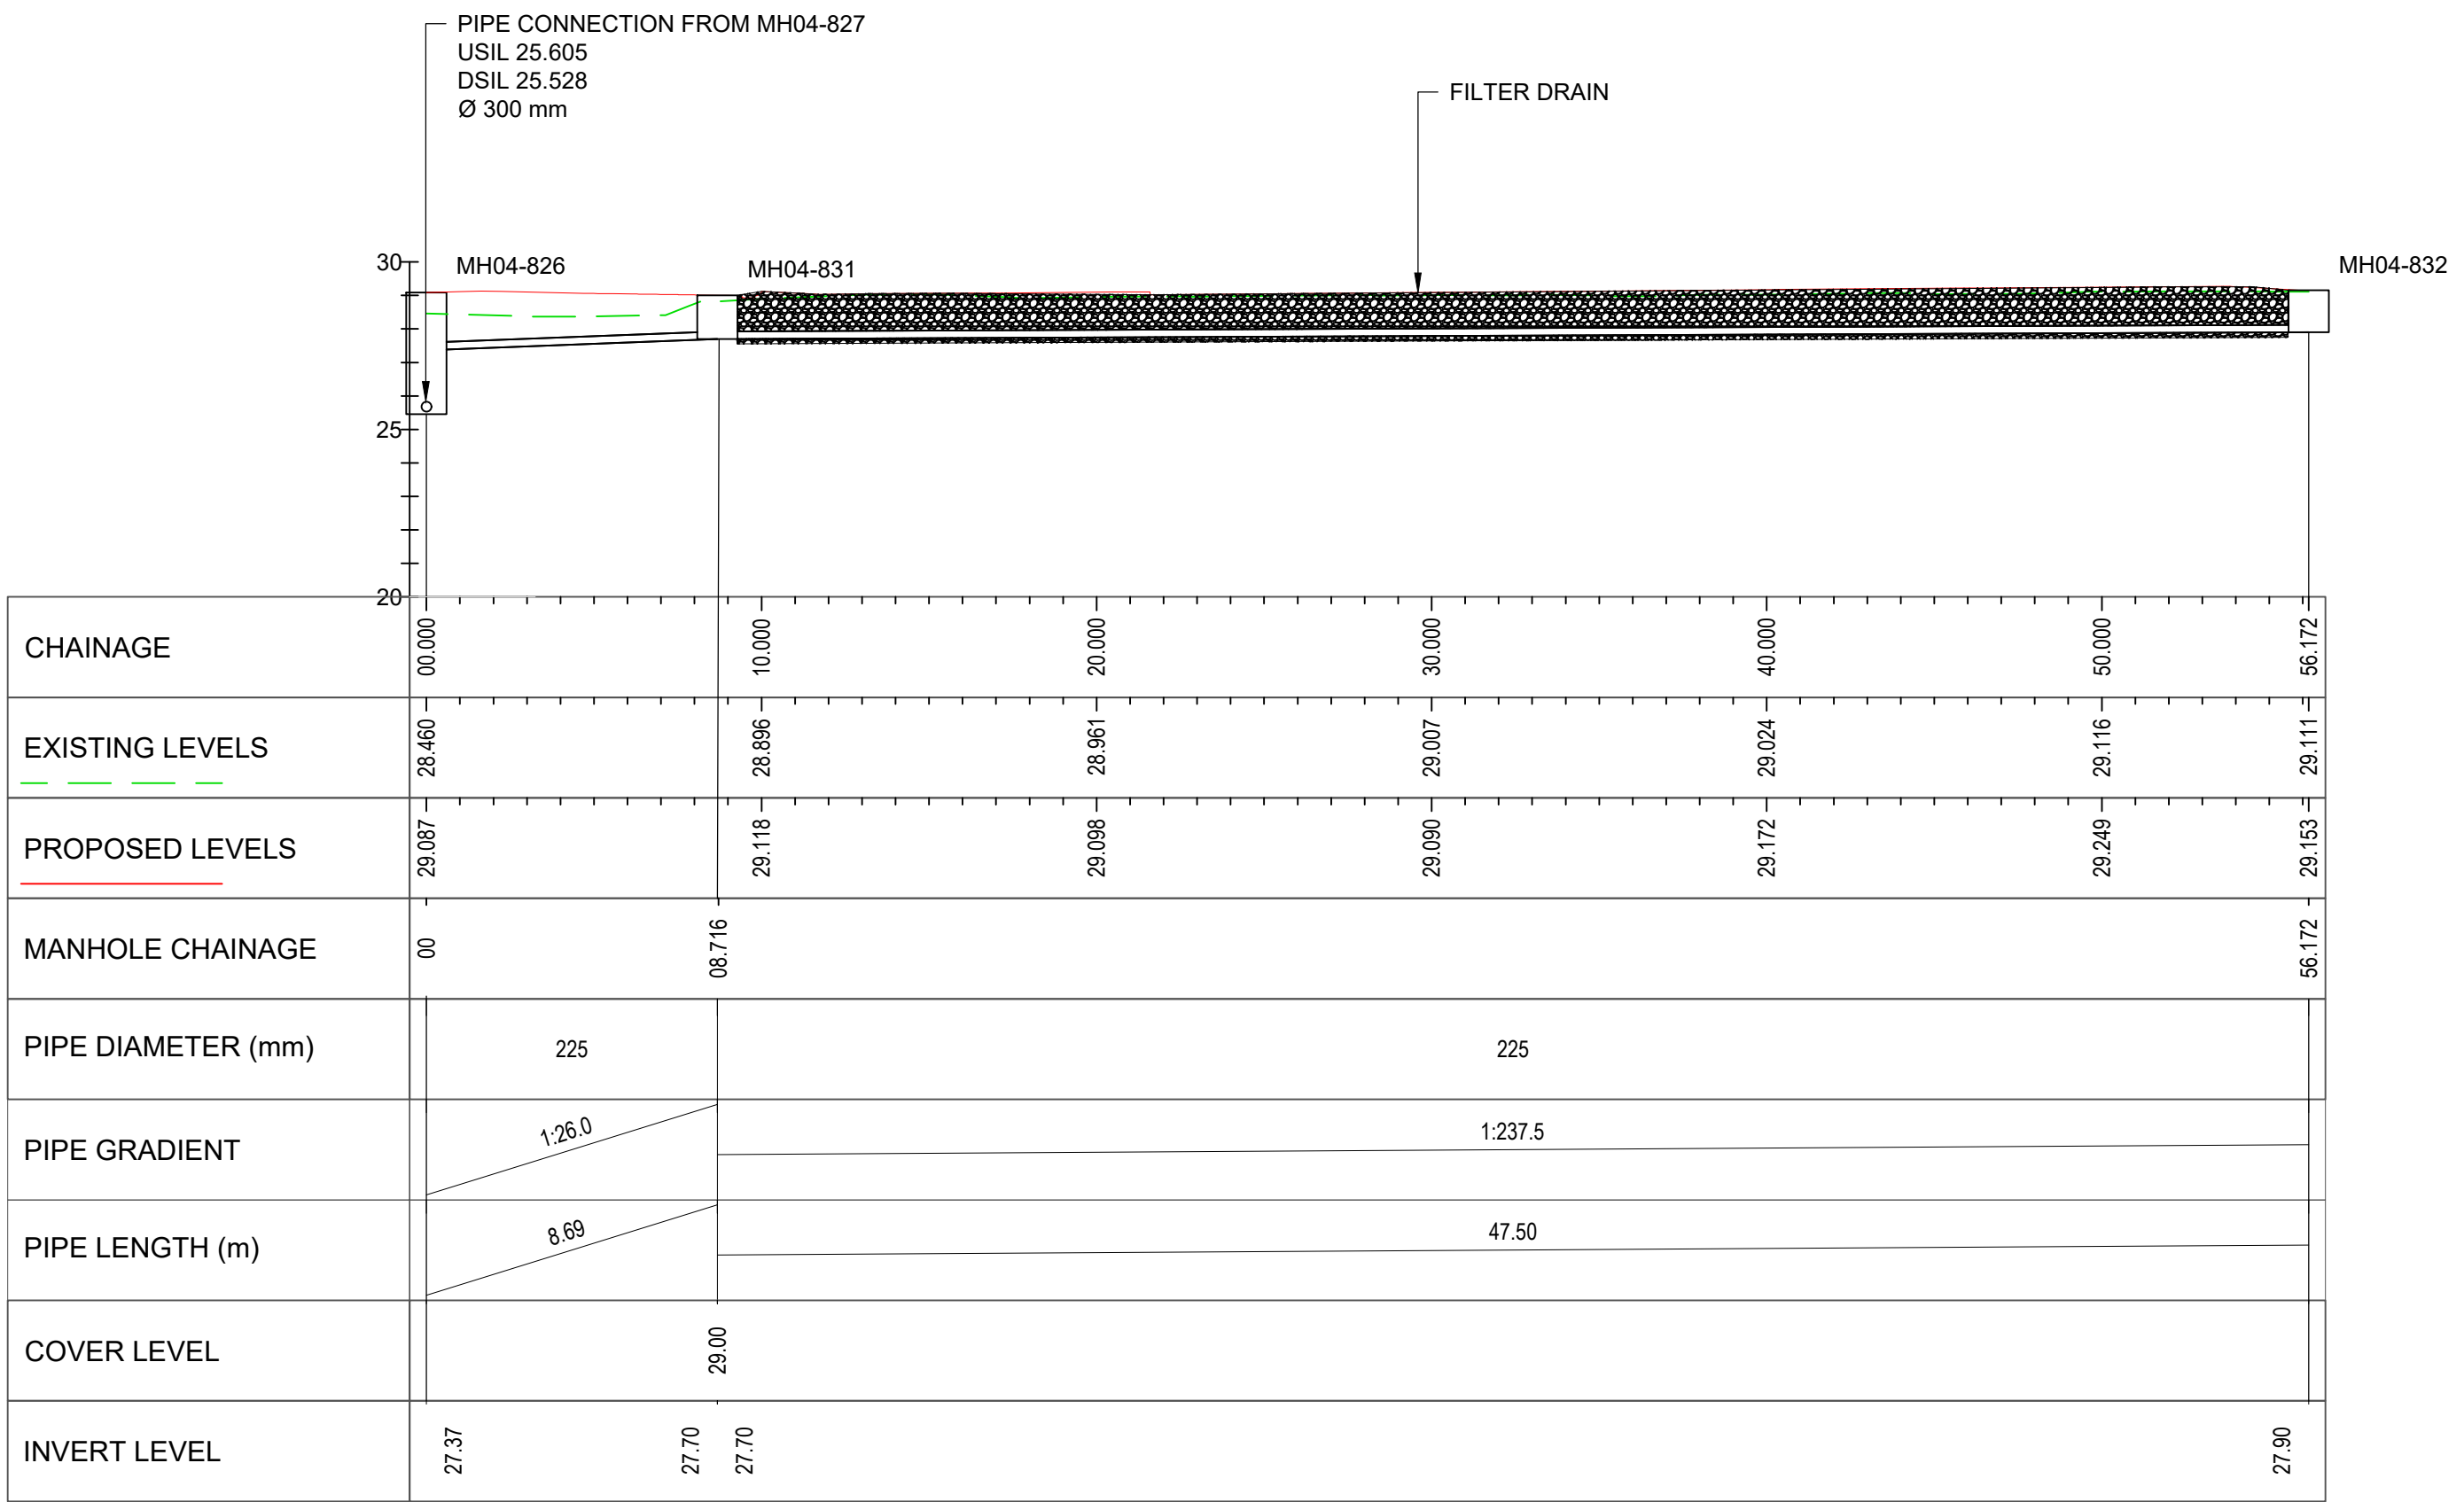

NETWORK 4.8 LONGSECTION 11 - FROM MH04-826 TO MH04-832

Scale 1:200