



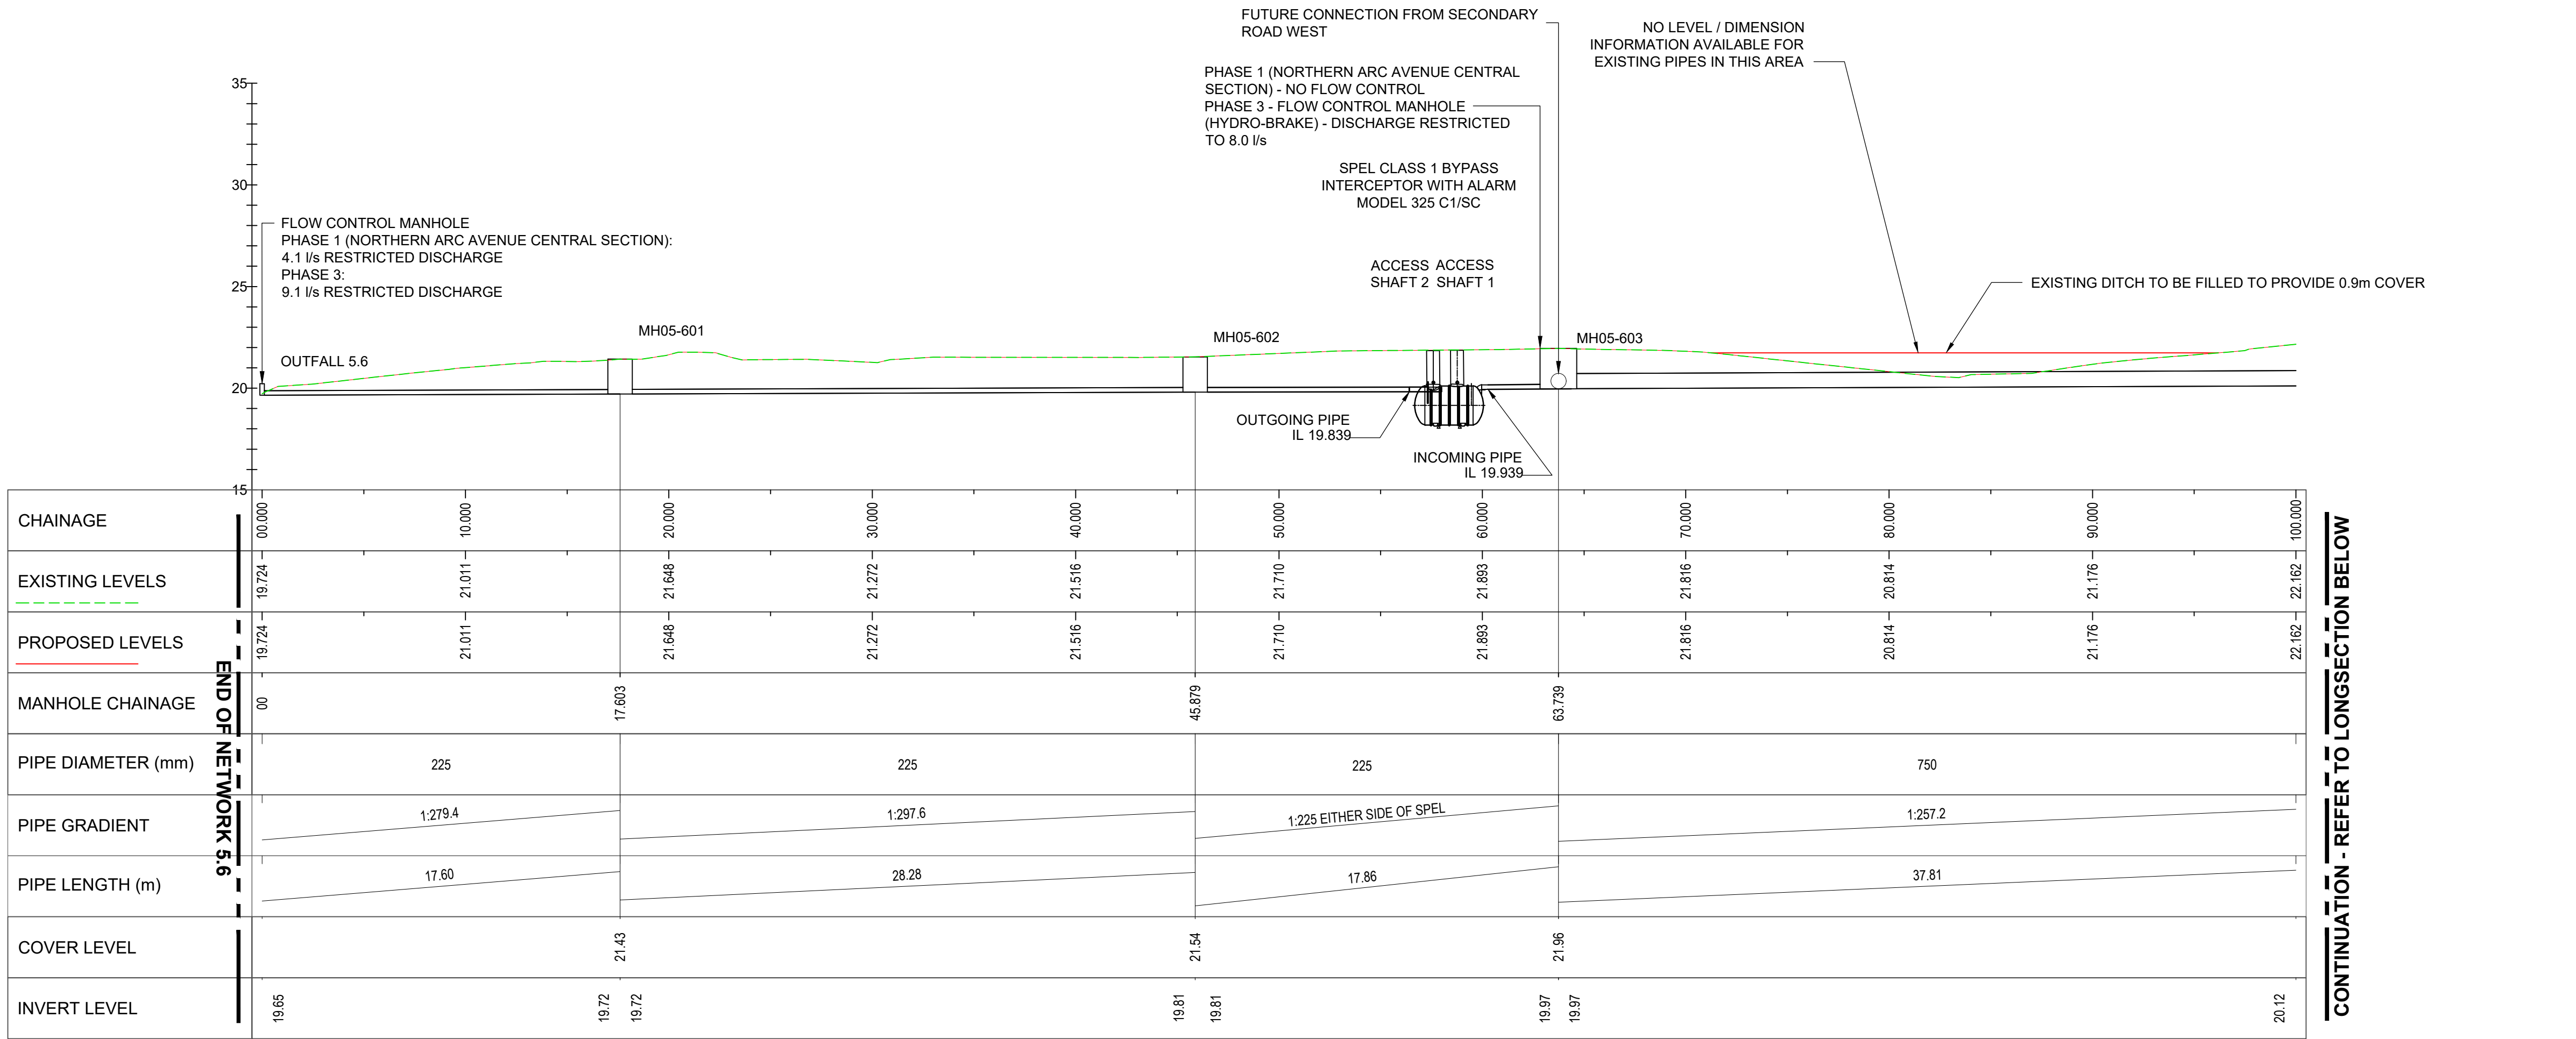

NETWORK 5.6 LONGSECTION 1 CHAINAGE 0.000 TO 100.000

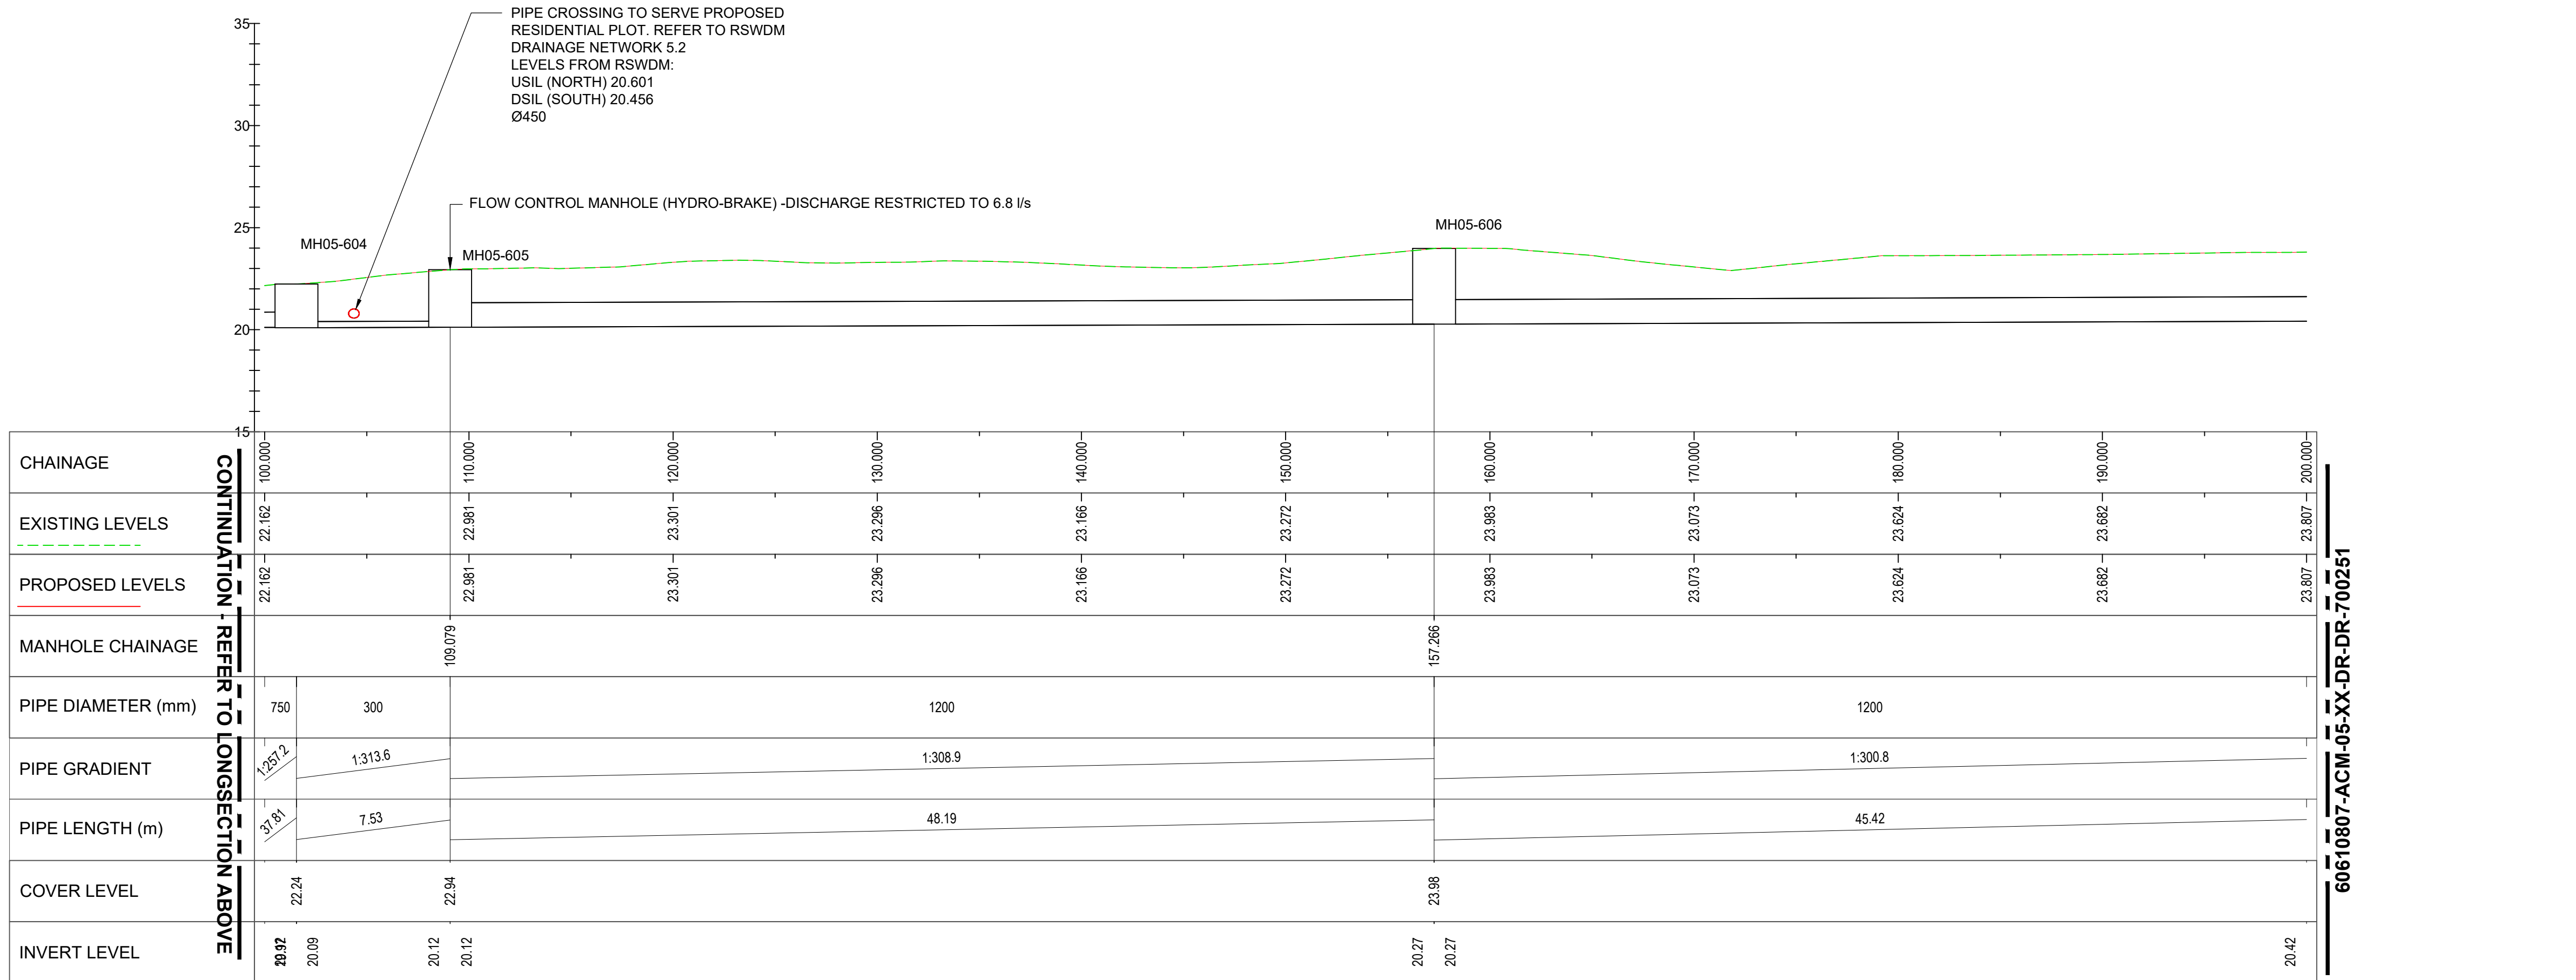

NETWORK 5.6 LONGSECTION 2 CHAINAGE 100.000 TO 200.000



PROJECT

Brookleigh -
Northern Arc avenue
Central Section

CLIENT

Homes England

CONSULTANT

AECOM
Aldgate Tower
2 Leman Street
London, E1 8FA
United Kingdom

T +44 (0)2076 452000
www.aecom.com

NOTES

- Do not scale from the drawing.
- All levels shown are in metres Above Ordnance Datum (AOD) unless stated otherwise.
- Drawing is to be read in conjunction with the following:
60610807-ACM-05-XX-DR-DR-700251
60610807-ACM-05-XX-DR-DR-700252
60610807-ACM-05-XX-DR-DR-700253
Project Specification Appendix 5/1.
- Regional SuDS arrangements shown are indicative only.
- Existing ground levels based on existing topographic survey.
- For Network 5.6 drainage layouts refer to the following:
60610807-ACM-05-XX-DR-DR-700150
60610807-ACM-05-XX-DR-DR-700151
60610807-ACM-05-XX-DR-DR-700152
- Attenuation volumes are from microdrainage model
60610807-ACM-05-XX-CU-DR-700056

KEY

- EXISTING GROUND
- PROPOSED GROUND
- CONNECTING PIPE
- PIPES
- MANHOLE
- CROSSING NETWORK / SERVICES

SUITABILITY

S3 FOR REVIEW & COMMENT

ISSUE/REVISION

P02	20.12.2024	SECOND ISSUE
P01	19.01.2024	FIRST ISSUE
I/R	DATE	DESCRIPTION

PROJECT NUMBER

60610807

SHEET TITLE

DRAINAGE NETWORK 5.6
LONGSECTION
SHEET 1 OF 4

SHEET NUMBER

60610807-ACM-05-XX-DR-DR-700250