



PROJECT

Brookleigh -  
Northern Arc avenue  
Central Section

CLIENT

Homes England

CONSULTANT

AECOM  
Aldgate Tower  
2 Leman Street  
London, E1 8FA  
United Kingdom

T +44 (0)2076 452000  
www.aecom.com

NOTES

- Do not scale from the drawing.
- All levels shown are in metres Above Ordnance Datum (AOD) unless stated otherwise.
- Drawing is to be read in conjunction with the following:  
60610807-ACM-05-XX-DR-DR-700250  
60610807-ACM-05-XX-DR-DR-700252  
60610807-ACM-05-XX-DR-DR-700253  
Project Specification Appendix 5/1.
- Regional SuDS arrangements shown are indicative only.
- Existing ground levels based on existing topographic survey.
- For Network 5.6 drainage layouts refer to the following:  
60610807-ACM-05-XX-DR-DR-700150  
60610807-ACM-05-XX-DR-DR-700151  
60610807-ACM-05-XX-DR-DR-700152
- Attenuation volumes are from microdrainage model  
60610807-ACM-05-XX-CU-DR-700056

KEY

- EXISTING GROUND
- PROPOSED GROUND
- CONNECTING PIPE
- PIPES
- MANHOLE
- CROSSING NETWORK / SERVICES

SUITABILITY

S3      FOR REVIEW & COMMENT

ISSUE/REVISION

| P02 | 20.12.2024 | SECOND ISSUE |
|-----|------------|--------------|
| P01 | 19.01.2024 | FIRST ISSUE  |
| I/R | DATE       | DESCRIPTION  |

PROJECT NUMBER


60610807

SHEET TITLE

DRAINAGE NETWORK 5.6  
LONGSECTION  
SHEET 2 OF 4



SHEET NUMBER

60610807-ACM-05-XX-DR-DR-700251

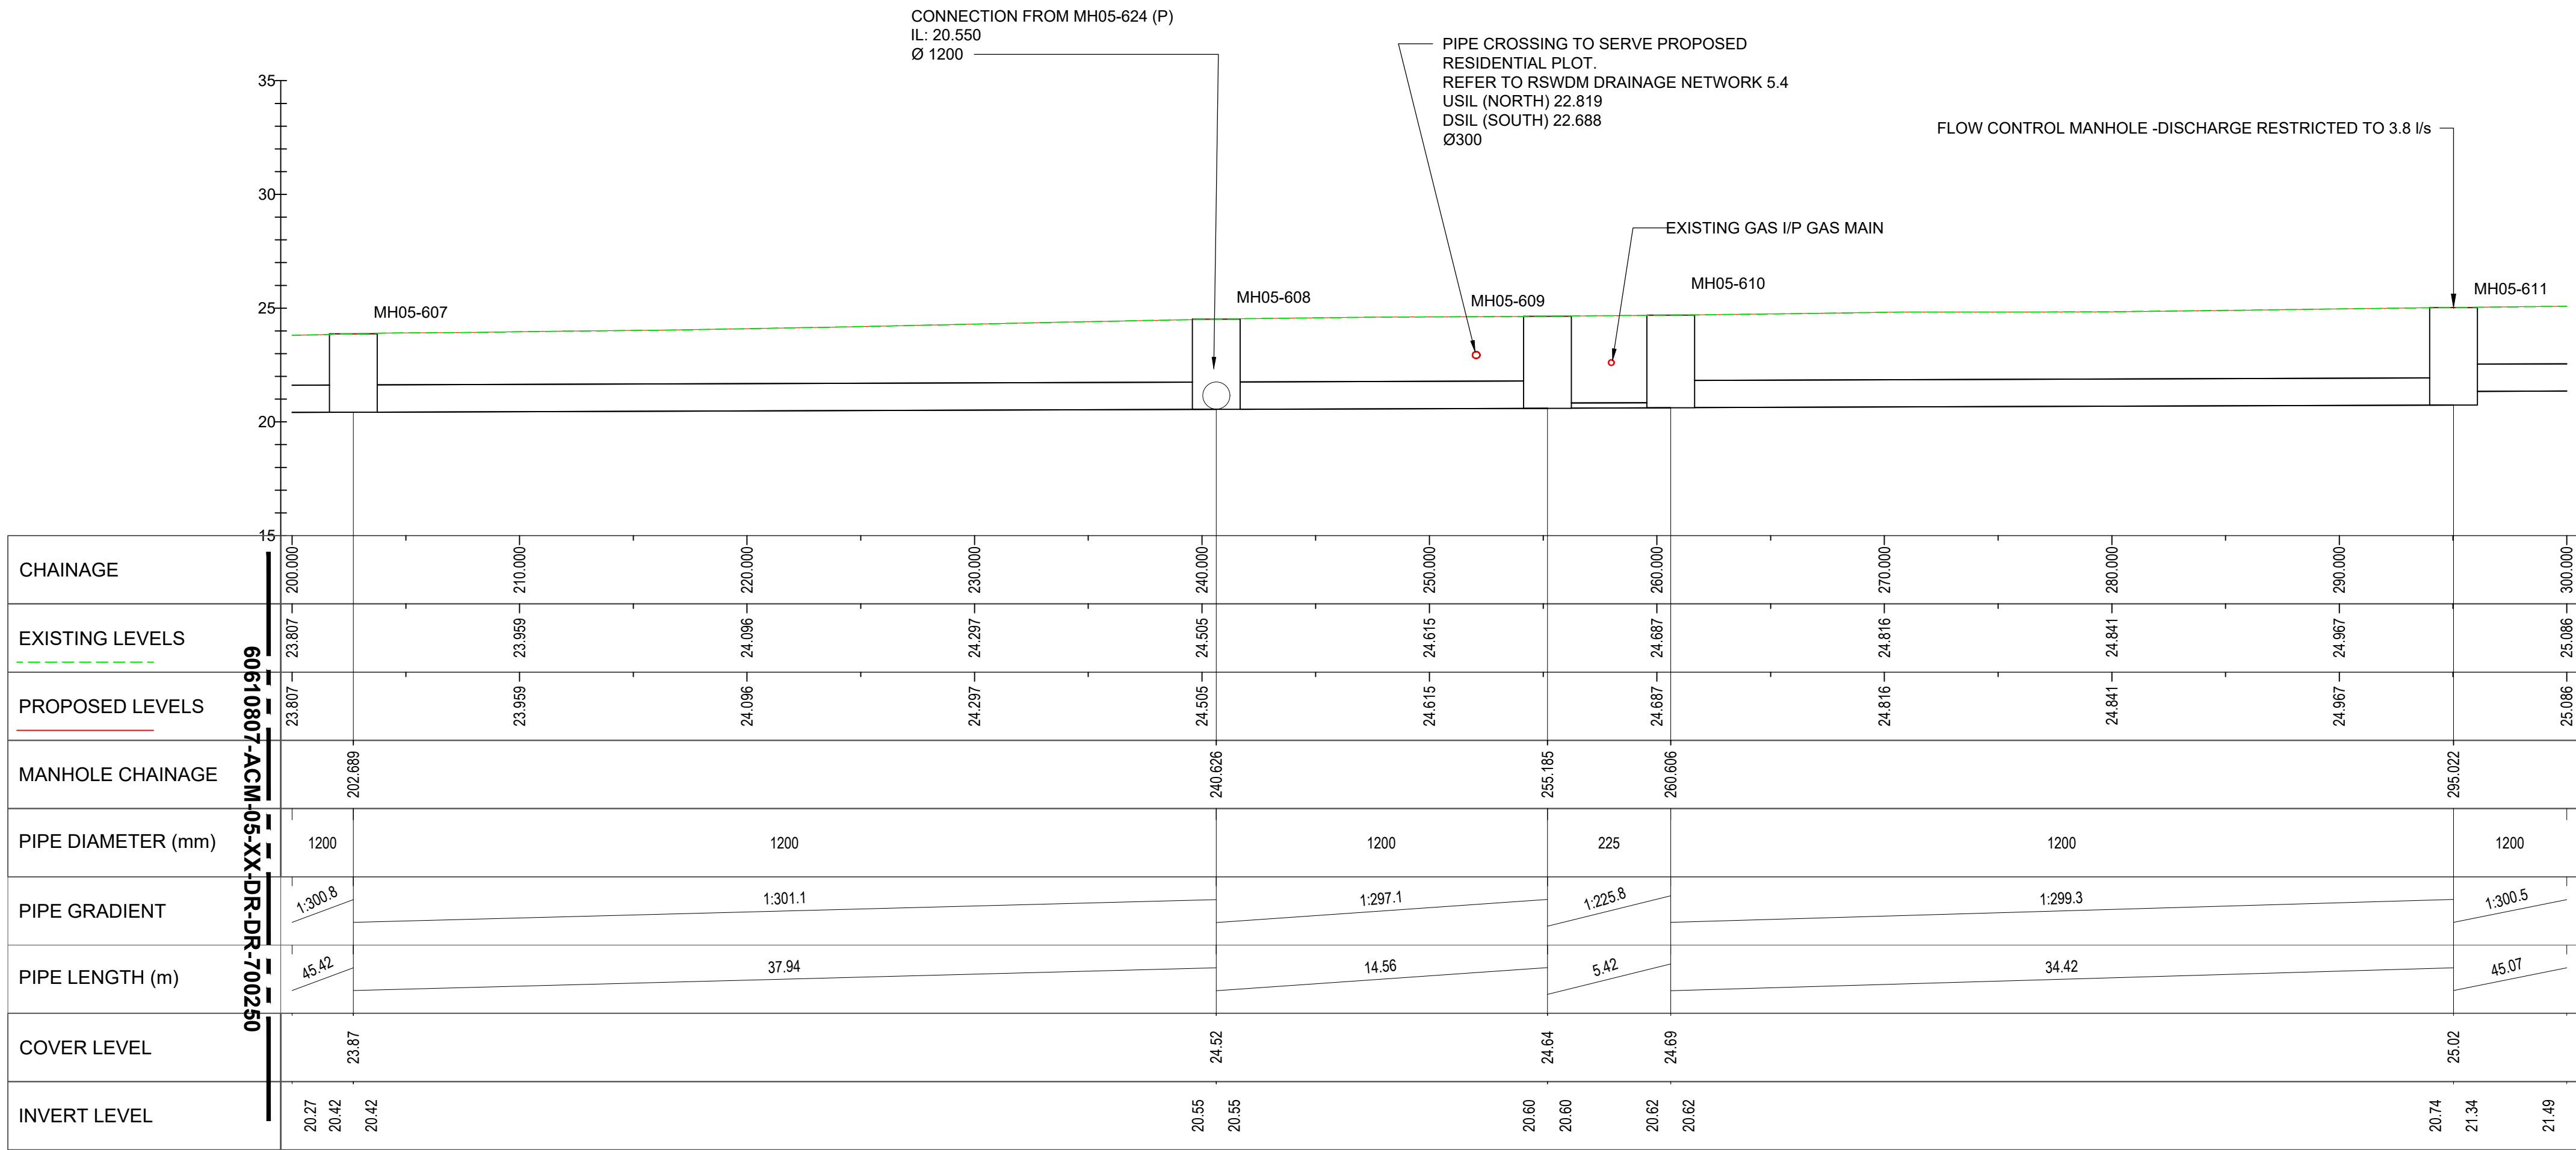

NETWORK 5.6 LONGSECTION 3 CHAINAGE 200.000 TO 300.000

 Scale 1:200

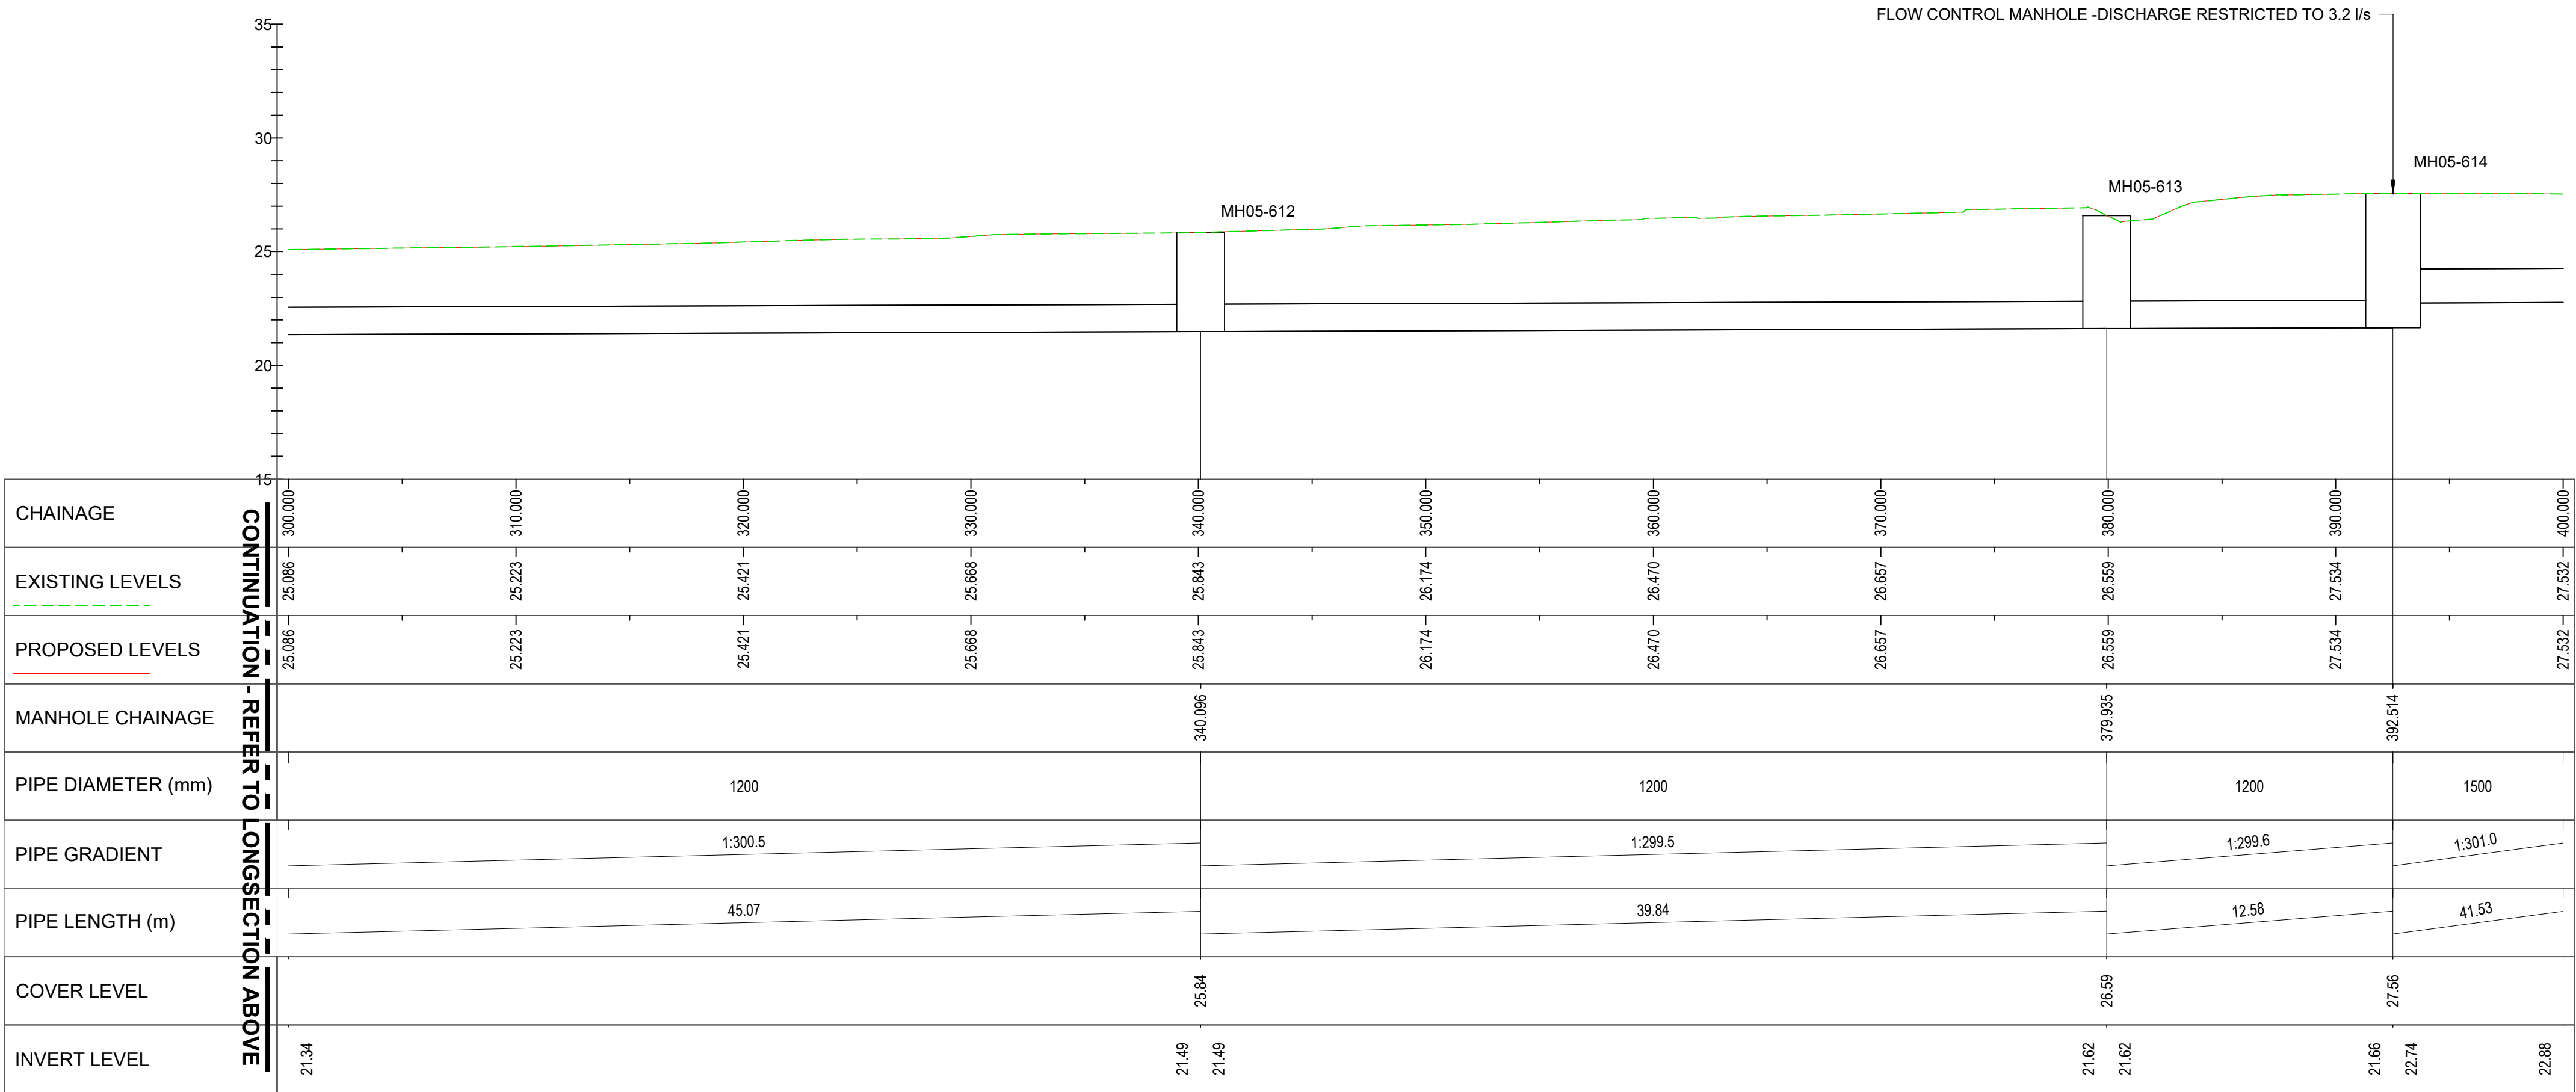

NETWORK 5.6 LONGSECTION 4 CHAINAGE 300.000 TO 400.000

Scale 1:200

