

 
 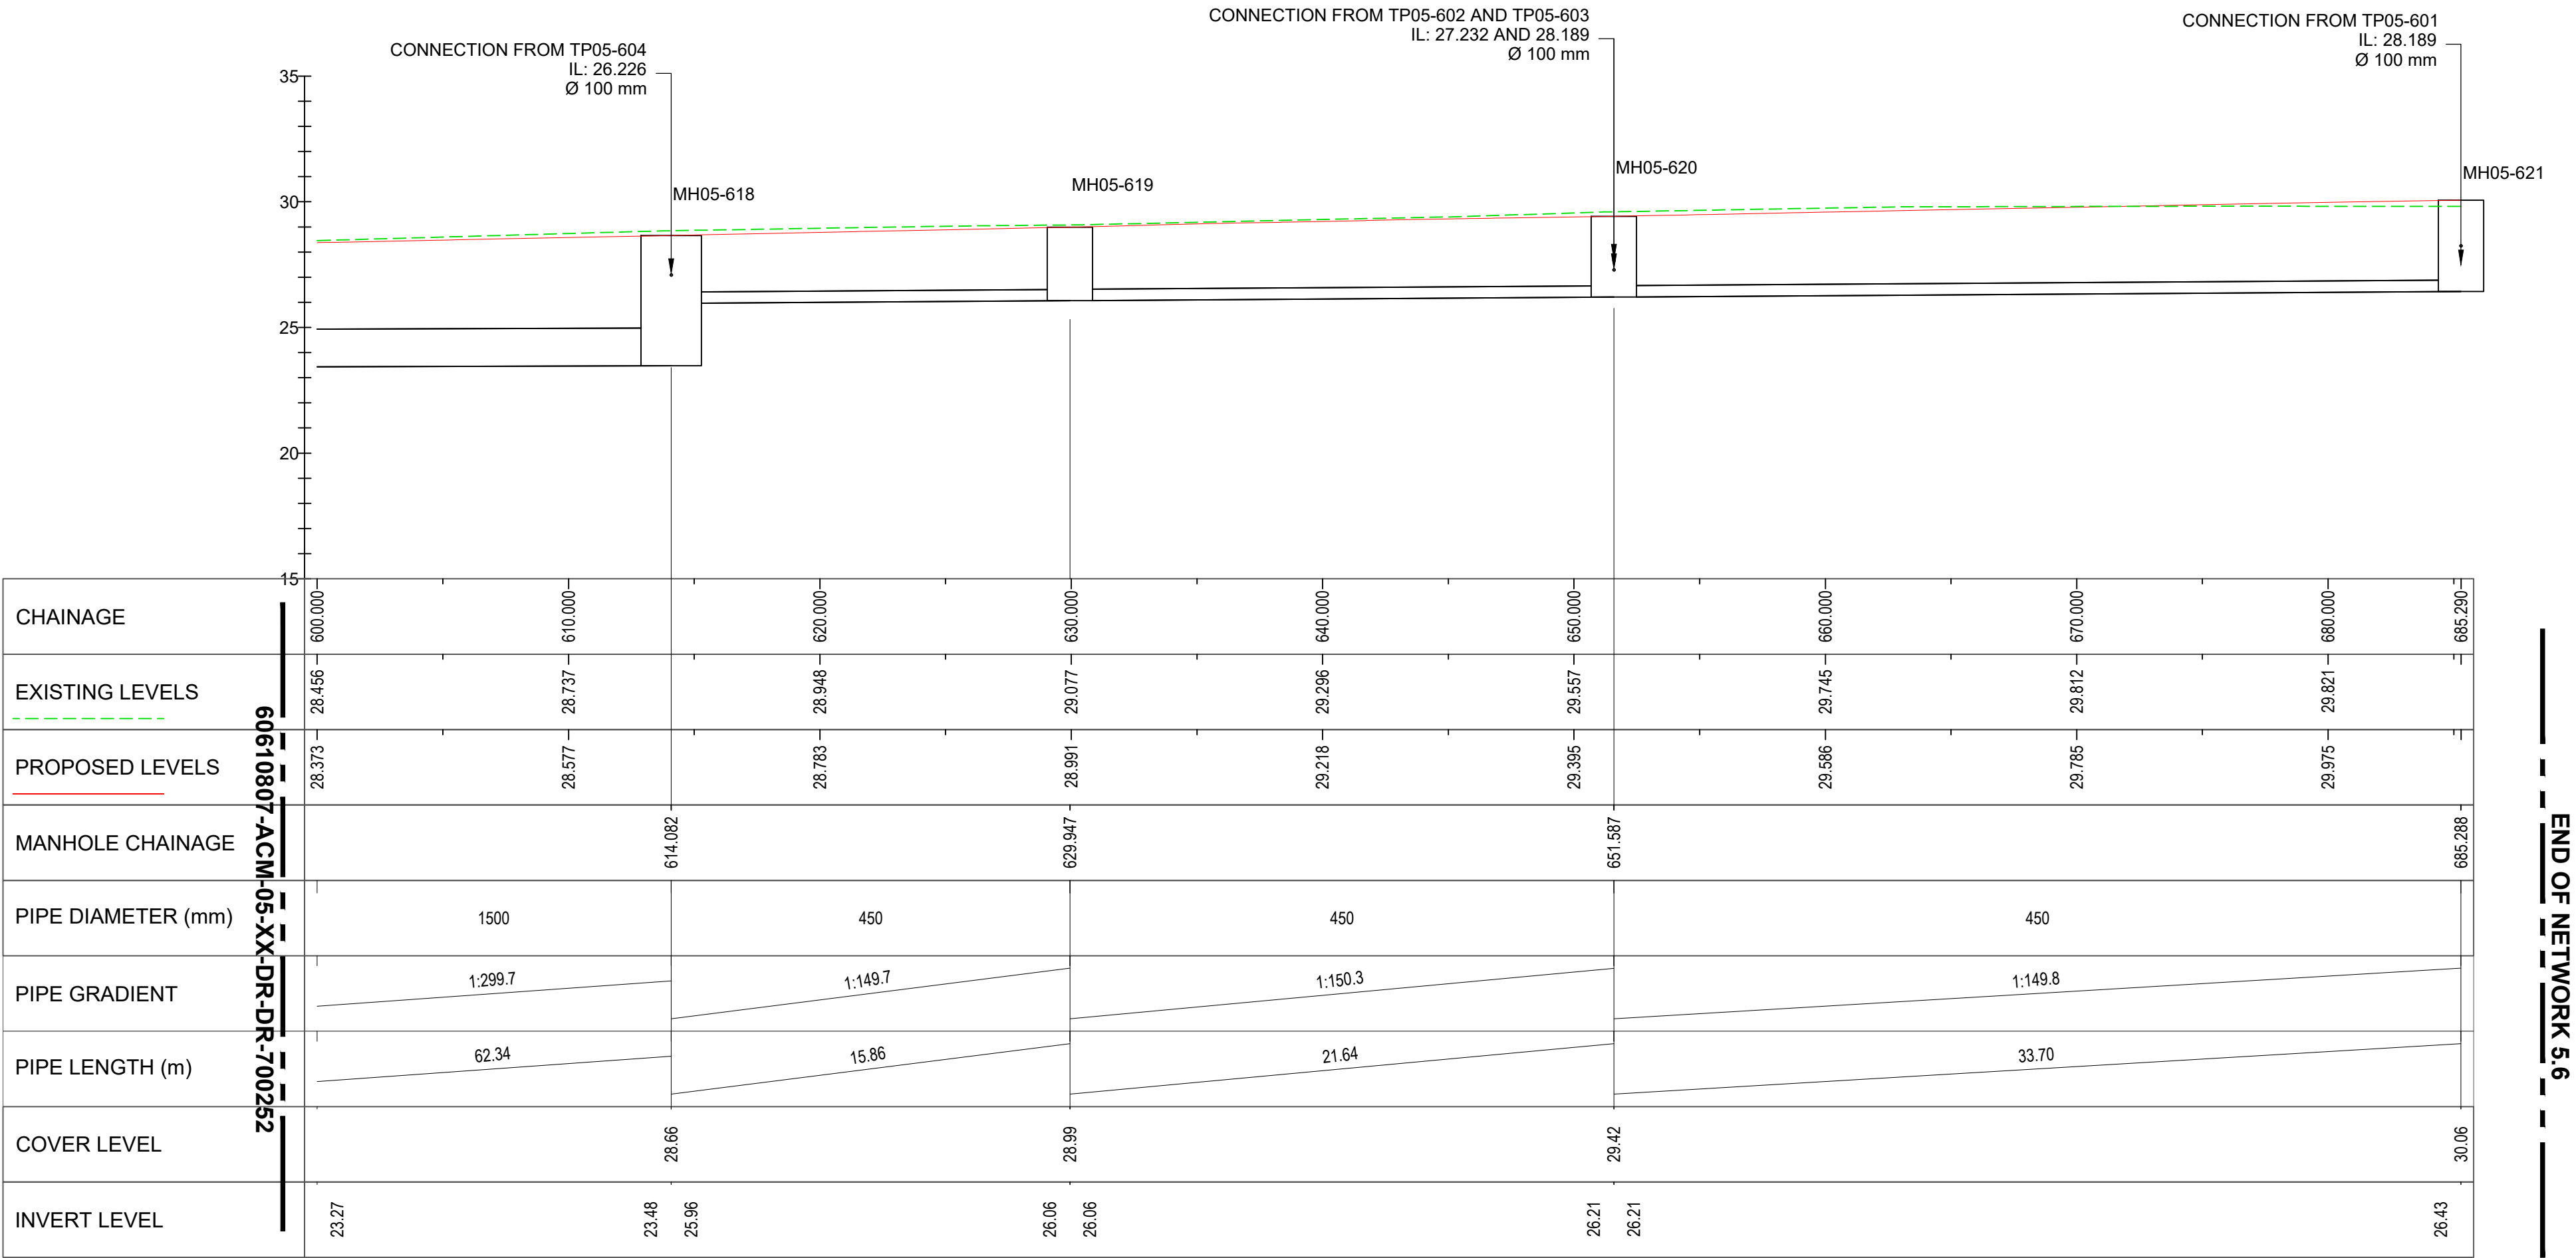


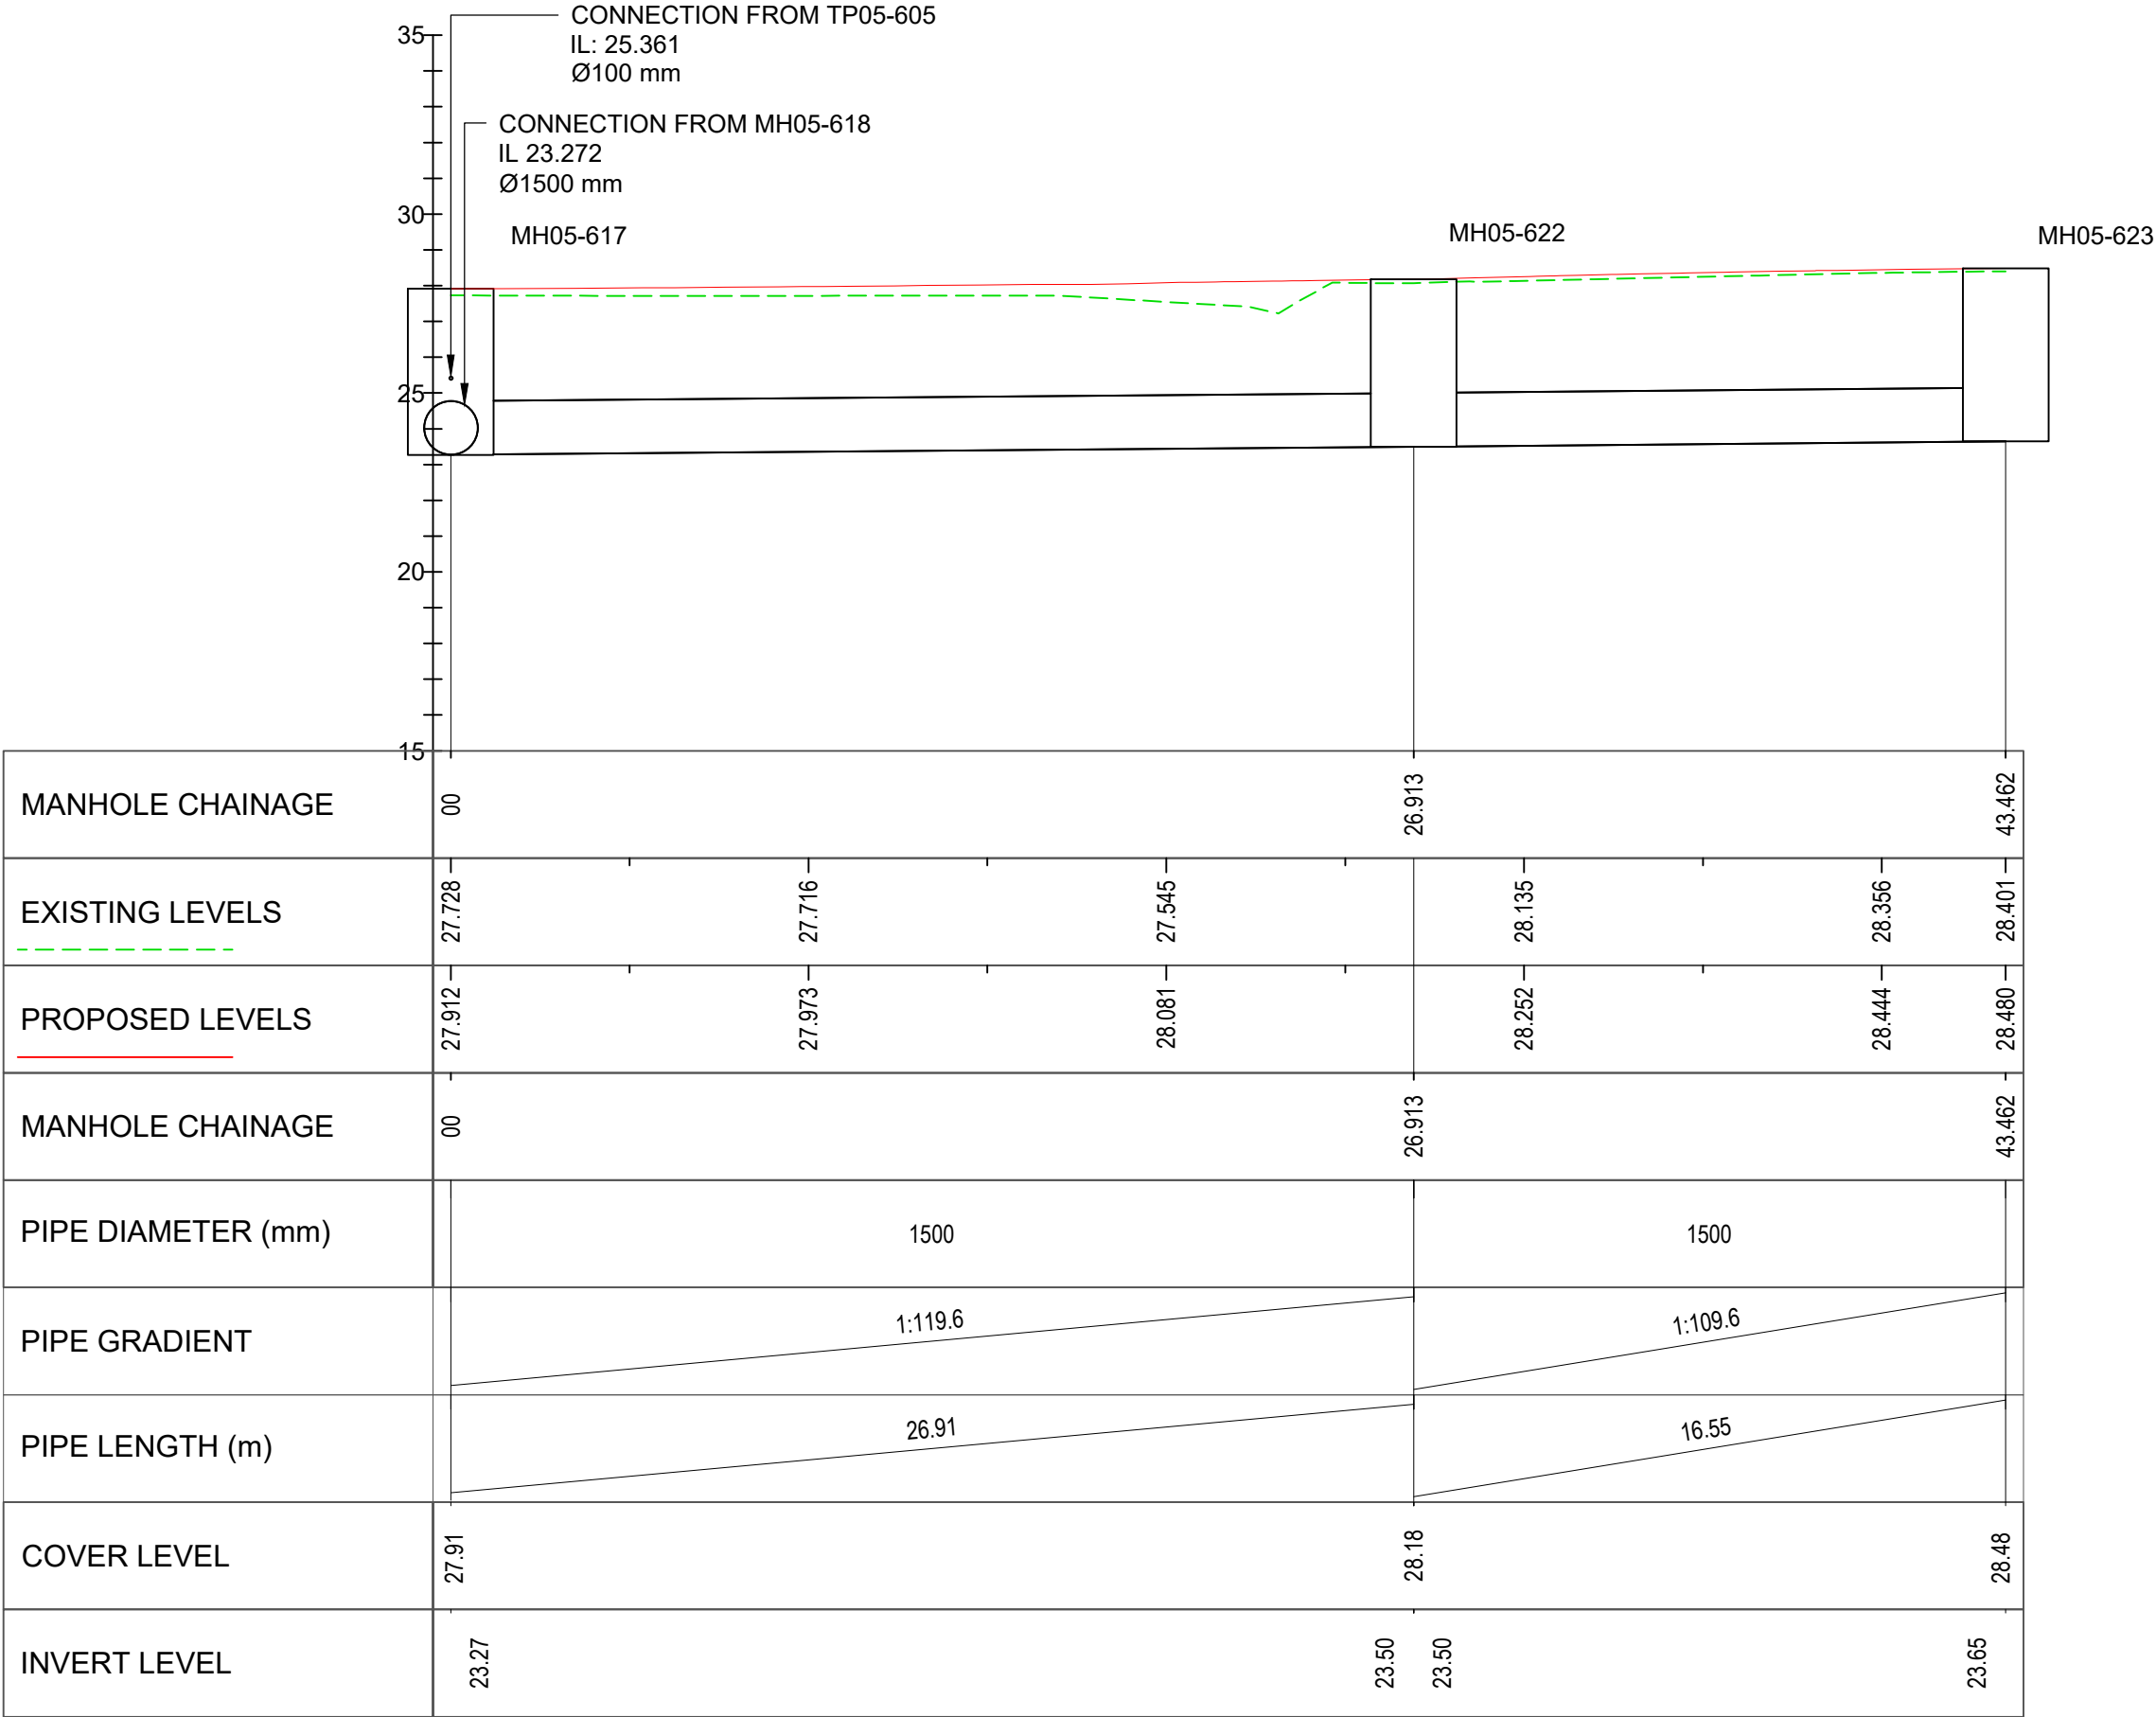

NETWORK 5.6 LONGSECTION 7 CHAINAGE 600.000 TO 685.270
Scale 1:200



NETWORK 5.6 LONGSECTION 8 MH05-617 TO MH05-623
Scale 1:200



PROJECT

Brookleigh - Northern Arc avenue Central Section

CLIENT

Homes England

CONSULTANT

AECOM
Aldgate Tower
2 Leman Street
London, E1 8FA
United Kingdom

T +44 (0)2076 452000
www.aecom.com

NOTES

- Do not scale from the drawing.
- All levels shown are in metres Above Ordnance Datum (AOD) unless stated otherwise.
- Drawing is to be read in conjunction with the following:
60610807-ACM-05-XX-DR-DR-700250
60610807-ACM-05-XX-DR-DR-700251
60610807-ACM-05-XX-DR-DR-700252
Project Specification Appendix 5/1.
- Regional SuDS arrangements shown are indicative only.
- Existing ground levels based on existing topographic survey.
- For Network 5.6 drainage layouts refer to the following:
60610807-ACM-05-XX-DR-DR-700150
60610807-ACM-05-XX-DR-DR-700151
60610807-ACM-05-XX-DR-DR-700152
- Attenuation volumes are from microdrainage model
60610807-ACM-05-XX-CU-DR-700056

KEY

- EXISTING GROUND
- PROPOSED GROUND
- CONNECTING PIPE
- PIPES
- MANHOLE
- CROSSING NETWORK / SERVICES

SUITABILITY

S3 FOR REVIEW & COMMENT

ISSUE/REVISION

P02	20.12.2024	SECOND ISSUE
P01	19.01.2024	FIRST ISSUE
I/R	DATE	DESCRIPTION

PROJECT NUMBER

60610807

SHEET TITLE

DRAINAGE NETWORK 5.6
LONGSECTION
SHEET 4 OF 4

SHEET NUMBER

60610807-ACM-05-XX-DR-DR-700253

This drawing has been prepared for the use of AECOM's client. It may not be used, modified, reproduced or relied upon by third parties, except as agreed by AECOM or as required by law. AECOM accepts no responsibility, and denies any liability whatsoever, to any party that uses or relies on this drawing without AECOM's express written consent. Do not scale this document. All measurements must be obtained from the stated dimensions.