



• THIS DOCUMENT IS COPYRIGHT OF THE ORIGINATOR AND MUST BE TREATED AS CONFIDENTIAL.
• THIS DOCUMENT MUST NOT BE ALTERED, REPRODUCED OR DISTRIBUTED WITHOUT PRIOR WRITTEN CONSENT OF THE ORIGINATOR.
• DO NOT SCALE THIS DOCUMENT. ALL DIMENSIONS MUST BE CHECKED ON SITE PRIOR TO COMMENCEMENT OF ANY RELATED WORKS.
• THIS DOCUMENT MUST BE READ IN CONJUNCTION WITH ALL SUPPORTING DOCUMENTS PRODUCED BY THE ORIGINATOR.
• USERS OF THIS DOCUMENT ARE RESPONSIBLE FOR CHECKING WHICH REVISION IS CURRENT.

Notes & Symbols:

KEY	
	Single switched socket
	Twin switched socket
	CAT6 data outlet. Number represents gangs
	Floor box - 2 x DSSO, 4 x CAT6 data
	Switched fused spur
	20A single phase isolator
	32A three phase isolator
	Fan isolator
	Distribution board
	WAP

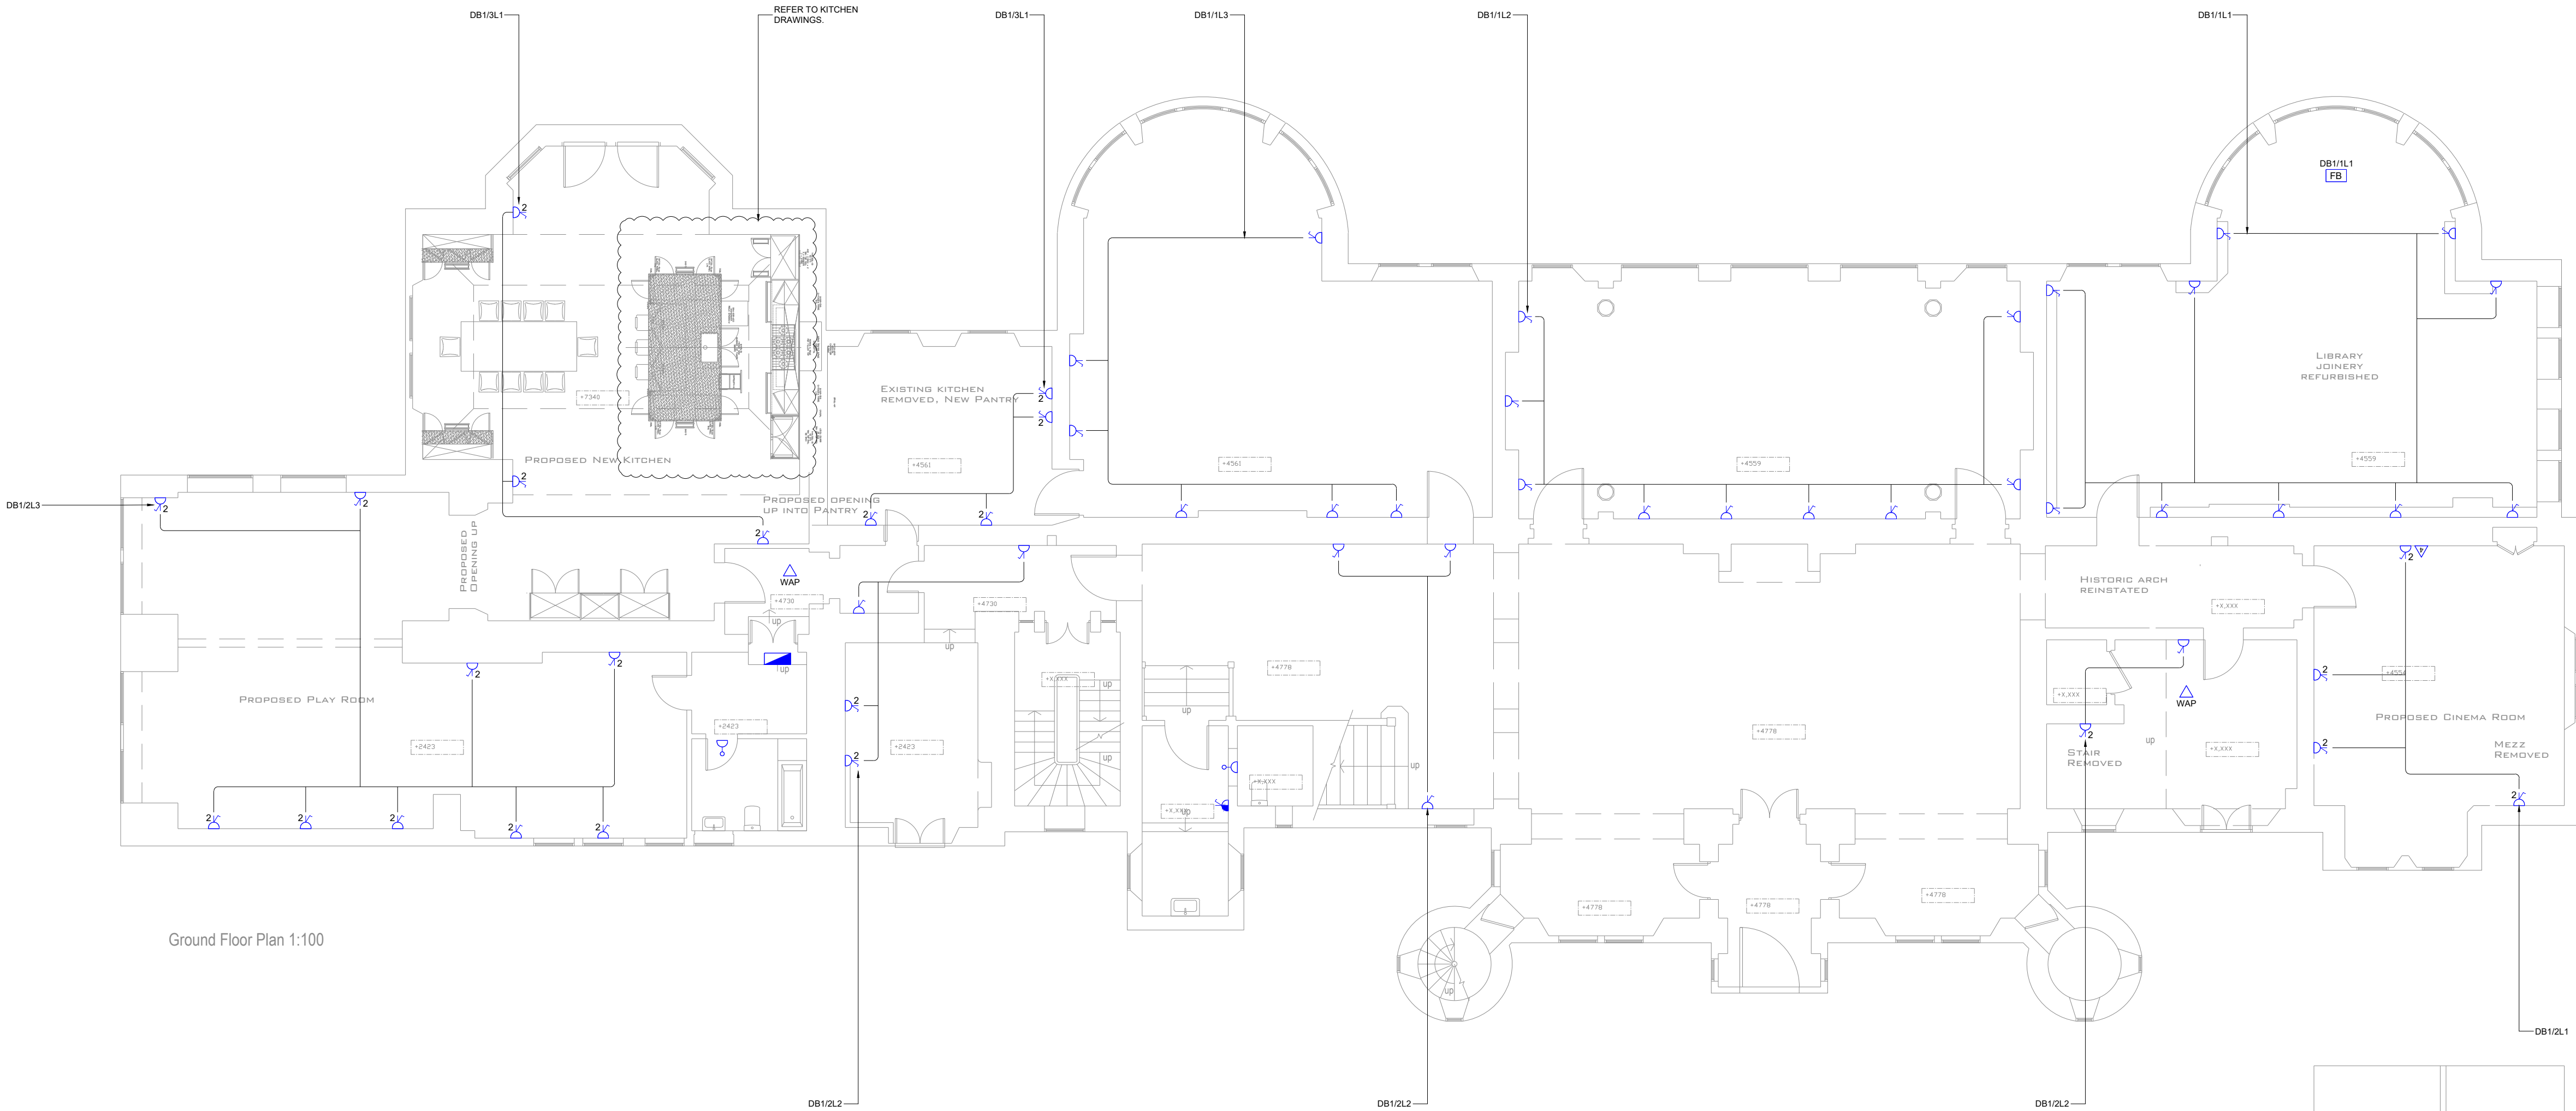

Ground Floor Plan 1:100

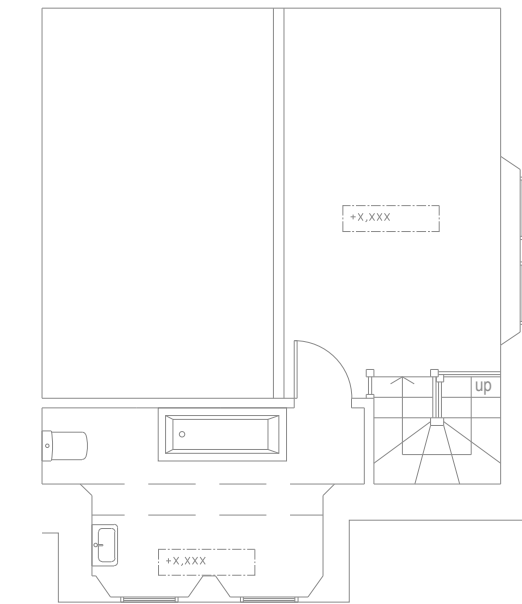

Mezzanine Floor Plan 1:100

Rev.	Date.	Description.
------	-------	--------------



Project:
WYKEHURST PLACE

Drawing Title:
GROUND FLOOR
SMALL POWER LAYOUT

Scale:
1:100@A1

Date:
14/04/25

Drawing Status:
PROPOSED

Drawing No.
04

Revision: