

NOTES - HEATING SERVICES

GENERAL NOTES

THE COMPLETE MECHANICAL AND ELECTRICAL INSTALLATION SHALL BE INSTALLED AND COMMISSIONED IN ACCORDANCE WITH JOULE MECHANICAL AND ELECTRICAL INSTALLATION GUIDELINES PROVIDED WITH THE HEATING SYSTEM.

- FOR A DETAILED OVERVIEW OF THE HEATING SYSTEM, PLEASE REFER TO THE SYSTEM DRAWING SCHEMATICS.
- ALL PIPEWORK SIZES NOTED REFER TO THE NOMINAL PIPE DIAMETER.
- ALL PIPEWORK SHALL BE THERMALLY INSULATED IN ACCORDANCE WITH BS 5422: 2023.
- JOULE RECOMMENDS THAT ALL JOINTS THAT ARE TO BE SOLDERED SHOULD BE MADE USING A FLUX THAT IS SPARINGLY APPLIED AND ANY RESIDUE IS FLUSHED OUT OF THE SYSTEM BEFORE COMMISSIONING.

HEAT PUMP

- THE HEAT PUMP SHALL BE A MONO-BLOCK UNIT TYPE C/W INDOOR HOT WATER CYLINDER, HOT WATER PRIORITY, INTERNAL UNIT TO LOCATED WITHIN PLANTROOM, EXTERNAL UNIT EXACT LOCATION TO BE AGREED WITH ARCHITECT.
- THE HOT WATER CYLINDER SHALL BE PRE-PLUMBED VALVE SET AND COME WITH 1NO. 3KW IMMERSION HEATERS, EXPANSION VESSEL, PACKAGED CONTROLS ETC.

UNDERFLOOR HEATING SYSTEM

- **DO NOT CUT PIPES TO LENGTH PRIOR TO INSTALLATION:** THE LENGTHS OF PIPE LOOPS SHOWN ARE FOR GUIDANCE PURPOSES ONLY.
- **INSTALL MANIFOLDS AT THE CORRECT HEIGHT:** UNDERFLOOR PIPE MANIFOLDS SHOULD BE INSTALLED AT A HEIGHT AT LEAST 600mm FROM THE FINISHED FLOOR UNLESS OTHERWISE SPECIFIED.
- **FOLLOW MAXIMUM PIPE LENGTH RECOMMENDATIONS:** THE MAXIMUM RECOMMENDED PIPE LENGTH FOR 16mm PIPE IS 100m AND FOR 12mm PIPE IS 75m.
- **ADHERE TO PIPE CENTRE RECOMMENDATIONS:** RECOMMENDED 16mm PIPE CENTRES ARE 150mm WHEN USING A LOW TEMPERATURE HEAT SOURCE, SUCH AS A HEAT PUMP, OR 200mm WHEN USING A HIGH TEMPERATURE HEAT SOURCE.
- **MIXING SETS:** MIXING SETS ARE REQUIRED WITH HIGH TEMPERATURE HEAT SOURCES. WHEN USING A LOW TEMPERATURE HEAT SOURCE, MIXING SETS MAY NOT BE REQUIRED.
- **CIRCULATION PUMP:** IT IS RECOMMENDED TO FIT A CIRCULATION PUMP TO THE MANIFOLD IF A MIXING SET IS NOT INSTALLED TO GUARANTEE CIRCULATION THROUGH THE UNDERFLOOR LOOPS.
- **INSTALL A BYPASS VALVE:** A BYPASS VALVE MUST BE INSTALLED ON THE PRIMARY PIPEWORK TO THE UNDERFLOOR HEATING MANIFOLD.
- **FOLLOW THE LAYOUT SCHEMATIC:** ADHERE TO THE LAYOUT SCHEMATIC PROVIDED FOR PIPE LAYOUT.
- **INSTALL PIPE FLOW AROUND THE ROOM PERIMETER FIRST:** THE PIPE FLOW SHOULD BE INSTALLED AROUND THE PERIMETER OF THE ROOM FIRST TO PREVENT ANY POTENTIAL COLD SPOTS IN THE FLOOR IN THESE AREAS.
- **PRESSURE TESTING:** PRESSURE TESTING MUST BE CARRIED OUT PRIOR TO THE LAYING OF SCREED. AIR (NOT WATER) MUST BE USED FOR PERIODS OF PROLONGED PRESSURE TESTING.
- **FLOOR COVERING:** FLOOR COVERINGS SHOULD BE SUITABLE FOR USE WITH UNDERFLOOR HEATING. IF CARPETS ARE FITTED, THE UNDERLAY MUST HAVE A TOG NO GREATER THAN 1 WITH THE CARPET HAVING A TOG NO GREATER THAN 1.5, OR HAVE A MAXIMUM THERMAL RESISTANCE OF 0.15m²/K/W.
- **SCREED CURING:** CONCRETE SCREED FLOORS MUST BE CURED BEFORE HEAT IS APPLIED. ALLOW 1 DAY PER 2mm OF SCREED BEFORE TURNING ON THE HEATING SYSTEM.
- **FLOW TEMPERATURE:** WHEN TURNING HEAT ON IN A NEW PROPERTY, THE FLOW TEMPERATURE INTO THE PIPEWORK FROM THE HEAT SOURCE MUST BE INITIALLY SET TO 28° DEGREES CELSIUS. THE TEMPERATURE INCREASE SHOULD BE NO MORE THAN 2° DEGREES PER 24 HOURS UNTIL THE DESIRED FLOW TEMPERATURE IS REACHED.

RADIATOR INSTALLATION

- ALL RADIATORS TO BE SUPPLIED AND INSTALLED IN ACCORDANCE WITH JOULE INSTALLATION GUIDELINES AND OPERATIONS MANUAL.
- PRIOR TO ORDER OF THE RADIATORS THE CONTRACTOR SHALL VERIFY & CO-ORDINATE ALL RADIATORS SPECIFIED ON SITE. REFER TO ARCHITECTURAL LAYOUTS FOR SETTING OUT OF RADIATORS.
- ALL FINAL CONNECTIONS TO RADIATORS TO BE Ø15mm F&R.


ELECTRICAL NOTES

- THE UNDERFLOOR WIRING CENTRE REQUIRES ITS OWN 3 CORE SUPPLY FROM A 5A SUPPLY USING A 3 CORE 1.5mm CABLE. THE CONTROLLER MUST BE LOCATED IN CLOSE PROXIMITY TO THE UNDERFLOOR MAINFOLD. A 2 CORE 1.5mm CABLE IS REQUIRED TO PROVIDE A RUN SIGNAL BETWEEN THE UNDERFLOOR WIRING CENTRE AND THE ROOMS. THE PULSED UNDERFLOOR WIRING CENTRE CAN BE CONNECTED TO A MAXIMUM OF 8 INDIVIDUAL ROOM STATS.
- 12V: WHEN USING 12V TEMPERATURE ROOM STATS, USE A CAT 5 / CAT 6 SHIELDED CABLE BETWEEN EACH ROOM STAT AND ITS RELEVANT UNDERFLOOR CONTROLLER.
- 230V: WHEN USING 230V TEMPERATURE ROOM STATS, THE CABLE SHOULD BE 3 CORE 1.5mm CABLE BETWEEN EACH ROOM AND ITS RELEVANT UNDERFLOOR CONTROLLER.





ADDITIONAL NOTES

- **THIS DESIGN PACKAGE, PREPARED AND COPYRIGHTED BY JOULE: IT IS INTENDED FOR CONFIDENTIAL USE BY OUR CLIENT OR THEIR DESIGNATED PARTIES FOR EQUIPMENT INSTALLATION PURPOSES.**
- **SAFETY RESPONSIBILITY: INSTALLERS SHOULD ADHERE TO THEIR OWN CDM GUIDELINES WHEN HANDLING AND INSTALLING POTENTIALLY HEAVY EQUIPMENT.**
- **REGULATORY RESPONSIBILITY: INSTALLERS' MUST ENSURE ALL SPACE HEATING AND DOMESTIC HOT WATER INSTALLATIONS COMPLY WITH LOCAL BUILDING REGULATIONS AND STANDARDS.**

HEATING PIPEWORK REFERENCE KEY


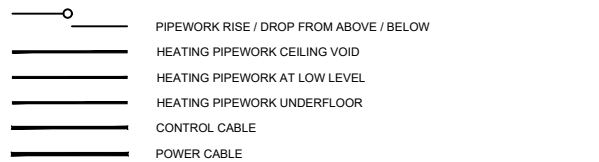


HEATING SERVICES REFERENCE KEY

  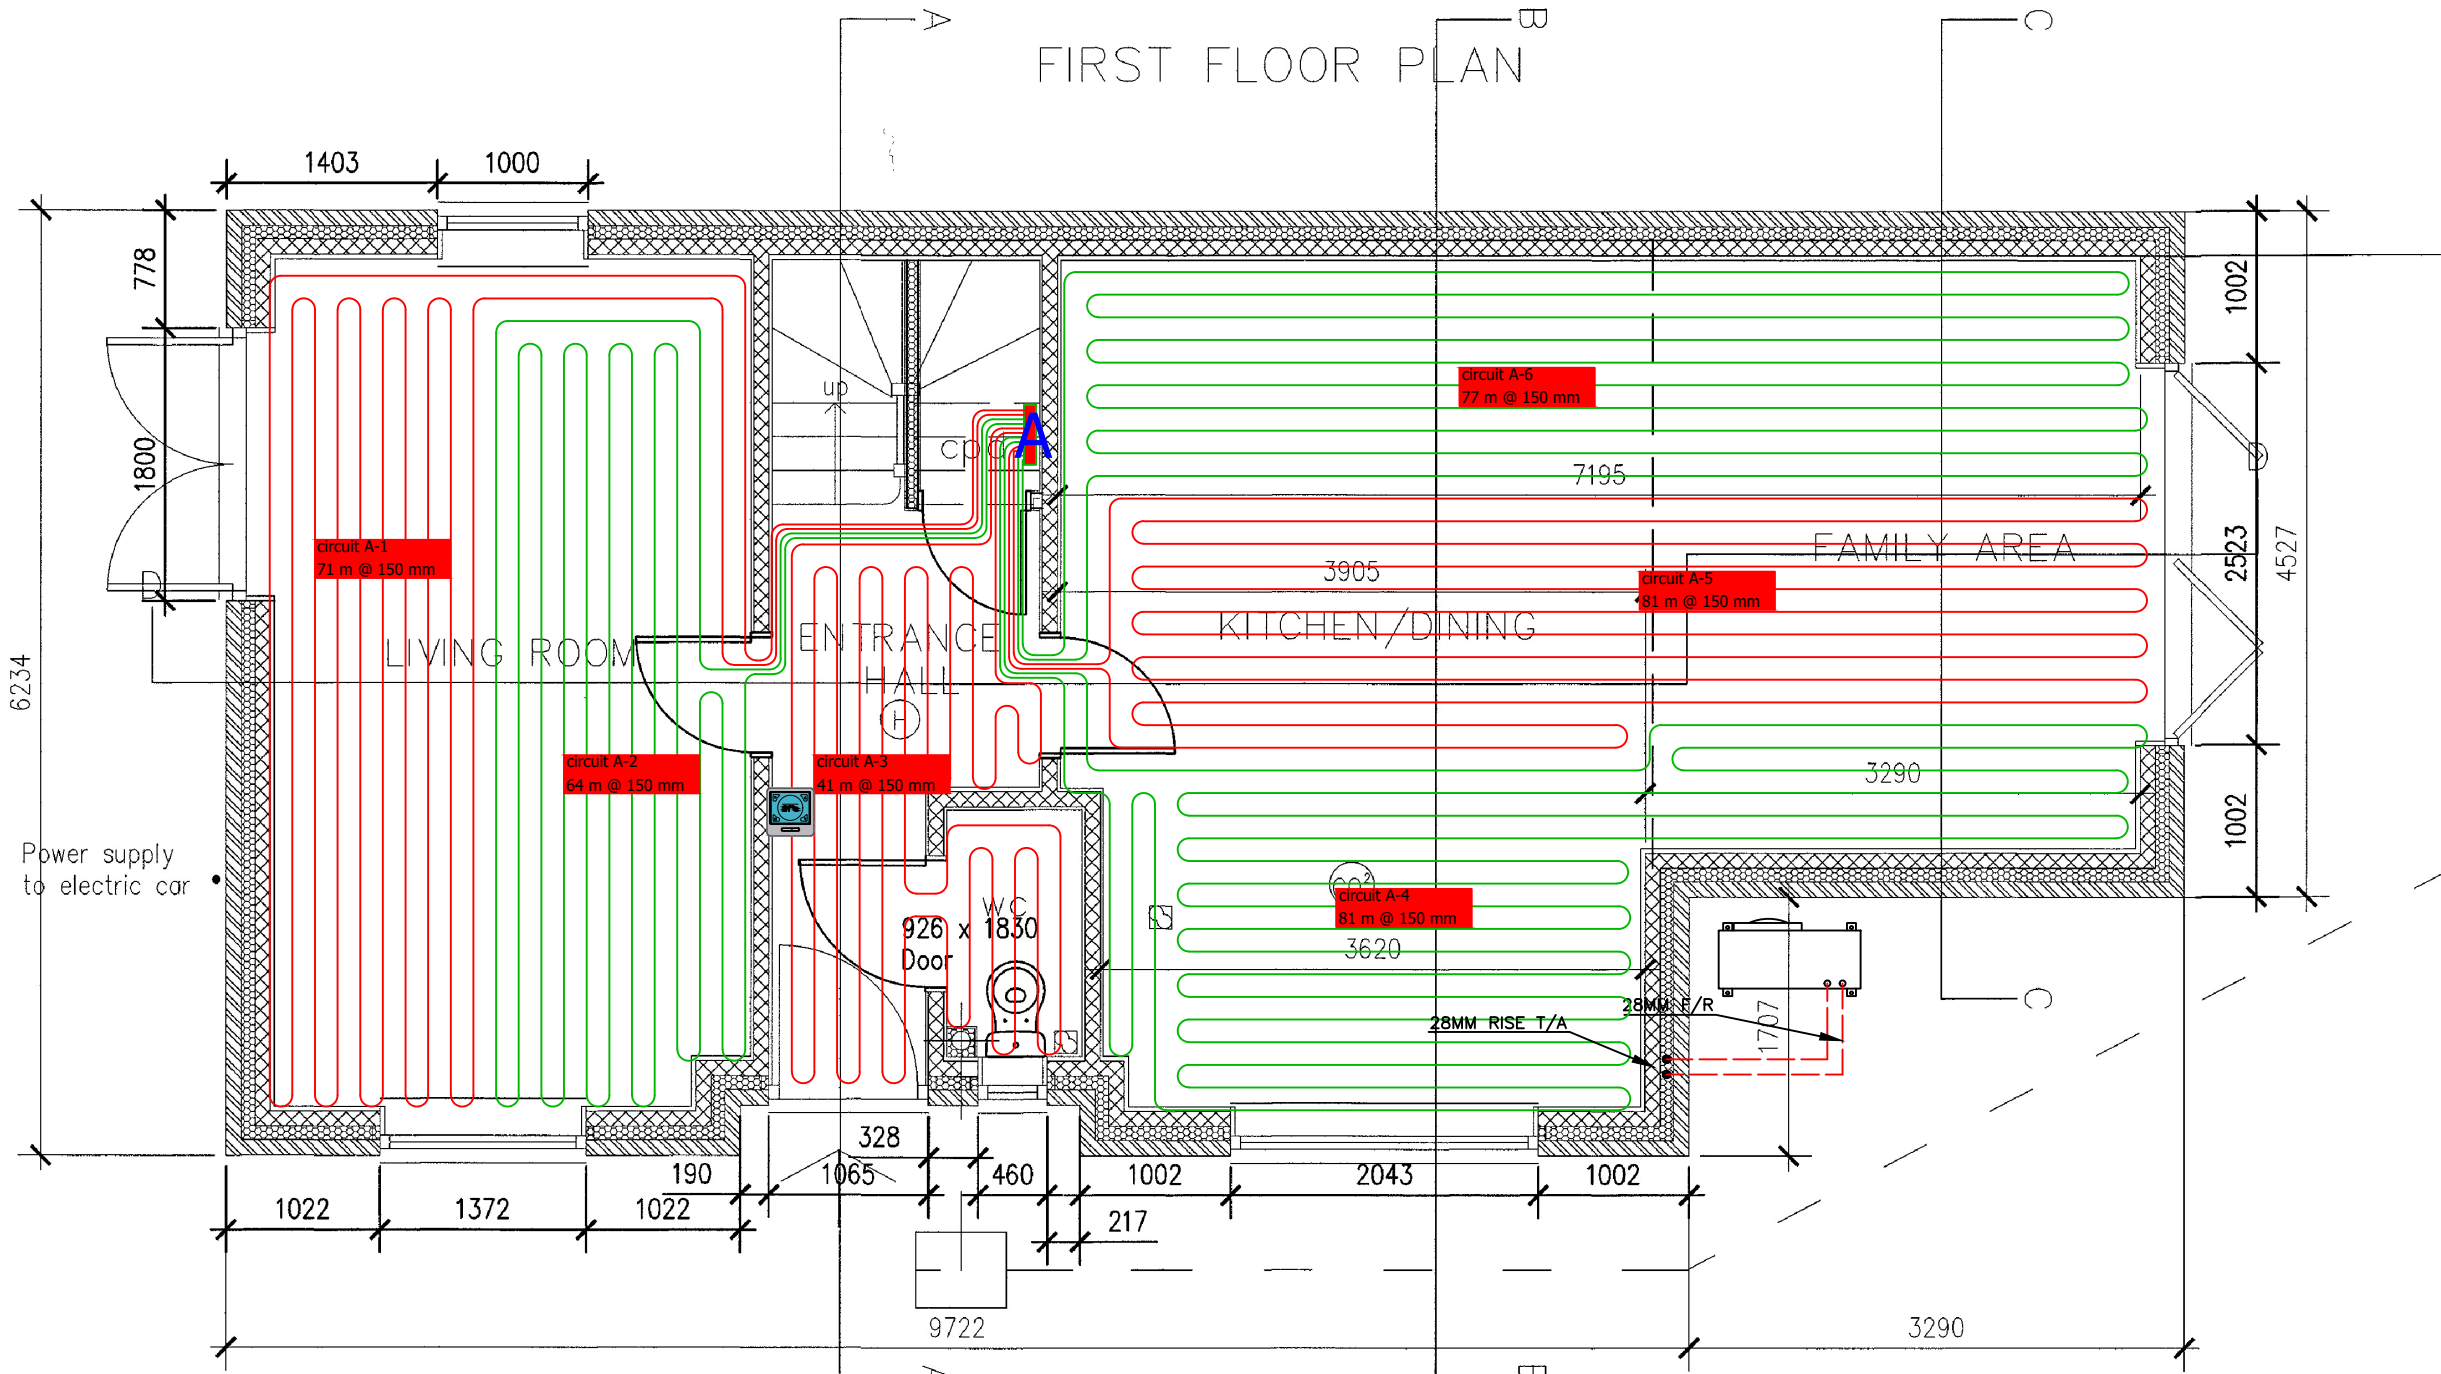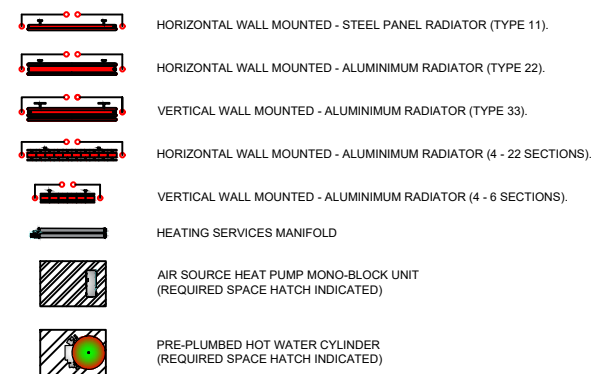

GROUND FLOOR PLAN

 (Gross internal floor area = 133.80m²)

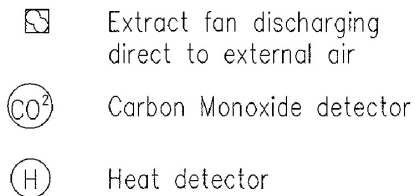

DRAWING TYPE CENTRAL HEATING	PROJECT Rear of 6 Petlands Road, Haywards Heath	DWG NO:	310631806177	 
DRAWING TITLE GROUND FLOOR	CLIENT	ISSUE DATE:	25/06/2026	
DWELLING TYPE HOUSE	ON BEHALF OF JOULE HEATING SOLUTIONS	SCALE:	1:50 @ A3	
		REVISION:	01	

NOTES - HEATING SERVICES

GENERAL NOTES

- THE COMPLETE MECHANICAL AND ELECTRICAL INSTALLATION SHALL BE INSTALLED AND COMMISSIONED IN ACCORDANCE WITH JOULE MECHANICAL AND ELECTRICAL INSTALLATION GUIDELINES PROVIDED WITH THE HEATING SYSTEM.
- FOR A DETAILED OVERVIEW OF THE HEATING SYSTEM, PLEASE REFER TO THE SYSTEM DRAWING SCHEMATICS.
 - ALL PIPEWORK SIZES NOTED REFER TO THE NOMINAL PIPE DIAMETER.
 - ALL PIPEWORK SHALL BE THERMALLY INSULATED IN ACCORDANCE WITH BS 5422: 2023.
 - JOULE RECOMMENDS THAT ALL JOINTS THAT ARE TO BE SOLDERED SHOULD BE MADE USING A FLUX THAT IS SPARINGLY APPLIED AND ANY RESIDUE IS FLUSHED OUT OF THE SYSTEM BEFORE COMMISSIONING.

HEAT PUMP

- THE HEAT PUMP SHALL BE A MONO-BLOCK UNIT TYPE C/W INDOOR HOT WATER CYLINDER, HOT WATER PRIORITY, INTERNAL UNIT TO LOCATED WITHIN PLANTROOM, EXTERNAL UNIT EXACT LOCATION TO BE AGREED WITH ARCHITECT.
- THE HOT WATER CYLINDER SHALL BE PRE-PLUMBED VALVE SET AND COME WITH 1NO. 3KW IMMERSION HEATERS, EXPANSION VESSEL, PACKAGED CONTROLS ETC.

UNDERFLOOR HEATING SYSTEM

- DO NOT CUT PIPES TO LENGTH PRIOR TO INSTALLATION:** THE LENGTHS OF PIPE LOOPS SHOWN ARE FOR GUIDANCE PURPOSES ONLY.
- INSTALL MANIFOLDS AT THE CORRECT HEIGHT:** UNDERFLOOR PIPE MANIFOLDS SHOULD BE INSTALLED AT A HEIGHT AT LEAST 600mm FROM THE FINISHED FLOOR UNLESS OTHERWISE SPECIFIED.
- FOLLOW MAXIMUM PIPE LENGTH RECOMMENDATIONS:** THE MAXIMUM RECOMMENDED PIPE LENGTH FOR 16mm PIPE IS 100m AND FOR 12mm PIPE IS 75m.
- ADHERE TO PIPE CENTRE RECOMMENDATIONS:** RECOMMENDED 16mm PIPE CENTRES ARE 150mm WHEN USING A LOW TEMPERATURE HEAT SOURCE, SUCH AS A HEAT PUMP, OR 200mm WHEN USING A HIGH TEMPERATURE HEAT SOURCE.
- MIXING SETS:** MIXING SETS ARE REQUIRED WITH HIGH TEMPERATURE HEAT SOURCES. WHEN USING A LOW TEMPERATURE HEAT SOURCE, MIXING SETS MAY NOT BE REQUIRED.
- CIRCULATION PUMP:** IT IS RECOMMENDED TO FIT A CIRCULATION PUMP TO THE MANIFOLD IF A MIXING SET IS NOT INSTALLED TO GUARANTEE CIRCULATION THROUGH THE UNDERFLOOR LOOPS.
- INSTALL A BYPASS VALVE:** A BYPASS VALVE MUST BE INSTALLED ON THE PRIMARY PIPEWORK TO THE UNDERFLOOR HEATING MANIFOLD.
- FOLLOW THE LAYOUT SCHEMATIC:** ADHERE TO THE LAYOUT SCHEMATIC PROVIDED FOR PIPE LAYOUT.
- INSTALL PIPE FLOW AROUND THE ROOM PERIMETER FIRST:** THE PIPE FLOW SHOULD BE INSTALLED AROUND THE PERIMETER OF THE ROOM FIRST TO PREVENT ANY POTENTIAL COLD SPOTS IN THE FLOOR IN THESE AREAS.
- PRESSURE TESTING:** PRESSURE TESTING MUST BE CARRIED OUT PRIOR TO THE LAYING OF SCREED. AIR (NOT WATER) MUST BE USED FOR PERIODS OF PROLONGED PRESSURE TESTING.
- FLOOR COVERING:** FLOOR COVERINGS SHOULD BE SUITABLE FOR USE WITH UNDERFLOOR HEATING. IF CARPETS ARE FITTED, THE UNDERLAY MUST HAVE A TOG NO GREATER THAN 1 WITH THE CARPET HAVING A TOG NO GREATER THAN 1.5, OR HAVE A MAXIMUM THERMAL RESISTANCE OF 0.15m²/K/W.
- SCREED CURING:** CONCRETE SCREED FLOORS MUST BE CURED BEFORE HEAT IS APPLIED. ALLOW 1 DAY PER 2mm OF SCREED BEFORE TURNING ON THE HEATING SYSTEM.
- FLOW TEMPERATURE:** WHEN TURNING HEAT ON IN A NEW PROPERTY, THE FLOW TEMPERATURE INTO THE PIPEWORK FROM THE HEAT SOURCE MUST BE INITIALLY SET TO 28° DEGREES CELSIUS. THE TEMPERATURE INCREASE SHOULD BE NO MORE THAN 2° DEGREES PER 24 HOURS UNTIL THE DESIRED FLOW TEMPERATURE IS REACHED.

RADIATOR INSTALLATION

- ALL RADIATORS TO BE SUPPLIED AND INSTALLED IN ACCORDANCE WITH JOULE INSTALLATION GUIDELINES AND OPERATIONS MANUAL.
- PRIOR TO ORDER OF THE RADIATORS THE CONTRACTOR SHALL VERIFY & CO-ORDINATE ALL RADIATORS SPECIFIED ON SITE. REFER TO ARCHITECTURAL LAYOUTS FOR SETTING OUT OF RADIATORS.
- ALL FINAL CONNECTIONS TO RADIATORS TO BE Ø15mm F&R.

ELECTRICAL NOTES

- THE UNDERFLOOR WIRING CENTRE REQUIRES ITS OWN 3 CORE SUPPLY FROM A SA SUPPLY USING A 3 CORE 1.5mm CABLE. THE CONTROLLER MUST BE LOCATED IN CLOSE PROXIMITY TO THE UNDERFLOOR MANIFOLD. A 2 CORE 1.5mm CABLE IS REQUIRED TO PROVIDE A RUN SIGNAL BETWEEN THE UNDERFLOOR CONTROLLER AND THE BOILER/HEAT PUMP. EACH UNDERFLOOR WIRING CENTRE CAN BE CONNECTED TO A MAXIMUM OF 8 INDIVIDUAL ROOM STATS.
- 12V: WHEN USING 12V TEMPERATURE ROOM STATS, USE A CAT 5 / CAT 6 SHIELDED CABLE BETWEEN EACH ROOM STAT AND ITS RELEVANT UNDERFLOOR CONTROLLER.
- 230V: WHEN USING 230V TEMPERATURE ROOM STATS, THE CABLE SHOULD BE 3 CORE 1.5mm CABLE BETWEEN EACH ROOM AND ITS RELEVANT UNDERFLOOR CONTROLLER.

ADDITIONAL NOTES

- THIS DESIGN PACKAGE, PREPARED AND COPYRIGHTED BY JOULE:** IT IS INTENDED FOR CONFIDENTIAL USE BY OUR CLIENT OR THEIR DESIGNATED PARTIES FOR EQUIPMENT INSTALLATION PURPOSES.
- SAFETY RESPONSIBILITY:** INSTALLERS SHOULD ADHERE TO THEIR OWN CDM GUIDELINES WHEN HANDLING AND INSTALLING POTENTIALLY HEAVY EQUIPMENT.
- REGULATORY RESPONSIBILITY:** INSTALLERS MUST ENSURE ALL SPACE HEATING AND DOMESTIC HOT WATER INSTALLATIONS COMPLY WITH LOCAL BUILDING REGULATIONS AND STANDARDS.

HEATING PIPEWORK REFERENCE KEY

- PIPEWORK RISE / DROP FROM ABOVE / BELOW
- HEATING PIPEWORK CEILING VOID
- HEATING PIPEWORK AT LOW LEVEL
- HEATING PIPEWORK UNDERFLOOR
- CONTROL CABLE
- POWER CABLE

HEATING SERVICES REFERENCE KEY

- HORIZONTAL WALL MOUNTED - STEEL PANEL RADIATOR (TYPE 11).
- HORIZONTAL WALL MOUNTED - ALUMINIUM RADIATOR (TYPE 22).
- VERTICAL WALL MOUNTED - ALUMINIUM RADIATOR (TYPE 33).
- HORIZONTAL WALL MOUNTED - ALUMINIUM RADIATOR (4 - 22 SECTIONS).
- VERTICAL WALL MOUNTED - ALUMINIUM RADIATOR (4 - 6 SECTIONS).
- HEATING SERVICES MANIFOLD
- AIR SOURCE HEAT PUMP MONO-BLOCK UNIT (REQUIRED SPACE HATCH INDICATED)
- PRE-PLUMBED HOT WATER CYLINDER (REQUIRED SPACE HATCH INDICATED)
- UNDERFLOOR HEATING CONTROL ZONE. EACH ZONE IS REGULATED BY A LINKED TEMPERATURE SENSOR (HATCH COLOUR DENOTES INDIVIDUAL ZONE OF CONTROL).



ANALOG ROOM STAT



12V NEO STAT



230V ROOM STAT



230V NEO STAT

FA

FROM ABOVE

TA


TO ABOVE

FB

FROM BELOW

TB

TO BELOW

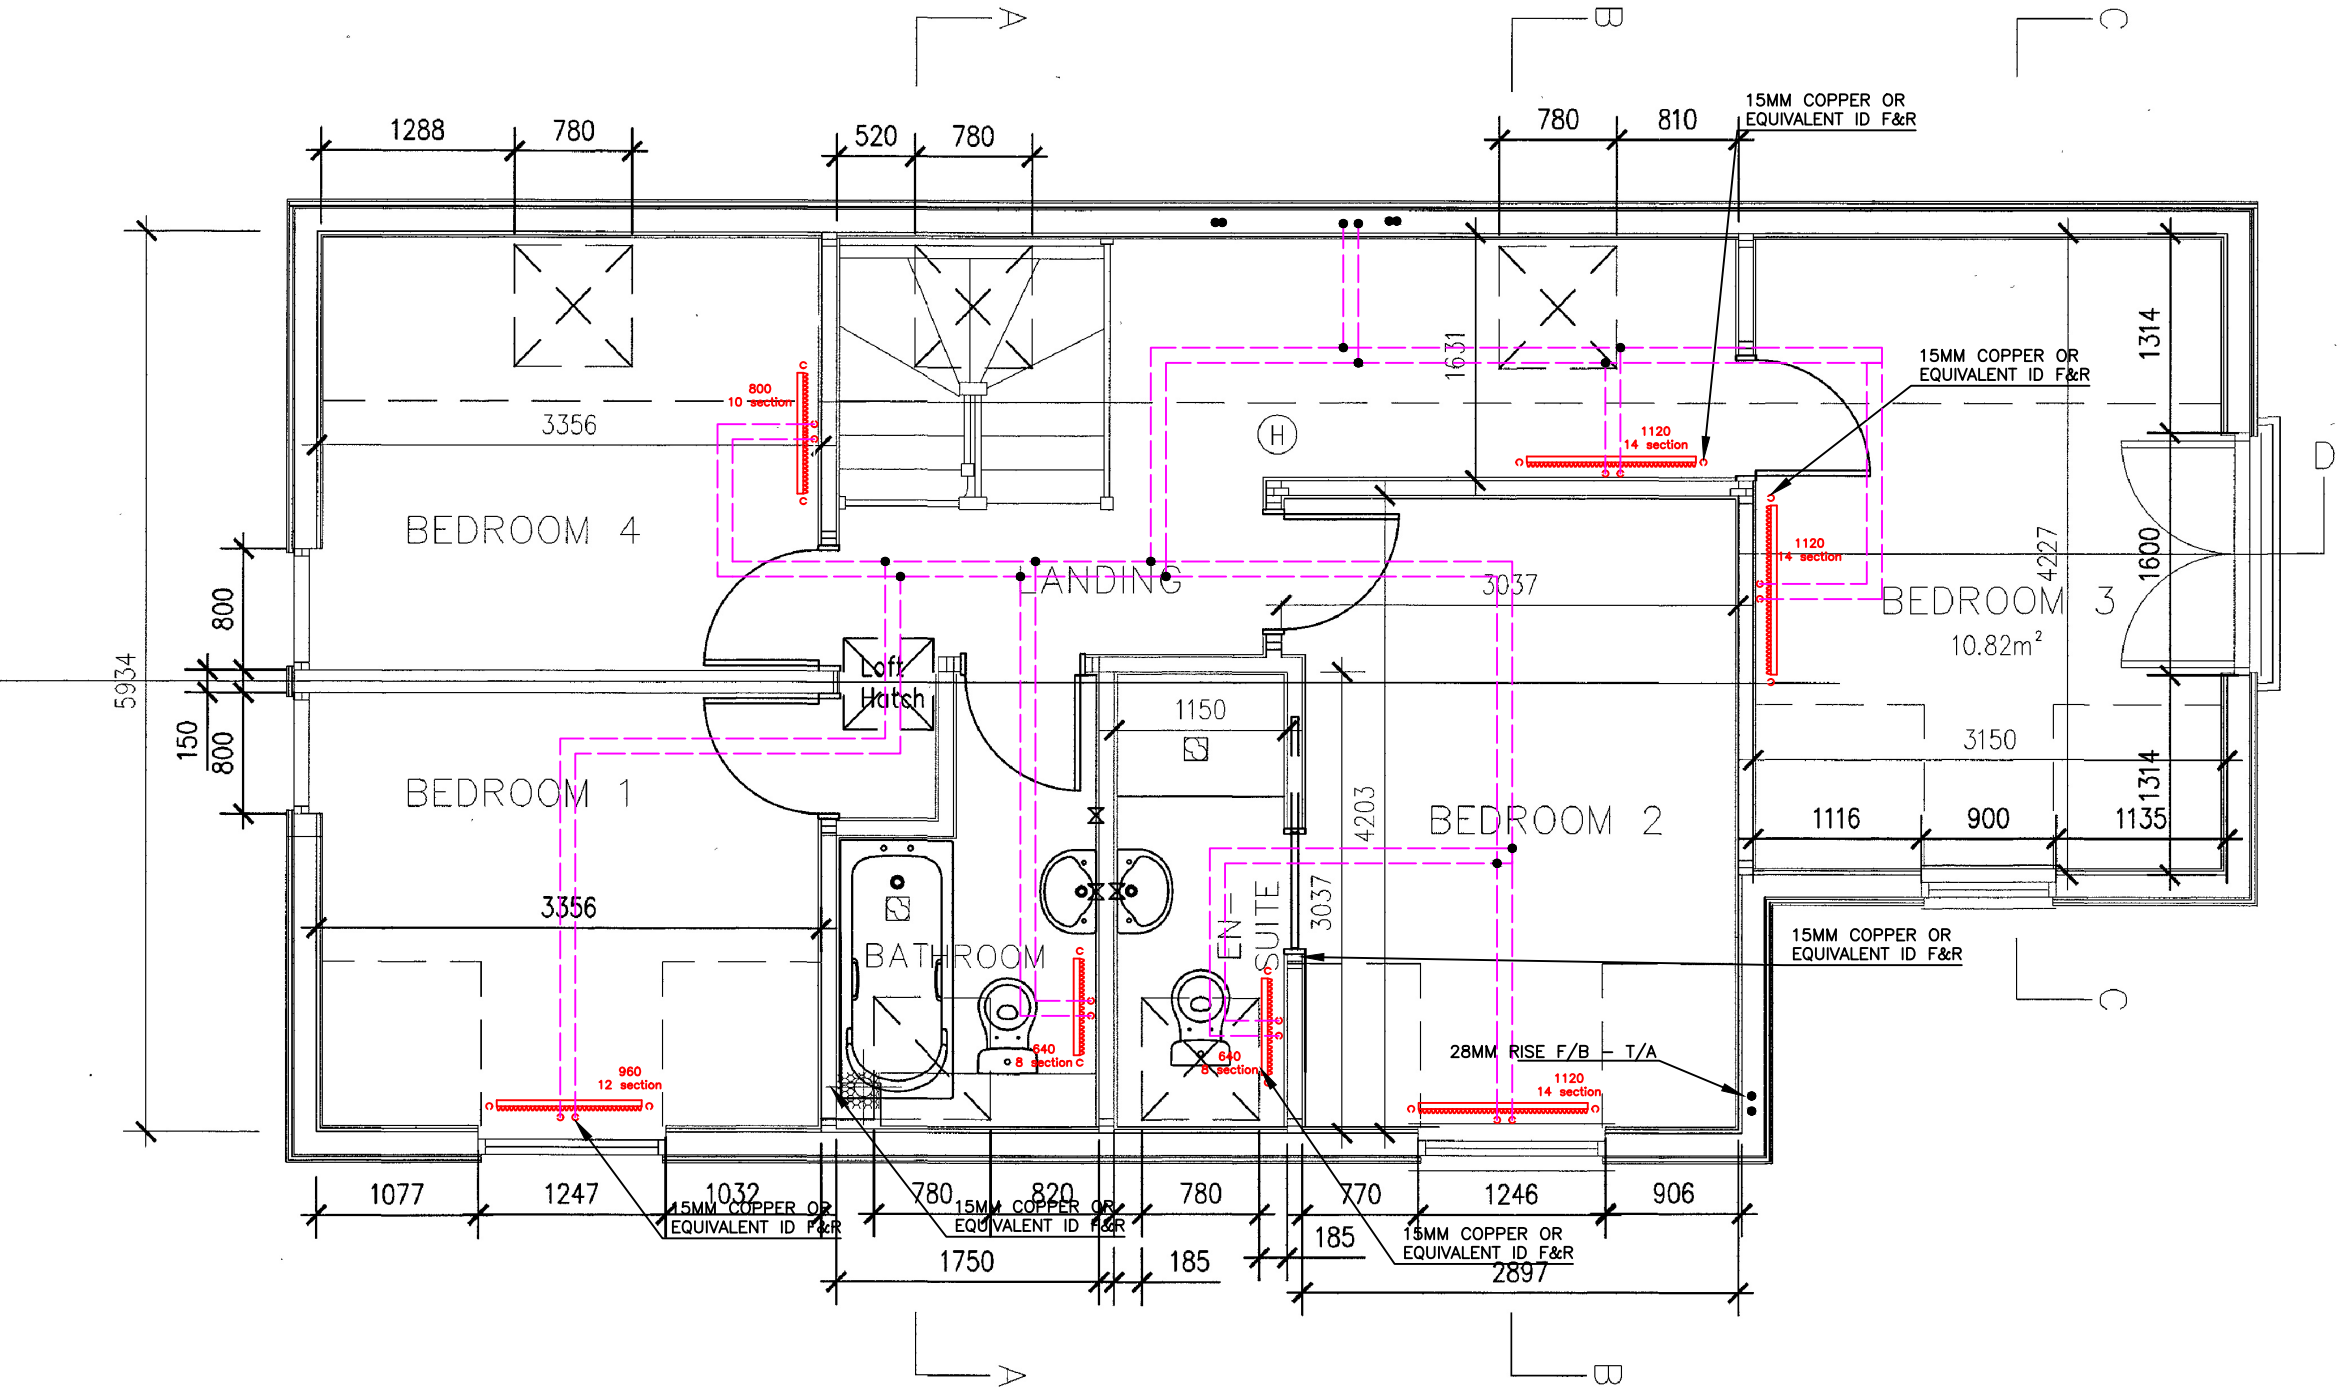

DRAWING TYPE	PROJECT	DWG NO:	310631806177	 
CENTRAL HEATING	Rear of 6 Petlands Road, Haywards Heath	ISSUE DATE:	25/06/2026	
DRAWING TITLE	CLIENT	SCALE:	1:50 @ A3	
FIRST FLOOR	ON BEHALF OF	REVISION:	01	
DWELLING TYPE	JOULE HEATING SOLUTIONS			
HOUSE				

NOTES - HEATING SERVICES

GENERAL NOTES

- THE COMPLETE MECHANICAL AND ELECTRICAL INSTALLATION SHALL BE INSTALLED AND COMMISSIONED IN ACCORDANCE WITH JOULE MECHANICAL AND ELECTRICAL INSTALLATION GUIDELINES PROVIDED WITH THE HEATING SYSTEM.
- FOR A DETAILED OVERVIEW OF THE HEATING SYSTEM, PLEASE REFER TO THE SYSTEM DRAWING SCHEMATICS.
 - ALL PIPEWORK SIZES NOTED REFER TO THE NOMINAL PIPE DIAMETER.
 - ALL PIPEWORK SHALL BE THERMALLY INSULATED IN ACCORDANCE WITH BS 5422: 2023.
 - JOULE RECOMMENDS THAT ALL JOINTS THAT ARE TO BE SOLDERED SHOULD BE MADE USING A FLUX THAT IS SPARINGLY APPLIED AND ANY RESIDUE IS FLUSHED OUT OF THE SYSTEM BEFORE COMMISSIONING.

HEAT PUMP

- THE HEAT PUMP SHALL BE A MONO-BLOCK UNIT TYPE C/W INDOOR HOT WATER CYLINDER, HOT WATER PRIORITY, INTERNAL UNIT TO LOCATED WITHIN PLANTROOM, EXTERNAL UNIT EXACT LOCATION TO BE AGREED WITH ARCHITECT.
- THE HOT WATER CYLINDER SHALL BE PRE-PLUMBED VALVE SET AND COME WITH 1NO. 3KW IMMERSION HEATERS, EXPANSION VESSEL, PACKAGED CONTROLS ETC.

UNDERFLOOR HEATING SYSTEM

- DO NOT CUT PIPES TO LENGTH PRIOR TO INSTALLATION:** THE LENGTHS OF PIPE LOOPS SHOWN ARE FOR GUIDANCE PURPOSES ONLY.
- INSTALL MANIFOLDS AT THE CORRECT HEIGHT:** UNDERFLOOR PIPE MANIFOLDS SHOULD BE INSTALLED AT A HEIGHT AT LEAST 600mm FROM THE FINISHED FLOOR UNLESS OTHERWISE SPECIFIED.
- FOLLOW MAXIMUM PIPE LENGTH RECOMMENDATIONS:** THE MAXIMUM RECOMMENDED PIPE LENGTH FOR 16mm PIPE IS 100m AND FOR 12mm PIPE IS 75m.
- ADHERE TO PIPE CENTRE RECOMMENDATIONS:** RECOMMENDED 16mm PIPE CENTRES ARE 150mm WHEN USING A LOW TEMPERATURE HEAT SOURCE, SUCH AS A HEAT PUMP, OR 200mm WHEN USING A HIGH TEMPERATURE HEAT SOURCE.
- MIXING SETS:** MIXING SETS ARE REQUIRED WITH HIGH TEMPERATURE HEAT SOURCES. WHEN USING A LOW TEMPERATURE HEAT SOURCE, MIXING SETS MAY NOT BE REQUIRED.
- CIRCULATION PUMP:** IT IS RECOMMENDED TO FIT A CIRCULATION PUMP TO THE MANIFOLD IF A MIXING SET IS NOT INSTALLED TO GUARANTEE CIRCULATION THROUGH THE UNDERFLOOR LOOPS.
- INSTALL A BYPASS VALVE:** A BYPASS VALVE MUST BE INSTALLED ON THE PRIMARY PIPEWORK TO THE UNDERFLOOR HEATING MANIFOLD.
- FOLLOW THE LAYOUT SCHEMATIC:** ADHERE TO THE LAYOUT SCHEMATIC PROVIDED FOR PIPE LAYOUT.
- INSTALL PIPE FLOW AROUND THE ROOM PERIMETER FIRST:** THE PIPE FLOW SHOULD BE INSTALLED AROUND THE PERIMETER OF THE ROOM FIRST TO PREVENT ANY POTENTIAL COLD SPOTS IN THE FLOOR IN THESE AREAS.
- PRESSURE TESTING:** PRESSURE TESTING MUST BE CARRIED OUT PRIOR TO THE LAYING OF SCREED. AIR (NOT WATER) MUST BE USED FOR PERIODS OF PROLONGED PRESSURE TESTING.
- FLOOR COVERING:** FLOOR COVERINGS SHOULD BE SUITABLE FOR USE WITH UNDERFLOOR HEATING. IF CARPETS ARE FITTED, THE UNDERLAY MUST HAVE A TOG NO GREATER THAN 1 WITH THE CARPET HAVING A TOG NO GREATER THAN 1.5, OR HAVE A MAXIMUM THERMAL RESISTANCE OF 0.15m²/K/W.
- SCREED CURING:** CONCRETE SCREED FLOORS MUST BE CURED BEFORE HEAT IS APPLIED. ALLOW 1 DAY PER 2mm OF SCREED BEFORE TURNING ON THE HEATING SYSTEM.
- FLOW TEMPERATURE:** WHEN TURNING HEAT ON IN A NEW PROPERTY, THE FLOW TEMPERATURE INTO THE PIPEWORK FROM THE HEAT SOURCE MUST BE INITIALLY SET TO 28° DEGREES CELSIUS. THE TEMPERATURE INCREASE SHOULD BE NO MORE THAN 2° DEGREES PER 24 HOURS UNTIL THE DESIRED FLOW TEMPERATURE IS REACHED.

RADIATOR INSTALLATION

- ALL RADIATORS TO BE SUPPLIED AND INSTALLED IN ACCORDANCE WITH JOULE INSTALLATION GUIDELINES AND OPERATIONS MANUAL.
- PRIOR TO ORDER OF THE RADIATORS THE CONTRACTOR SHALL VERIFY & CO-ORDINATE ALL RADIATORS SPECIFIED ON SITE. REFER TO ARCHITECTURAL LAYOUTS FOR SETTING OUT OF RADIATORS.
- ALL FINAL CONNECTIONS TO RADIATORS TO BE Ø15mm F&R.

ELECTRICAL NOTES

- THE UNDERFLOOR WIRING CENTRE REQUIRES ITS OWN 3 CORE SUPPLY FROM A SA SUPPLY USING A 3 CORE 1.5mm CABLE. THE CONTROLLER MUST BE LOCATED IN CLOSE PROXIMITY TO THE UNDERFLOOR MANIFOLD. A 2 CORE 1.5mm CABLE IS REQUIRED TO PROVIDE A RUN SIGNAL BETWEEN THE UNDERFLOOR CONTROLLER AND THE BOILER/HEAT PUMP. EACH UNDERFLOOR WIRING CENTRE CAN BE CONNECTED TO A MAXIMUM OF 8 INDIVIDUAL ROOM STATS.
- 12V: WHEN USING 12V TEMPERATURE ROOM STATS, USE A CAT 5 / CAT 6 SHIELDED CABLE BETWEEN EACH ROOM STAT AND ITS RELEVANT UNDERFLOOR CONTROLLER.
- 230V: WHEN USING 230V TEMPERATURE ROOM STATS, THE CABLE SHOULD BE 3 CORE 1.5mm CABLE BETWEEN EACH ROOM AND ITS RELEVANT UNDERFLOOR CONTROLLER.

ADDITIONAL NOTES

- THIS DESIGN PACKAGE, PREPARED AND COPYRIGHTED BY JOULE:** IT IS INTENDED FOR CONFIDENTIAL USE BY OUR CLIENT OR THEIR DESIGNATED PARTIES FOR EQUIPMENT INSTALLATION PURPOSES.
- SAFETY RESPONSIBILITY:** INSTALLERS SHOULD ADHERE TO THEIR OWN CDM GUIDELINES WHEN HANDLING AND INSTALLING POTENTIALLY HEAVY EQUIPMENT.
- REGULATORY RESPONSIBILITY:** INSTALLERS' MUST ENSURE ALL SPACE HEATING AND DOMESTIC HOT WATER INSTALLATIONS COMPLY WITH LOCAL BUILDING REGULATIONS AND STANDARDS.


HEATING PIPEWORK REFERENCE KEY

- PIPEWORK RISE / DROP FROM ABOVE / BELOW
- HEATING PIPEWORK CEILING VOID
- HEATING PIPEWORK AT LOW LEVEL
- HEATING PIPEWORK UNDERFLOOR
- CONTROL CABLE
- POWER CABLE

HEATING SERVICES REFERENCE KEY

- HORIZONTAL WALL MOUNTED - STEEL PANEL RADIATOR (TYPE 11).
- HORIZONTAL WALL MOUNTED - ALUMINIMUM RADIATOR (TYPE 22).
- VERTICAL WALL MOUNTED - ALUMINIMUM RADIATOR (TYPE 33).
- HORIZONTAL WALL MOUNTED - ALUMINIMUM RADIATOR (4 - 22 SECTIONS).
- VERTICAL WALL MOUNTED - ALUMINIMUM RADIATOR (4 - 6 SECTIONS).
- HEATING SERVICES MANIFOLD
- AIR SOURCE HEAT PUMP MONO-BLOCK UNIT (REQUIRED SPACE HATCH INDICATED)
- PRE-PLUMBED HOT WATER CYLINDER (REQUIRED SPACE HATCH INDICATED)
- UNDERFLOOR HEATING CONTROL ZONE. EACH ZONE IS REGULATED BY A LINKED TEMPERATURE SENSOR (HATCH COLOUR DENOTES INDIVIDUAL ZONE OF CONTROL).

- | | | | |
|--|------------------|---|---------------|
|  | ANALOG ROOM STAT |  | 12V NEO STAT |
|  | 230V ROOM STAT |  | 230V NEO STAT |
| FA | FROM ABOVE | TA | TO ABOVE |
| FB | FROM BELOW | TB | TO BELOW |

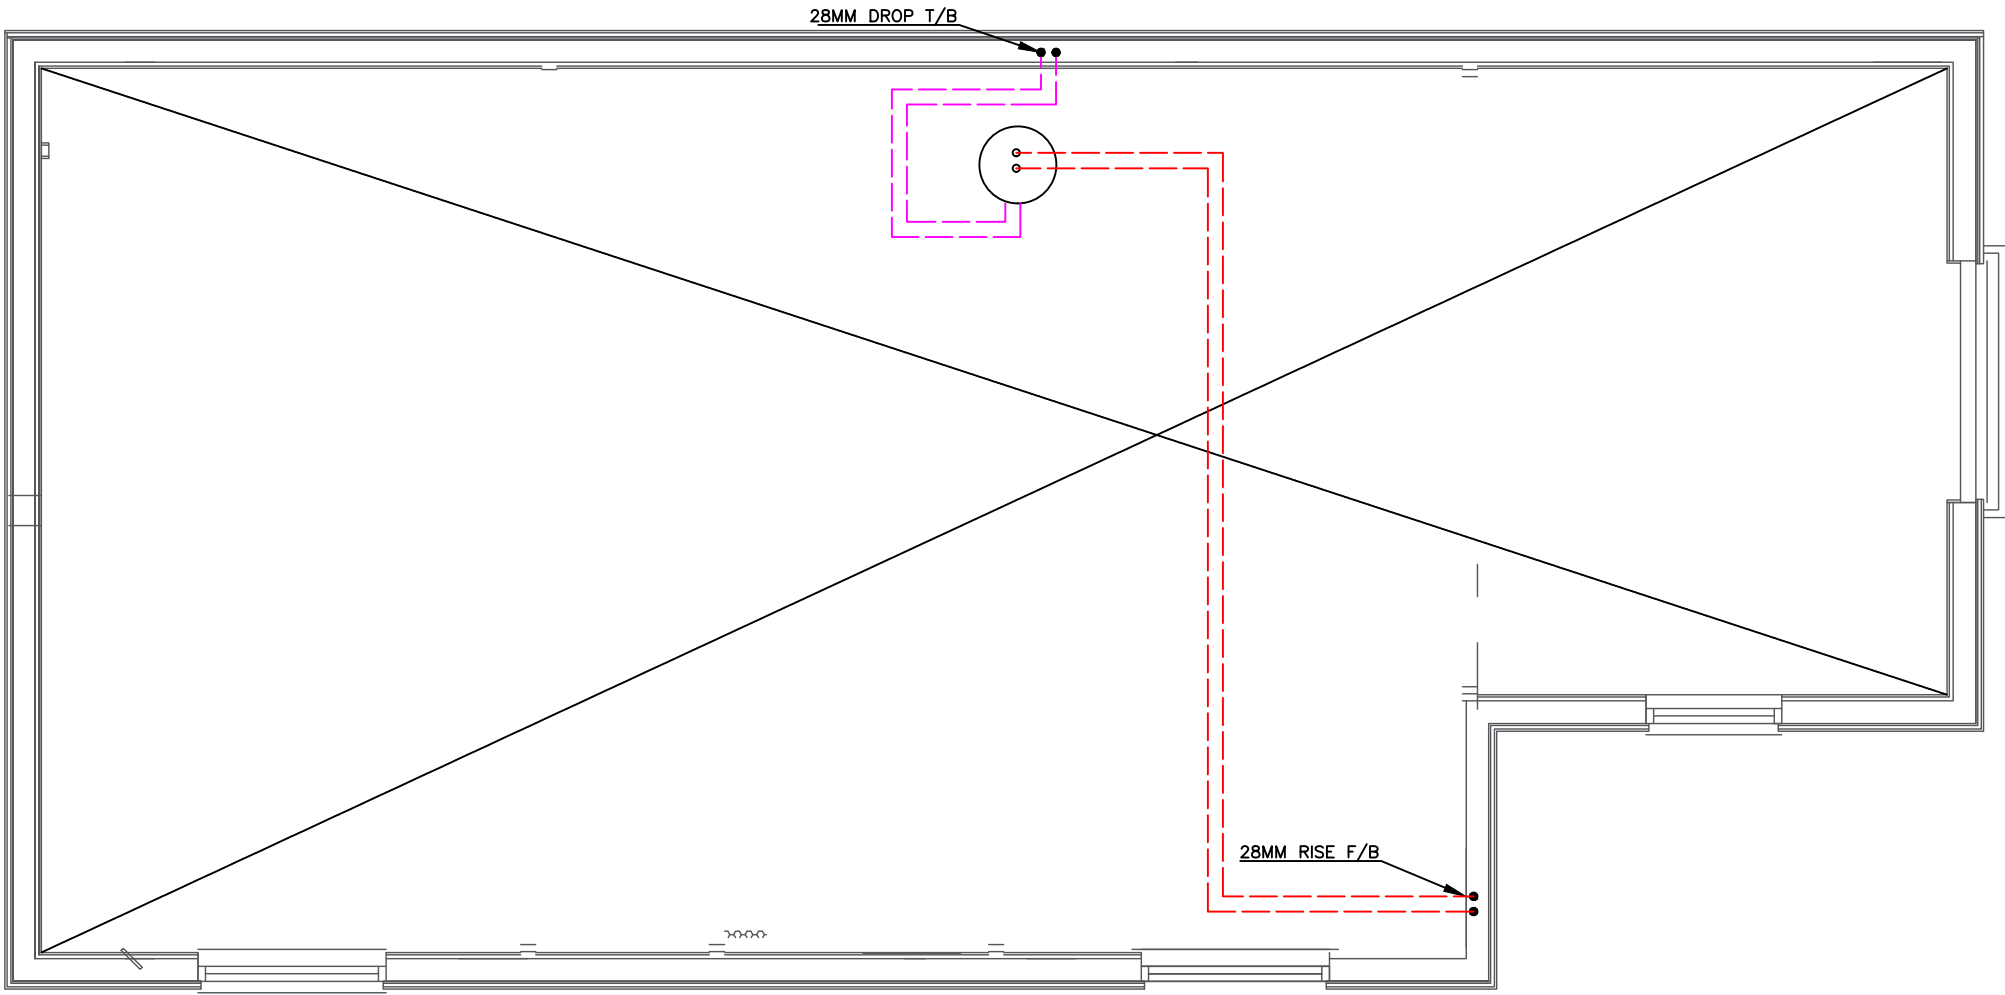

DRAWING TYPE	PROJECT	DWG NO:	310631806177	
CENTRAL HEATING	Rear of 6 Petlands Road, Haywards Heath	ISSUE DATE:	25/06/2026	
DRAWING TITLE	CLIENT	SCALE:	1:50 @ A3	
LOFT	ON BEHALF OF	REVISION:	01	
DWELLING TYPE	HOUSE			
JOULE HEATING SOLUTIONS				

NOTES - HEATING SERVICES

GENERAL NOTES

- THE COMPLETE MECHANICAL AND ELECTRICAL INSTALLATION SHALL BE INSTALLED AND COMMISSIONED IN ACCORDANCE WITH JOULE MECHANICAL AND ELECTRICAL INSTALLATION GUIDELINES PROVIDED WITH THE HEATING SYSTEM.
- FOR A DETAILED OVERVIEW OF THE HEATING SYSTEM, PLEASE REFER TO THE SYSTEM DRAWING SCHEMATICS.
 - ALL PIPEWORK SIZES NOTED REFER TO THE NOMINAL PIPE DIAMETER.
 - ALL PIPEWORK SHALL BE THERMALLY INSULATED IN ACCORDANCE WITH BS 5422: 2023.
 - JOULE RECOMMENDS THAT ALL JOINTS THAT ARE TO BE SOLDERED SHOULD BE MADE USING A FLUX THAT IS SPARINGLY APPLIED AND ANY RESIDUE IS FLUSHED OUT OF THE SYSTEM BEFORE COMMISSIONING.

HEAT PUMP

- THE HEAT PUMP SHALL BE A MONO-BLOCK UNIT TYPE C/W INDOOR HOT WATER CYLINDER, HOT WATER PRIORITY, INTERNAL UNIT TO LOCATED WITHIN PLANTROOM, EXTERNAL UNIT EXACT LOCATION TO BE AGREED WITH ARCHITECT.
- THE HOT WATER CYLINDER SHALL BE PRE-PLUMBED VALVE SET AND COME WITH 1NO. 3KW IMMERSION HEATERS, EXPANSION VESSEL, PACKAGED CONTROLS ETC.

UNDERFLOOR HEATING SYSTEM

- DO NOT CUT PIPES TO LENGTH PRIOR TO INSTALLATION:** THE LENGTHS OF PIPE LOOPS SHOWN ARE FOR GUIDANCE PURPOSES ONLY.
- INSTALL MANIFOLDS AT THE CORRECT HEIGHT:** UNDERFLOOR PIPE MANIFOLDS SHOULD BE INSTALLED AT A HEIGHT AT LEAST 600mm FROM THE FINISHED FLOOR UNLESS OTHERWISE SPECIFIED.
- FOLLOW MAXIMUM PIPE LENGTH RECOMMENDATIONS:** THE MAXIMUM RECOMMENDED PIPE LENGTH FOR 16mm PIPE IS 100m AND FOR 12mm PIPE IS 75m.
- ADHERE TO PIPE CENTRE RECOMMENDATIONS:** RECOMMENDED 16mm PIPE CENTRES ARE 150mm WHEN USING A LOW TEMPERATURE HEAT SOURCE, SUCH AS A HEAT PUMP, OR 200mm WHEN USING A HIGH TEMPERATURE HEAT SOURCE.
- MIXING SETS:** MIXING SETS ARE REQUIRED WITH HIGH TEMPERATURE HEAT SOURCES. WHEN USING A LOW TEMPERATURE HEAT SOURCE, MIXING SETS MAY NOT BE REQUIRED.
- CIRCULATION PUMP:** IT IS RECOMMENDED TO FIT A CIRCULATION PUMP TO THE MANIFOLD IF A MIXING SET IS NOT INSTALLED TO GUARANTEE CIRCULATION THROUGH THE UNDERFLOOR LOOPS.
- INSTALL A BYPASS VALVE:** A BYPASS VALVE MUST BE INSTALLED ON THE PRIMARY PIPEWORK TO THE UNDERFLOOR HEATING MANIFOLD.
- FOLLOW THE LAYOUT SCHEMATIC:** ADHERE TO THE LAYOUT SCHEMATIC PROVIDED FOR PIPE LAYOUT.
- INSTALL PIPE FLOW AROUND THE ROOM PERIMETER FIRST:** THE PIPE FLOW SHOULD BE INSTALLED AROUND THE PERIMETER OF THE ROOM FIRST TO PREVENT ANY POTENTIAL COLD SPOTS IN THE FLOOR IN THESE AREAS.
- PRESSURE TESTING:** PRESSURE TESTING MUST BE CARRIED OUT PRIOR TO THE LAYING OF SCREED. AIR (NOT WATER) MUST BE USED FOR PERIODS OF PROLONGED PRESSURE TESTING.
- FLOOR COVERING:** FLOOR COVERINGS SHOULD BE SUITABLE FOR USE WITH UNDERFLOOR HEATING. IF CARPETS ARE FITTED, THE UNDERLAY MUST HAVE A TOG NO GREATER THAN 1 WITH THE CARPET HAVING A TOG NO GREATER THAN 1.5, OR HAVE A MAXIMUM THERMAL RESISTANCE OF 0.15m²/K/W.
- SCREED CURING:** CONCRETE SCREED FLOORS MUST BE CURED BEFORE HEAT IS APPLIED. ALLOW 1 DAY PER 2mm OF SCREED BEFORE TURNING ON THE HEATING SYSTEM.
- FLOW TEMPERATURE:** WHEN TURNING HEAT ON IN A NEW PROPERTY, THE FLOW TEMPERATURE INTO THE PIPEWORK FROM THE HEAT SOURCE MUST BE INITIALLY SET TO 28° DEGREES CELSIUS. THE TEMPERATURE INCREASE SHOULD BE NO MORE THAN 2° DEGREES PER 24 HOURS UNTIL THE DESIRED FLOW TEMPERATURE IS REACHED.

RADIATOR INSTALLATION

- ALL RADIATORS TO BE SUPPLIED AND INSTALLED IN ACCORDANCE WITH JOULE INSTALLATION GUIDELINES AND OPERATIONS MANUAL.
- PRIOR TO ORDER OF THE RADIATORS THE CONTRACTOR SHALL VERIFY & CO-ORDINATE ALL RADIATORS SPECIFIED ON SITE. REFER TO ARCHITECTURAL LAYOUTS FOR SETTING OUT OF RADIATORS.
- ALL FINAL CONNECTIONS TO RADIATORS TO BE Ø15mm F&R.

ELECTRICAL NOTES

- THE UNDERFLOOR WIRING CENTRE REQUIRES ITS OWN 3 CORE SUPPLY FROM A 5A SUPPLY USING A 3 CORE 1.5mm CABLE. THE CONTROLLER MUST BE LOCATED IN CLOSE PROXIMITY TO THE UNDERFLOOR MANIFOLD. A 2 CORE 1.5mm CABLE IS REQUIRED TO PROVIDE A RUN SIGNAL BETWEEN THE UNDERFLOOR CONTROLLER AND THE BOILER/HEAT PUMP. EACH UNDERFLOOR WIRING CENTRE CAN BE CONNECTED TO A MAXIMUM OF 8 INDIVIDUAL ROOM STATS.
- 12V: WHEN USING 12V TEMPERATURE ROOM STATS, USE A CAT 5 / CAT 6 SHIELDED CABLE BETWEEN EACH ROOM STAT AND ITS RELEVANT UNDERFLOOR CONTROLLER.
- 230V: WHEN USING 230V TEMPERATURE ROOM STATS, THE CABLE SHOULD BE 3 CORE 1.5mm CABLE BETWEEN EACH ROOM AND ITS RELEVANT UNDERFLOOR CONTROLLER.

ADDITIONAL NOTES

- THIS DESIGN PACKAGE, PREPARED AND COPYRIGHTED BY JOULE:** IT IS INTENDED FOR CONFIDENTIAL USE BY OUR CLIENT OR THEIR DESIGNATED PARTIES FOR EQUIPMENT INSTALLATION PURPOSES.
- SAFETY RESPONSIBILITY:** INSTALLERS SHOULD ADHERE TO THEIR OWN CDM GUIDELINES WHEN HANDLING AND INSTALLING POTENTIALLY HEAVY EQUIPMENT.
- REGULATORY RESPONSIBILITY:** INSTALLERS MUST ENSURE ALL SPACE HEATING AND DOMESTIC HOT WATER INSTALLATIONS COMPLY WITH LOCAL BUILDING REGULATIONS AND STANDARDS.


HEATING PIPEWORK REFERENCE KEY

- Zone 1 Heating System Pipework
- Zone 2 Heating System Pipework
- Domestic Hot Water Supply
- Domestic Cold Water Supply
- Pipework at Low Level
- Pipework in Floor Voids
- Pipework in Roof / Ceiling Void

HEATING SERVICES REFERENCE KEY

- HORIZONTAL WALL MOUNTED - STEEL PANEL RADIATOR (TYPE 11).
- HORIZONTAL WALL MOUNTED - ALUMINIUM RADIATOR (TYPE 22).
- VERTICAL WALL MOUNTED - ALUMINIUM RADIATOR (TYPE 33).
- HORIZONTAL WALL MOUNTED - ALUMINIUM RADIATOR (4 - 22 SECTIONS).
- VERTICAL WALL MOUNTED - ALUMINIUM RADIATOR (4 - 6 SECTIONS).
- HEATING SERVICES MANIFOLD
- AIR SOURCE HEAT PUMP MONO-BLOCK UNIT (REQUIRED SPACE HATCH INDICATED)
- PRE-PLUMBED HOT WATER CYLINDER (REQUIRED SPACE HATCH INDICATED)
- UNDERFLOOR HEATING CONTROL ZONE. EACH ZONE IS REGULATED BY A LINKED TEMPERATURE SENSOR (HATCH COLOUR DENOTES INDIVIDUAL ZONE OF CONTROL).

- | | | | |
|----|------------------|----|---------------|
| | ANALOG ROOM STAT | | 12V NEO STAT |
| | 230V ROOM STAT | | 230V NEO STAT |
| FA | FROM ABOVE | TA | TO ABOVE |
| FB | FROM BELOW | TB | TO BELOW |

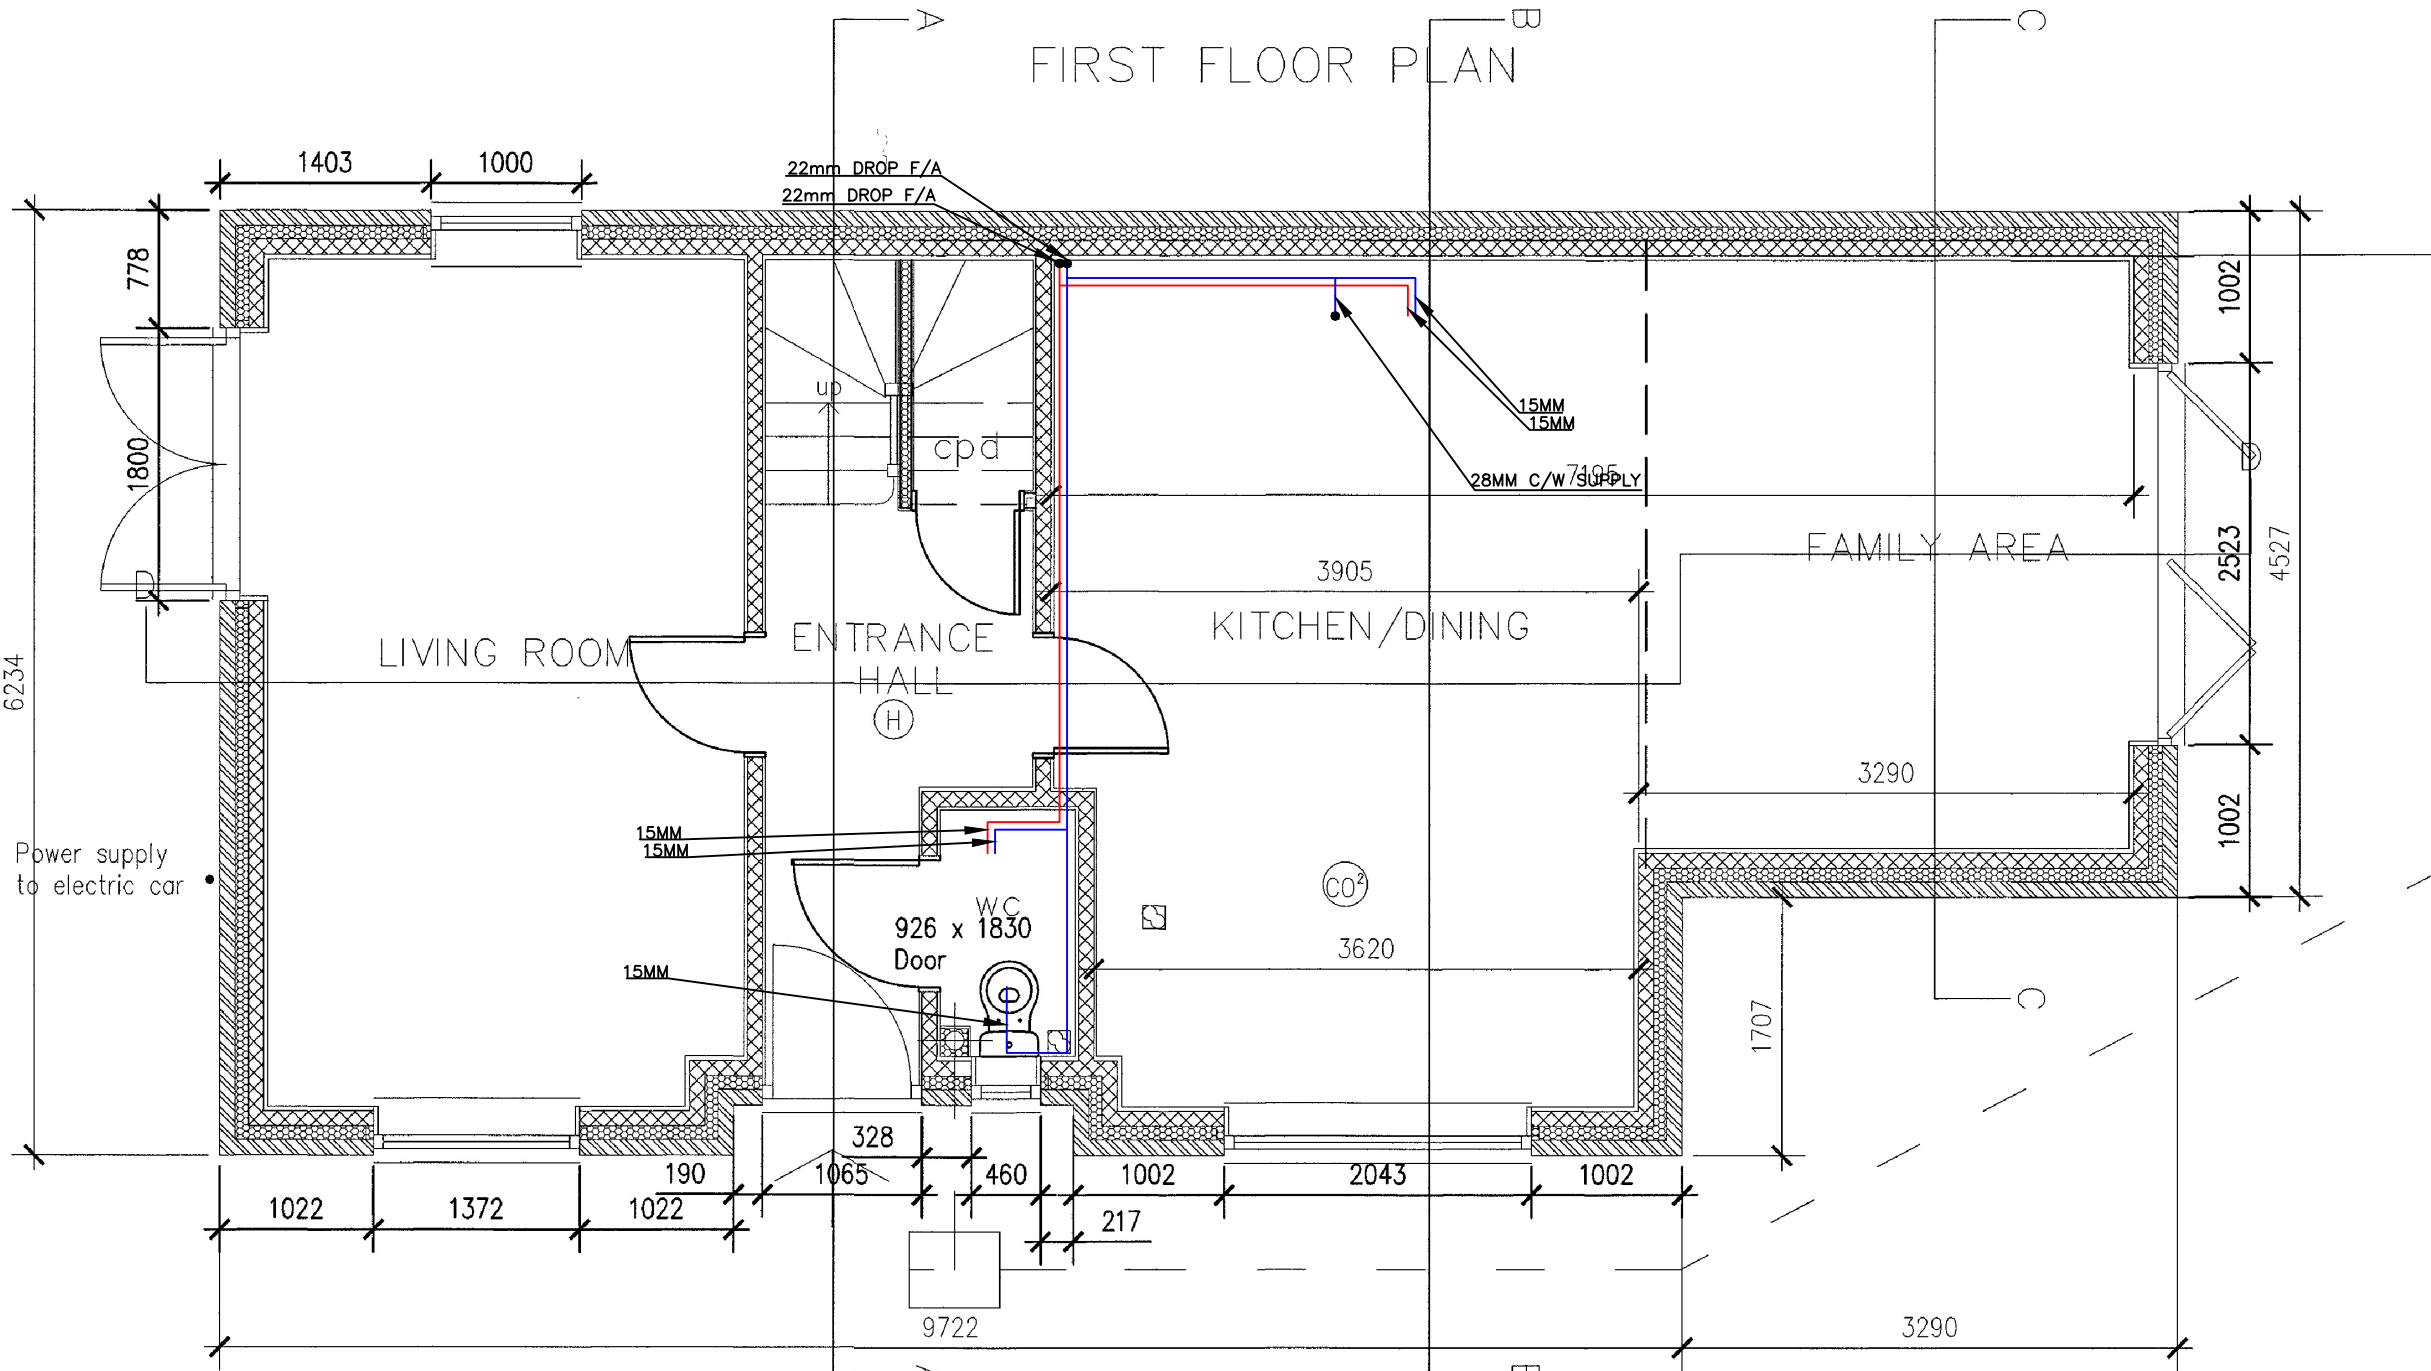

- Extract fan discharging direct to external air
- Carbon Monoxide detector
- Heat detector

0 1000 2000 3000 4000 5000
scale (mm) 1:50

DRAWING TYPE HOT & COLD WATER SERVICES	PROJECT Rear of 6 Petlands Road, Haywards Heath	DWG NO: 310631806177
DRAWING TITLE GROUND FLOOR	CLIENT	ISSUE DATE: 25/06/2026
DWELLING TYPE HOUSE	ON BEHALF OF JOULE HEATING SOLUTIONS	SCALE: 1:50 @ A3
		REVISION: 01

NOTES - HEATING SERVICES

GENERAL NOTES

- THE COMPLETE MECHANICAL AND ELECTRICAL INSTALLATION SHALL BE INSTALLED AND COMMISSIONED IN ACCORDANCE WITH JOULE MECHANICAL AND ELECTRICAL INSTALLATION GUIDELINES PROVIDED WITH THE HEATING SYSTEM.
- FOR A DETAILED OVERVIEW OF THE HEATING SYSTEM, PLEASE REFER TO THE SYSTEM DRAWING SCHEMATICS.
 - ALL PIPEWORK SIZES NOTED REFER TO THE NOMINAL PIPE DIAMETER.
 - ALL PIPEWORK SHALL BE THERMALLY INSULATED IN ACCORDANCE WITH BS 5422: 2023.
 - JOULE RECOMMENDS THAT ALL JOINTS THAT ARE TO BE SOLDERED SHOULD BE MADE USING A FLUX THAT IS SPARINGLY APPLIED AND ANY RESIDUE IS FLUSHED OUT OF THE SYSTEM BEFORE COMMISSIONING.

HEAT PUMP

- THE HEAT PUMP SHALL BE A MONO-BLOCK UNIT TYPE C/W INDOOR HOT WATER CYLINDER, HOT WATER PRIORITY, INTERNAL UNIT TO LOCATED WITHIN PLANTROOM, EXTERNAL UNIT EXACT LOCATION TO BE AGREED WITH ARCHITECT.
- THE HOT WATER CYLINDER SHALL BE PRE-PLUMBED VALVE SET AND COME WITH 1NO. 3KW IMMERSION HEATERS, EXPANSION VESSEL, PACKAGED CONTROLS ETC.

UNDERFLOOR HEATING SYSTEM

- DO NOT CUT PIPES TO LENGTH PRIOR TO INSTALLATION:** THE LENGTHS OF PIPE LOOPS SHOWN ARE FOR GUIDANCE PURPOSES ONLY.
- INSTALL MANIFOLDS AT THE CORRECT HEIGHT:** UNDERFLOOR PIPE MANIFOLDS SHOULD BE INSTALLED AT A HEIGHT AT LEAST 600mm FROM THE FINISHED FLOOR UNLESS OTHERWISE SPECIFIED.
- FOLLOW MAXIMUM PIPE LENGTH RECOMMENDATIONS:** THE MAXIMUM RECOMMENDED PIPE LENGTH FOR 16mm PIPE IS 100m AND FOR 12mm PIPE IS 75m.
- ADHERE TO PIPE CENTRE RECOMMENDATIONS:** RECOMMENDED 16mm PIPE CENTRES ARE 150mm WHEN USING A LOW TEMPERATURE HEAT SOURCE, SUCH AS A HEAT PUMP, OR 200mm WHEN USING A HIGH TEMPERATURE HEAT SOURCE.
- MIXING SETS:** MIXING SETS ARE REQUIRED WITH HIGH TEMPERATURE HEAT SOURCES. WHEN USING A LOW TEMPERATURE HEAT SOURCE, MIXING SETS MAY NOT BE REQUIRED.
- CIRCULATION PUMP:** IT IS RECOMMENDED TO FIT A CIRCULATION PUMP TO THE MANIFOLD IF A MIXING SET IS NOT INSTALLED TO GUARANTEE CIRCULATION THROUGH THE UNDERFLOOR LOOPS.
- INSTALL A BYPASS VALVE:** A BYPASS VALVE MUST BE INSTALLED ON THE PRIMARY PIPEWORK TO THE UNDERFLOOR HEATING MANIFOLD.
- FOLLOW THE LAYOUT SCHEMATIC:** ADHERE TO THE LAYOUT SCHEMATIC PROVIDED FOR PIPE LAYOUT.
- INSTALL PIPE FLOW AROUND THE ROOM PERIMETER FIRST:** THE PIPE FLOW SHOULD BE INSTALLED AROUND THE PERIMETER OF THE ROOM FIRST TO PREVENT ANY POTENTIAL COLD SPOTS IN THE FLOOR IN THESE AREAS.
- PRESSURE TESTING:** PRESSURE TESTING MUST BE CARRIED OUT PRIOR TO THE LAYING OF SCREED. AIR (NOT WATER) MUST BE USED FOR PERIODS OF PROLONGED PRESSURE TESTING.
- FLOOR COVERING:** FLOOR COVERINGS SHOULD BE SUITABLE FOR USE WITH UNDERFLOOR HEATING. IF CARPETS ARE FITTED, THE UNDERLAY MUST HAVE A TOG NO GREATER THAN 1 WITH THE CARPET HAVING A TOG NO GREATER THAN 1.5, OR HAVE A MAXIMUM THERMAL RESISTANCE OF 0.15m²/K/W.
- SCREED CURING:** CONCRETE SCREED FLOORS MUST BE CURED BEFORE HEAT IS APPLIED. ALLOW 1 DAY PER 2mm OF SCREED BEFORE TURNING ON THE HEATING SYSTEM.
- FLOW TEMPERATURE:** WHEN TURNING HEAT ON IN A NEW PROPERTY, THE FLOW TEMPERATURE INTO THE PIPEWORK FROM THE HEAT SOURCE MUST BE INITIALLY SET TO 28° DEGREES CELSIUS. THE TEMPERATURE INCREASE SHOULD BE NO MORE THAN 2° DEGREES PER 24 HOURS UNTIL THE DESIRED FLOW TEMPERATURE IS REACHED.

RADIATOR INSTALLATION

- ALL RADIATORS TO BE SUPPLIED AND INSTALLED IN ACCORDANCE WITH JOULE INSTALLATION GUIDELINES AND OPERATIONS MANUAL.
- PRIOR TO ORDER OF THE RADIATORS THE CONTRACTOR SHALL VERIFY & CO-ORDINATE ALL RADIATORS SPECIFIED ON SITE. REFER TO ARCHITECTURAL LAYOUTS FOR SETTING OUT OF RADIATORS.
- ALL FINAL CONNECTIONS TO RADIATORS TO BE Ø15mm F&R.

ELECTRICAL NOTES

- THE UNDERFLOOR WIRING CENTRE REQUIRES ITS OWN 3 CORE SUPPLY FROM A 5A SUPPLY USING A 3 CORE 1.5mm CABLE. THE CONTROLLER MUST BE LOCATED IN CLOSE PROXIMITY TO THE UNDERFLOOR MANIFOLD. A 2 CORE 1.5mm CABLE IS REQUIRED TO PROVIDE A RUN SIGNAL BETWEEN THE UNDERFLOOR CONTROLLER AND THE BOILER/HEAT PUMP. EACH UNDERFLOOR WIRING CENTRE CAN BE CONNECTED TO A MAXIMUM OF 8 INDIVIDUAL ROOM STATS.
- 12V: WHEN USING 12V TEMPERATURE ROOM STATS, USE A CAT 5 / CAT 6 SHIELDED CABLE BETWEEN EACH ROOM STAT AND ITS RELEVANT UNDERFLOOR CONTROLLER.
- 230V: WHEN USING 230V TEMPERATURE ROOM STATS, THE CABLE SHOULD BE 3 CORE 1.5mm CABLE BETWEEN EACH ROOM AND ITS RELEVANT UNDERFLOOR CONTROLLER.

ADDITIONAL NOTES

- THIS DESIGN PACKAGE, PREPARED AND COPYRIGHTED BY JOULE:** IT IS INTENDED FOR CONFIDENTIAL USE BY OUR CLIENT OR THEIR DESIGNATED PARTIES FOR EQUIPMENT INSTALLATION PURPOSES.
- SAFETY RESPONSIBILITY:** INSTALLERS SHOULD ADHERE TO THEIR OWN CDM GUIDELINES WHEN HANDLING AND INSTALLING POTENTIALLY HEAVY EQUIPMENT.
- REGULATORY RESPONSIBILITY:** INSTALLERS' MUST ENSURE ALL SPACE HEATING AND DOMESTIC HOT WATER INSTALLATIONS COMPLY WITH LOCAL BUILDING REGULATIONS AND STANDARDS.


HEATING PIPEWORK REFERENCE KEY

- Zone 1 Heating System Pipework
- Zone 2 Heating System Pipework
- Domestic Hot Water Supply
- Domestic Cold Water Supply
- Pipework at Low Level
- Pipework in Floor Voids
- Pipework in Roof / Ceiling Void

HEATING SERVICES REFERENCE KEY

- HORIZONTAL WALL MOUNTED - STEEL PANEL RADIATOR (TYPE 11).
- HORIZONTAL WALL MOUNTED - ALUMINIUM RADIATOR (TYPE 22).
- VERTICAL WALL MOUNTED - ALUMINIUM RADIATOR (TYPE 33).
- HORIZONTAL WALL MOUNTED - ALUMINIUM RADIATOR (4 - 22 SECTIONS).
- VERTICAL WALL MOUNTED - ALUMINIUM RADIATOR (4 - 6 SECTIONS).
- HEATING SERVICES MANIFOLD
- AIR SOURCE HEAT PUMP MONO-BLOCK UNIT (REQUIRED SPACE HATCH INDICATED)
- PRE-PLUMBED HOT WATER CYLINDER (REQUIRED SPACE HATCH INDICATED)
- UNDERFLOOR HEATING CONTROL ZONE. EACH ZONE IS REGULATED BY A LINKED TEMPERATURE SENSOR (HATCH COLOUR DENOTES INDIVIDUAL ZONE OF CONTROL).

- | | | | |
|----|------------------|----|---------------|
| | ANALOG ROOM STAT | | 12V NEO STAT |
| | 230V ROOM STAT | | 230V NEO STAT |
| FA | FROM ABOVE | TA | TO ABOVE |
| FB | FROM BELOW | TB | TO BELOW |

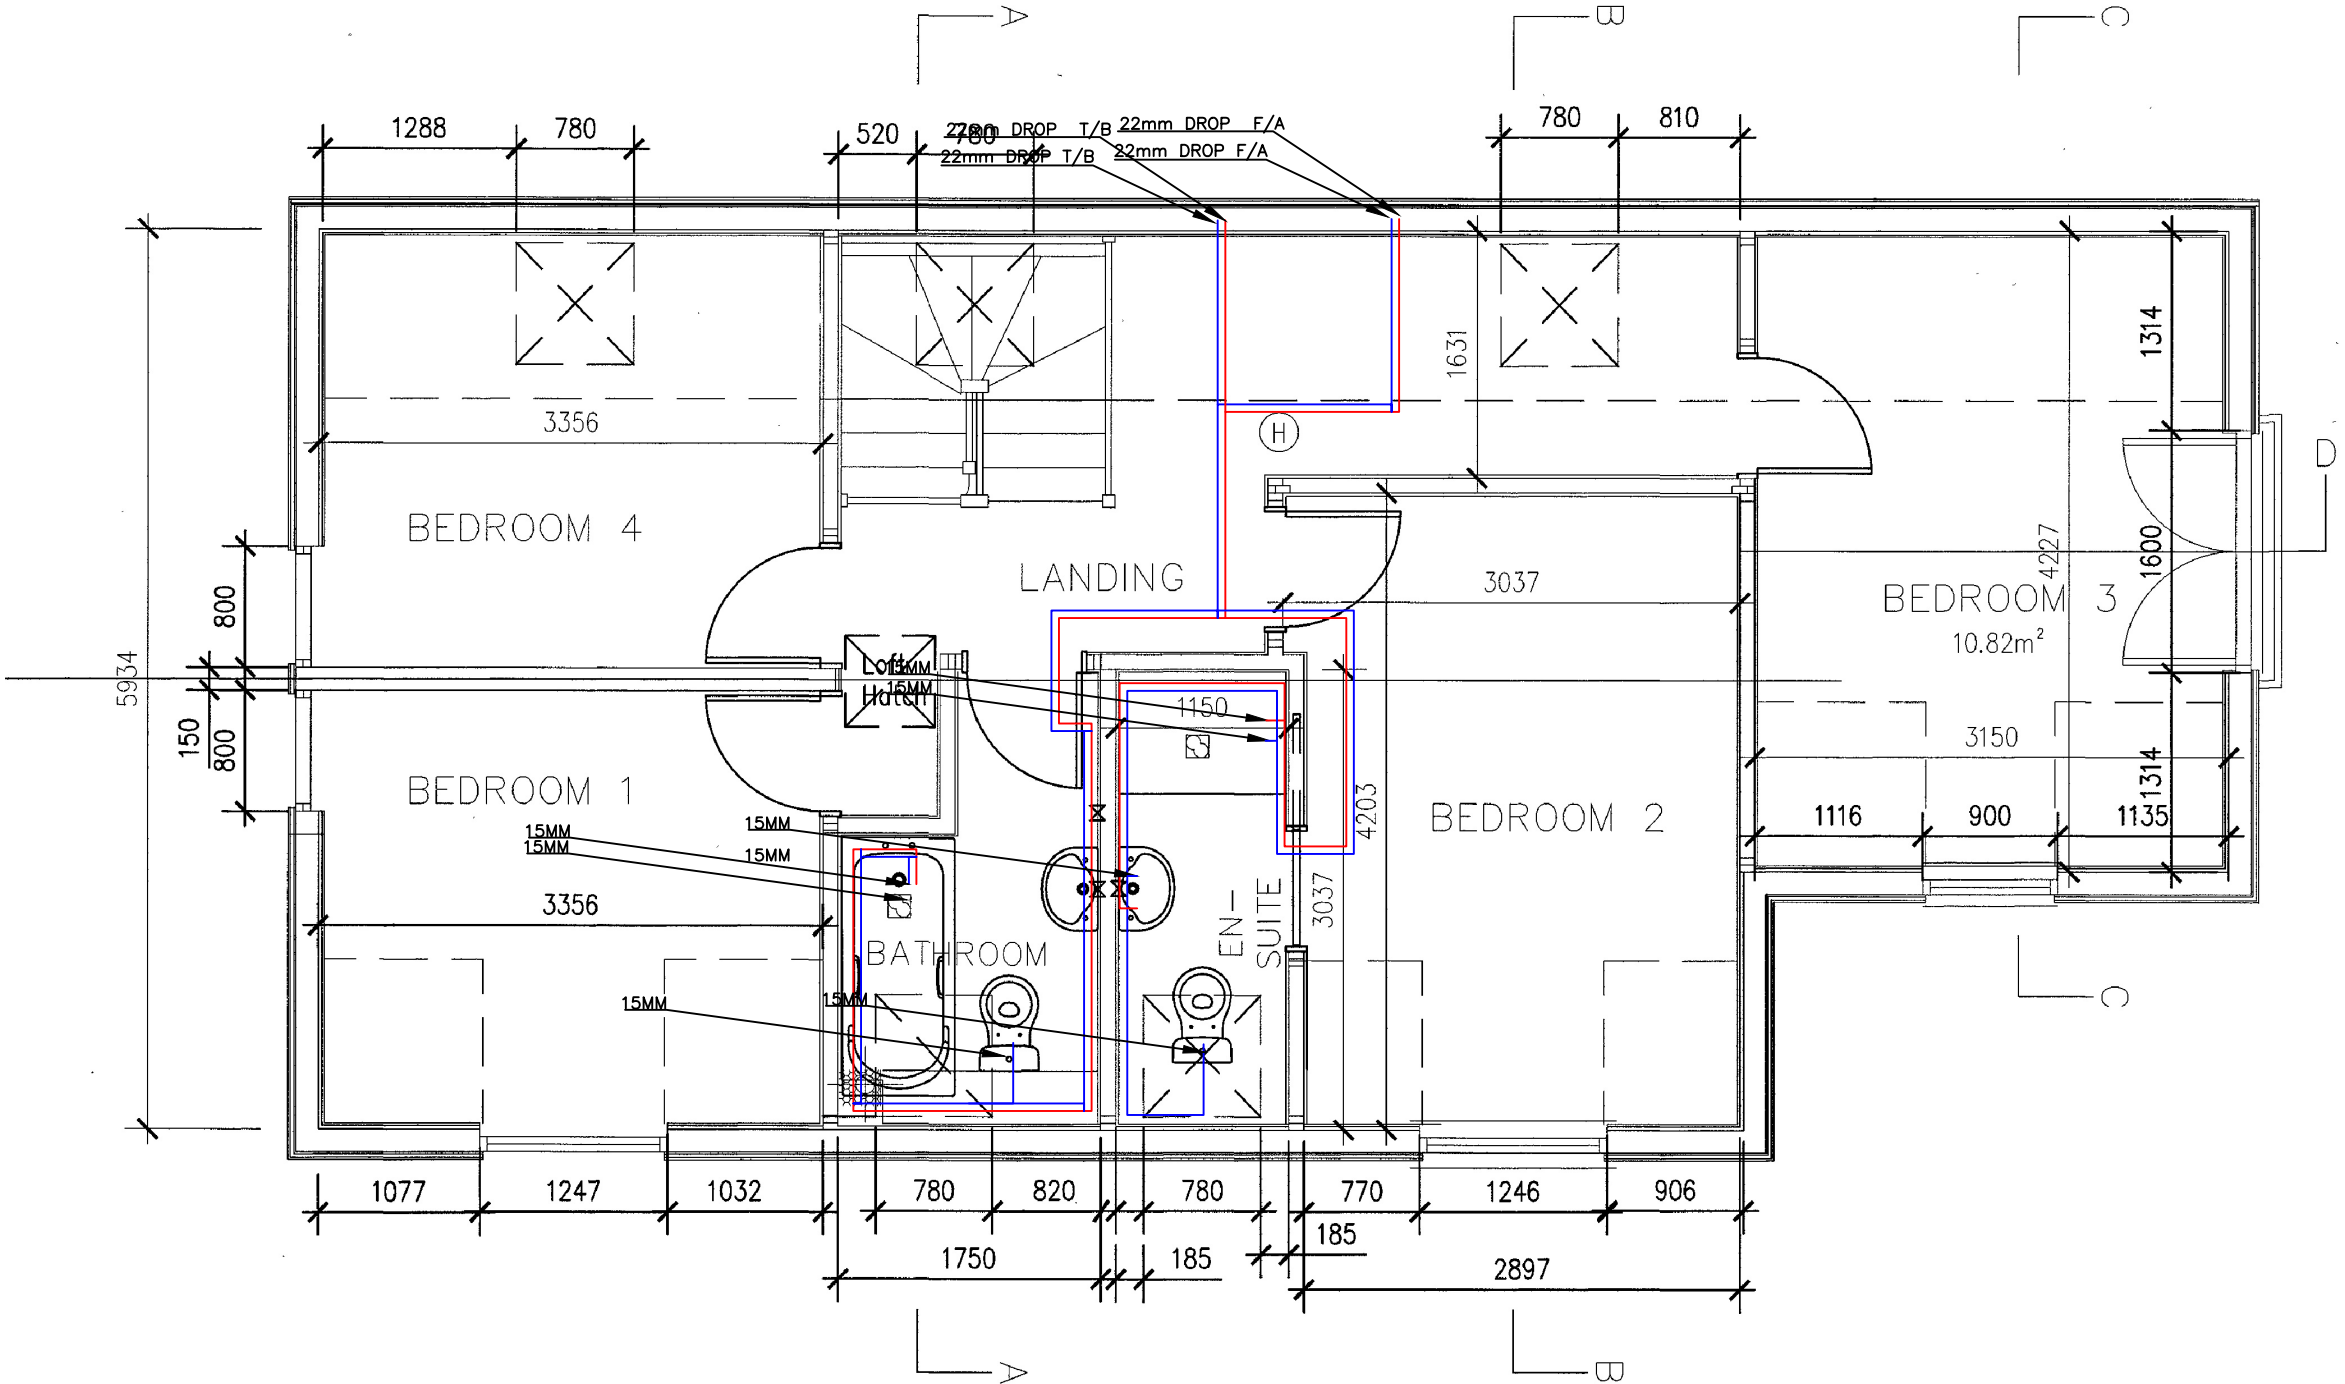

DRAWING TYPE HOT & COLD WATER SERVICES	PROJECT Rear of 6 Petlands Road, Haywards Heath	DWG NO:	310631806177	
DRAWING TITLE FIRST FLOOR	CLIENT	ISSUE DATE:	25/06/2026	
DWELLING TYPE HOUSE	ON BEHALF OF JOULE HEATING SOLUTIONS	SCALE:	1:50 @ A3	
		REVISION:	01	

NOTES - HEATING SERVICES

GENERAL NOTES

- THE COMPLETE MECHANICAL AND ELECTRICAL INSTALLATION SHALL BE INSTALLED AND COMMISSIONED IN ACCORDANCE WITH JOULE MECHANICAL AND ELECTRICAL INSTALLATION GUIDELINES PROVIDED WITH THE HEATING SYSTEM.
- FOR A DETAILED OVERVIEW OF THE HEATING SYSTEM, PLEASE REFER TO THE SYSTEM DRAWING SCHEMATICS.
 - ALL PIPEWORK SIZES NOTED REFER TO THE NOMINAL PIPE DIAMETER.
 - ALL PIPEWORK SHALL BE THERMALLY INSULATED IN ACCORDANCE WITH BS 5422: 2023.
 - JOULE RECOMMENDS THAT ALL JOINTS THAT ARE TO BE SOLDERED SHOULD BE MADE USING A FLUX THAT IS SPARINGLY APPLIED AND ANY RESIDUE IS FLUSHED OUT OF THE SYSTEM BEFORE COMMISSIONING.

HEAT PUMP

- THE HEAT PUMP SHALL BE A MONO-BLOCK UNIT TYPE C/W INDOOR HOT WATER CYLINDER, HOT WATER PRIORITY, INTERNAL UNIT TO LOCATED WITHIN PLANTROOM, EXTERNAL UNIT EXACT LOCATION TO BE AGREED WITH ARCHITECT.
- THE HOT WATER CYLINDER SHALL BE PRE-PLUMBED VALVE SET AND COME WITH 1NO. 3KW IMMERSION HEATERS, EXPANSION VESSEL, PACKAGED CONTROLS ETC.

UNDERFLOOR HEATING SYSTEM

- DO NOT CUT PIPES TO LENGTH PRIOR TO INSTALLATION:** THE LENGTHS OF PIPE LOOPS SHOWN ARE FOR GUIDANCE PURPOSES ONLY.
- INSTALL MANIFOLDS AT THE CORRECT HEIGHT:** UNDERFLOOR PIPE MANIFOLDS SHOULD BE INSTALLED AT A HEIGHT AT LEAST 600mm FROM THE FINISHED FLOOR UNLESS OTHERWISE SPECIFIED.
- FOLLOW MAXIMUM PIPE LENGTH RECOMMENDATIONS:** THE MAXIMUM RECOMMENDED PIPE LENGTH FOR 16mm PIPE IS 100m AND FOR 12mm PIPE IS 75m.
- ADHERE TO PIPE CENTRE RECOMMENDATIONS:** RECOMMENDED 16mm PIPE CENTRES ARE 150mm WHEN USING A LOW TEMPERATURE HEAT SOURCE, SUCH AS A HEAT PUMP, OR 200mm WHEN USING A HIGH TEMPERATURE HEAT SOURCE.
- MIXING SETS:** MIXING SETS ARE REQUIRED WITH HIGH TEMPERATURE HEAT SOURCES. WHEN USING A LOW TEMPERATURE HEAT SOURCE, MIXING SETS MAY NOT BE REQUIRED.
- CIRCULATION PUMP:** IT IS RECOMMENDED TO FIT A CIRCULATION PUMP TO THE MANIFOLD IF A MIXING SET IS NOT INSTALLED TO GUARANTEE CIRCULATION THROUGH THE UNDERFLOOR LOOPS.
- INSTALL A BYPASS VALVE:** A BYPASS VALVE MUST BE INSTALLED ON THE PRIMARY PIPEWORK TO THE UNDERFLOOR HEATING MANIFOLD.
- FOLLOW THE LAYOUT SCHEMATIC:** ADHERE TO THE LAYOUT SCHEMATIC PROVIDED FOR PIPE LAYOUT.
- INSTALL PIPE FLOW AROUND THE ROOM PERIMETER FIRST:** THE PIPE FLOW SHOULD BE INSTALLED AROUND THE PERIMETER OF THE ROOM FIRST TO PREVENT ANY POTENTIAL COLD SPOTS IN THE FLOOR IN THESE AREAS.
- PRESSURE TESTING:** PRESSURE TESTING MUST BE CARRIED OUT PRIOR TO THE LAYING OF SCREED. AIR (NOT WATER) MUST BE USED FOR PERIODS OF PROLONGED PRESSURE TESTING.
- FLOOR COVERING:** FLOOR COVERINGS SHOULD BE SUITABLE FOR USE WITH UNDERFLOOR HEATING. IF CARPETS ARE FITTED, THE UNDERLAY MUST HAVE A TOG NO GREATER THAN 1 WITH THE CARPET HAVING A TOG NO GREATER THAN 1.5, OR HAVE A MAXIMUM THERMAL RESISTANCE OF 0.15m²/K/W.
- SCREED CURING:** CONCRETE SCREED FLOORS MUST BE CURED BEFORE HEAT IS APPLIED. ALLOW 1 DAY PER 2mm OF SCREED BEFORE TURNING ON THE HEATING SYSTEM.
- FLOW TEMPERATURE:** WHEN TURNING HEAT ON IN A NEW PROPERTY, THE FLOW TEMPERATURE INTO THE PIPEWORK FROM THE HEAT SOURCE MUST BE INITIALLY SET TO 28° DEGREES CELSIUS. THE TEMPERATURE INCREASE SHOULD BE NO MORE THAN 2° DEGREES PER 24 HOURS UNTIL THE DESIRED FLOW TEMPERATURE IS REACHED.

RADIATOR INSTALLATION

- ALL RADIATORS TO BE SUPPLIED AND INSTALLED IN ACCORDANCE WITH JOULE INSTALLATION GUIDELINES AND OPERATIONS MANUAL.
- PRIOR TO ORDER OF THE RADIATORS THE CONTRACTOR SHALL VERIFY & CO-ORDINATE ALL RADIATORS SPECIFIED ON SITE. REFER TO ARCHITECTURAL LAYOUTS FOR SETTING OUT OF RADIATORS.
- ALL FINAL CONNECTIONS TO RADIATORS TO BE Ø15mm F&R.

ELECTRICAL NOTES

- THE UNDERFLOOR WIRING CENTRE REQUIRES ITS OWN 3 CORE SUPPLY FROM A 5A SUPPLY USING A 3 CORE 1.5mm CABLE. THE CONTROLLER MUST BE LOCATED IN CLOSE PROXIMITY TO THE UNDERFLOOR MANIFOLD. A 2 CORE 1.5mm CABLE IS REQUIRED TO PROVIDE A RUN SIGNAL BETWEEN THE UNDERFLOOR CONTROLLER AND THE BOILER/HEAT PUMP. EACH UNDERFLOOR WIRING CENTRE CAN BE CONNECTED TO A MAXIMUM OF 8 INDIVIDUAL ROOM STATS.
- 12V: WHEN USING 12V TEMPERATURE ROOM STATS, USE A CAT 5 / CAT 6 SHIELDED CABLE BETWEEN EACH ROOM STAT AND ITS RELEVANT UNDERFLOOR CONTROLLER.
- 230V: WHEN USING 230V TEMPERATURE ROOM STATS, THE CABLE SHOULD BE 3 CORE 1.5mm CABLE BETWEEN EACH ROOM AND ITS RELEVANT UNDERFLOOR CONTROLLER.

ADDITIONAL NOTES

- THIS DESIGN PACKAGE, PREPARED AND COPYRIGHTED BY JOULE:** IT IS INTENDED FOR CONFIDENTIAL USE BY OUR CLIENT OR THEIR DESIGNATED PARTIES FOR EQUIPMENT INSTALLATION PURPOSES.
- SAFETY RESPONSIBILITY:** INSTALLERS SHOULD ADHERE TO THEIR OWN CDM GUIDELINES WHEN HANDLING AND INSTALLING POTENTIALLY HEAVY EQUIPMENT.
- REGULATORY RESPONSIBILITY:** INSTALLERS' MUST ENSURE ALL SPACE HEATING AND DOMESTIC HOT WATER INSTALLATIONS COMPLY WITH LOCAL BUILDING REGULATIONS AND STANDARDS.


HEATING PIPEWORK REFERENCE KEY

- | | |
|--|---------------------------------|
| | Zone 1 Heating System Pipework |
| | Zone 2 Heating System Pipework |
| | Domestic Hot Water Supply |
| | Domestic Cold Water Supply |
| | Pipework at Low Level |
| | Pipework in Floor Voids |
| | Pipework in Roof / Ceiling Void |

HEATING SERVICES REFERENCE KEY

- | | |
|--|---|
| | HORIZONTAL WALL MOUNTED - STEEL PANEL RADIATOR (TYPE 11). |
| | HORIZONTAL WALL MOUNTED - ALUMINIUM RADIATOR (TYPE 22). |
| | VERTICAL WALL MOUNTED - ALUMINIUM RADIATOR (TYPE 33). |
| | HORIZONTAL WALL MOUNTED - ALUMINIUM RADIATOR (4 - 22 SECTIONS). |
| | VERTICAL WALL MOUNTED - ALUMINIUM RADIATOR (4 - 6 SECTIONS). |
| | HEATING SERVICES MANIFOLD |
| | AIR SOURCE HEAT PUMP MONO-BLOCK UNIT
(REQUIRED SPACE HATCH INDICATED) |
| | PRE-PLUMBED HOT WATER CYLINDER
(REQUIRED SPACE HATCH INDICATED) |
| | UNDERFLOOR HEATING CONTROL ZONE.
EACH ZONE IS REGULATED BY A LINKED TEMPERATURE SENSOR
(HATCH COLOUR DENOTES INDIVIDUAL ZONE OF CONTROL). |

- | | | | |
|----|------------------|----|---------------|
| | ANALOG ROOM STAT | | 12V NEO STAT |
| | 230V ROOM STAT | | 230V NEO STAT |
| FA | FROM ABOVE | TA | TO ABOVE |
| FB | FROM BELOW | TB | TO BELOW |

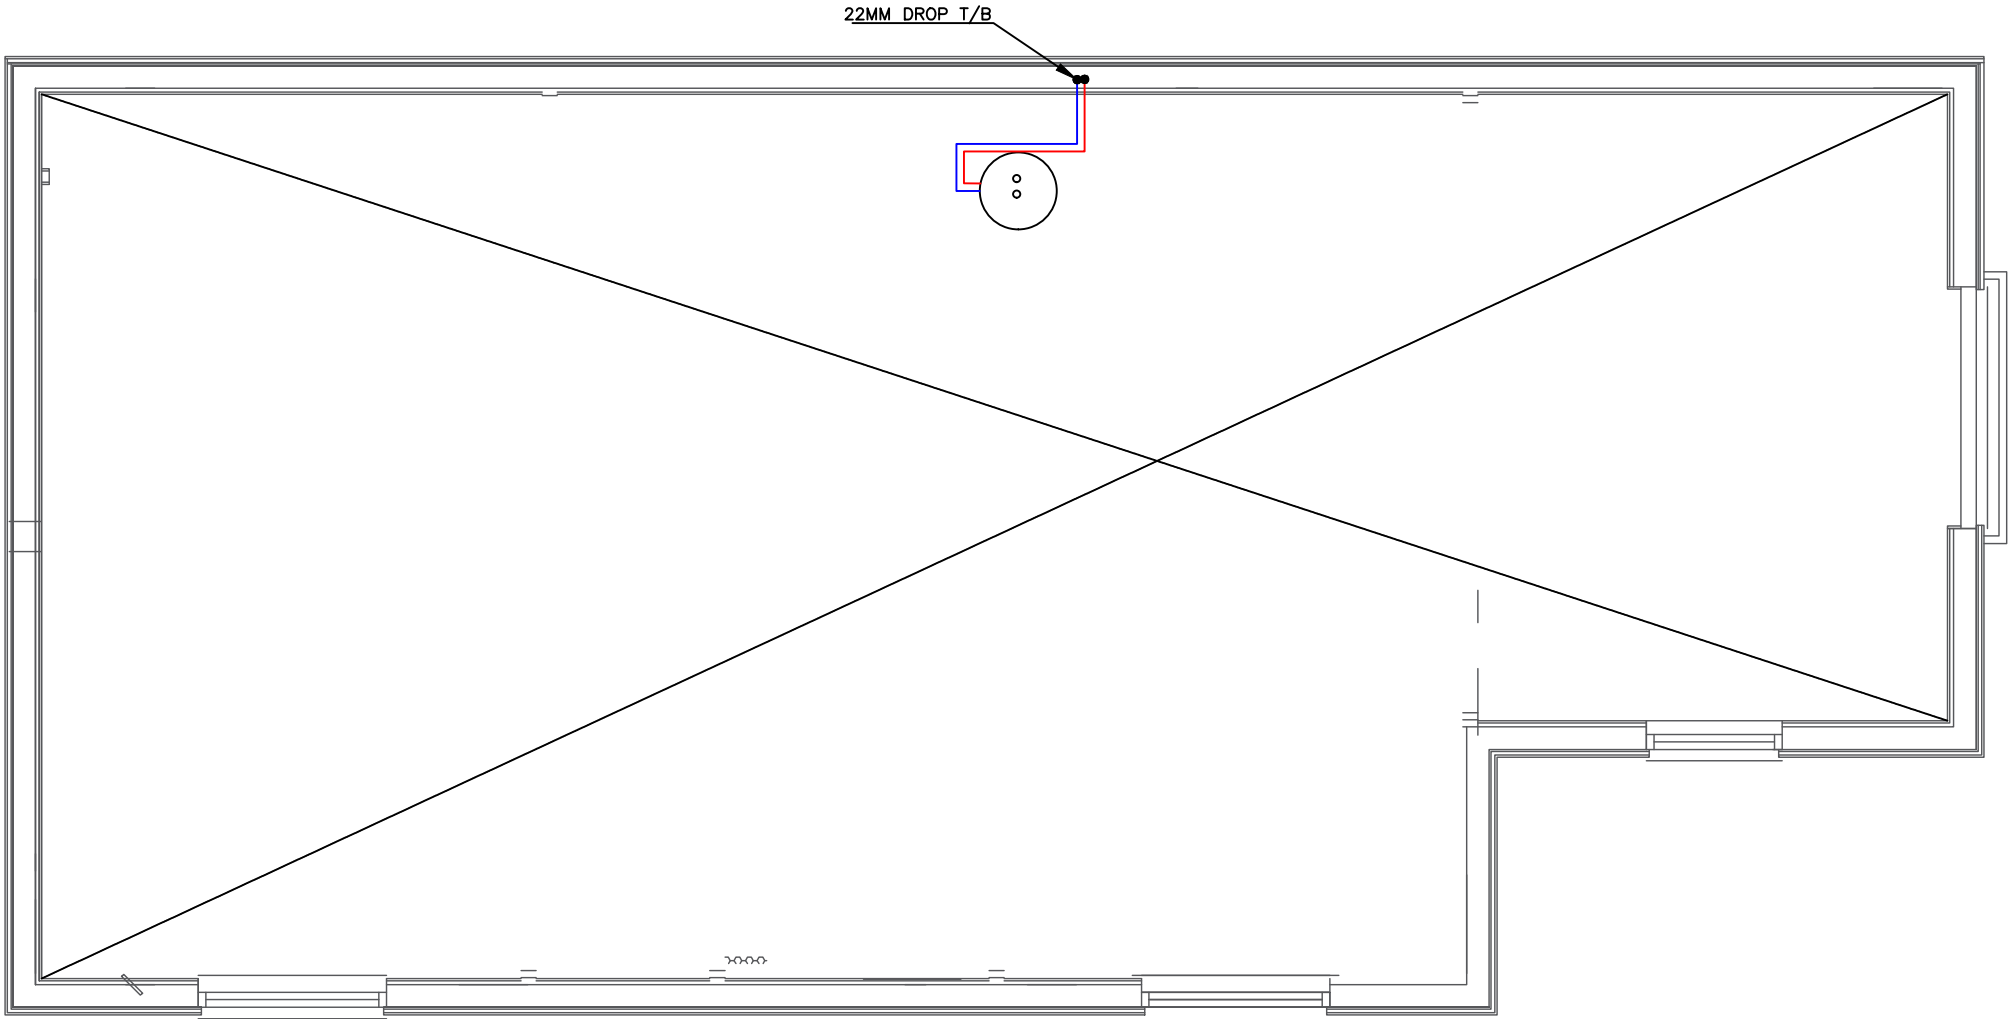

DRAWING TYPE HOT & COLD WATER SERVICES	PROJECT Rear of 6 Petlands Road, Haywards Heath	DWG NO:	310631806177	
DRAWING TITLE LOFT	CLIENT	ISSUE DATE:	25/06/2026	
DWELLING TYPE HOUSE	ON BEHALF OF JOULE HEATING SOLUTIONS	SCALE:	1:50 @ A3	
		REVISION:	01	