


• THIS DOCUMENT IS COPYRIGHT OF THE ORIGINATOR AND MUST BE TREATED AS CONFIDENTIAL.
• THIS DOCUMENT MUST NOT BE ALTERED, REPRODUCED OR DISTRIBUTED WITHOUT PRIOR WRITTEN CONSENT OF THE ORIGINATOR.
• DO NOT SCALE THIS DOCUMENT. ALL DIMENSIONS MUST BE CHECKED ON SITE PRIOR TO COMMENCEMENT OF ANY RELATED WORKS.
• THIS DOCUMENT MUST BE READ IN CONJUNCTION WITH ALL SUPPORTING DOCUMENTS PRODUCED BY THE ORIGINATOR.
• USERS OF THIS DOCUMENT ARE RESPONSIBLE FOR CHECKING WHICH REVISION IS CURRENT.

Notes & Symbols:

KEY	
	LED batten
	Spot light (spec. TBC)
	Pendant
	x
	Wall light
	LED strip lighting

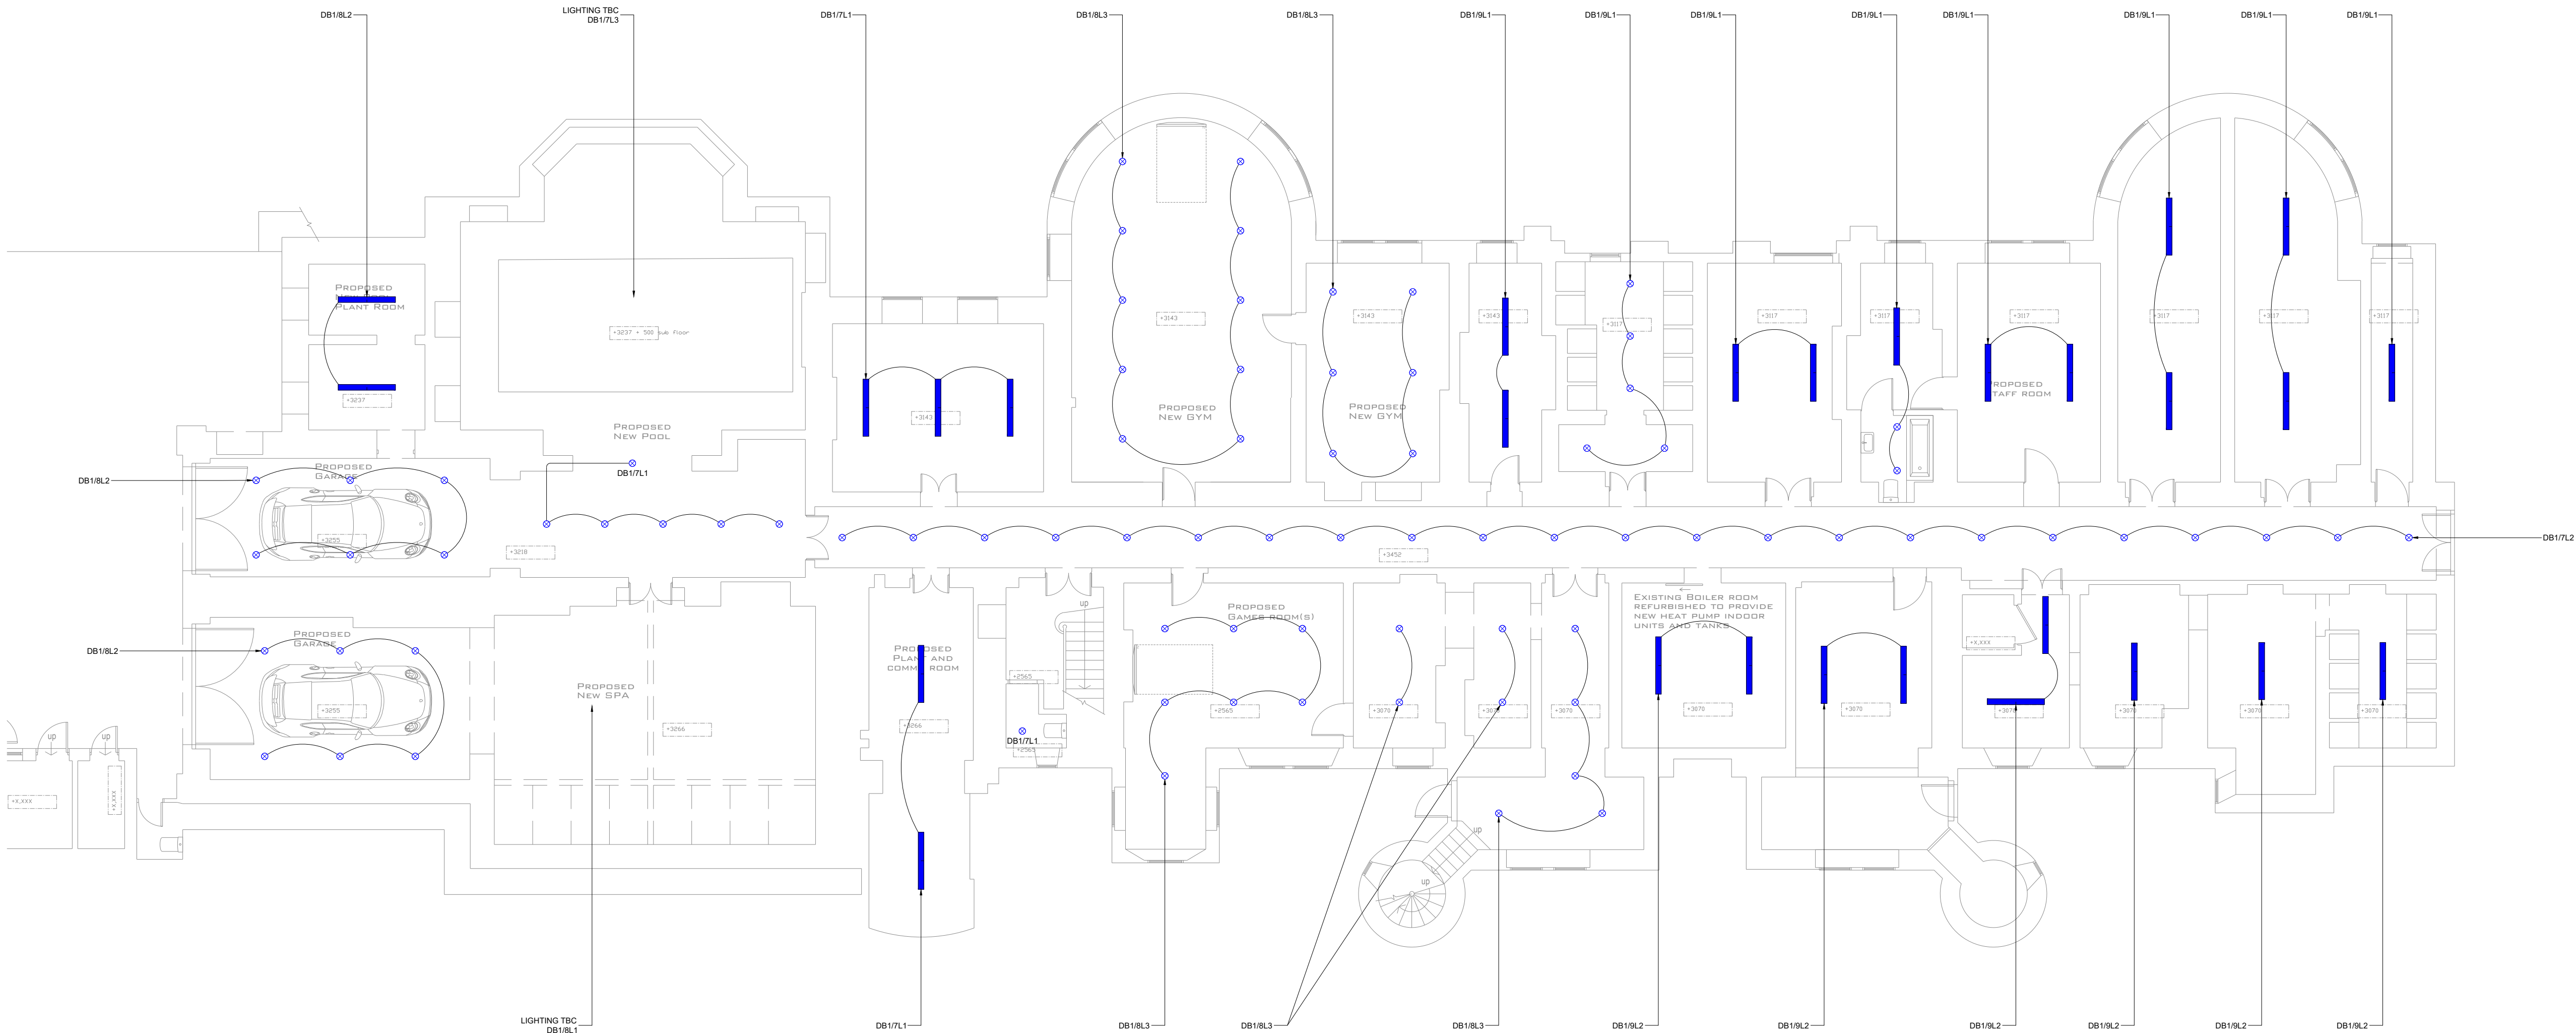

Rev.	Date.	Description.
------	-------	--------------



Project:
WYKEHURST PLACE

Drawing Title:
BASEMENT
LIGHTING LAYOUT

Scale:
1:100@A1

Date:
14/04/25

Drawing Status:
PROPOSED

Drawing No.
01

Revision: