



Services Key

- Denotes pull cord
- Denotes light switch (2 way)
- Denotes light switch (timer)
- Denotes light switch (dimmer)
- Denotes light switch (intermediate)
- Denotes telephone
- Denotes Entry Phone
- Denotes television aerial points
- Denotes HDMI television aerial points
- Denotes satellite point
- Denotes double socket
- Denotes double socket (floor level)
- Denotes cooker point
- Denotes Out 6 point
- Denotes spur
- Denotes shower socket incorporating light
- Denotes external water tap
- Denotes wall light
- Denotes ceiling rose
- Denotes low energy recessed spotlight
- Denotes fluorescent tube
- Denotes radiator
- Denotes PIR detector
- Denotes extractor fan
- Denotes smoke detector
- Denotes heat detector
- Denotes Carbon Monoxide detector
- Denotes meter
- Denotes gas point
- Denotes alarm panel
- Denotes alarm key point
- Denotes alarm call point
- Denotes emergency lighting self contained
- Denotes door bell sounder
- Denotes door bell push
- Denotes thermostat
- Denotes speaker
- Denotes fire extinguisher

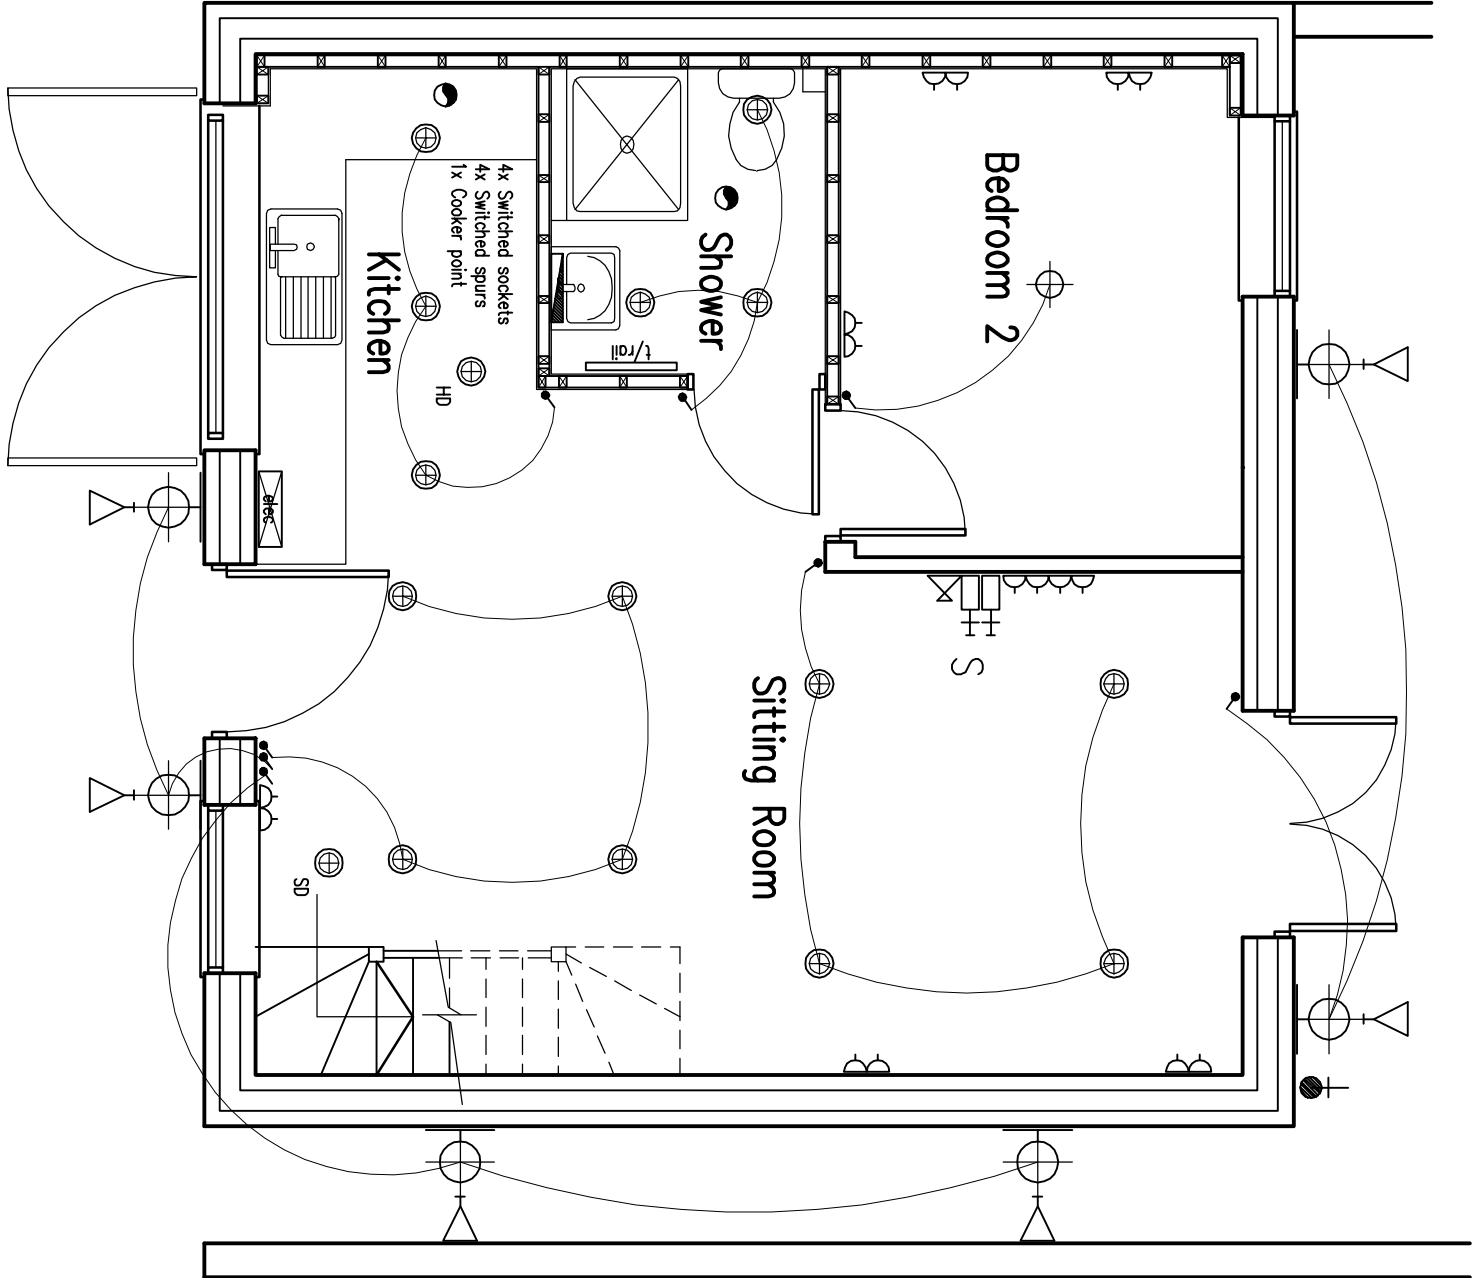

Ground Floor Plan

As Proposed

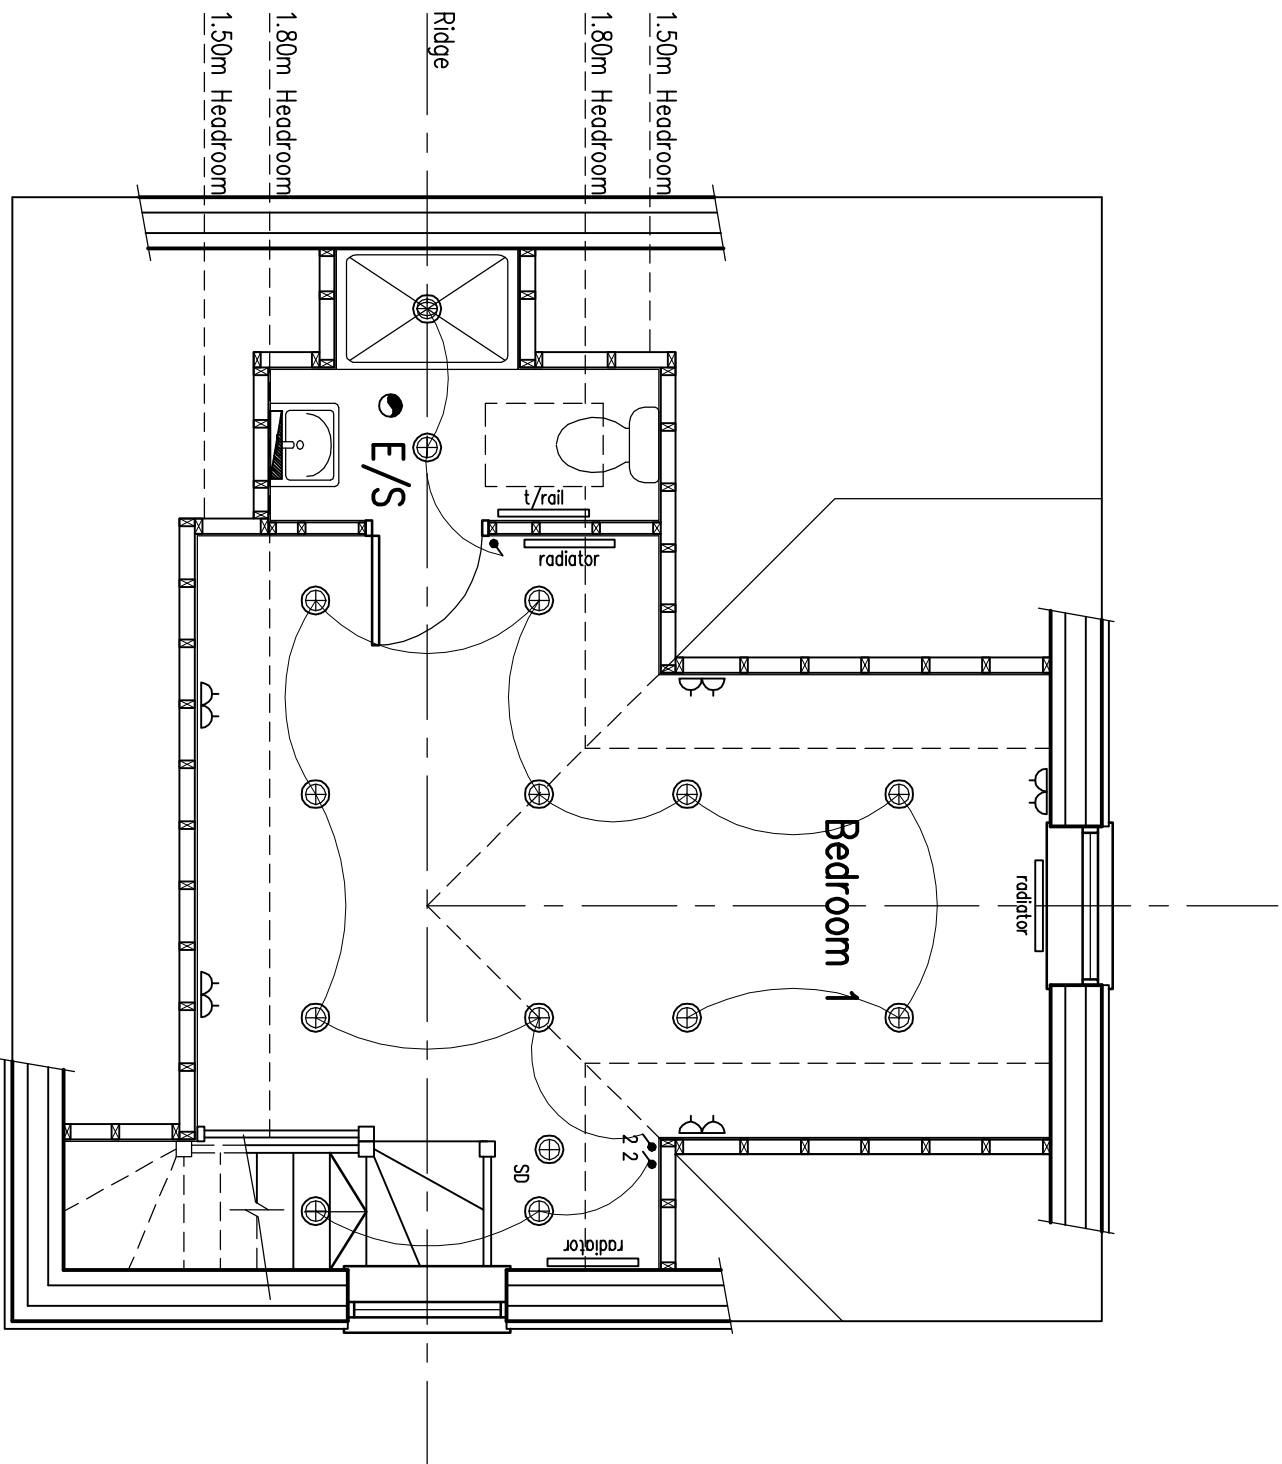

First Floor Plan

As Proposed

Copyright of:
Olive Voller Associates
Chartered Building Surveyors
15 Station Road
Burgess Hill
West Sussex
RH16 9DE
Tel: 01444 871010
Fax: 01444 870099
Web: www.olivevoller.com

RICS

Scale:
1:50 @ A1

Date:
Dec 2022

Drawn:

Dwg. No. **4044-14**

Rev'n **—**