


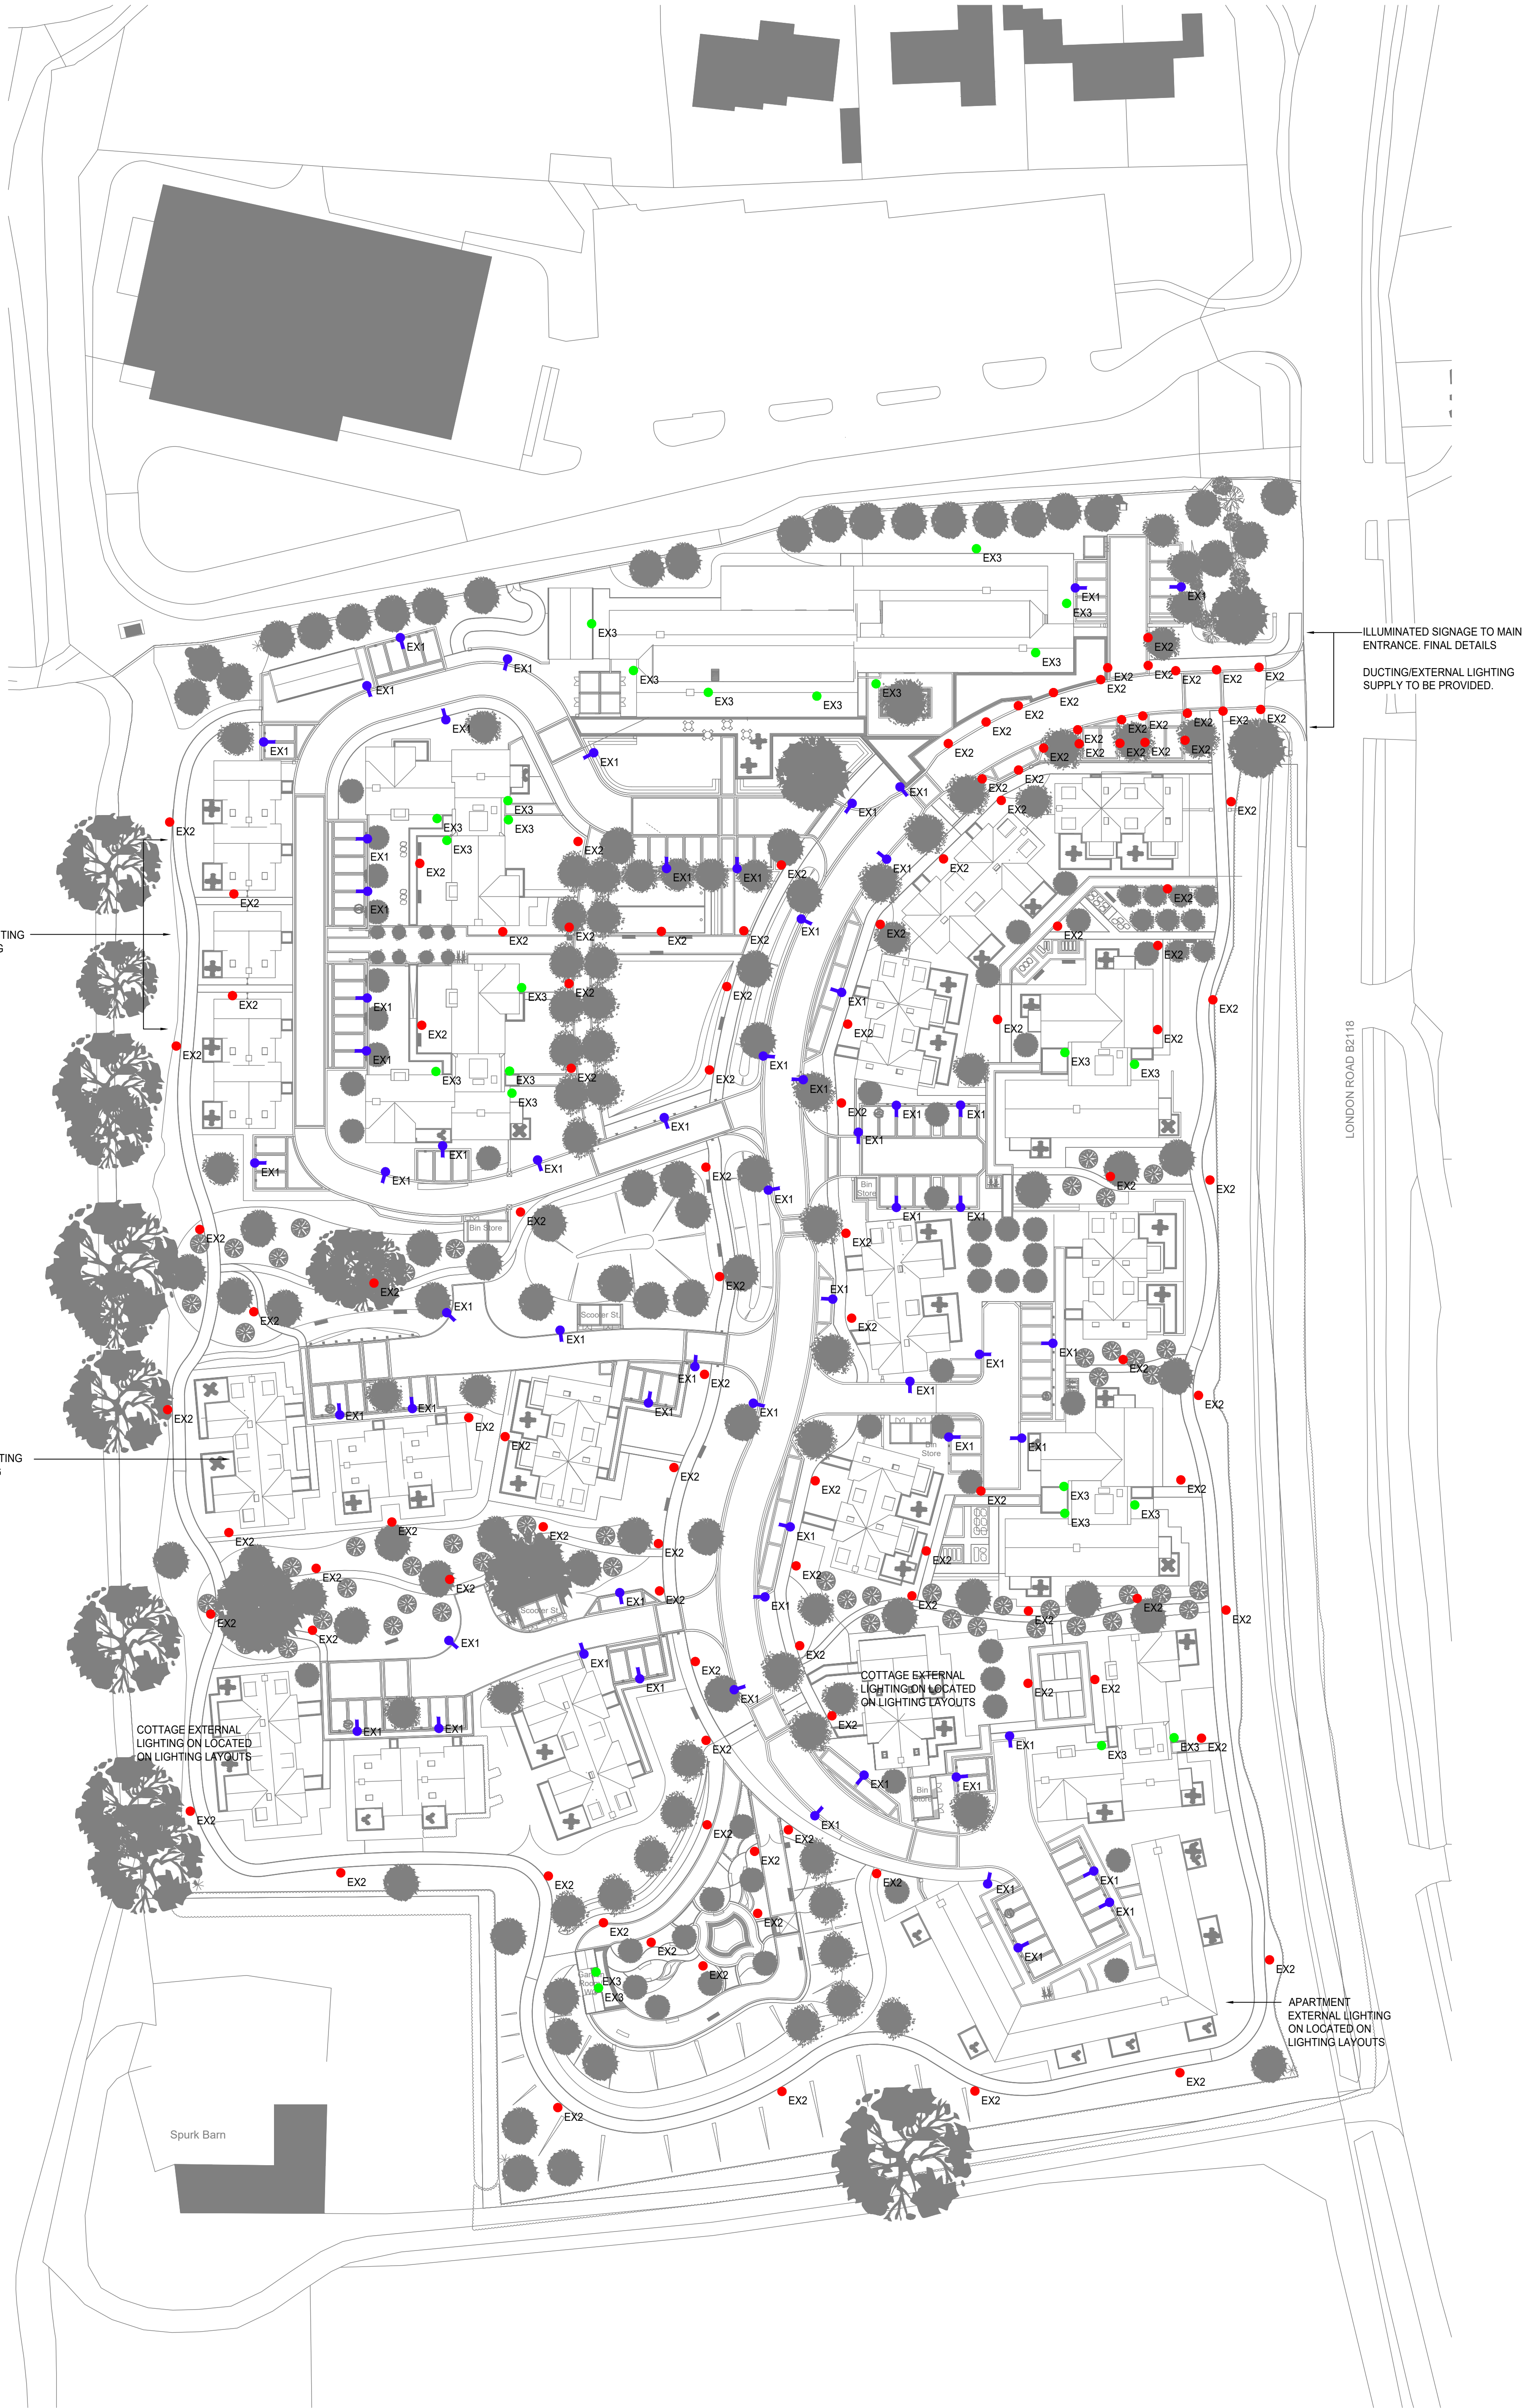

Notes

1. THE CONTRACTOR SHALL BE AWARE OF THEIR RESPONSIBILITIES WITH REGARD TO THE CONSTRUCTION (DESIGN AND MANAGEMENT) REGULATIONS AND SHALL UNDERTAKE THE DESIGN AND SUBSEQUENT INSTALLATION OF THESE SERVICES HAVING TAKEN DUE CONSIDERATION OF THESE REGULATIONS.
2. IN CONJUNCTION WITH THE INFORMATION DETAILED UPON THIS DRAWING THE CONTRACTOR SHALL FAMILIARISE THEMSELVES WITH ALL RELATED SERVICES AND TRADE DRAWINGS, SPECIFICATIONS AND SCHEDULES, ETC., ASSOCIATED WITH THESE WORKS. THIS SHALL INCLUDE, BUT NOT LIMITED TO, THE ELECTRICAL, MECHANICAL, PUBLIC HEALTH, ARCHITECTURAL AND STRUCTURAL WORKS.
3. THE CONTRACTOR SHALL FULLY COORDINATE ALL SERVICES USING THE COORDINATION AND INSTALLATION (WORKING) DRAWING PROCESS. THE CONTRACTOR SHALL COORDINATE WITH OTHER TRADES AND DISCIPLINES AND GENERAL COORDINATION WITH THE BUILDING FABRIC, STRUCTURE, ARCHITECTURAL FINISHES AND SPECIALIST TRADES.
4. INFORMATION AND DETAILS RELATING TO THIS DRAWING ARE FOR INFORMATION PURPOSES ONLY AND DO NOT CONSTITUTE THE EXTENT OF THE DESIGN INFORMATION OR ANY PART THEREOF. SIZES, DUTIES, RATINGS ETC. OF ANY PLANT OR EQUIPMENT DETAILED UPON THESE DRAWINGS ARE FOR GUIDANCE PURPOSES ONLY AND SHOULD BE CONFIRMED BY THE DESIGN AND BUILD CONTRACTOR.
5. THIS DRAWING IS NOT FOR CONSTRUCTION.

LEGEND

- EX1 WE-EF VFL 520 12 x 12W LED, 3000K POST TOP 4000mm
- EX2 WE-EF PSY 424 6 x 12W LED, 3000K BOLLARD 1000mm
- EX3 WE-EF SLS 410 LED UP/LIGHT/DOWNLIGHT WALL MOUNT
- COTTAGE/APARTMENT EXTERNAL WALL MOUNTED LUMINAIRES LOCATED ON SEPERATE LIGHTING LAYOUTS

/	04.09.2024	CHECKED WITH LATEST LANDSCAPE DESIGN
/	07.03.2024	EX3 REMOVED FROM COTTAGES, EX2 BY ENTRANCE AND PATHWAYS
/	31.01.2024	FOR INFORMATION

Rev.	Date	Details
------	------	---------

FOR INFORMATION	
Consulting Engineers Building Services	
SVM	
Berkhamsted	01442 869369

Architect
PRP

Structural Engineer
Ridge & Partners LLP

Quantity Surveyor
TFT

Project Name
Senior Living (Albourne) Ltd

Client
Inspired Villages

Drawing Title
Proposed External Lighting Layout

Scale	Date	Org. By	Drawn By	Checked
1:500@A0	JULY 2022	DMB	SJR	LIW

Drawing Number	Revision
----------------	----------

3187-SVM-ZZ-XX-DR-E-6302	/
--------------------------	---