


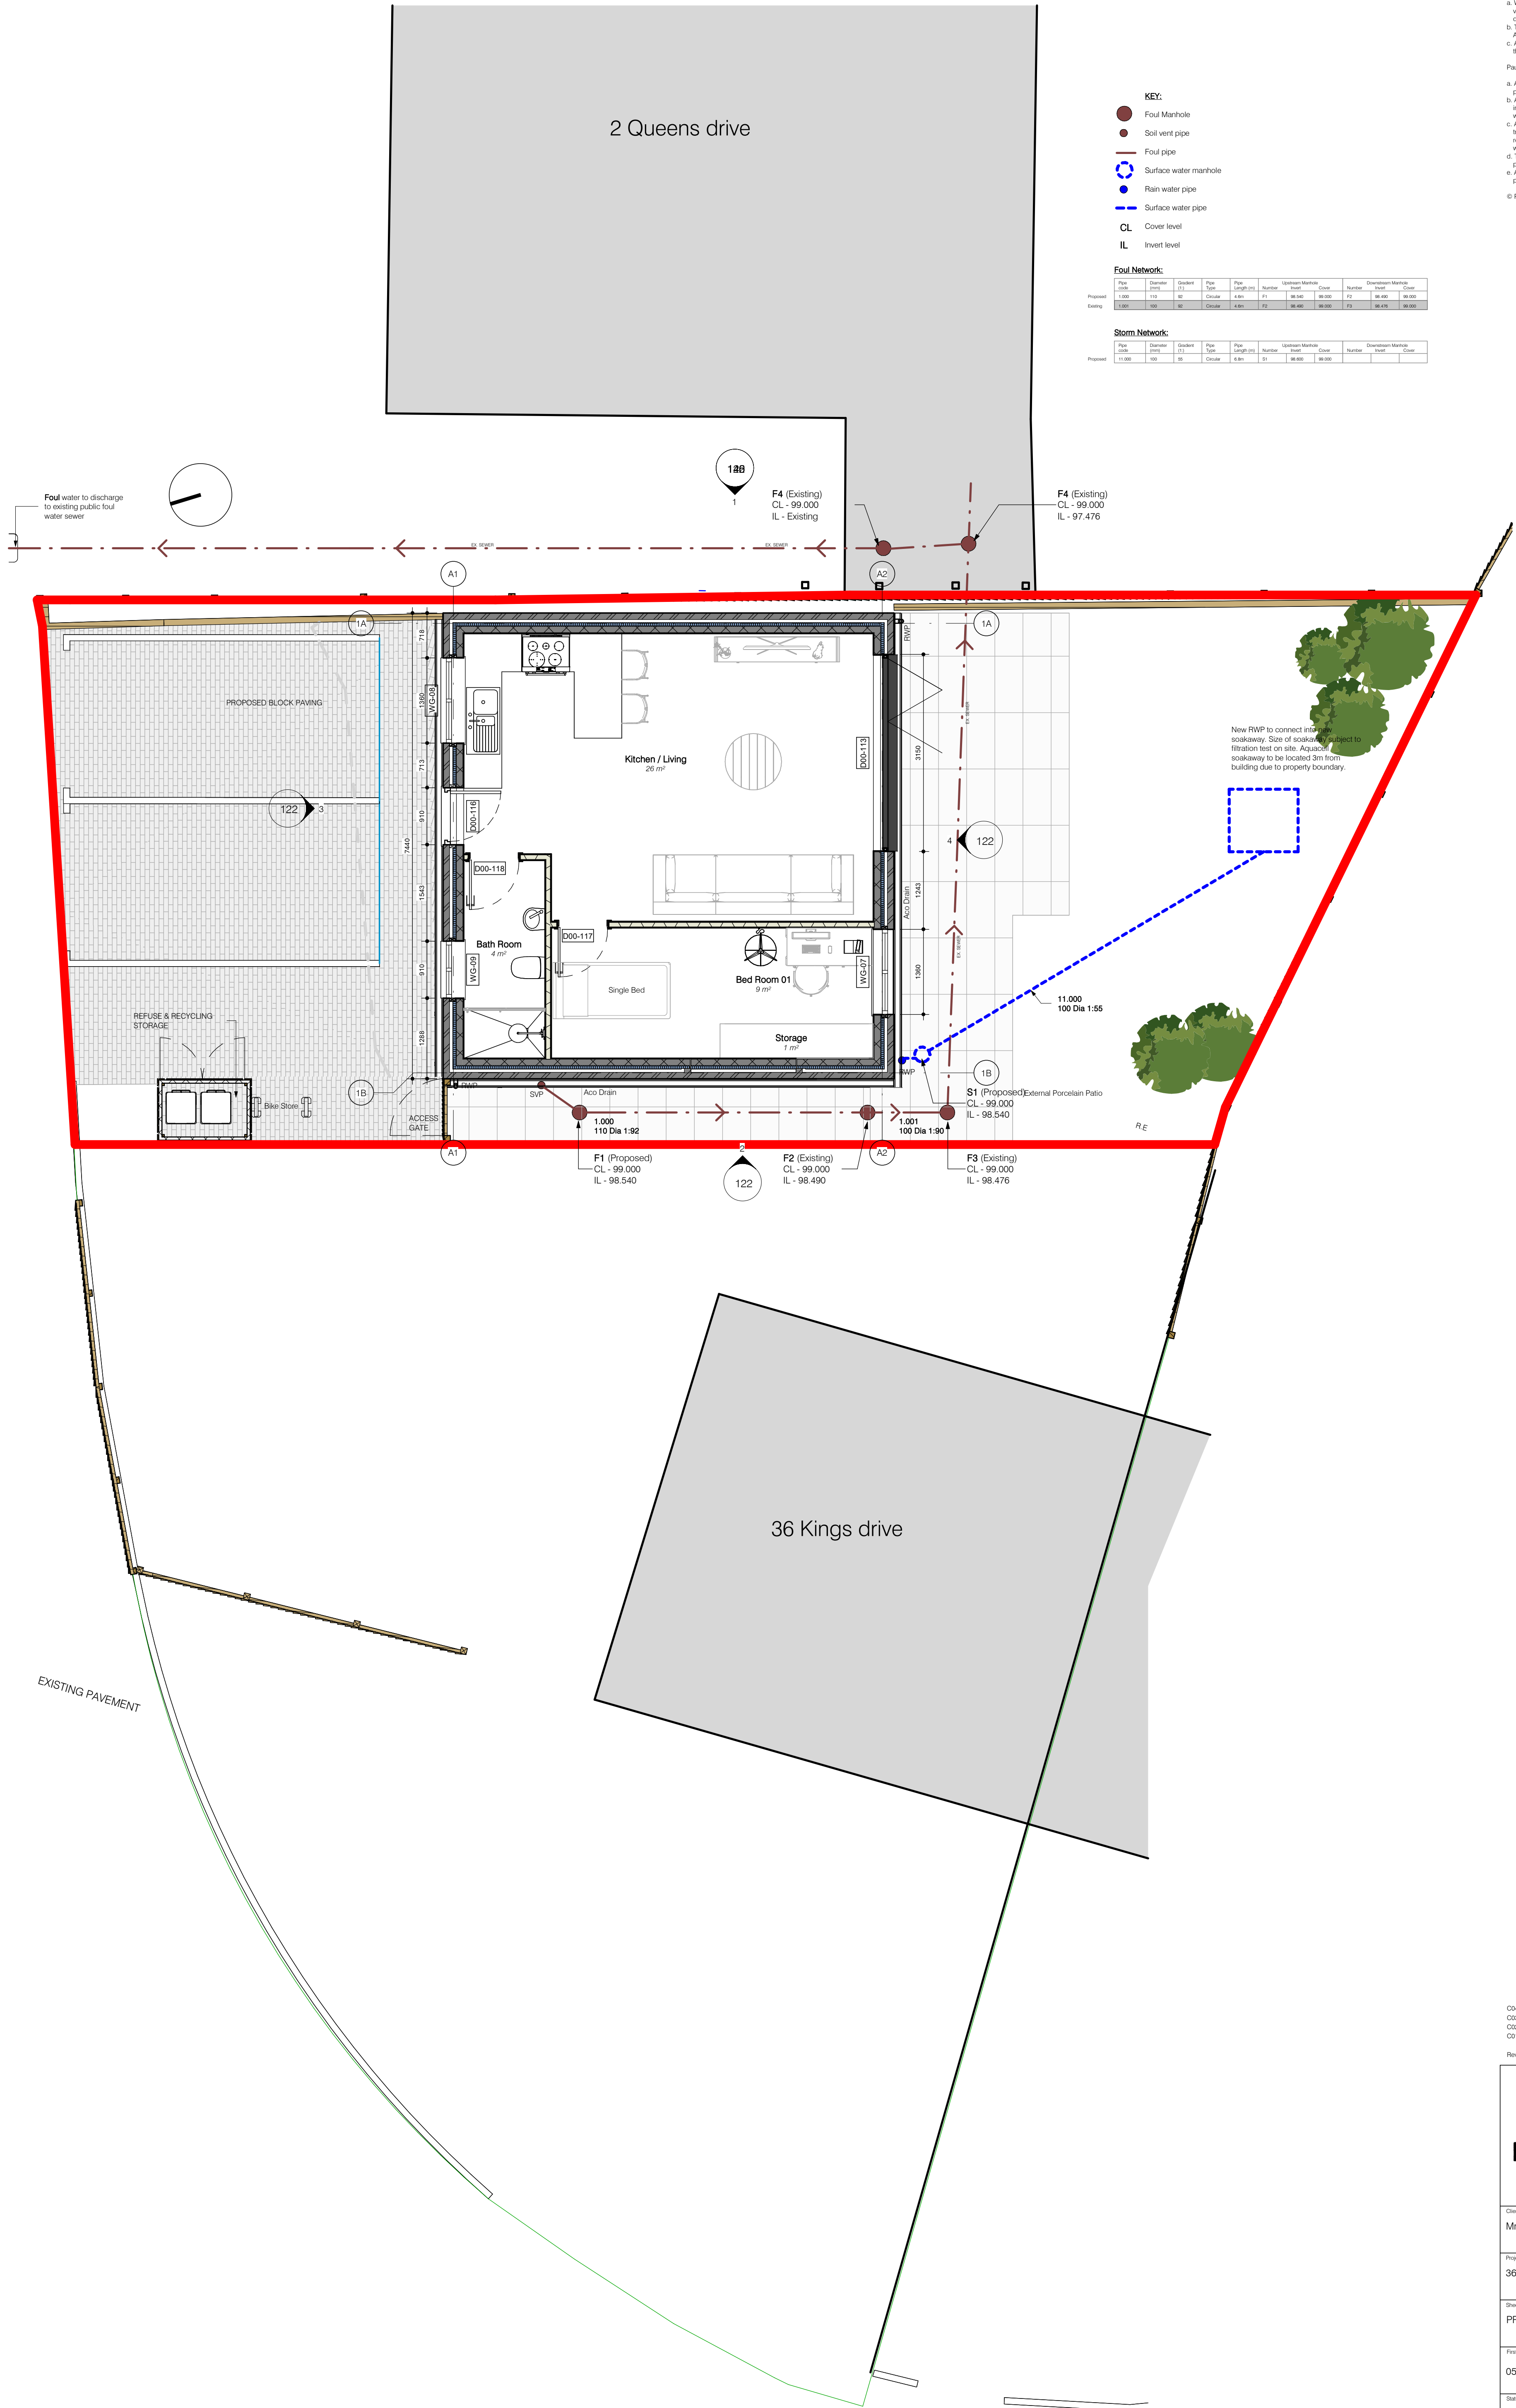

a. When this drawing is issued in uncontrolled .dwg format it will be accompanied by a .pdf version and is issued to enable the recipient to prepare their own documents, models or drawings for which they are solely responsible.  
b. The recipient should report all drawing errors, omissions and discrepancies to the Paul Architecture & Design.  
c. All dimensions should be checked on site by the contractor and such dimensions shall be the contractor's responsibility.

Paul Architecture & Design accepts no responsibility or liability for:

a. Any use of this drawing by parties other than the party for whom it was prepared or for purposes other than those for which it was prepared.  
b. Any alterations or additions to or discrepancies arising out of changes to the background information on which the drawings are based that was current at the time of issue, and which occur to that information after it has been issued by the Paul Architecture & Design.  
c. Any loss or degradation of the information held in this drawing resulting from the translation from the original file format to any other file format or from the recipient's reading of it in any other programme or any version of the programme other than that which was used to prepare it.  
d. The accuracy of survey information provided by others or for any costs, claims, proceedings and expenses arising out of reliance on such information.  
e. Any scaling from this drawing other than by the local planning authority solely for the purposes of the planning application to which it relates.

© Paul Architecture & Design | SN12 6LT

**KEY:**

- Foul Manhole
- Soil vent pipe
- Foul pipe
- Surface water manhole
- Rain water pipe
- Surface water pipe
- CL - Cover level
- IL - Invert level

**Foul Network:**

| Flow  | Direction | Depth | Pipe   | Pipe | Manhole | Upstream Manhole | Downstream Manhole |
|-------|-----------|-------|--------|------|---------|------------------|--------------------|
| Rate  | Flow      | Flow  | Flow   | Flow | Flow    | Flow             | Flow               |
| 1.000 | 110       | 50    | Circle | 4.0m | F1      | 98.540           | 98.000             |
| 1.001 | 100       | 50    | Circle | 4.0m | F2      | 98.490           | 98.000             |

**Storm Network:**

| Flow  | Direction | Depth | Pipe   | Pipe | Manhole | Upstream Manhole | Downstream Manhole |
|-------|-----------|-------|--------|------|---------|------------------|--------------------|
| Rate  | Flow      | Flow  | Flow   | Flow | Flow    | Flow             | Flow               |
| 1.000 | 110       | 50    | Circle | 4.0m | F1      | 98.540           | 98.000             |
| 1.001 | 100       | 50    | Circle | 4.0m | F2      | 98.490           | 98.000             |

Paul Architecture & Design

**PAUL DESIGNS**

Client Name:  
Mr D SHORT

Project Name:  
36 KINGS DRIVE, HASSECKS, WEST SUSSEX BN6 8DZ

Sheet Description:  
PROPOSED GROUND FLOOR PLAN

First Issued: 05/10/24  
Author: PO  
Checked: PO  
Project: HAS  
Scale: 1 : 50

Status & Issue Purpose:  
S2\_Suitable for Information

Revision:  
C04

S2\_Suitable for Information Note: This drawing has been prepared to show design intent and coordination between disciplines, and is to be used for information only.

Name:  
M2025-PD-M9-00-DR-A-113