


Landscaping & Lighting scheme design

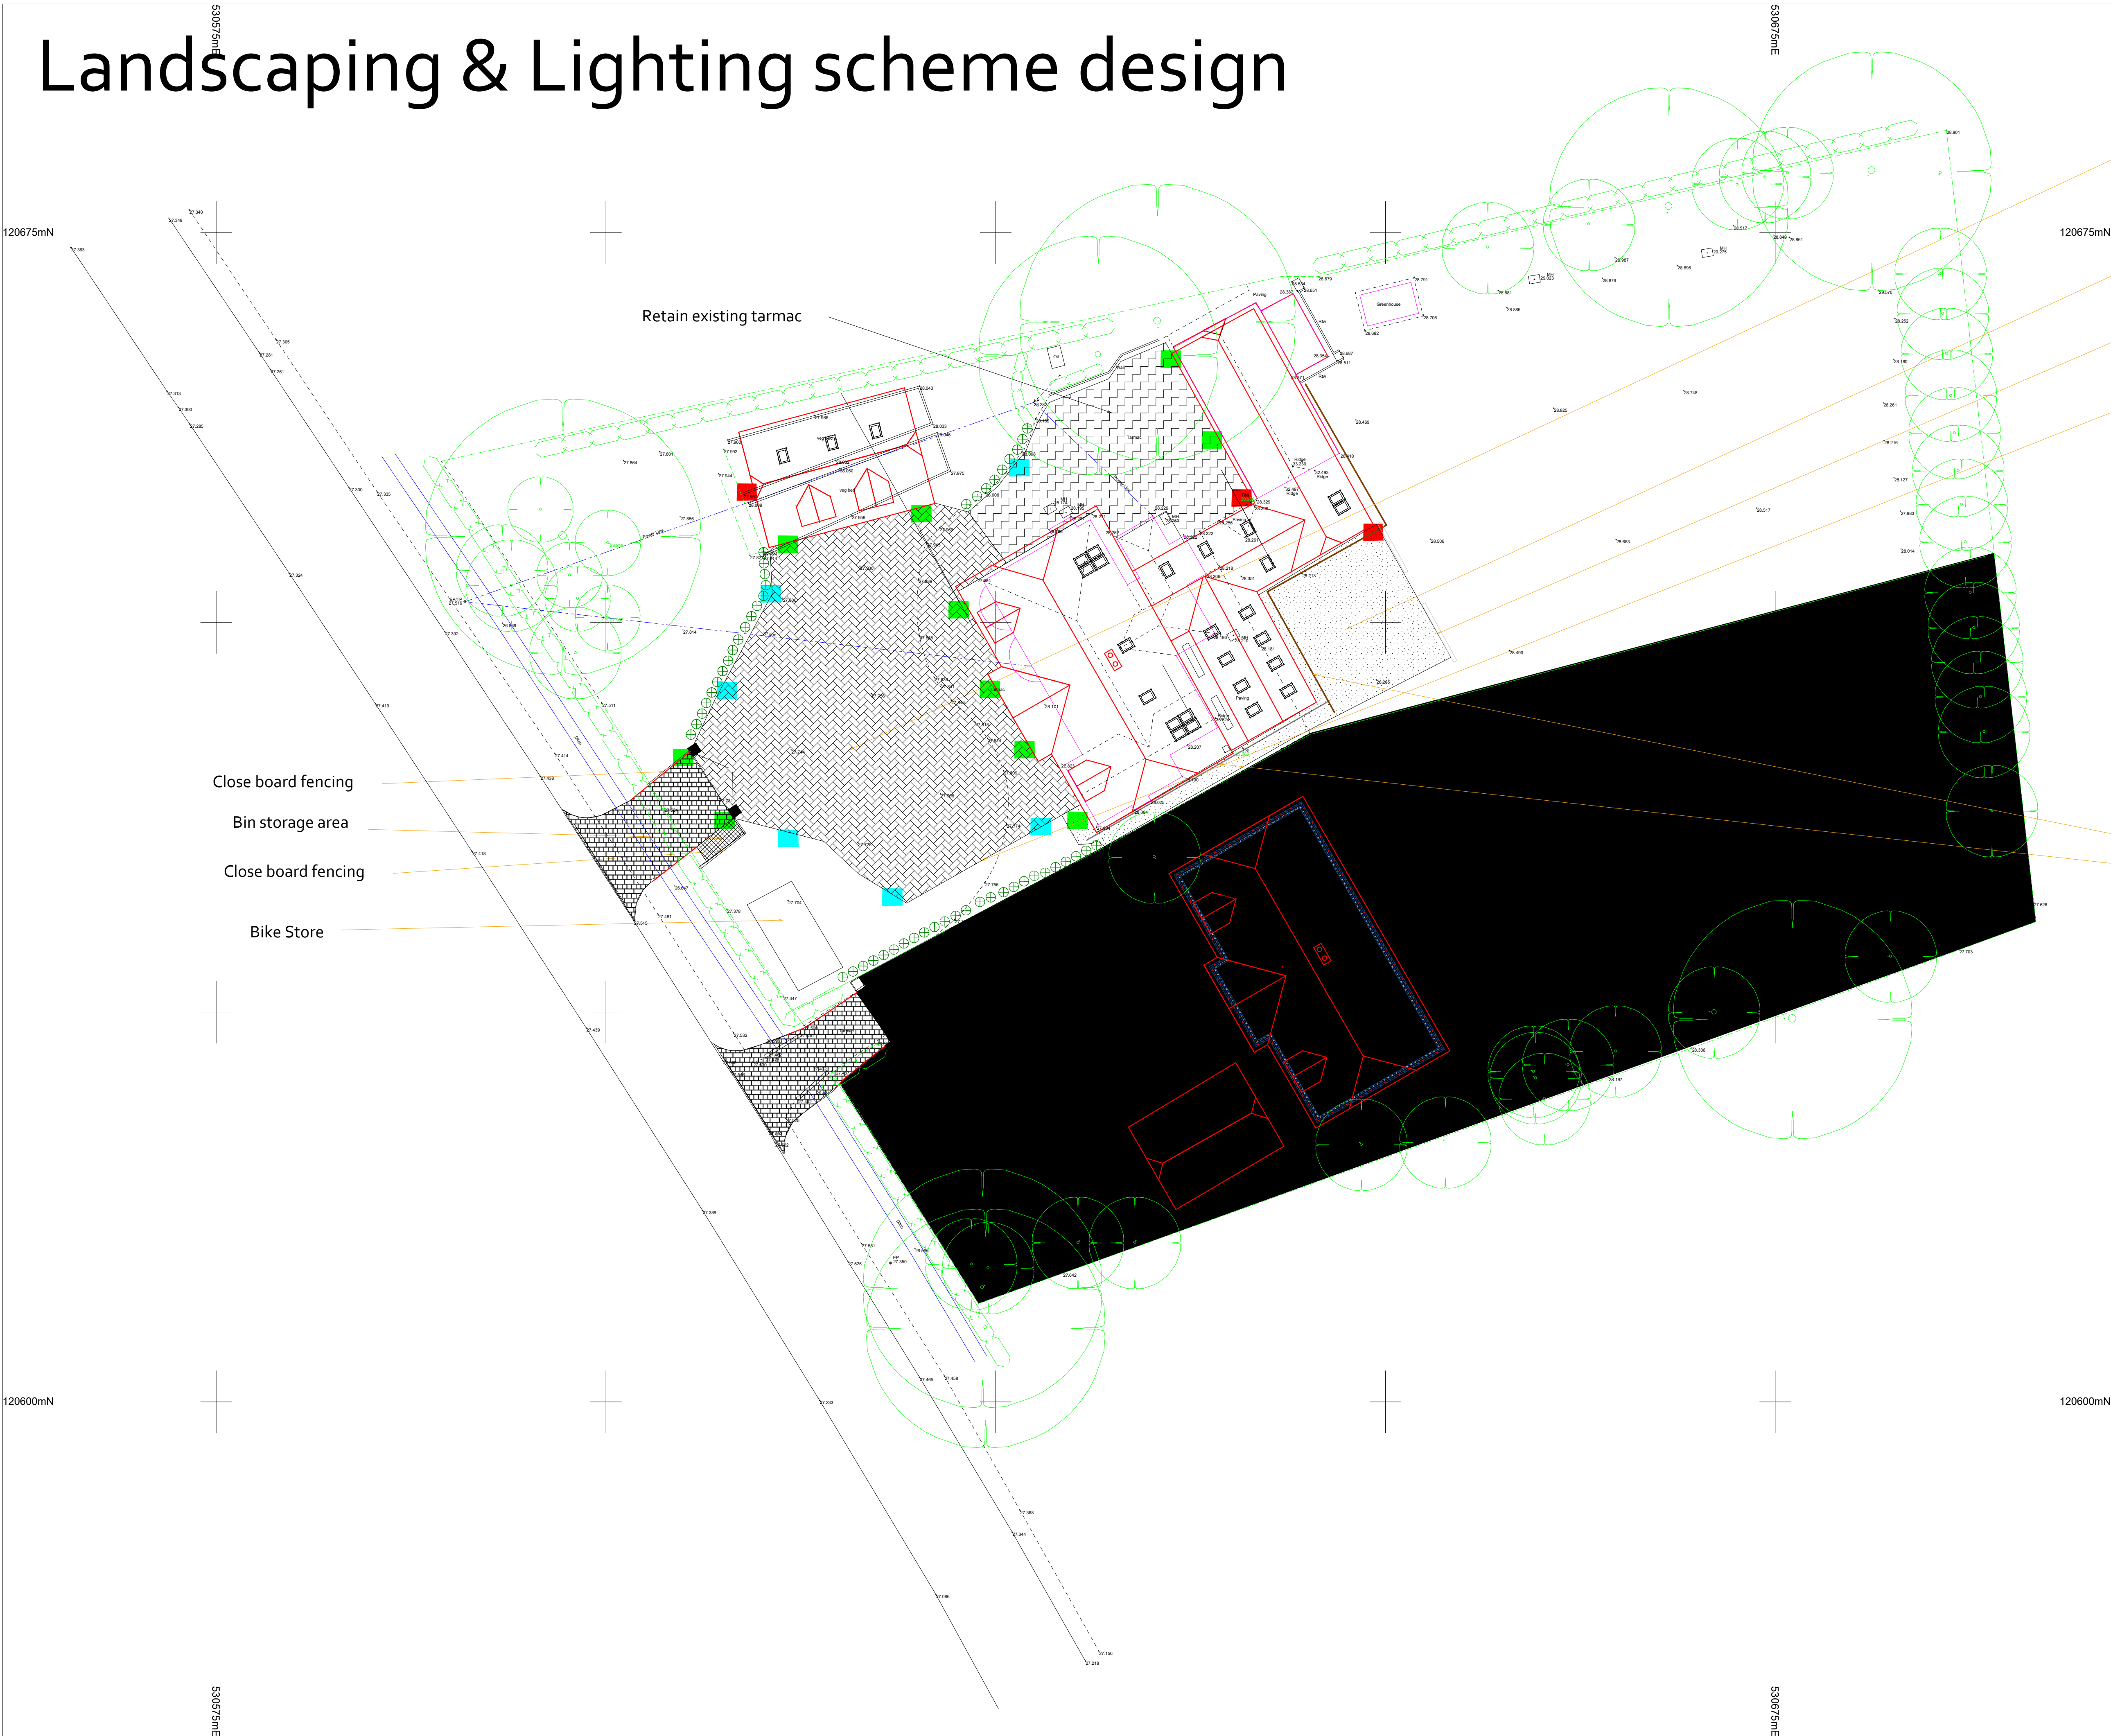

Landscaping Scheme

Key

1.5 metre portuguese laurel

Country cobble paviors

Permeable resin bound

small retaining wall

Corton steel edging

Lighting Scheme

Key

Wall light

Low level bollard

PIR Lighting

PIR lighting only

No lighting

N

10000

20000

Grid 25.00m A1 @1:200

ARCHITECTURAL JONES • PROJECTS

f

t

p

in

Site

Hollytree House
Cuckfield Road
Burgess Hill

Drawing Title

Site plan

Scale

1:200

Surveyed
MPN

Drawn
MPN

Checked
GLN

Project No
006

Drawing No
0123/006/01

Date
01/01/2023