




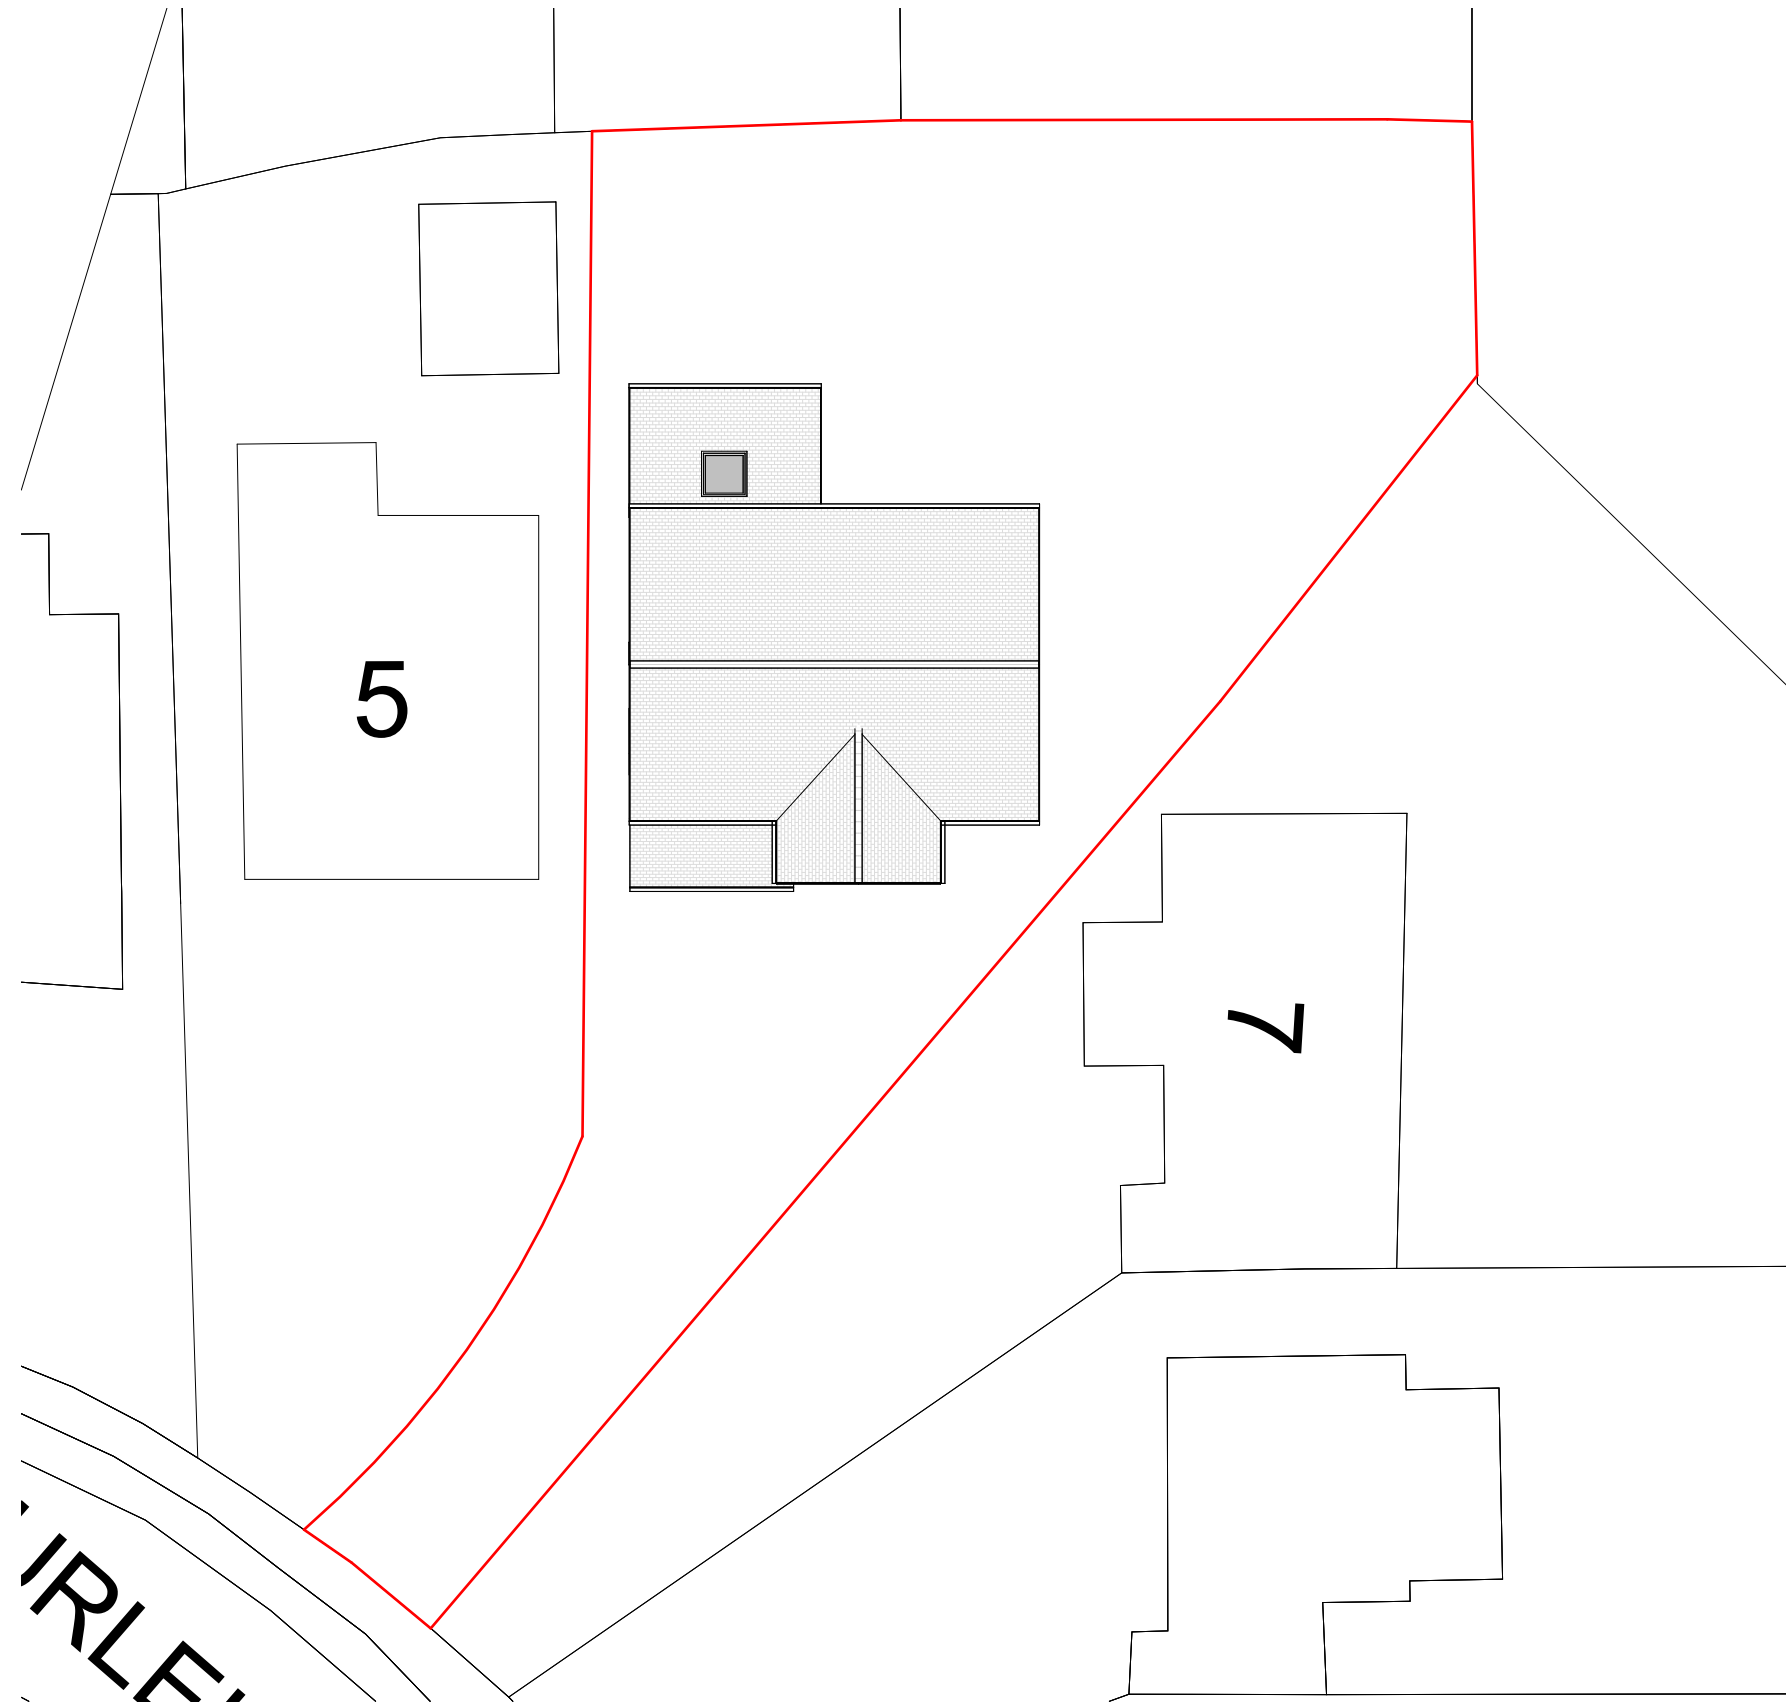

BURLEIGH
Site Plan

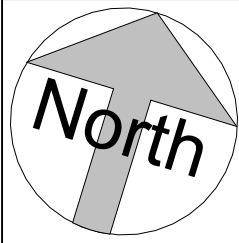

3D View 1

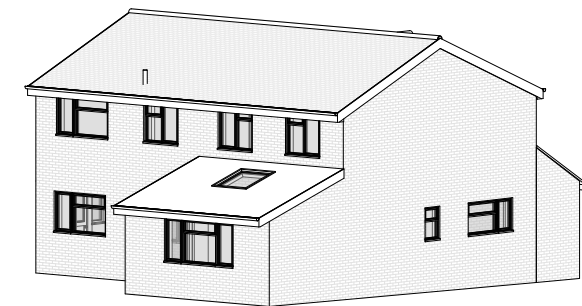

3D View 2



FLUENT
ARCHITECTURAL DESIGN SERVICES
TEL: 0800 043 8838
E-MAIL: INFO@FLUENT-ADS.CO.UK
WEB: FLUENT-ADS.CO.UK

6 Burleigh Close Crawley Down

Existing Site Plan and 3D Views

Scale @ A3
1 : 200

Date
03.12.25

Drawn by
S.G

 
Drawing number
P.M.100

Project number
2473

Rev
0

Key:

Existing Proposed SVP Boundary line
Existing drainage Proposed drainage Overhead



No.	Description	Date
0	First Draft	03.12.25