

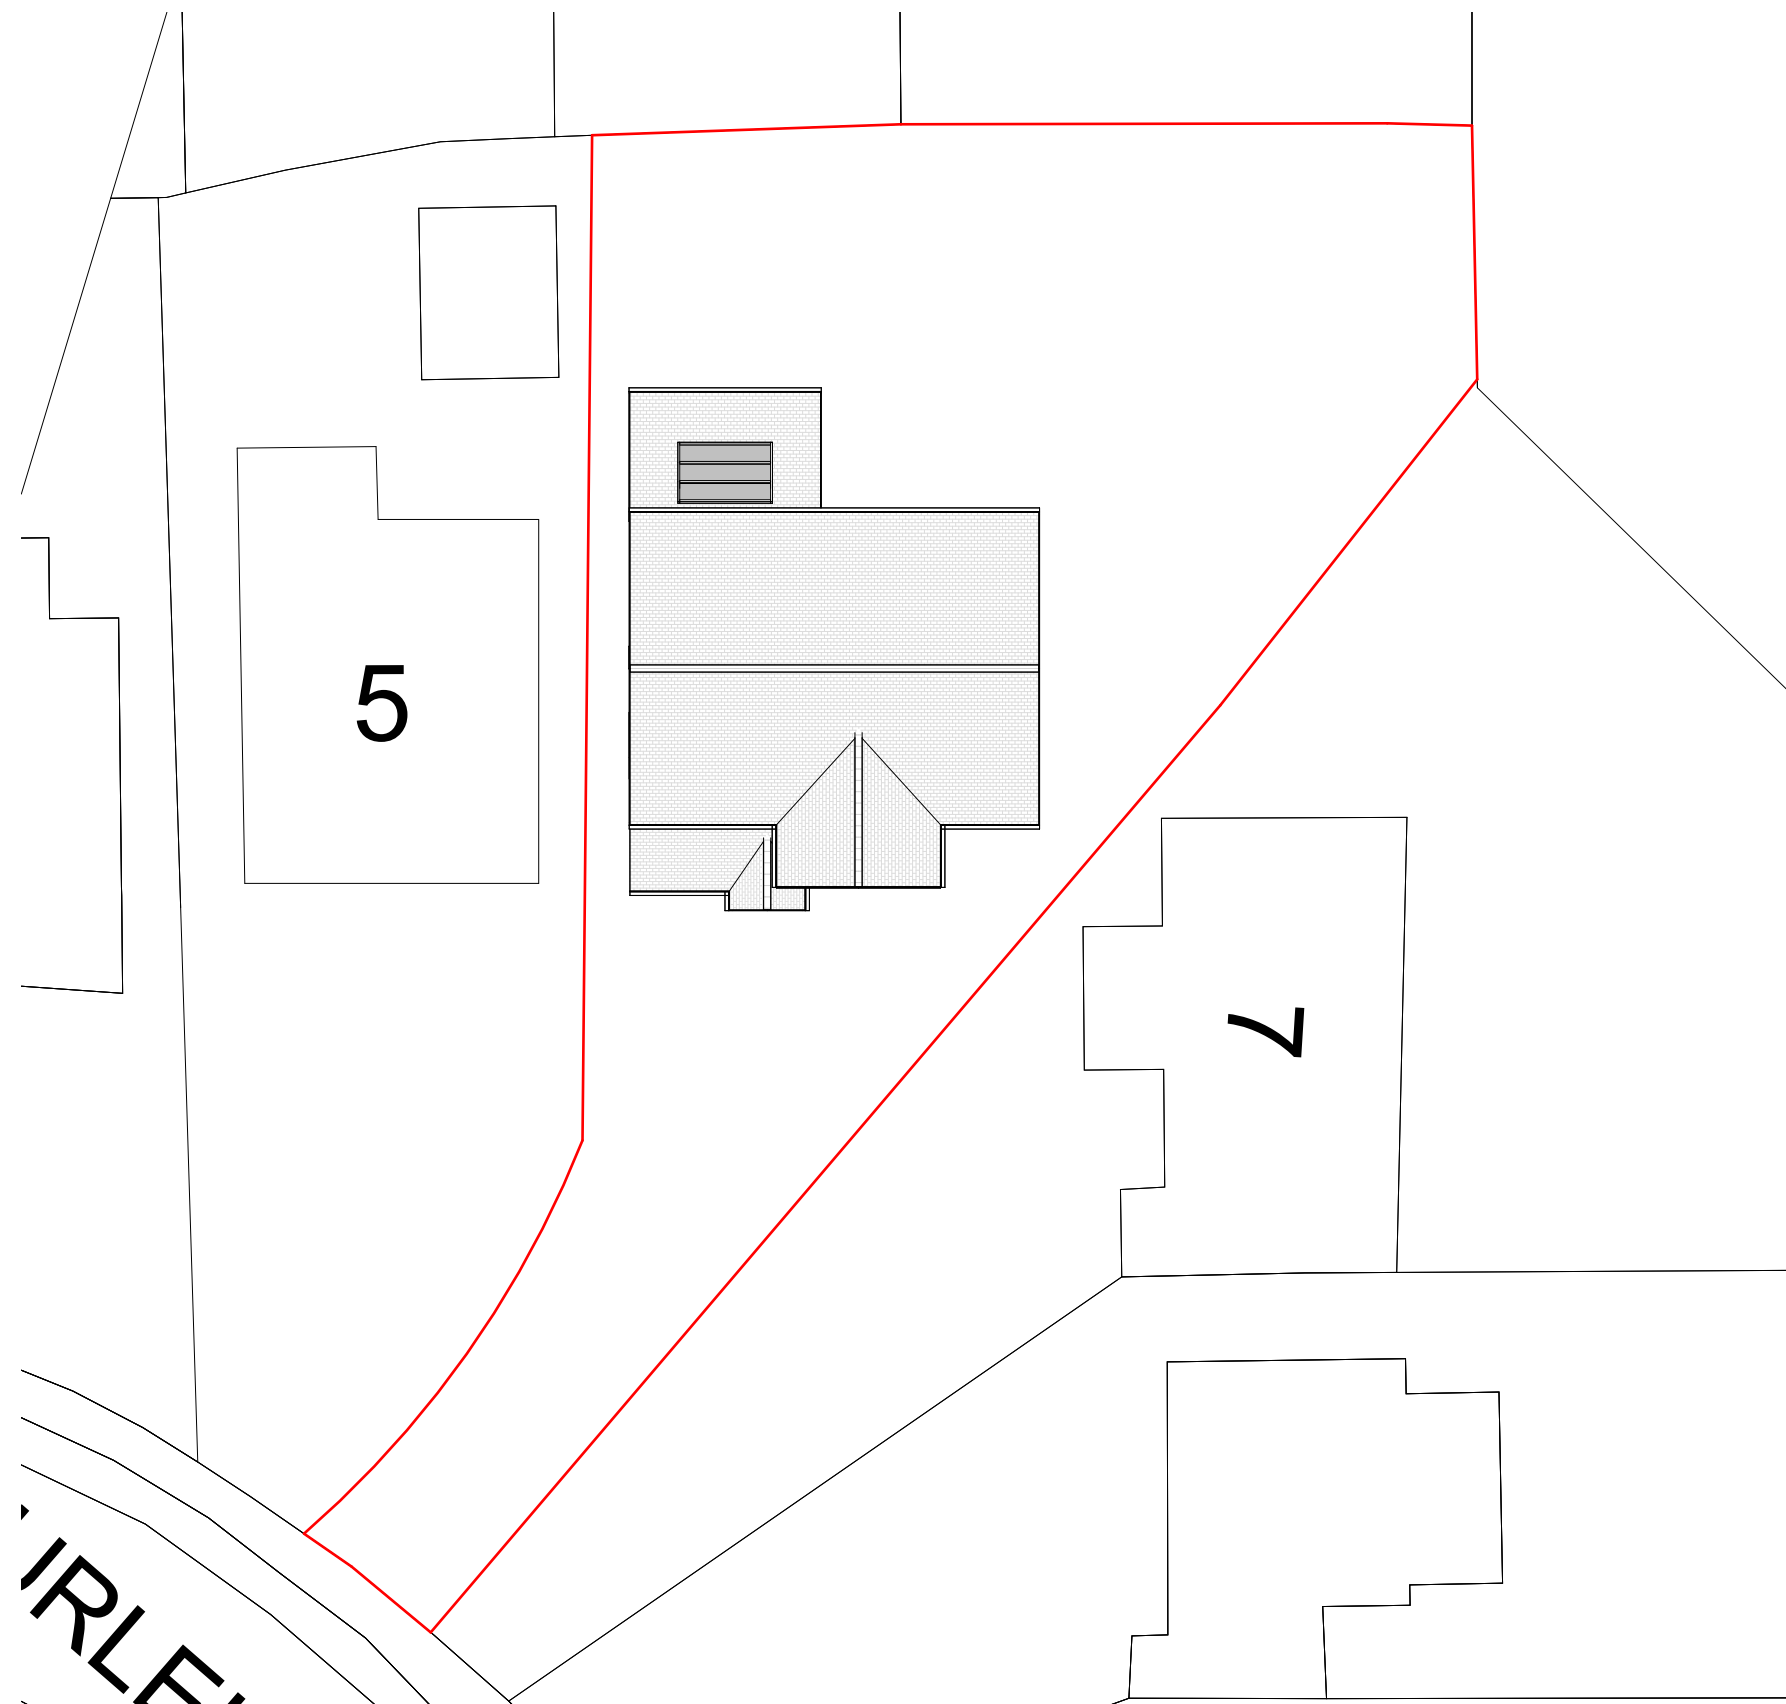


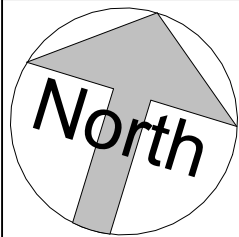

3D View 1

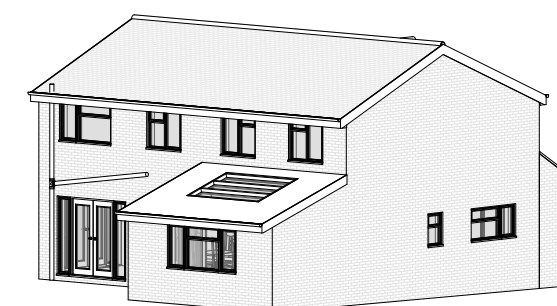

3D View 2

6 Burleigh Close
Crawley Down
Site Plan



FLUENT
ARCHITECTURAL DESIGN SERVICES
TEL: 0800 043 8838
E-MAIL: INFO@FLUENT-ADS.CO.UK
WEB: FLUENT-ADS.CO.UK

6 Burleigh Close Crawley Down

Proposed Site Plan and 3D Views

Scale @ A3
1 : 200

Date
03.12.25

Drawn by
S.G

 
Drawing number
P.M.400

Project number
2473

Rev
D

Key:

Existing Proposed SVP Boundary line
Existing drainage Proposed drainage Overhead



No.	Description	Date
0	First Draft	03.12.25
A	Client's comments (2)	13.01.26
B	Client's comments (3)	16.01.26
C	Drawing amended	03.03.26
D	Drawing amended	11.03.26