


NOTES
Do not scale from this drawing.
Any discrepancies should be reported immediately.
This drawing is copyright. It must not be reproduced or disclosed to third parties without our prior permission.
This drawing is to be read in conjunction with all relevant consultants, specialist manufacturers drawings and specifications.
Any surveyed information incorporated within this drawing cannot be guaranteed as accurate unless confirmed by fixed dimension.
All dimensions are in millimetres unless noted otherwise.



South West Elevation




South East Elevation

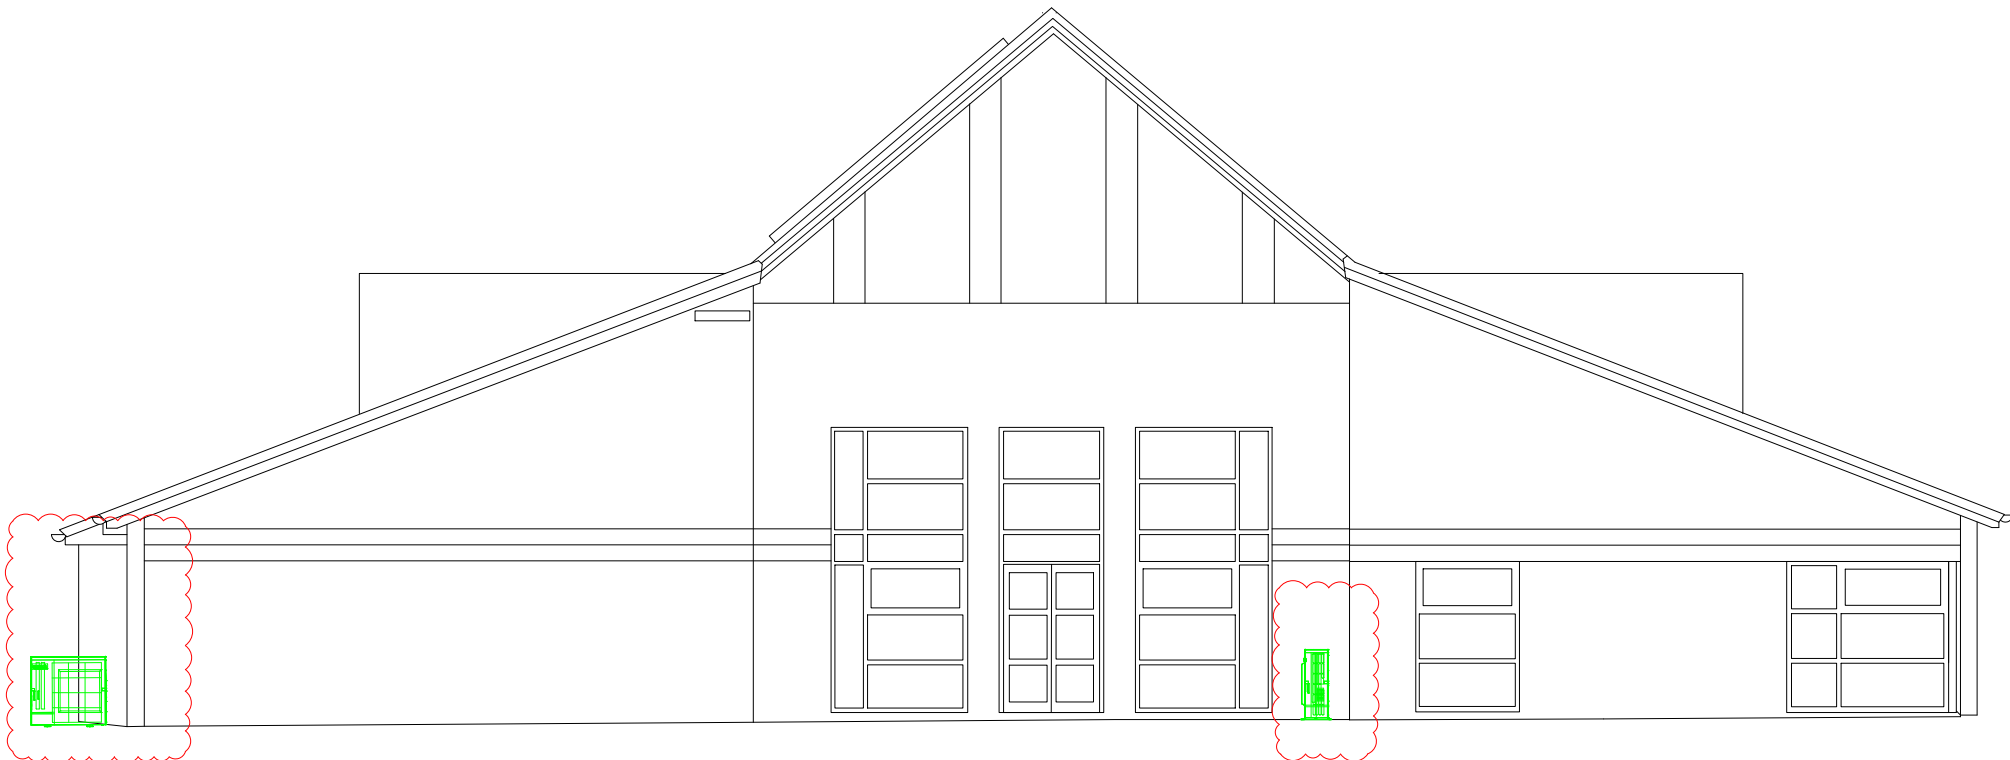

North East Elevation



North West Elevation

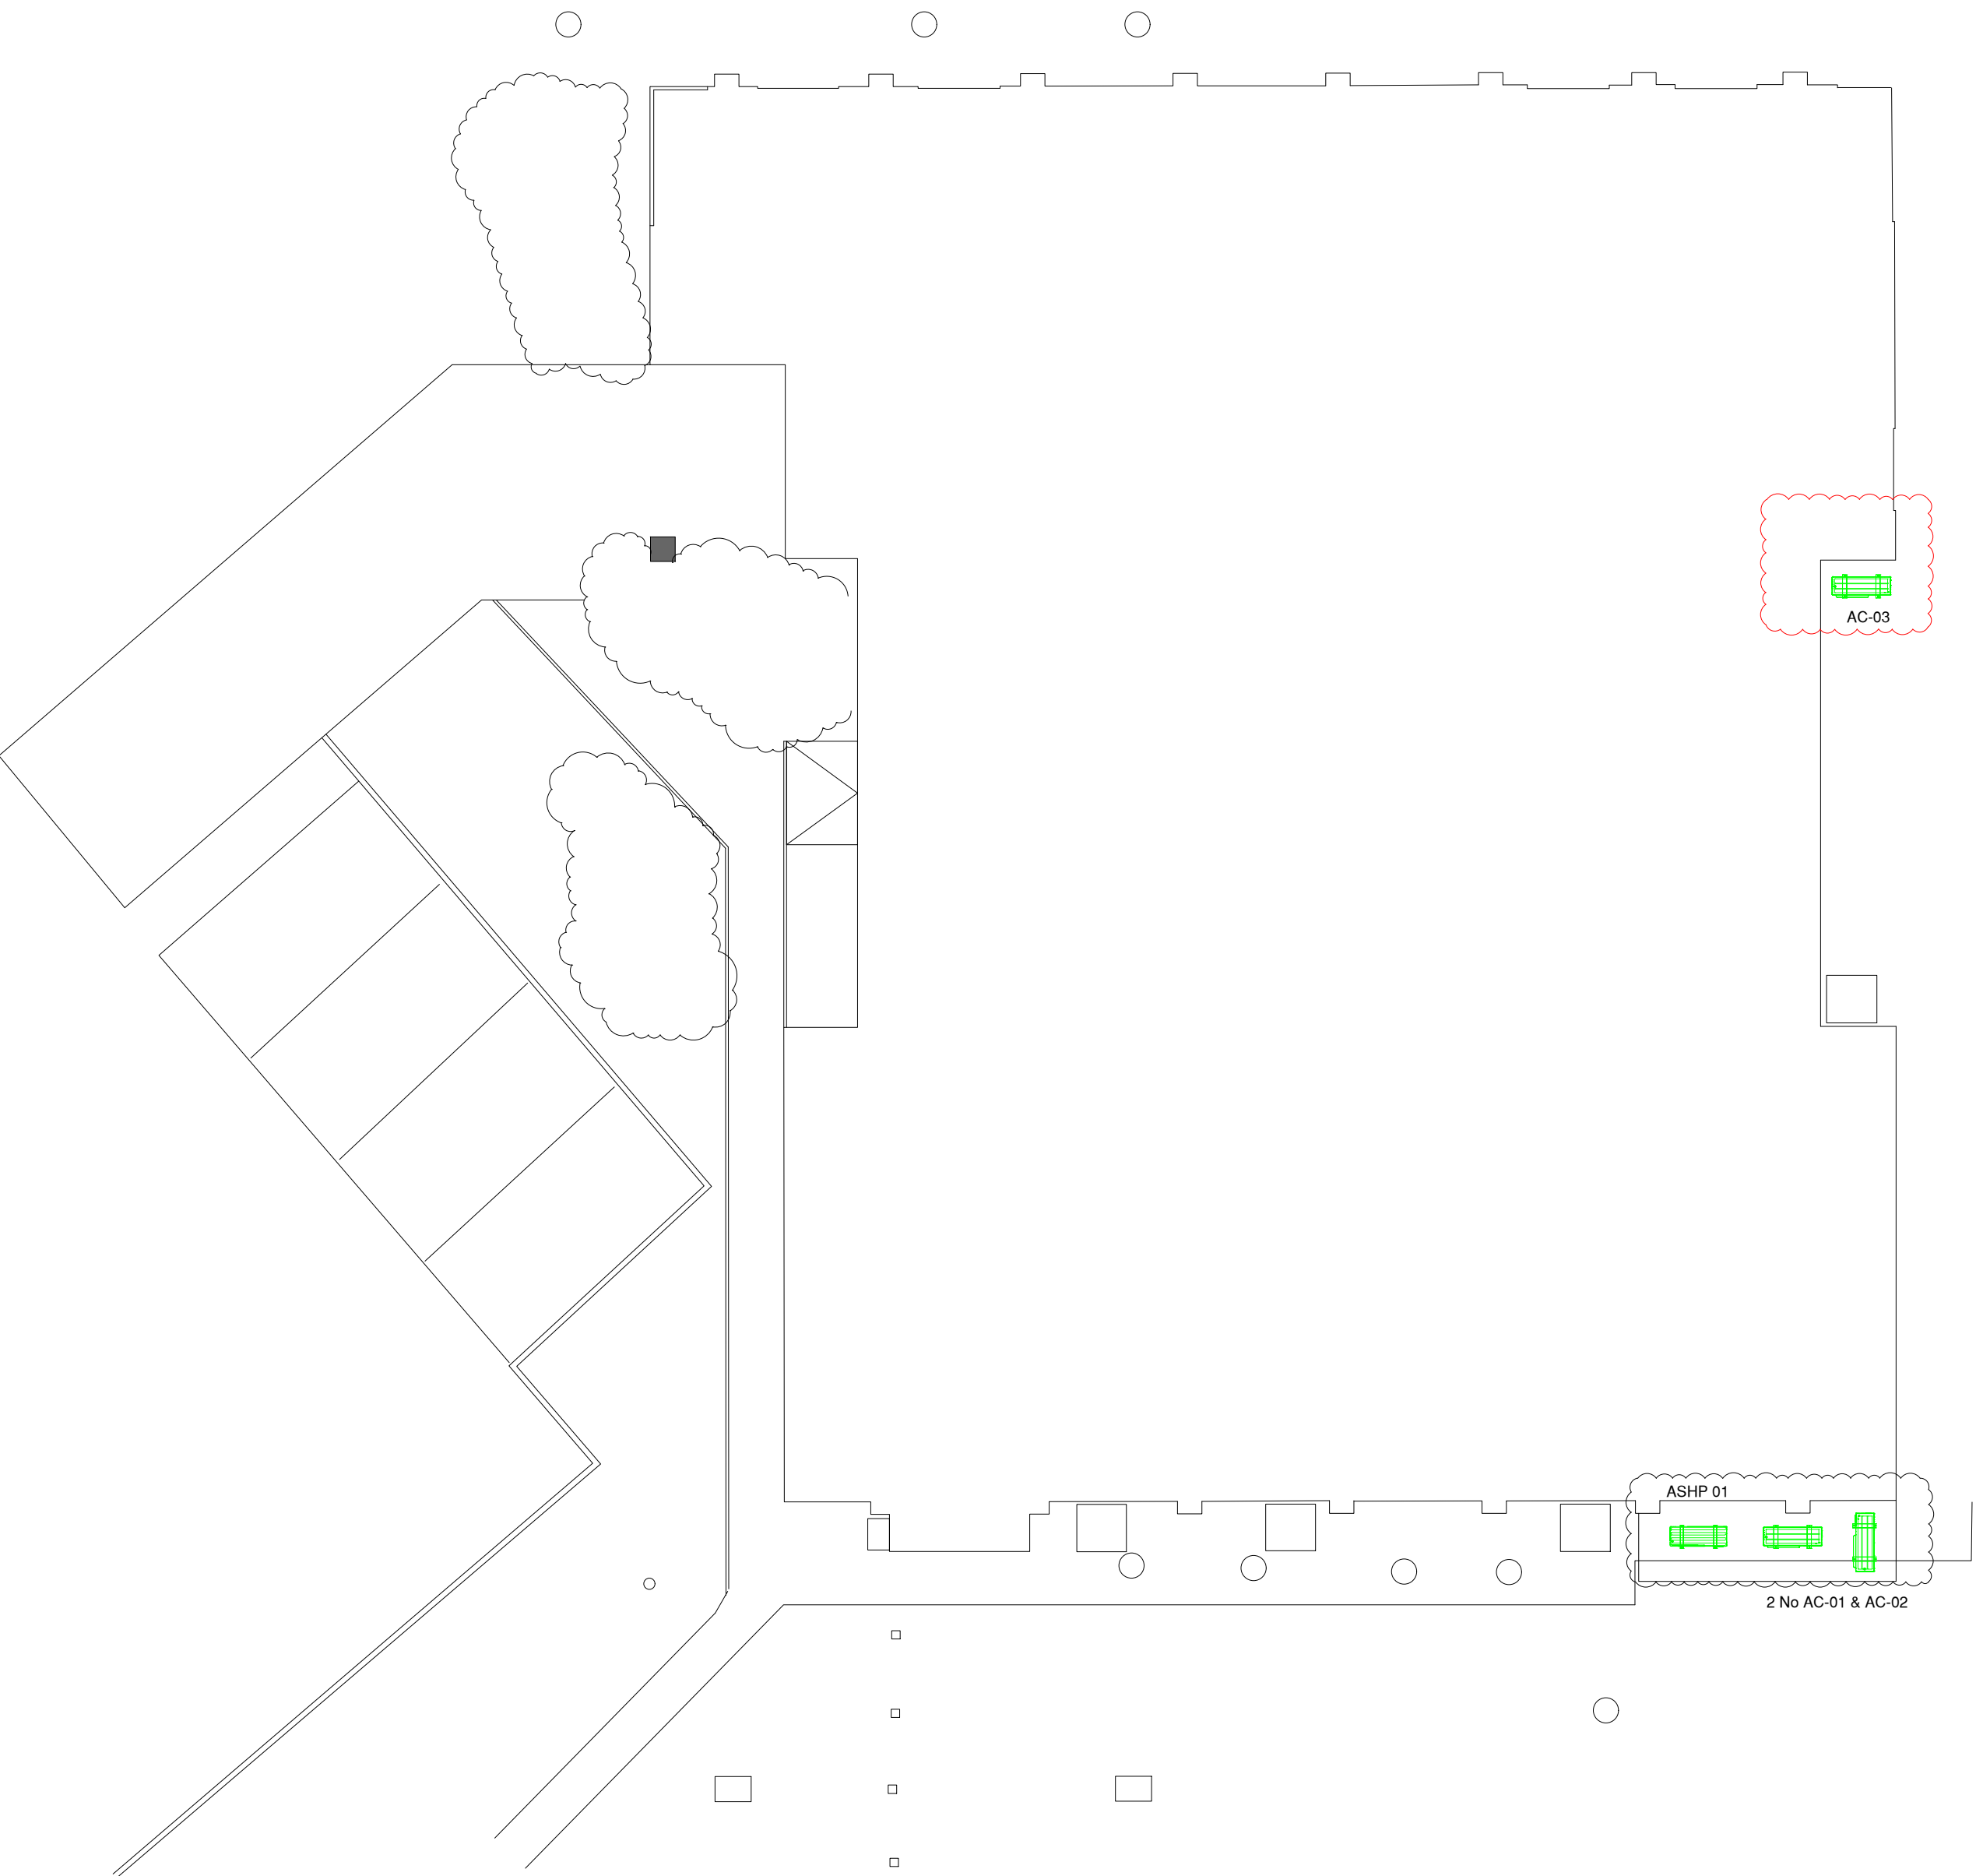

Ground Floor & Site Context Plan

1:100
0 1m 2m 3m 4m 5m 10m

studio@dwellarchitecture.com Tel: 01444 831 800 www.dwellarchitecture.com Fax: 01444 220 499				
Drawing Status				
PLANNING				
Client Trustees of Scaynes Hill Millennium Village Centre				
Project Proposed Air Source Heat Pump Installation Scaynes Hill Millennium Village Centre, Lewes Road				
Title Ground Floor Plan and Elevations as existing				
Dwg. 1409 GA 01 Rev. -				
Job No. 1409	Date 13/06/2025	Scale 1:100 @ A1	Drawn JSR	Checked