




Notes: Do Not Scale
Check all dimensions on site
© Dunthorne Parker Architects

Existing Sewage Drain
Electrical Mast

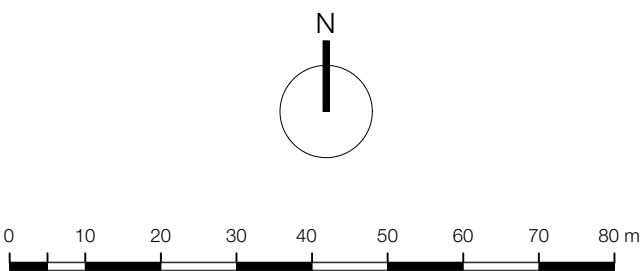

No	Date	By	Chkd	Revision
Project Barn Court, Crawley				
Drawing Existing Site Plan				
Job 1450		Dwg No. 200		
Scale 1:1000		By MK	Date Drawn 31/08/22	



Dunthorne Parker Architects

Call us
Email
Look
Find us

0207 258 0411
contact@dunthorneparker.co.uk
www.dunthorneparkerarchitects.co.uk
Suite 63 | The Hop Exchange |
24 Southwark Street | London | SE1 1TY