


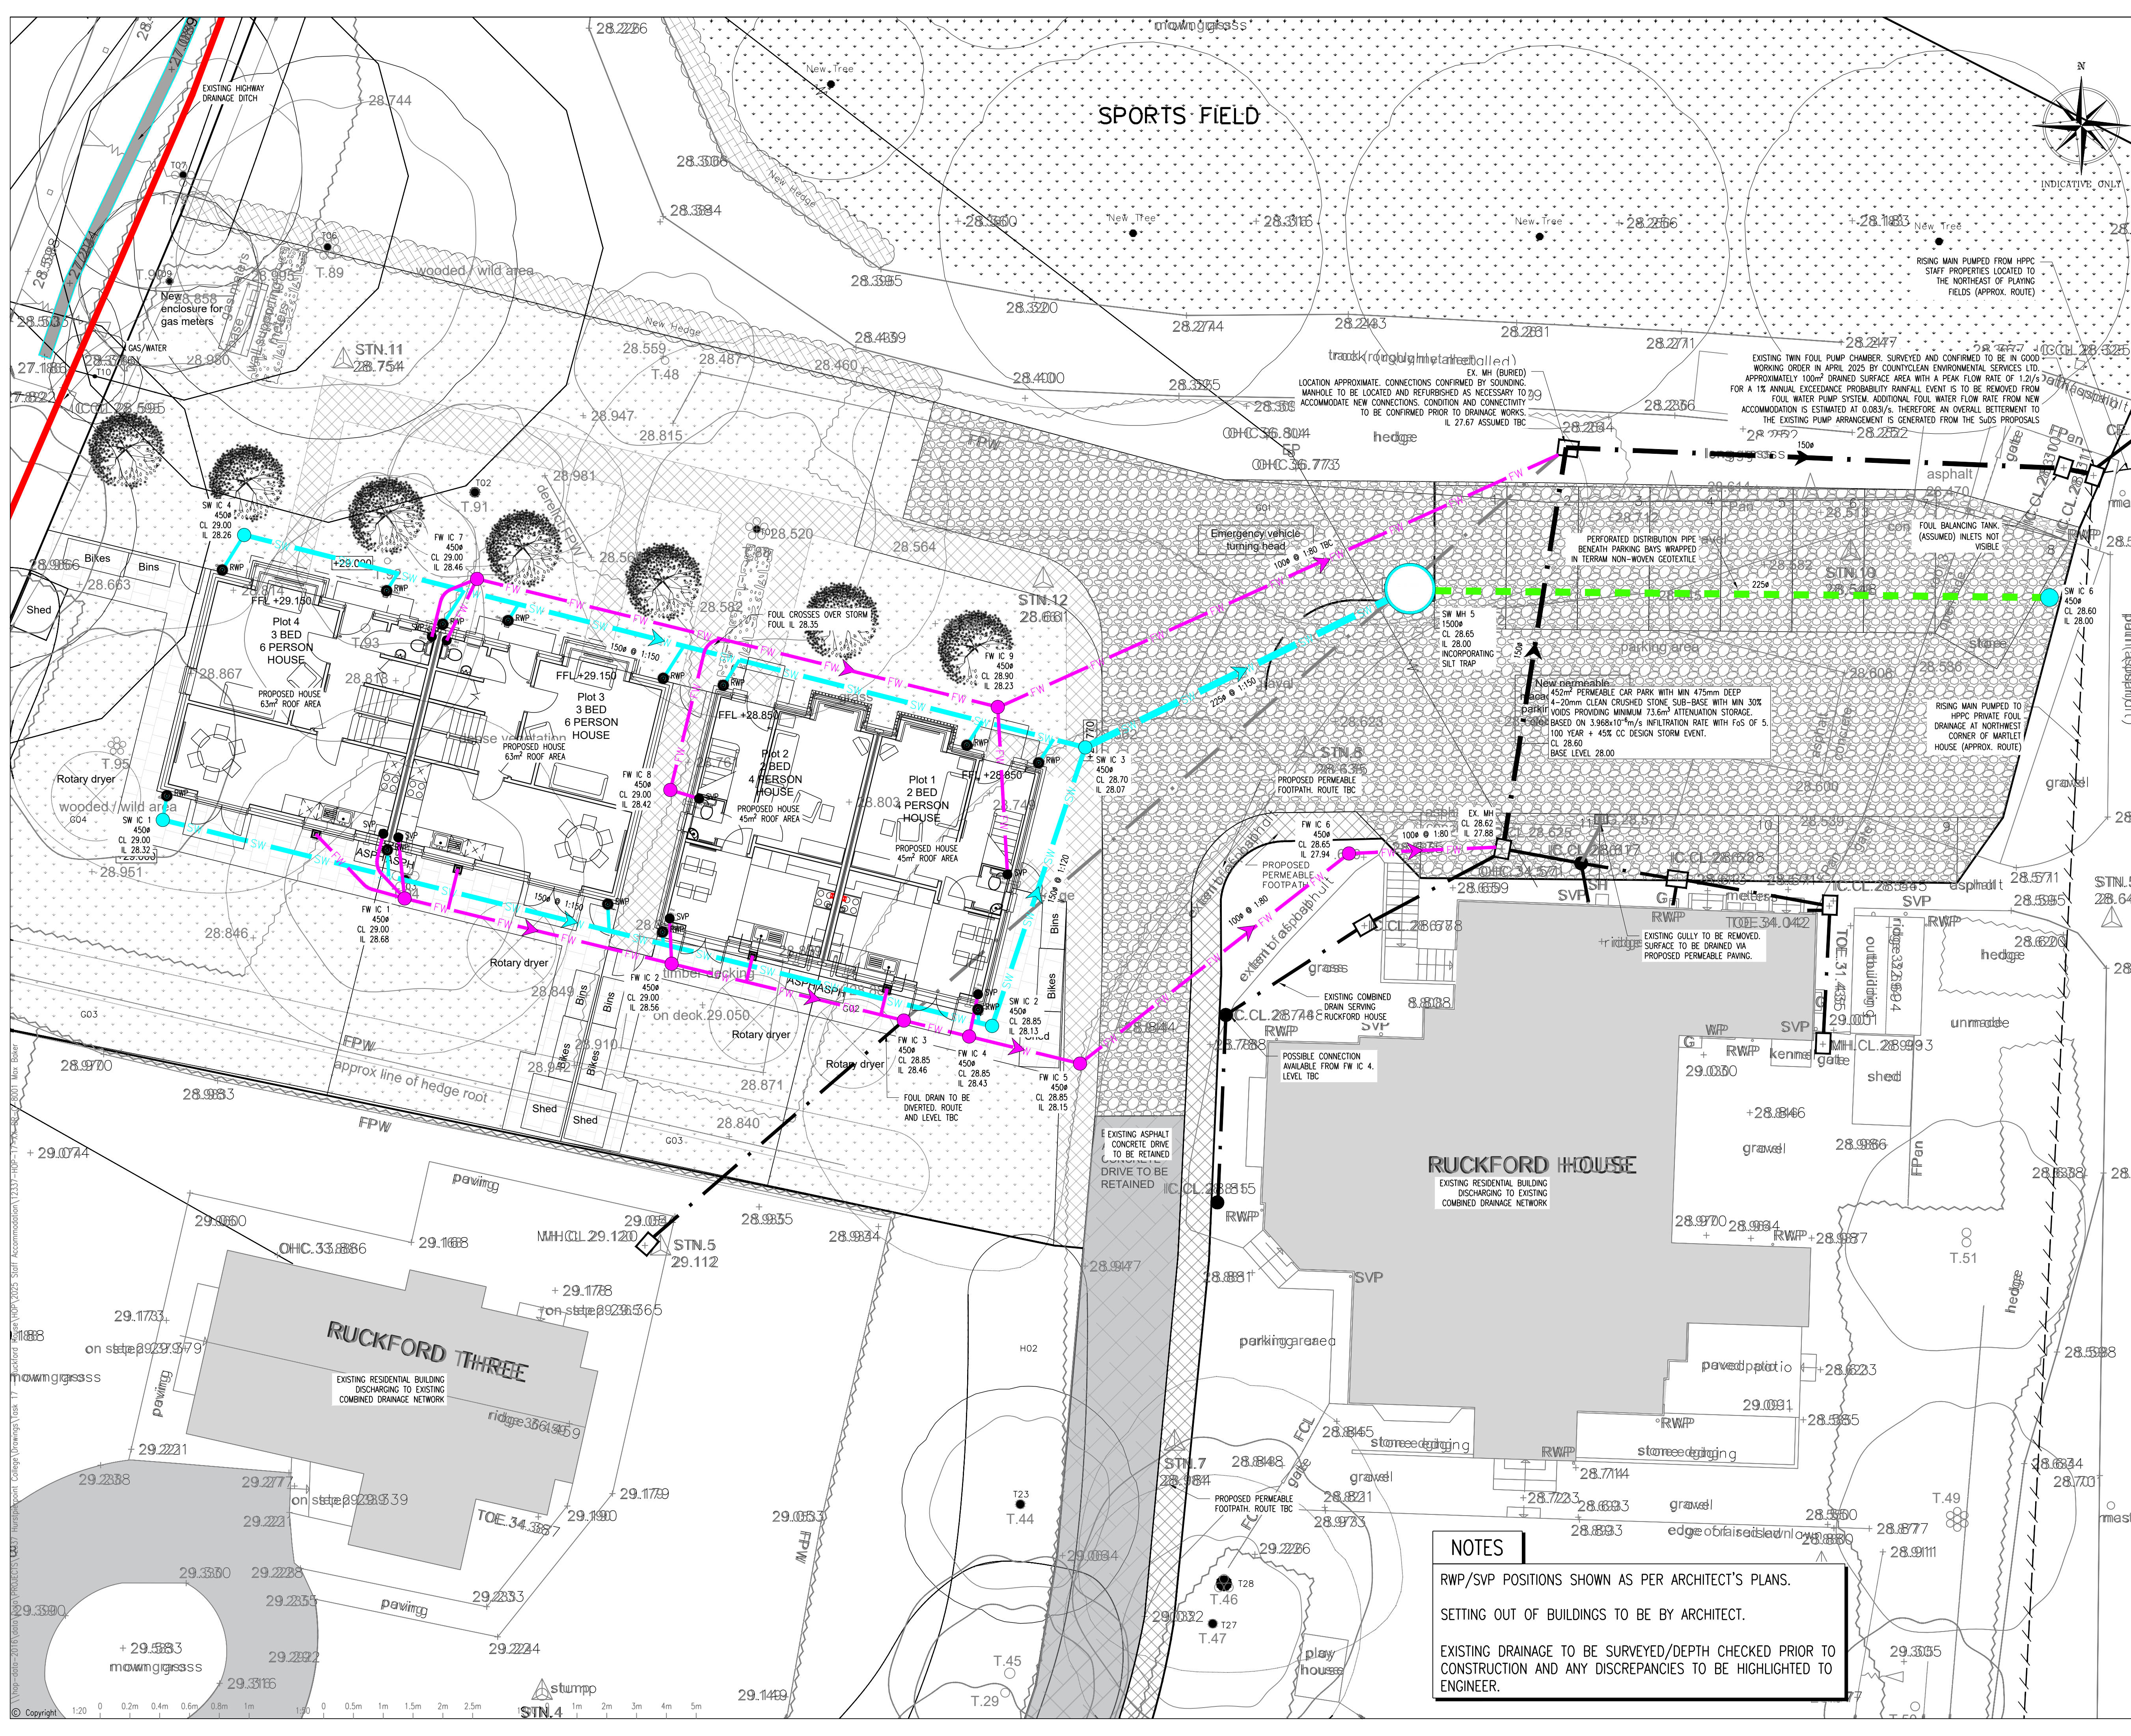

Project/Task No. 12337/17 Scale: 1:200 ORIGINAL DRAWING SIZE A1

1. GENERAL

A. This drawing is not to be scaled, work to figured dimensions only, confirmed on site.

B. This drawing is to be read in conjunction with all relevant architectural drawings, detailed specifications where applicable and all associated drawings in this series.

C. Any discrepancy on this drawing is to be reported immediately to the partnership for clarification.

D. The contractor is responsible for all temporary works and for the stability of the works in progress.

2. BELOW GROUND DRAINAGE

A. All foul and storm water drains which are not to be adopted as public sewers under a Section 104 Agreement must be constructed in accordance with Building Regulations Approved Document H, BS EN 752:2017 and, where appropriate, the relevant agreement certificates.

B. Plastic pipes and fittings shall be of unplasticised polyvinyl chloride (PVC-U) complying with the requirements of BS EN 1401-1:2019 +A1:2023.

C. Concrete pipes shall be spun by a centrifugal process or be vertically pressed. Concrete pipes shall comply with the requirements of, and be tested in accordance with, BS 5911-1:2021 and BS EN 1916:2002.

D. Vitified Clay pipes, fittings, joints, adaptors and couplings shall comply with the requirements of BS EN 295-1:2013 and BS EN 295-4:2013.

E. All private foul water drains are to be laid at minimum gradient of 1 in 40 at the head of pipe and minimum 1 in 80 elsewhere, unless otherwise stated on the drawing. Use chamber main channel invert levels to set gradient. Incoming branch invert level is typically 50mm above main channel.

F. All private foul water drains are 100mm diameter, unless otherwise stated on the drawing.

G. All private surface water drains are to be laid at minimum gradient of 1 in 80 unless otherwise stated on the drawing. Use chamber main channel invert levels to set gradient. Incoming branch invert level is typically 50mm above main channel.

H. All private surface water drains are 100mm diameter from downpipes and 150mm diameter elsewhere, unless otherwise stated on the drawing.

I. Allow for rodding access above ground where rainwater downpipes do not have a direct connection to an inspection chamber.

J. Plastic Inspection Chambers shall comply with the requirements of BS EN 13598-1:2002.

K. Precast concrete manhole units shall comply with the requirements of BS 5911-3:2022 and BS EN 1917:2002. Manhole cover slabs situated under carriageways shall be heavy duty and those situated elsewhere shall be light duty. The relevant absorption tests required shall be carried out on a sample of those rings and slabs used unless a certificate of testing is supplied by the manufacturer.

L. Manhole covers and frames are to be a minimum of: Class B125 in non-traffic areas, footways and verges. Class D400 in trafficked areas and highways. Class E600 and F900 manhole covers to be used for heavy duty applications such as docks, airports and industrial areas.

M. Manhole covers and frames to be bedded and hounded externally in mortar.

N. All concrete used in drainage works is to comply with BRE Special Digest 1 (S01:2005 - 3rd Edition) for Class 2 sulphate conditions.

O. Any existing drain or sewer being re-used is to be surveyed and levelled prior to commencement of the drainage works, and refurbished if necessary.

P. Connections to an adopted sewer are only to be made after receiving approval, from the relevant Sewerage Undertaker, of a sewer connection application (Section 106 - Water Industry Act 1991).

Q. All drains, sewers and manholes are to be cleaned and tested for water tightness on completion of construction.

**LEGEND**

- PROPOSED SURFACE WATER DRAIN
- PROPOSED FOUL WATER DRAIN
- PROPOSED PERFORATED PIPE
- EXISTING RISING MAIN
- EXISTING SURFACE WATER DRAIN
- EXISTING SURFACE WATER DRAIN TO BE ABANDONED
- EXISTING FOUL/COMBINED WATER DRAIN
- EXISTING FOUL/COMBINED WATER DRAIN TO BE ABANDONED
- PROPOSED CONCRETE MANHOLE
- PROPOSED PLASTIC INSPECTION CHAMBER (PPIC)
- HIGHWAY GULLY
- YARD/BINSTORE GULLY
- SOIL AND VENT PIPE
- RAIN WATER PIPE
- PROPOSED PERMEABLE PAVING
- SITE BOUNDARY

1:100

0 1m 2m 3m 4m 5m

|                                 |        |          |    |
|---------------------------------|--------|----------|----|
| ISSUED FOR BUILDING REGULATIONS | MB AK  | 23.12.25 | P2 |
| FIRST ISSUE                     | TRB AK | 21.07.25 | P1 |

Description By Apprd. Date Rev.

**PRELIMINARY DRAWING**  
NOT FOR CONSTRUCTION

Title **DRAINAGE LAYOUT**

Project **NEW STAFF ACCOMMODATION**

Client **HURSTPIERPOINT COLLEGE**

**HOP**  
CONSULTING CIVIL AND STRUCTURAL ENGINEERS  
HOP House, 41 Church Road  
Hove, East Sussex BN3 2BE  
www.hop.uk.com  
ask@hop.uk.com  
+44 (0)1273 223900

Drawing No. 12337-HOP-17-XX-DR-C-8011 Station S2  
Rev. P2

**NOTES**

 













RWP/SVP POSITIONS SHOWN AS PER ARCHITECT'S PLANS.

SETTING OUT OF BUILDINGS TO BE BY ARCHITECT.

EXISTING DRAINAGE TO BE SURVEYED/DEPTH CHECKED PRIOR TO CONSTRUCTION AND ANY DISCREPANCIES TO BE HIGHLIGHTED TO ENGINEER.

\\hop-880-2018\proj\010\proj\010\PROJECT\12337\_Hurstpierpoint\_College\Drawings\17 - Roadwork House\HOP\2025 Staff Accommodation\12337-HOP-17-XX-DR-C-8201.dwg 4/1/2025 12:25:25

1. GENERAL
- (i) This drawing is not to be scaled, work to figured dimensions only, confirmed on site.
- (ii) This drawing is to be read in conjunction with all relevant architectural drawings, detailed specifications where applicable and all associated drawings in this series.
- (iii) Any discrepancy on this drawing is to be reported immediately to the partnership for clarification.
- (iv) The contractor is responsible for all temporary works and for the stability of the works in progress.

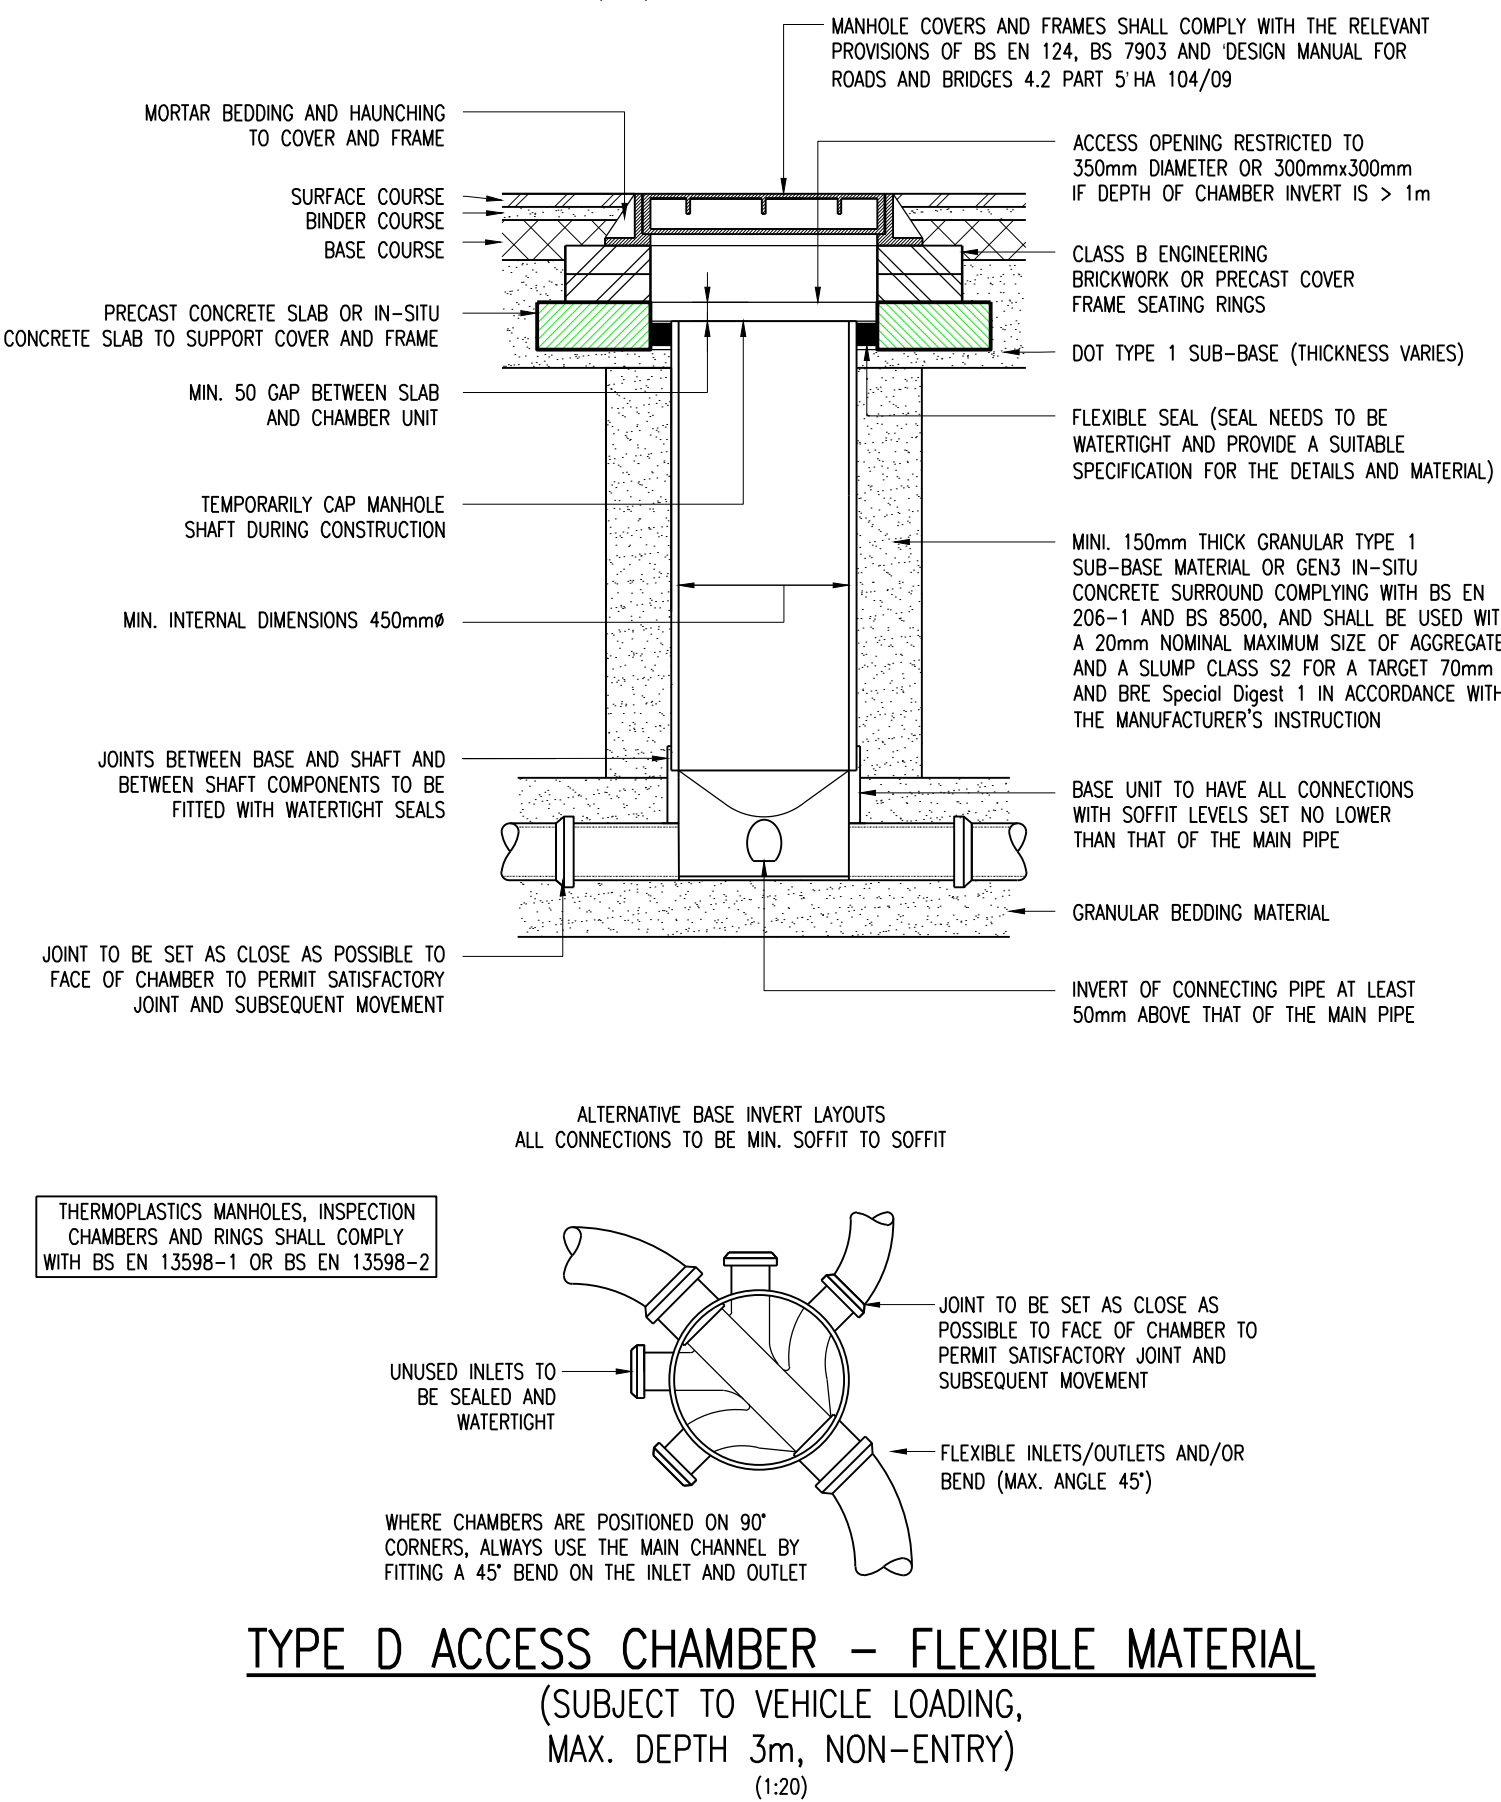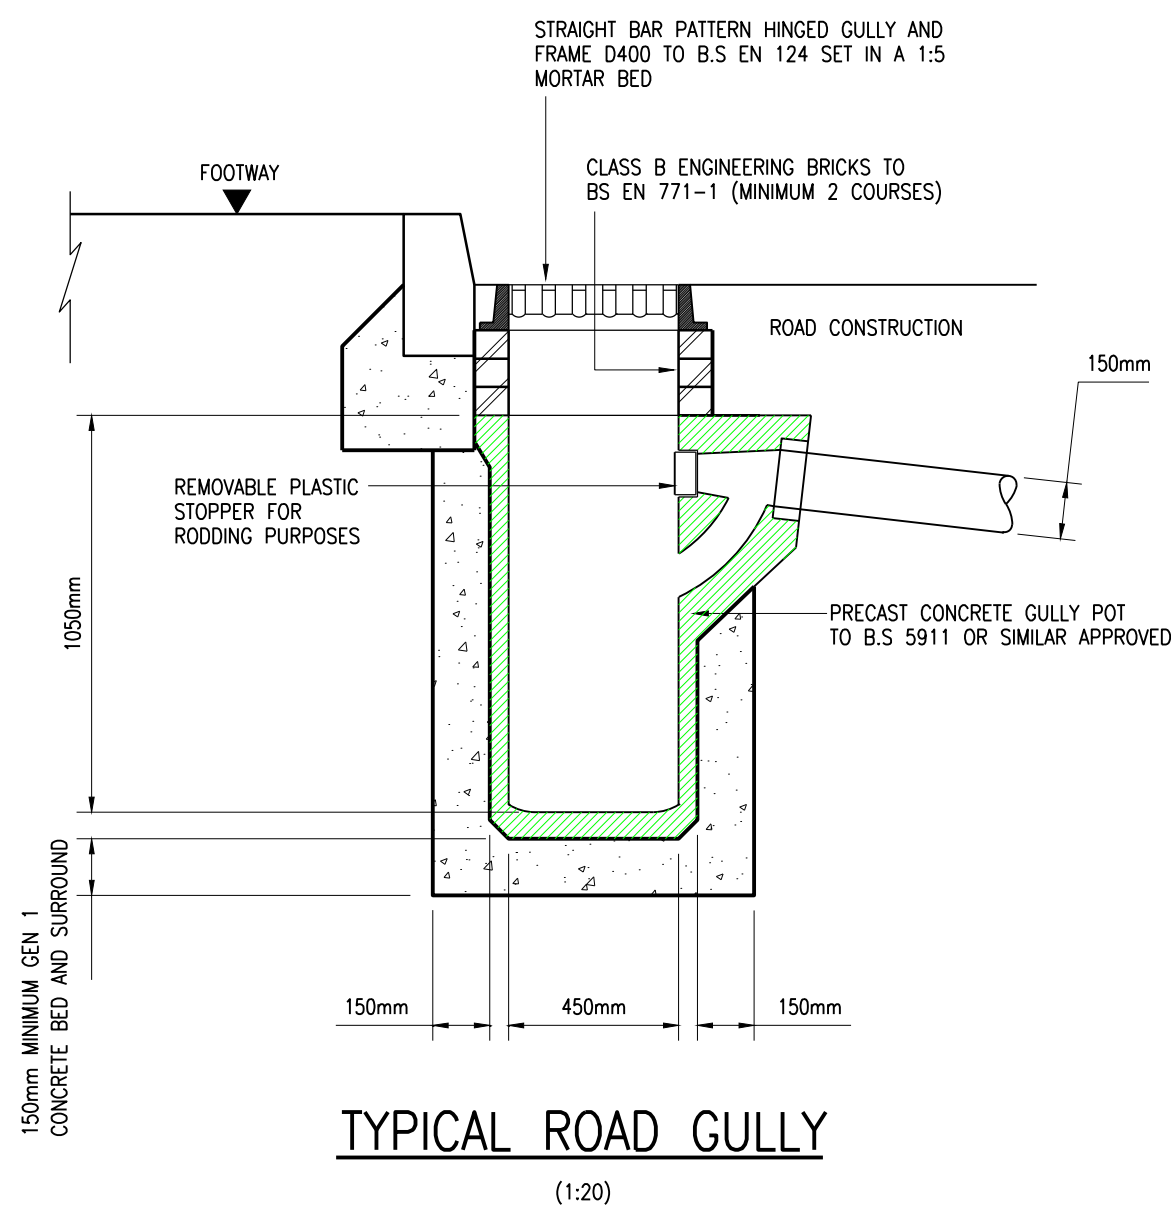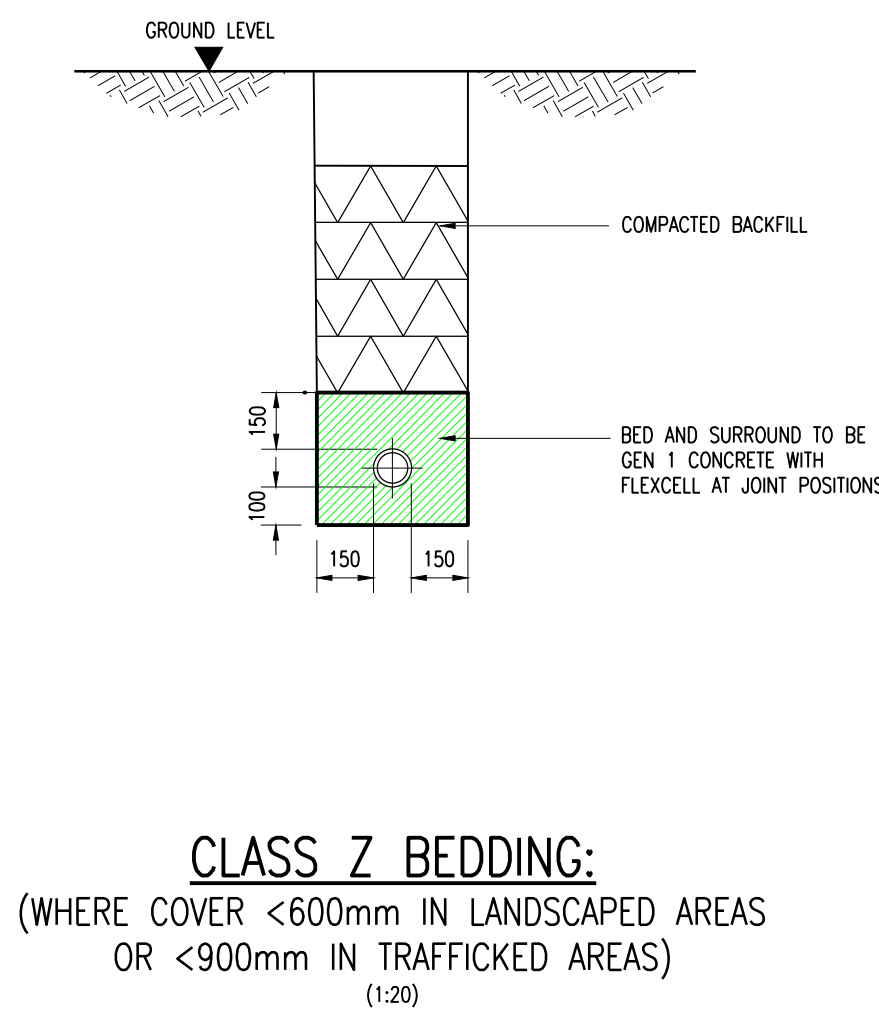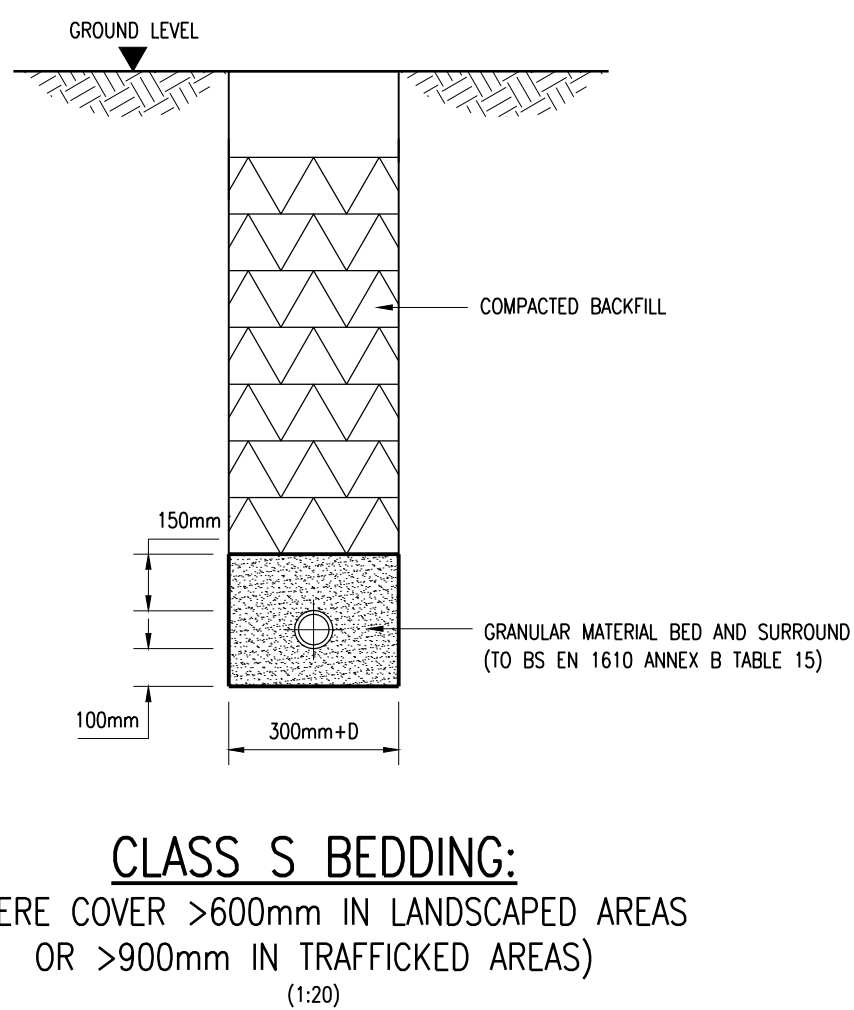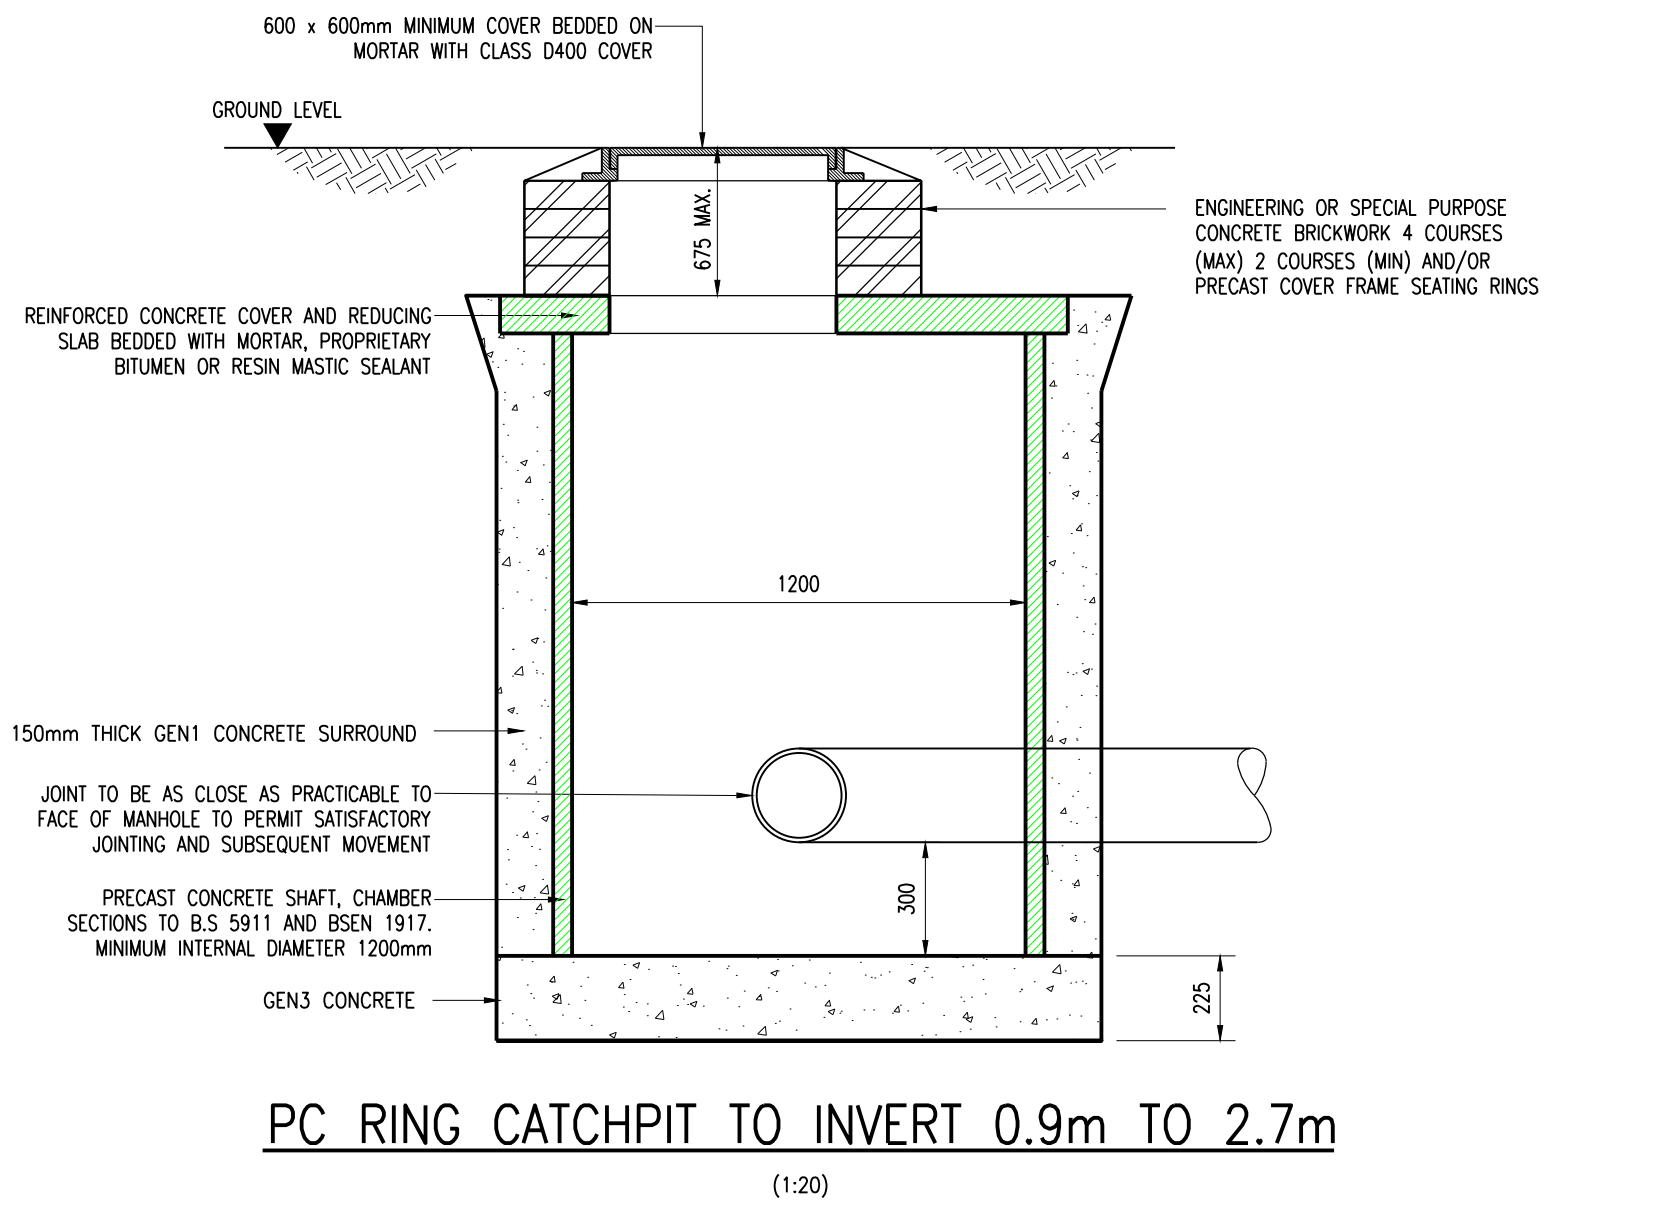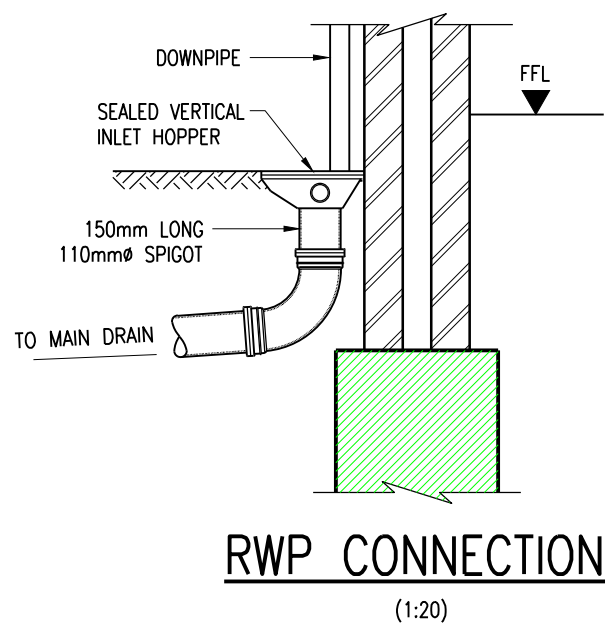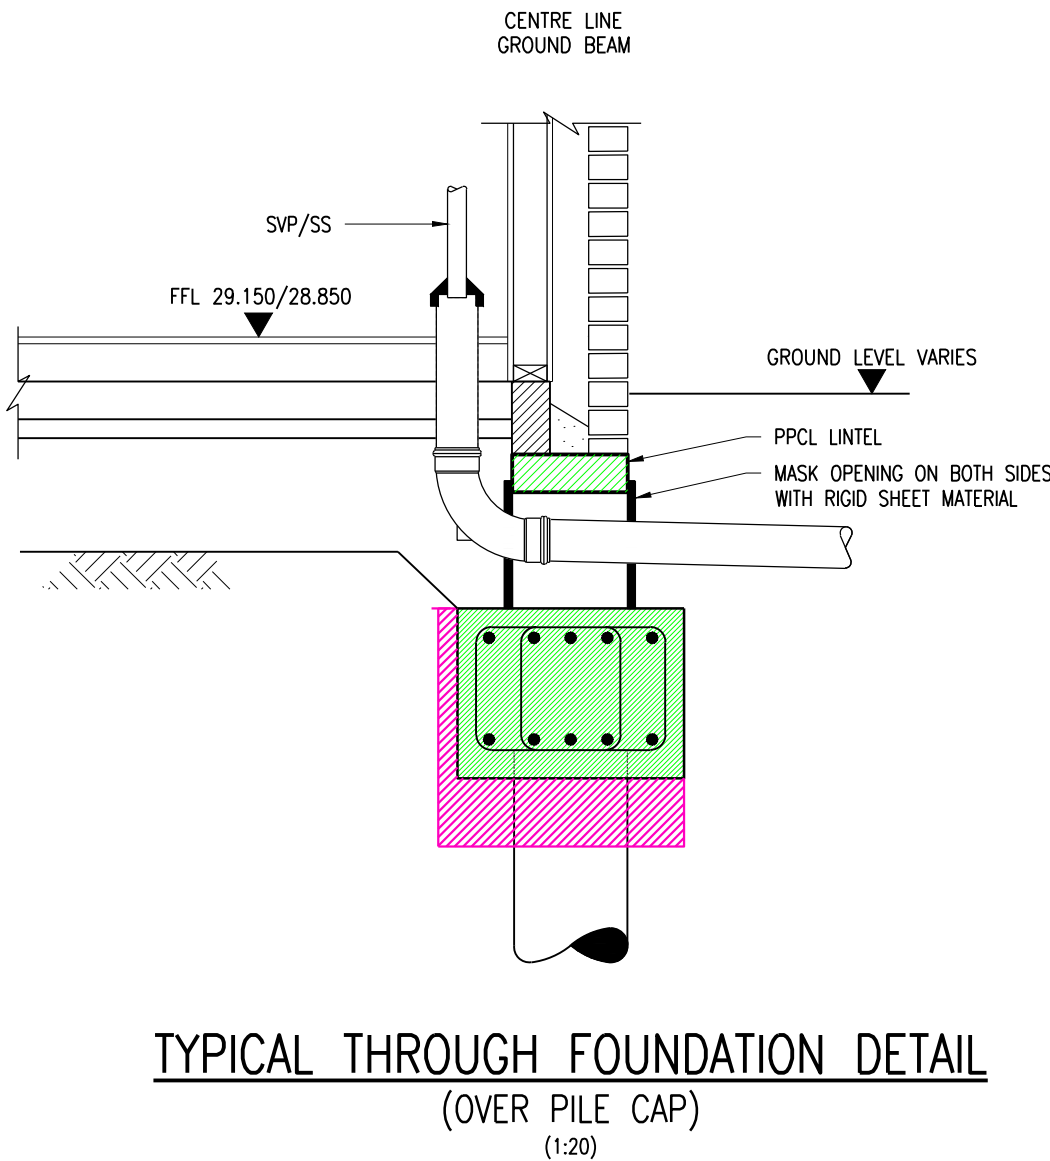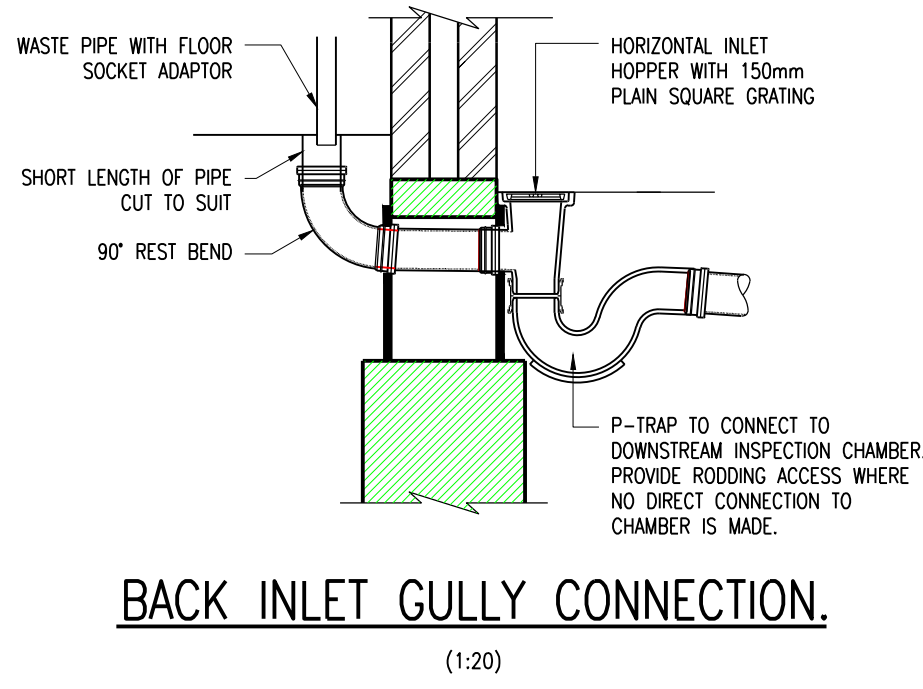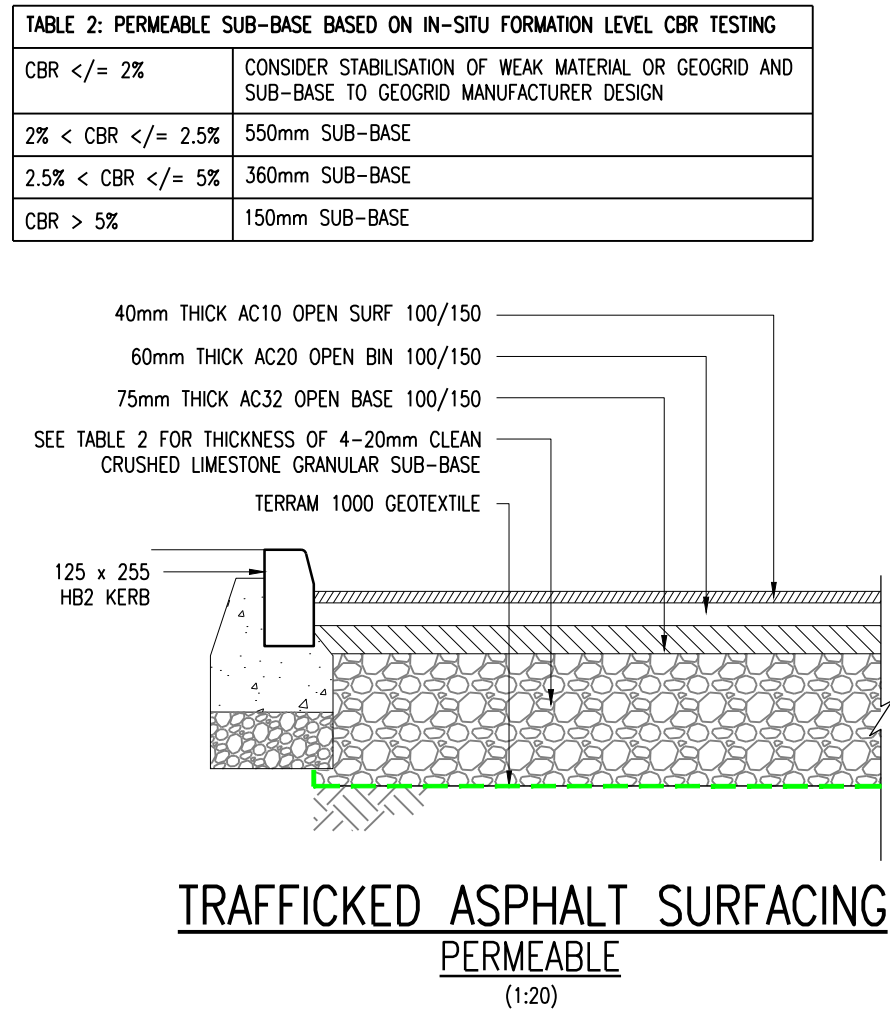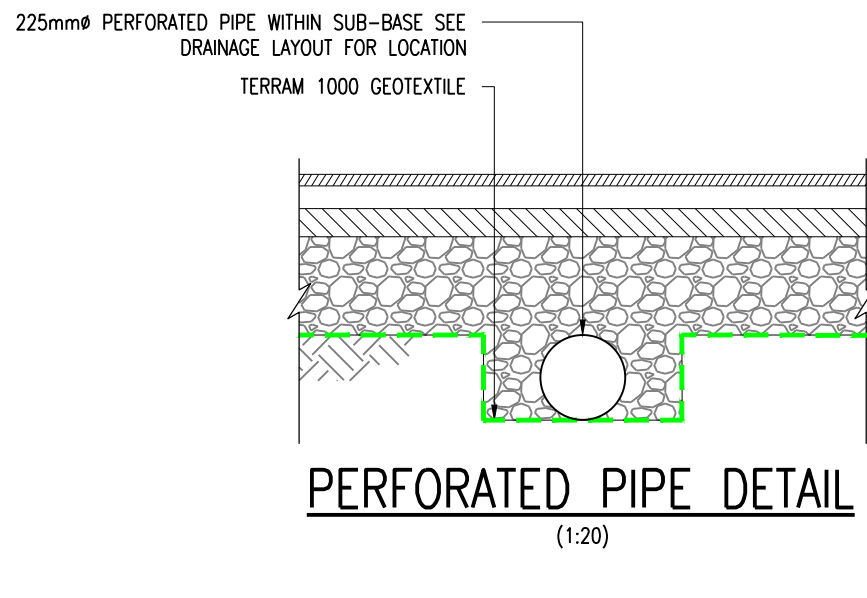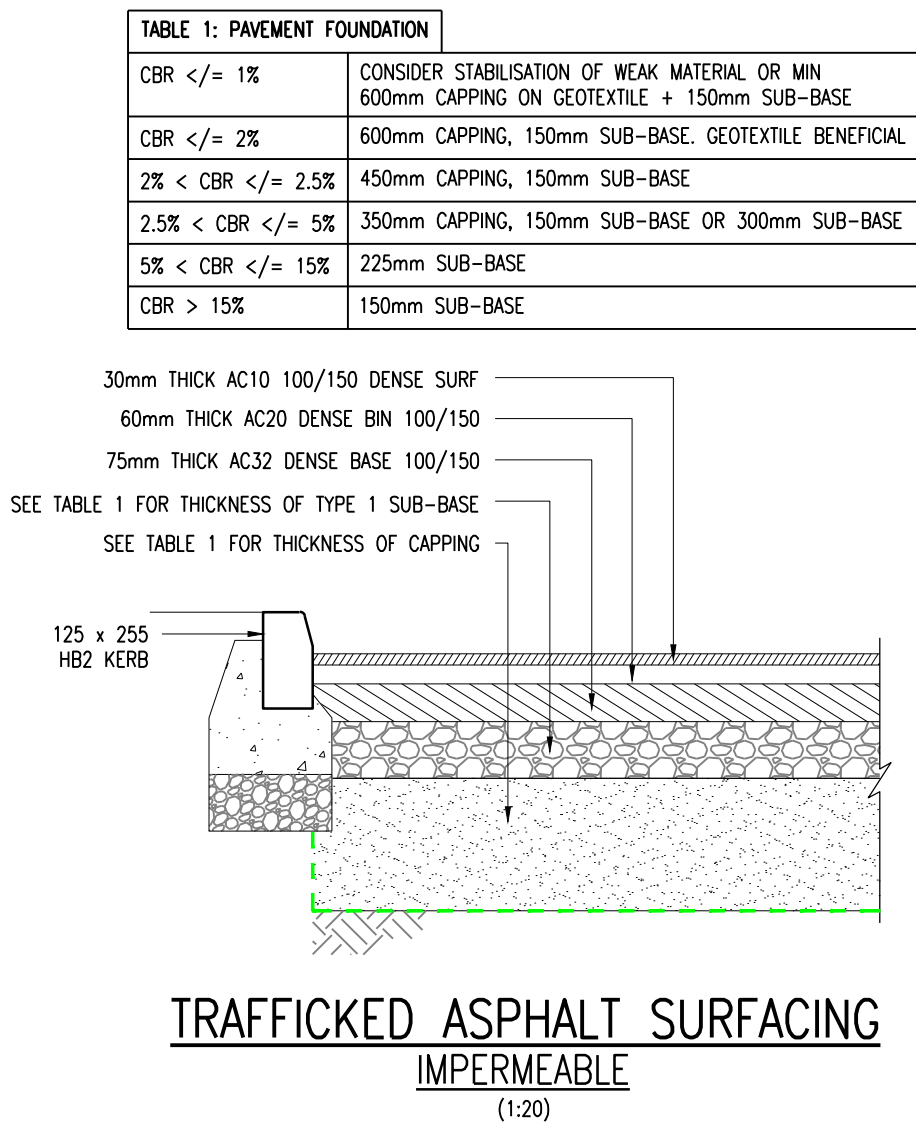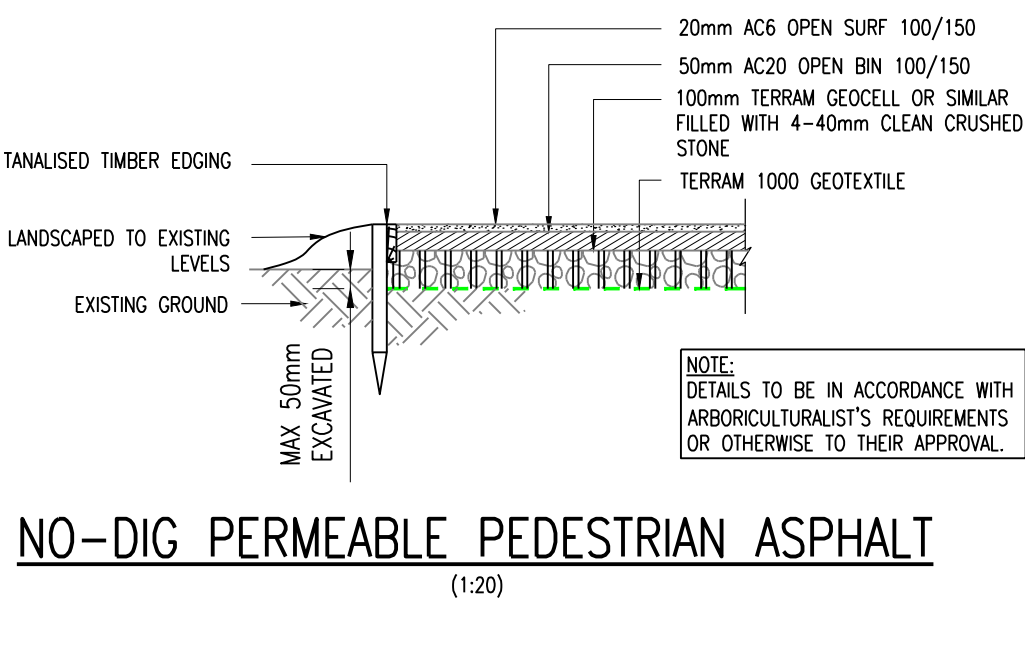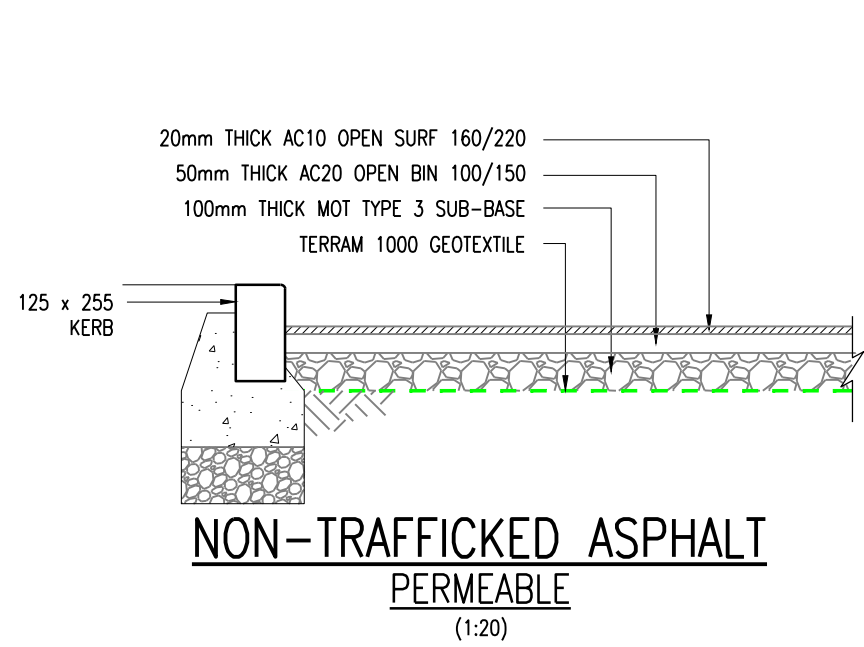

|                                 |     |        |          |      |
|---------------------------------|-----|--------|----------|------|
| ISSUED FOR BUILDING REGULATIONS | IAS | MB     | 23.12.25 | P1   |
| Description                     | By  | Agreed | Date     | Rev. |
| PRELIMINARY DRAWING             |     |        |          |      |
| NOT FOR CONSTRUCTION            |     |        |          |      |
| Title                           |     |        |          |      |
| DRAINAGE AND HIGHWAY DETAILS    |     |        |          |      |
| Project                         |     |        |          |      |
| NEW STAFF ACCOMMODATION         |     |        |          |      |
| Client                          |     |        |          |      |
| HURSTPIERPPOINT COLLEGE         |     |        |          |      |
| Drawing No.                     |     |        |          |      |
| 12337-HOP-17-XX-DR-C-8201       |     |        |          |      |
| Status                          |     |        |          |      |
| S2                              |     |        |          |      |
| Rev.                            |     |        |          |      |
| P1                              |     |        |          |      |