


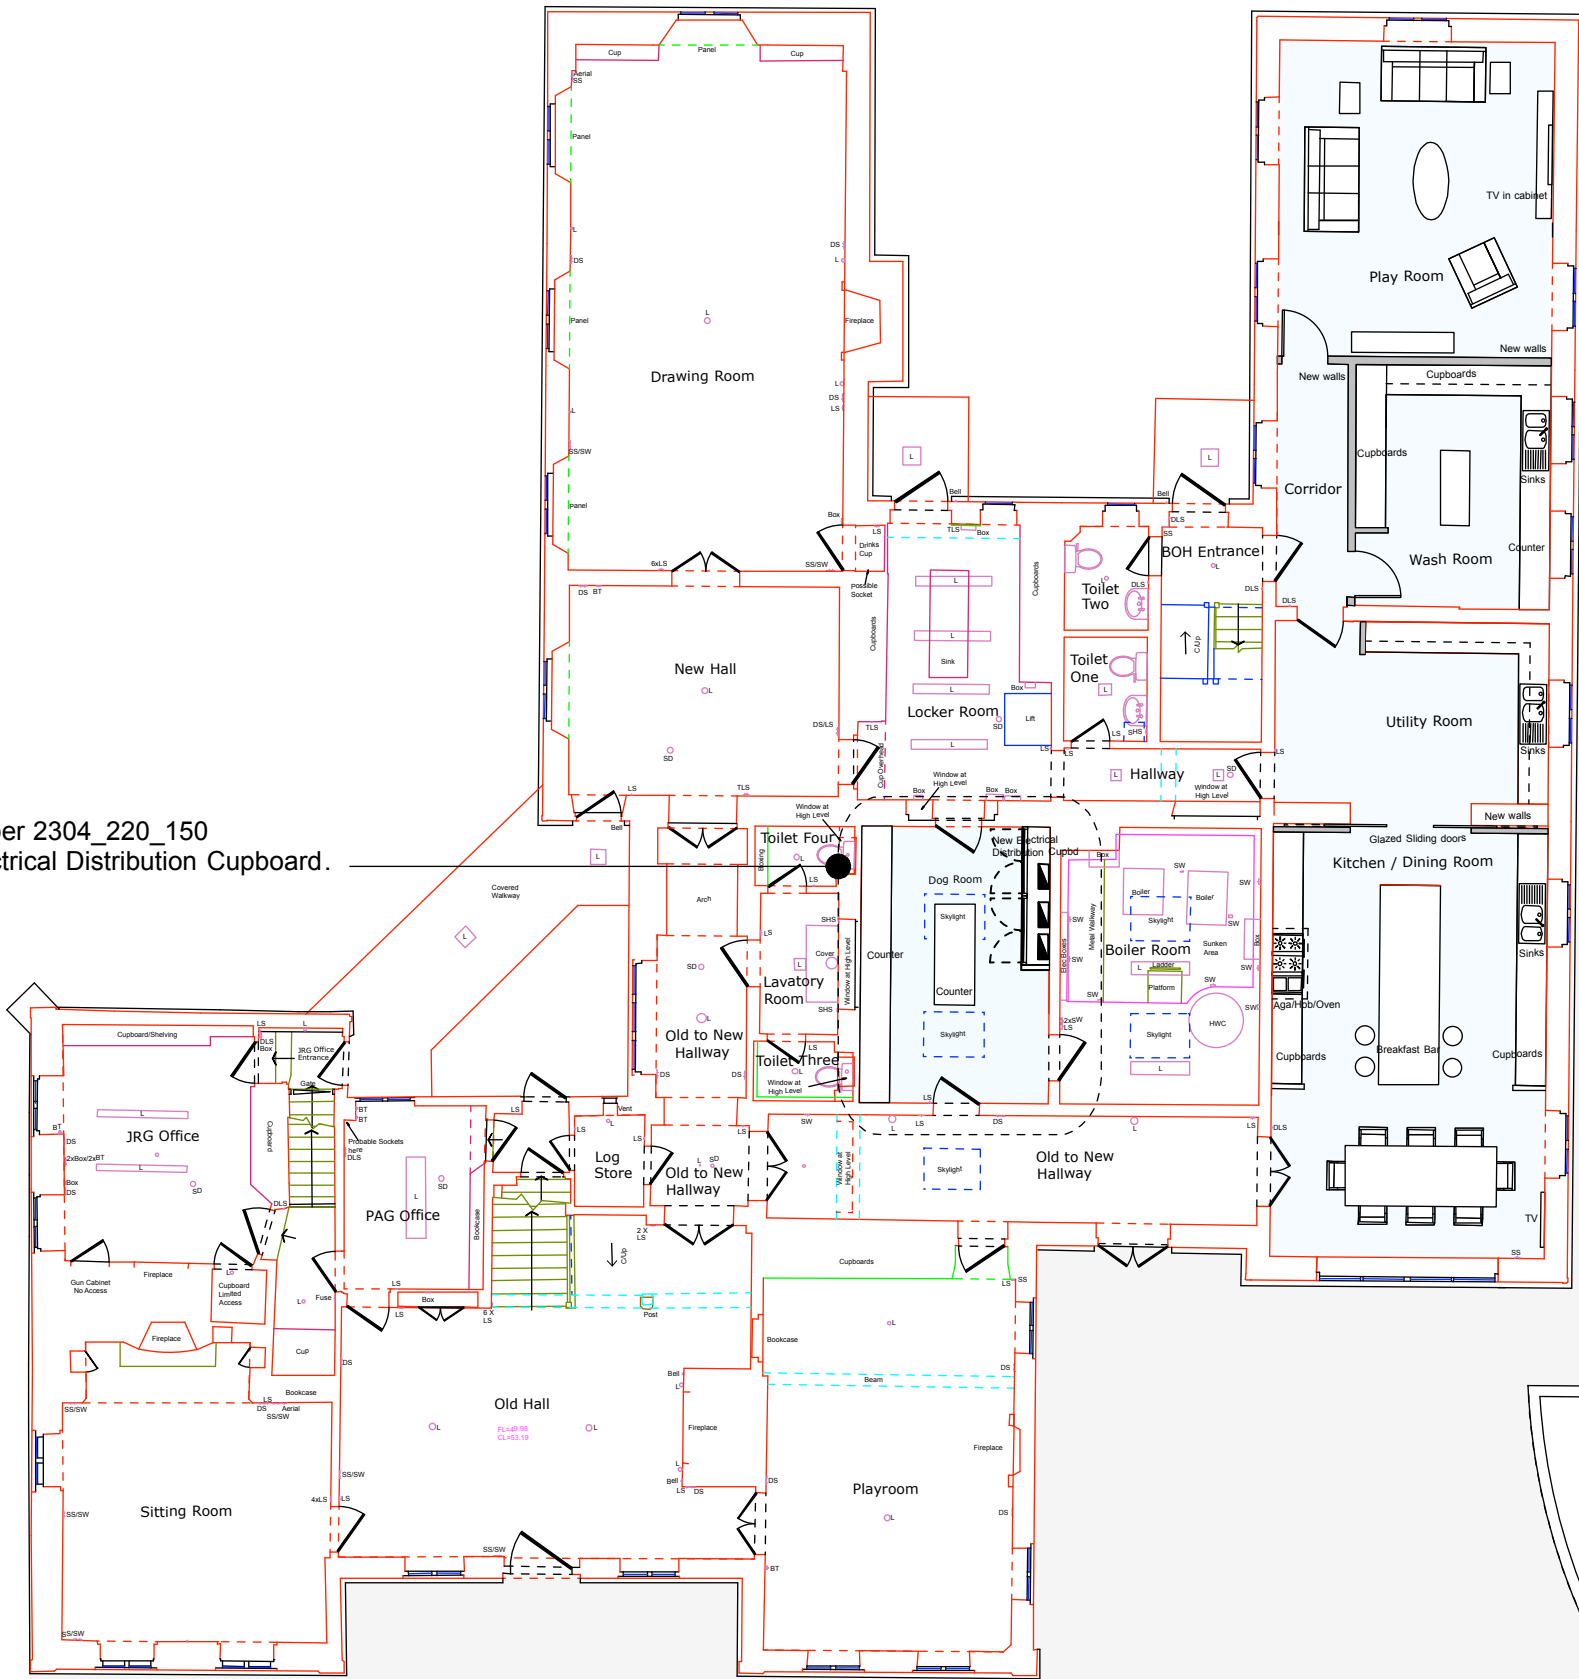

See drawing number 2304_220_150
details of new Electrical Distribution Cupboard.



C	Drawing revised. Sink location revised.	03 10 25	MW
B	Drawing revised. Electrical Distribution Cupboard added.	14 08 25	MW
A	Drawing revised.	07 08 25	MW
Rev.	Description	Date	Check by

- Do not scale this drawing. The Contractor is to verify all dimensions & conditions on site and report any discrepancies to the Architect before proceeding.
- This drawing is to be read in conjunction with all relevant project documentation.
- This drawing is subject to the approval of the appropriate Statutory Authorities.

PERSEVERANCE ARCHITECTS

PERSEVERANCE ARCHITECTS LTD
Three Brew Eagle House
163 City Road
London EC1V 1NR
+44 (0) 20 3773 8880
mail@perseverancearchitects.co.uk
www.perseverancearchitects.co.uk

Project :
STONE HALL
HAYWARDS HEATH RD, BALCOMBE,
HAYWARDS HEATH RH17 6QN

Title :
GROUND FLOOR PLAN
PROPOSED

Scale : 1:150 @ A3 | Date :
1:50 @ A0 | 05 02 2024

Drawn by : MS | Checked by : MW

Drawing No. : 2304_PL_002 | Revision : C

Status :
PLANNING

© PERSEVERANCEARCHITECTS LTD