
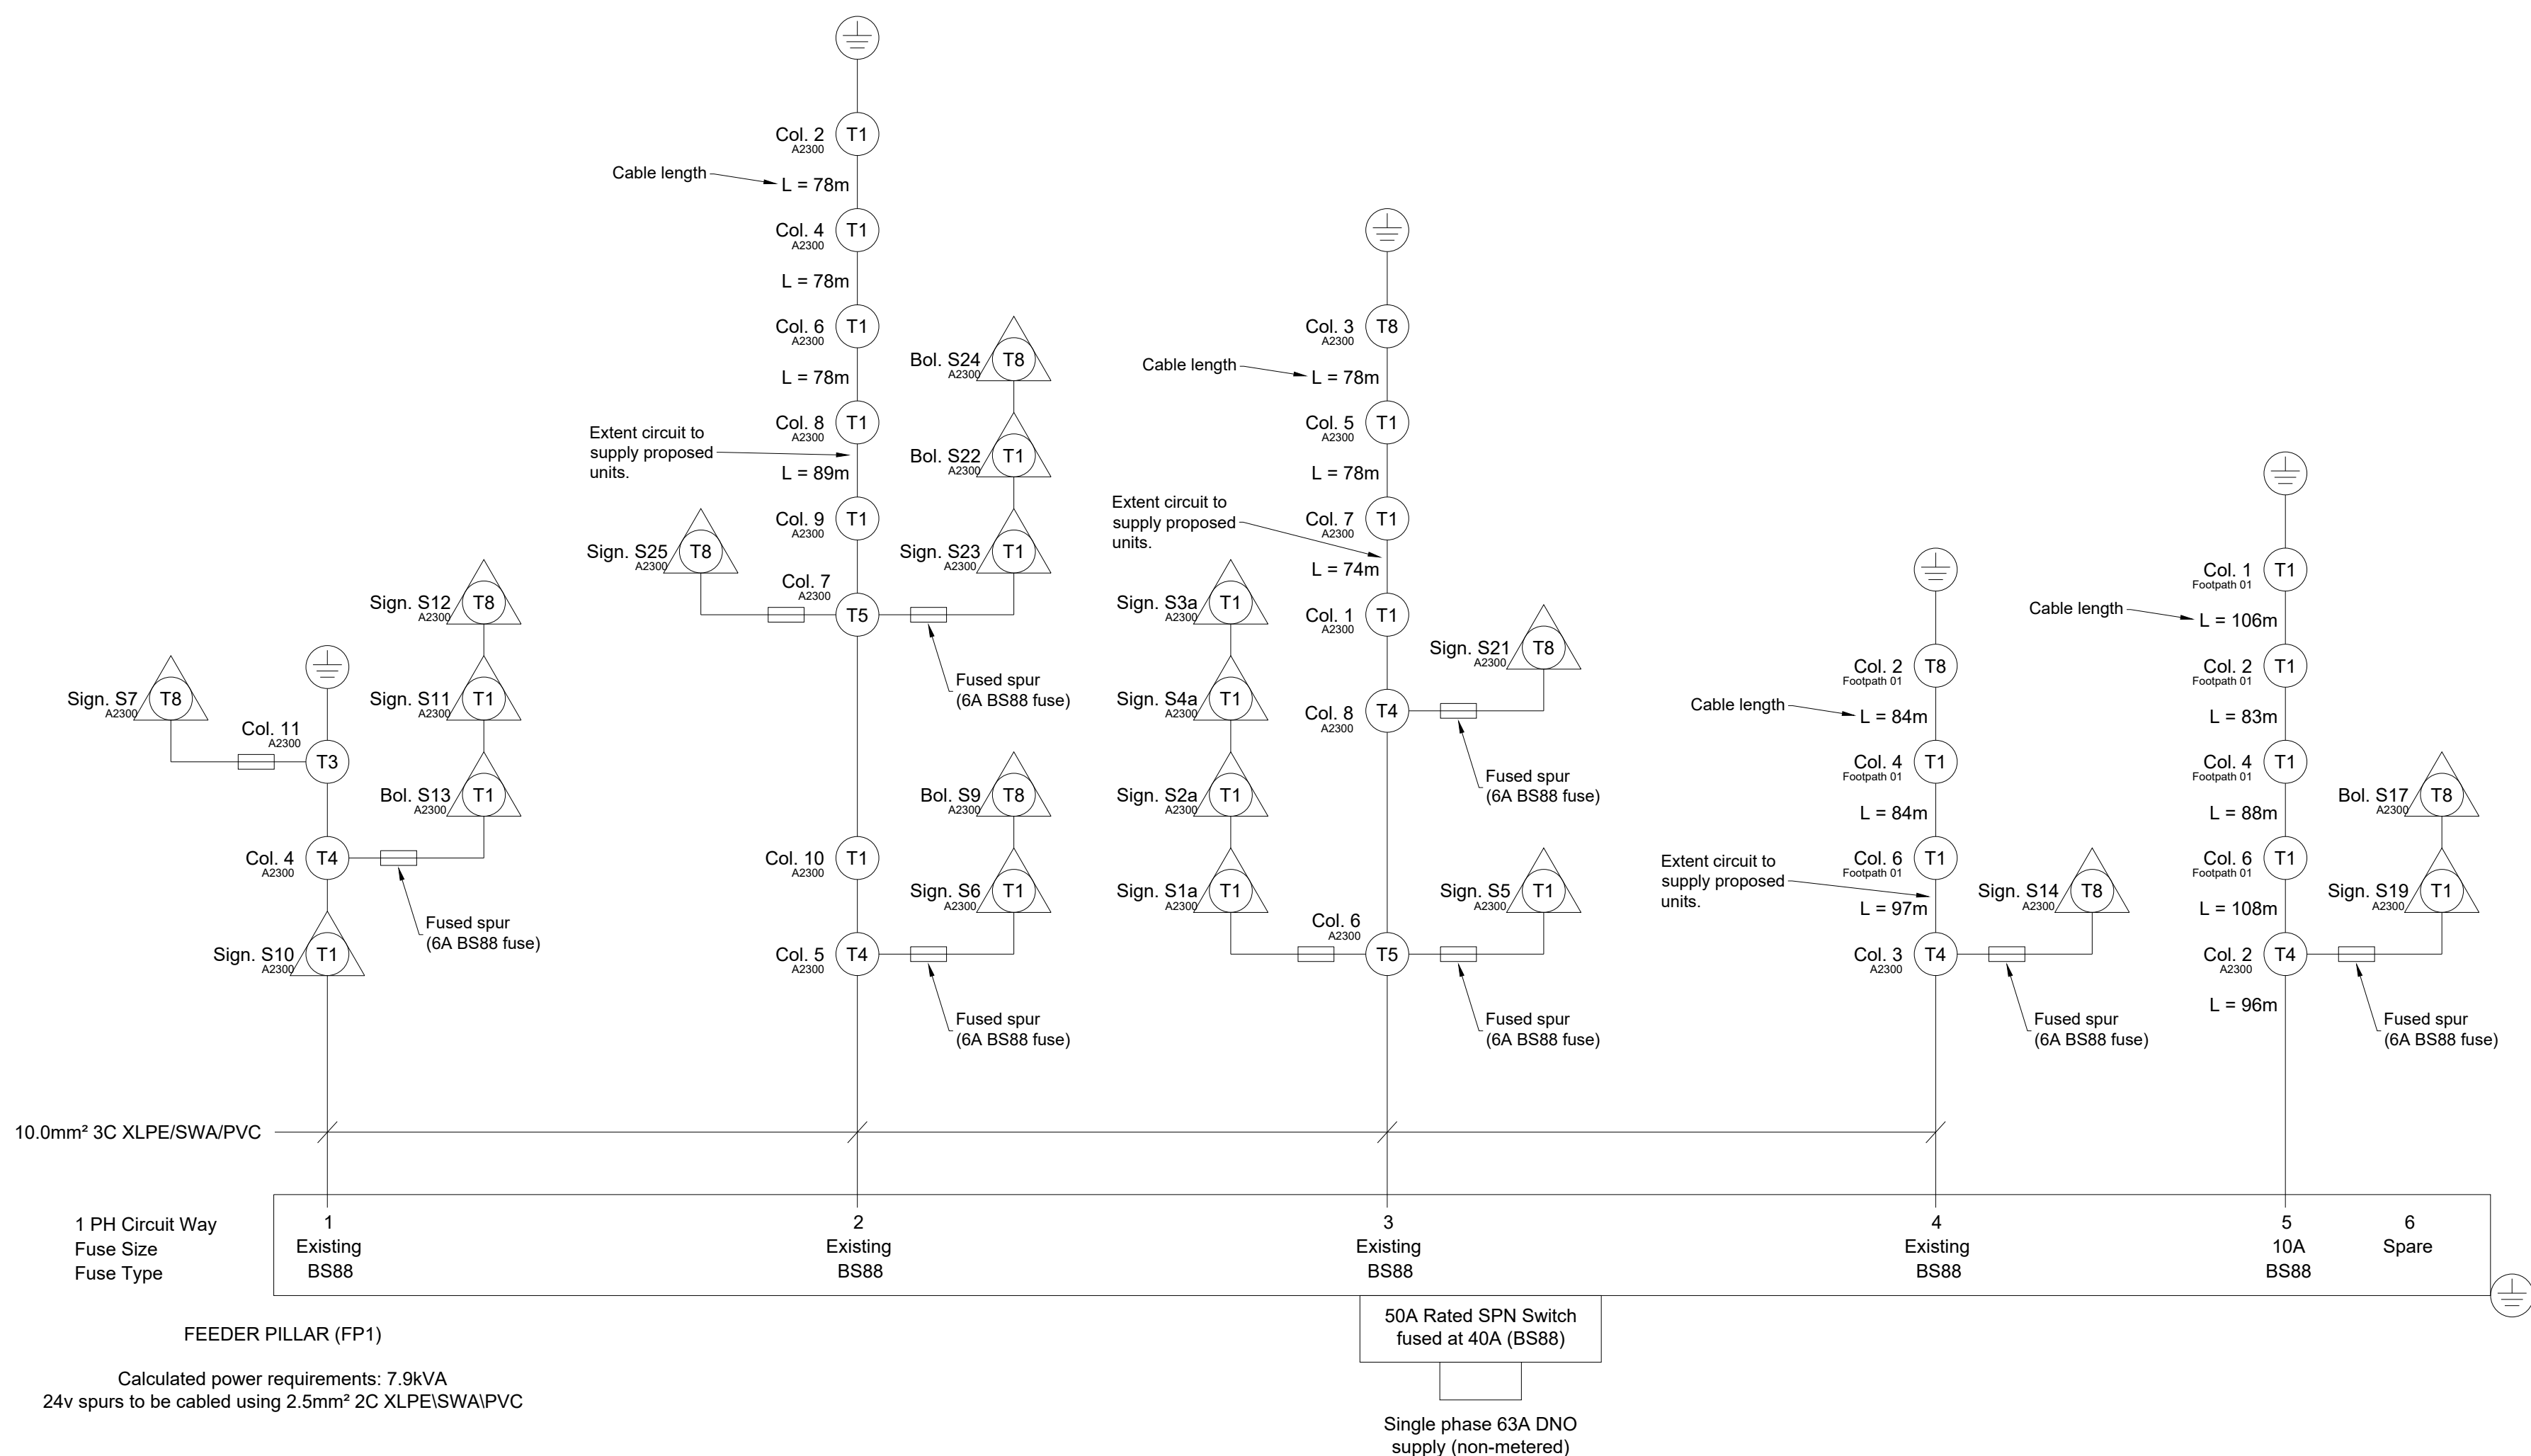
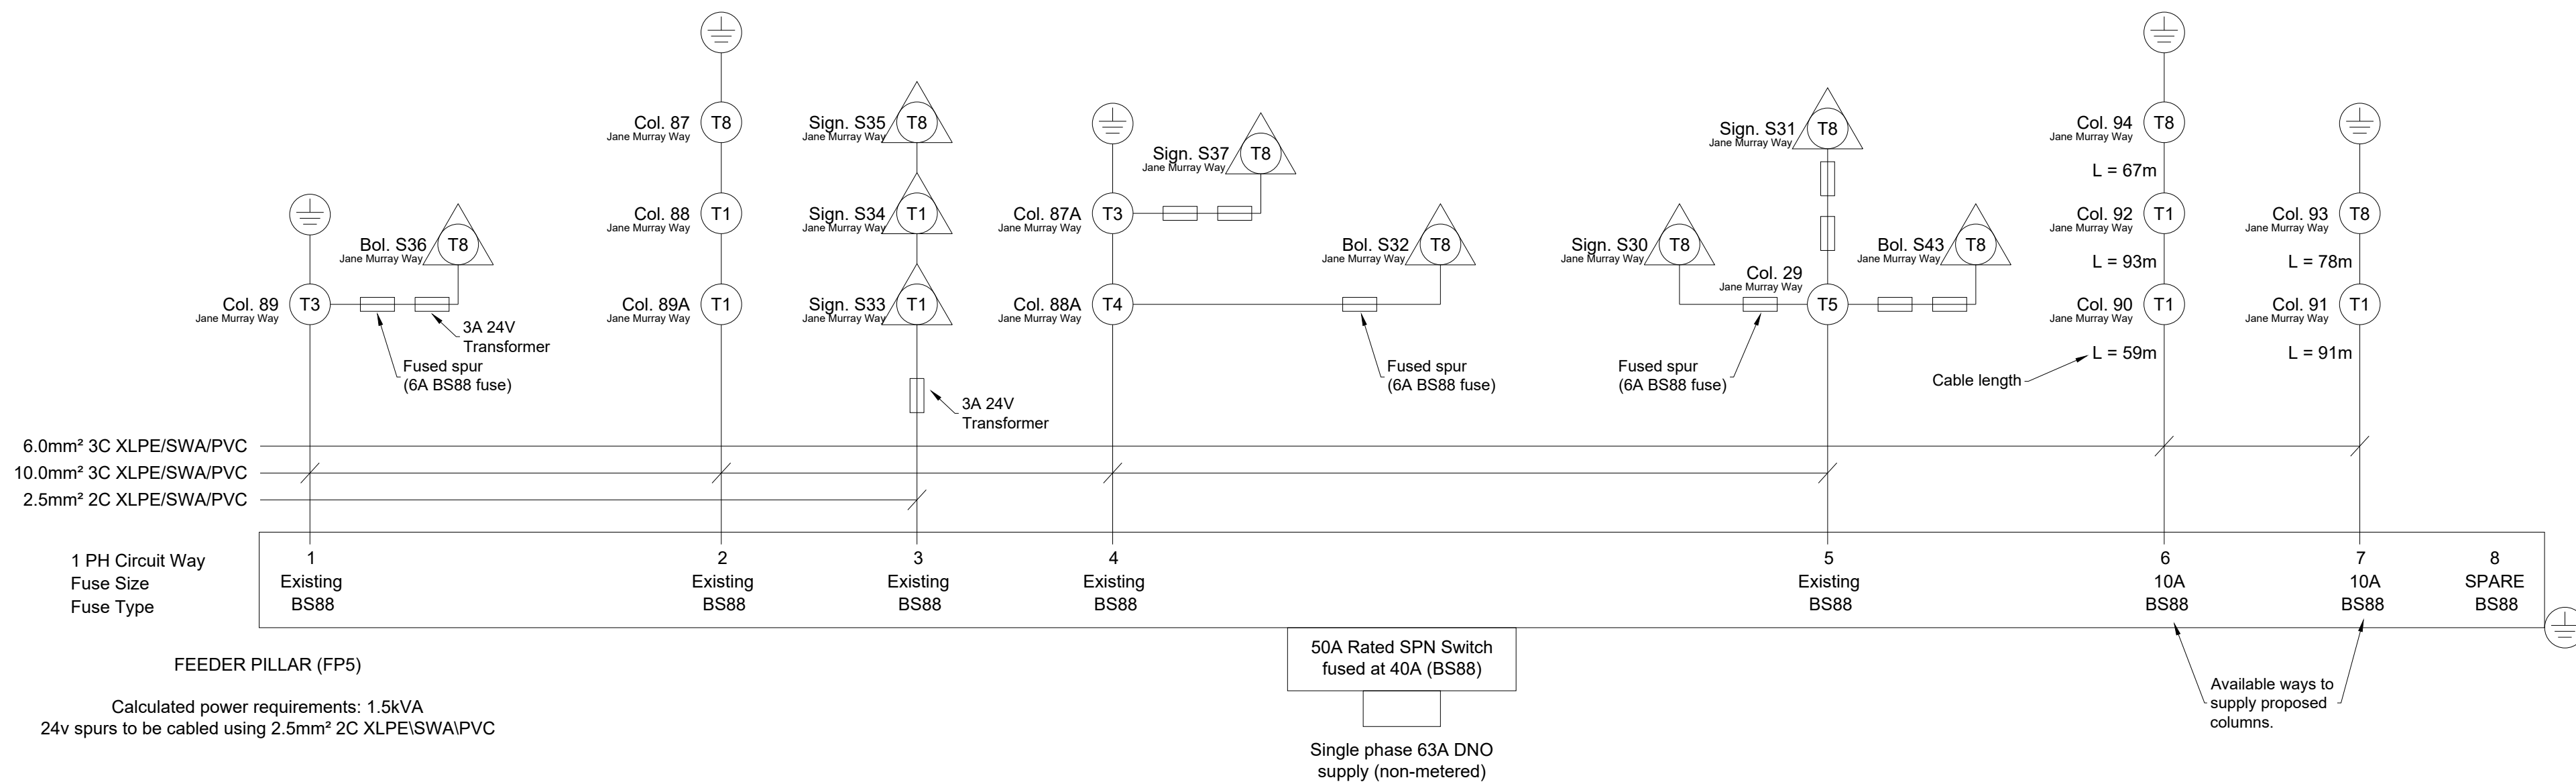


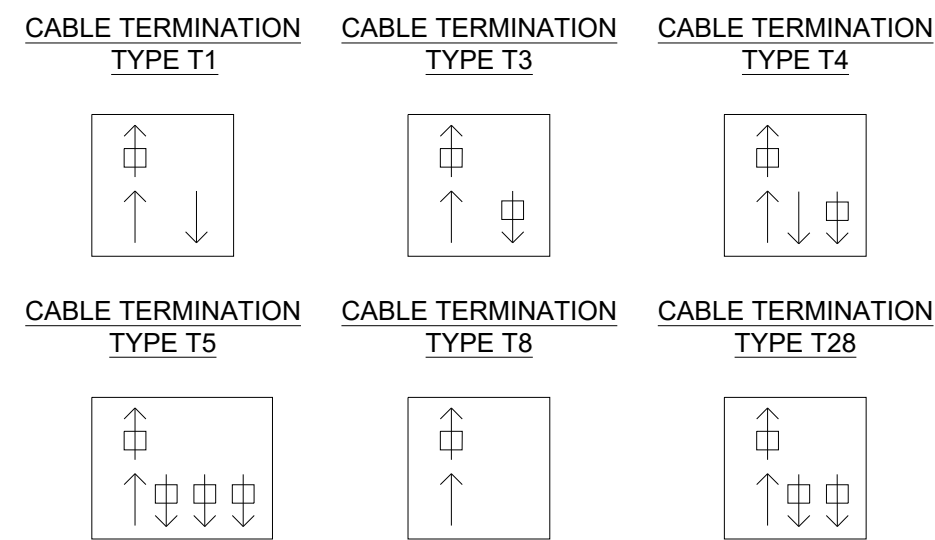

Hazard/Risk Codes 	
Code	Hazard/Risk Description
HV(U)	High Voltage Underground Cables
FO	Fibre Optic

C:\Users\michael.groves\Enverve\Lighting Design Hub - Documents\02 Projects\20014676 - Burgess Hill WBLR Phase 3\2_Design\EVO20014676-LD-001-H.dwg

Key

Col. 16  Illuminated column
Termination type
Unit reference number

sign. 16  Illuminated sign/bollard
Termination type
Unit reference number

 Earth electrode

1. Do not scale from drawing if not printed at original paper size.
2. All electrical equipment and works to be carried out in accordance with current West Sussex County Council's specification.
3. Contractor to confirm position of statutory undertakers plant before commencement of the works. For statutory undertaker's information visit www.linereachbeforeyoudig.co.uk
4. During works all traffic management to be in accordance with Chapter 8 of the Traffic Signs Manual.
5. All apparatus are to be new at the time of installation and be supported by relevant manufacturer's guarantees.
6. All illuminated apparatus must be installed and tested in compliance with BS57671 at the time of adoption.
7. All electrical cables to be 3 core XLPE/SWAP/PVC and laid in orange 100mm dia duct.
8. Road crossing to have one spare PVC duct.
9. 150mm wide yellow heavy gauge PVC tape marked "Street Lighting Cables" placed over private electricity ducts / cables
10. Ducting below footways to be 450mm below finished level.
11. Ducting below carriageways to be 600mm below finished level.
12. Every duct to be installed with draw cords.
13. This detailed design has been prepared in accordance with the HEA-HEMSA guidance note - CDM2015 regulations, issue 1.1, dated 09/04/15 Procedure 3: information has been supplied by the client or another designer or the principal designer which forms the basis of this lighting scheme design and includes the hazards identified by others on their hazard elimination and management list

B	AMENDED FOLLOWING JCE COMMENTS	30/04/25	MW
A	ORIGINAL ISSUE	17/02/25	MW
REV	DESCRIPTION	DATE	BY



TITLE	STREET LIGHTING LAYOUT DRAWING
	SHEET 4 OF 4

PROJECT		BURGESS HILL WBLR PHASE 3	
SCALE	DATE	17/02/25	
1:500 @ A1	DRAWN	MWG	
	CHECKED	RHJ	
PAPER SIZE	A1	APPROVED	SAB
DRAWING NUMBER			REVISION
EVO20014676-LD-004			B