



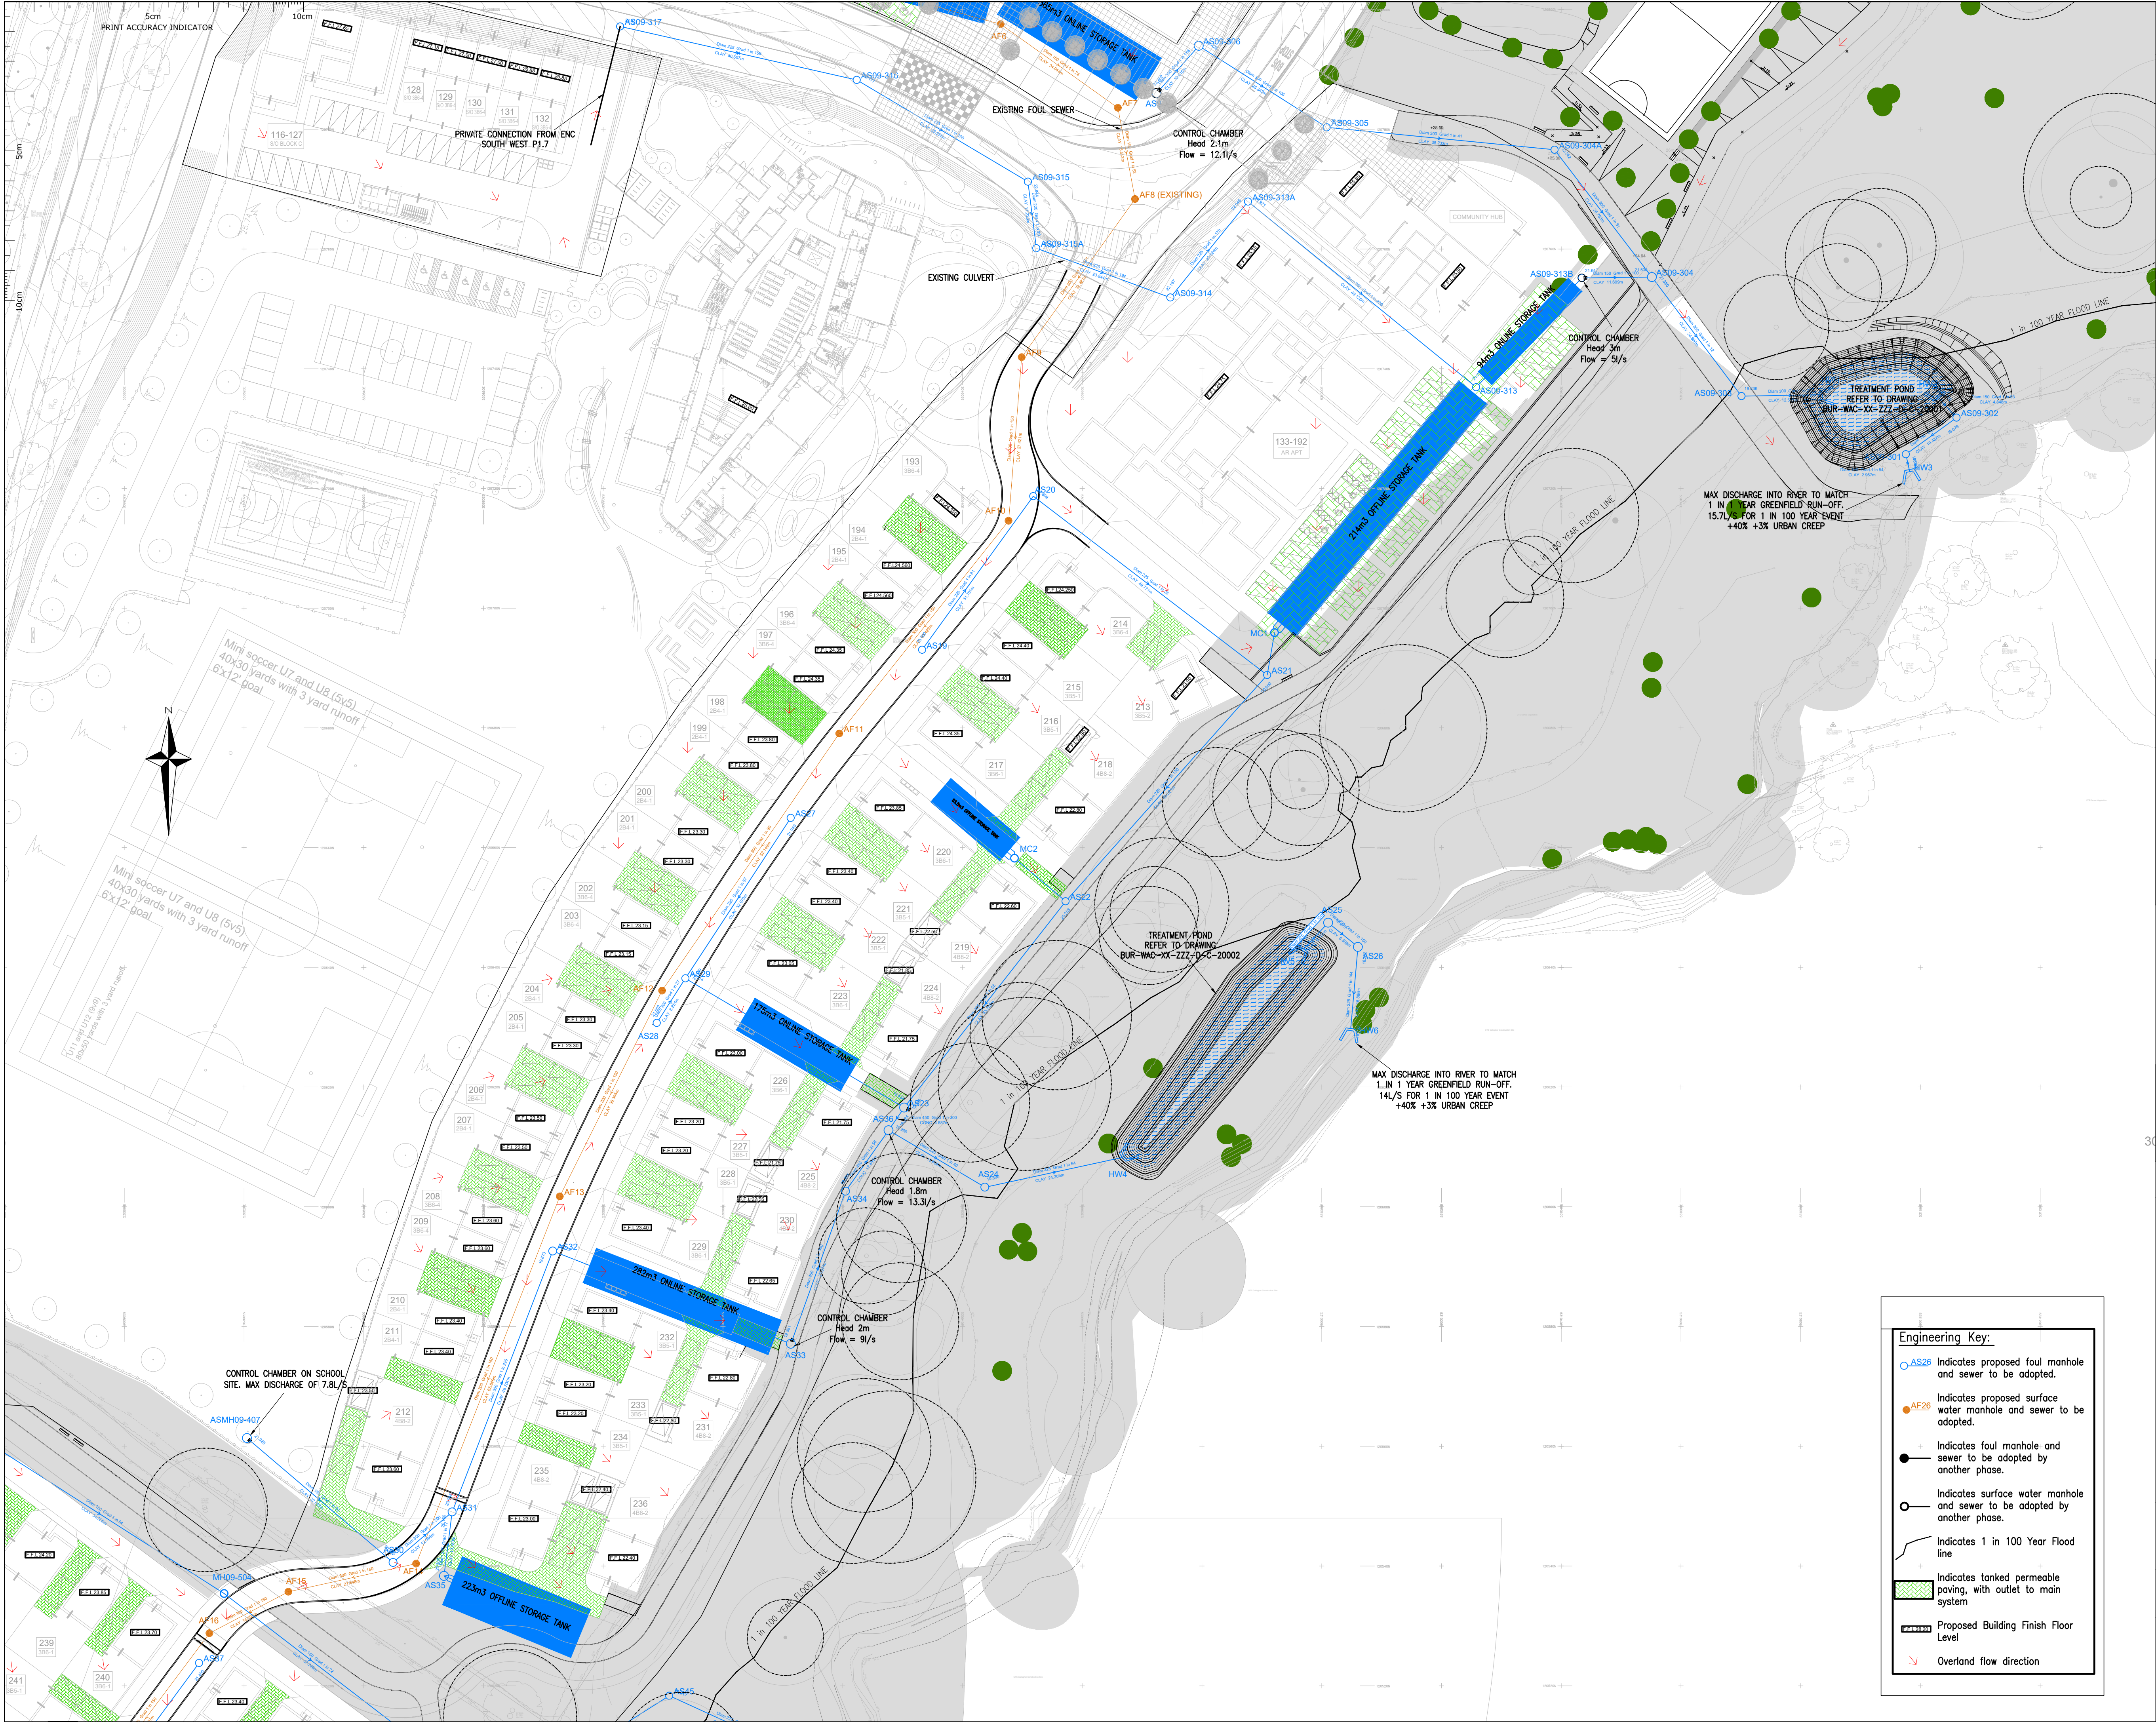

THIS DRAWING IS COPYRIGHT AND MUST NOT BE REPRODUCED IN WHOLE OR PART WITHOUT WRITTEN AUTHORITY

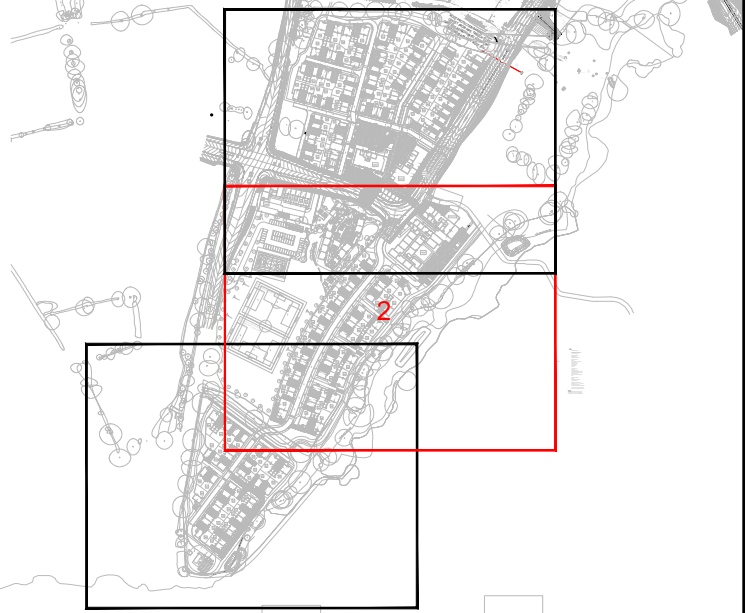

REV	DATE	AMENDMENT	BY	CHKD
P03	17/07/25	Site layout updated to latest.	AB	LRW
P02	10/07/25	Start of road 1 re-designed again as per client request. House FFL's and drainage adjusted to suit. Treatment pond 1 moved back to original position.	AB	LRW

STATUS
PLANNING

PROJECT
**Burgess Hill
Northern Arc
Phase 1C**
CLIENT



DRAWING
**Main Drainage Layout
Sheet 2**

DATE	02/06/2025	DRAWN BY	AB	REV.
SCALE (A1)-	1:500	CHECKED BY	LRW	P03
WALKERS JOB NUMBER	7714			

DRG NO.
BUR-WAC-XXX-YYY-D-C-10402

Walker Associates Consulting Limited
Structural and Civil Engineers
13 Capricorn Centre
Cranes Farm Road
Bosilton, Essex
SS14 3JF
01268 530 500
walker-associates.co.uk