
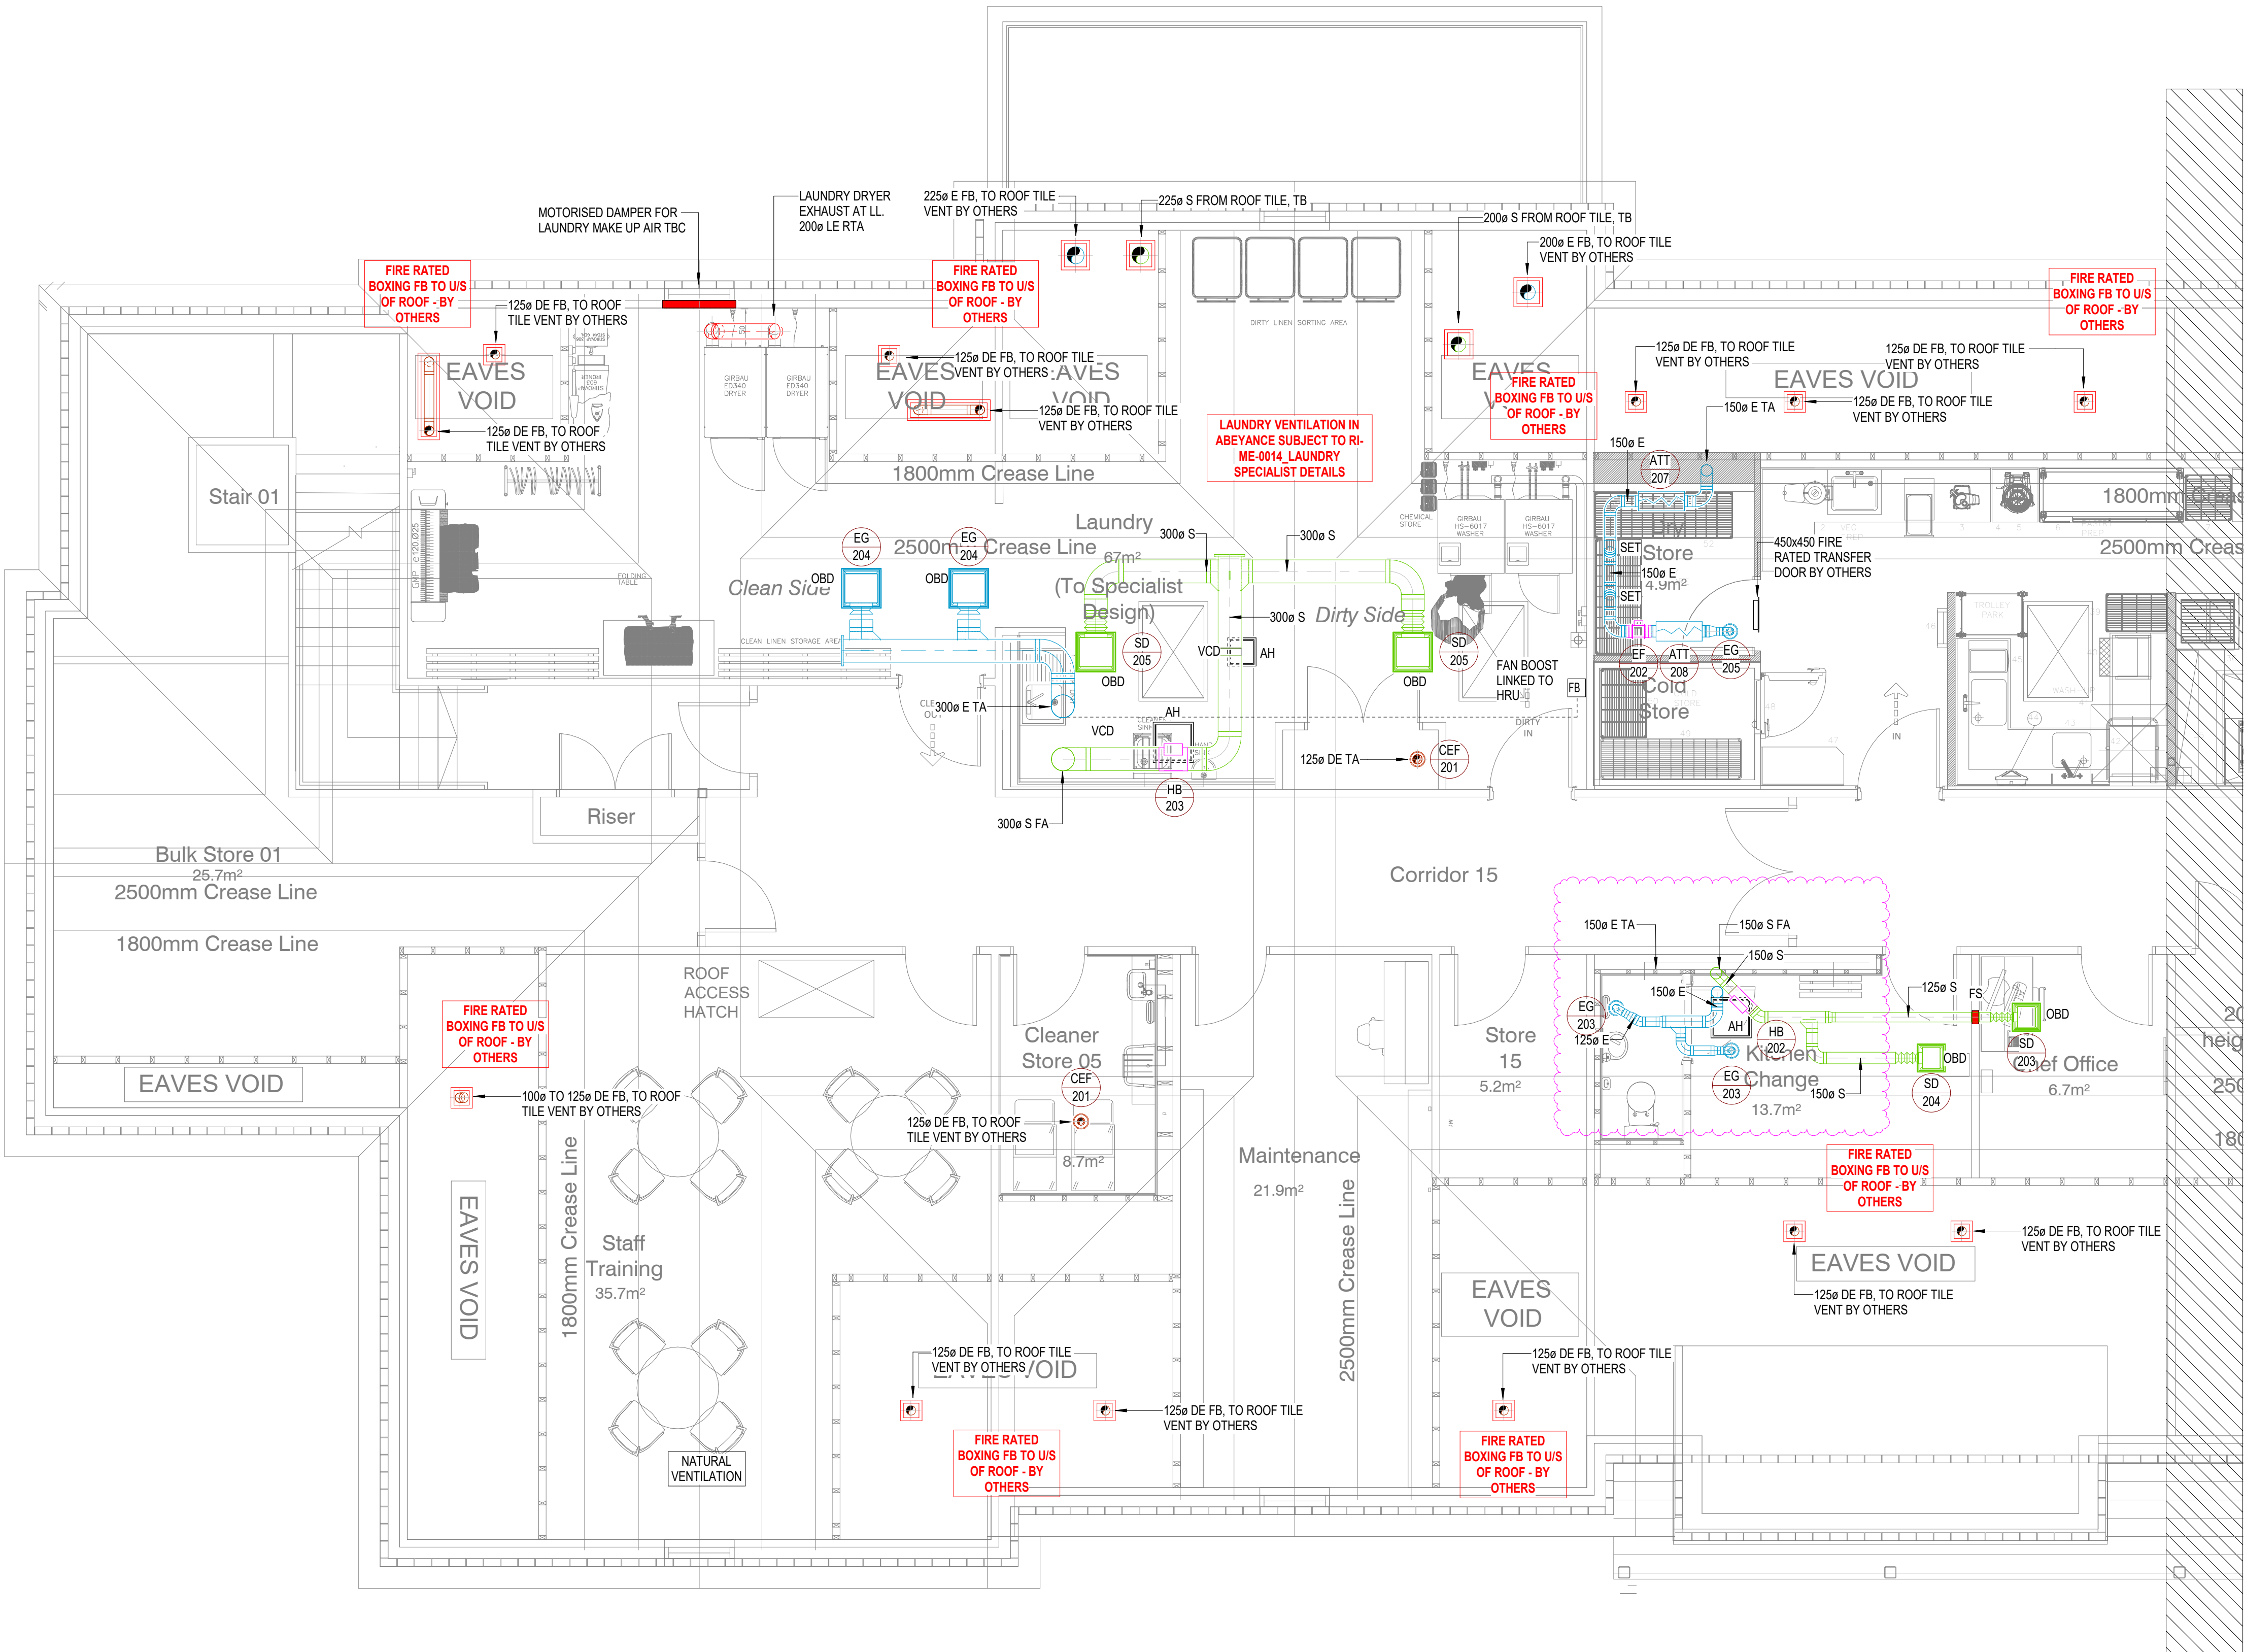
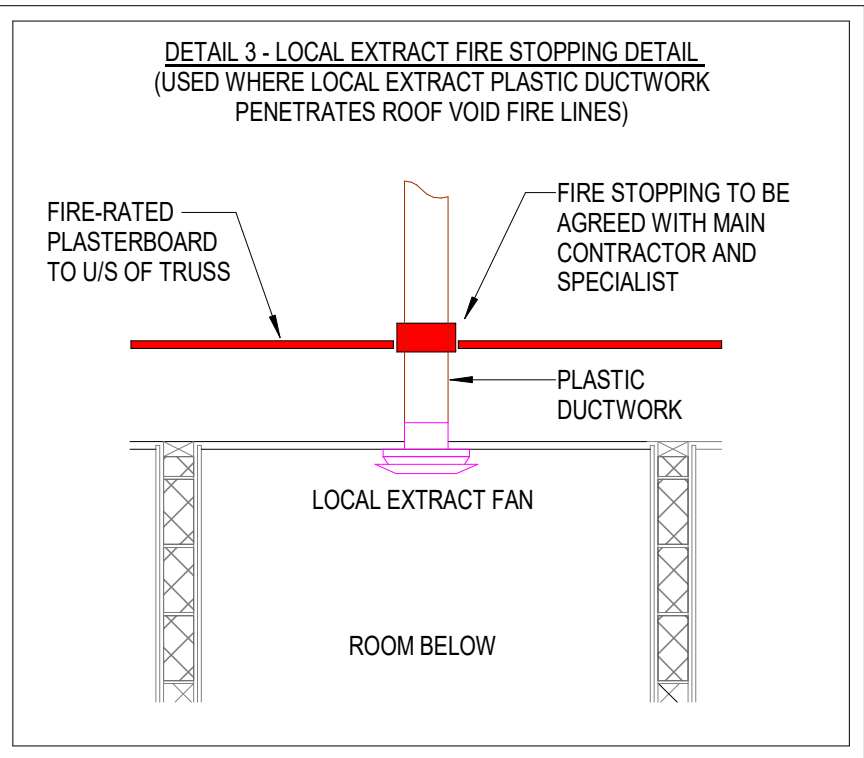
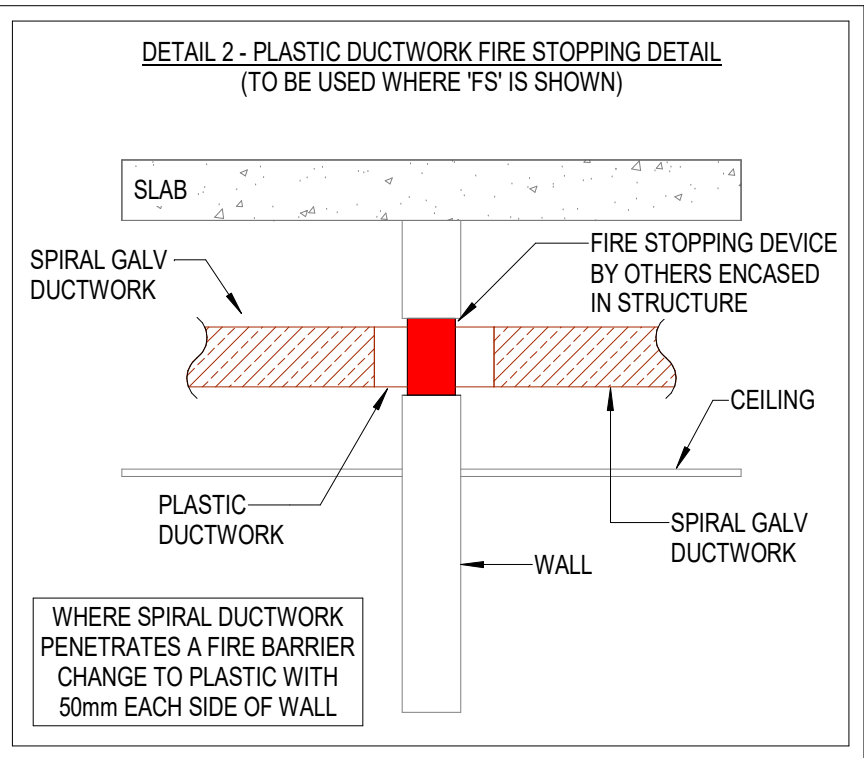


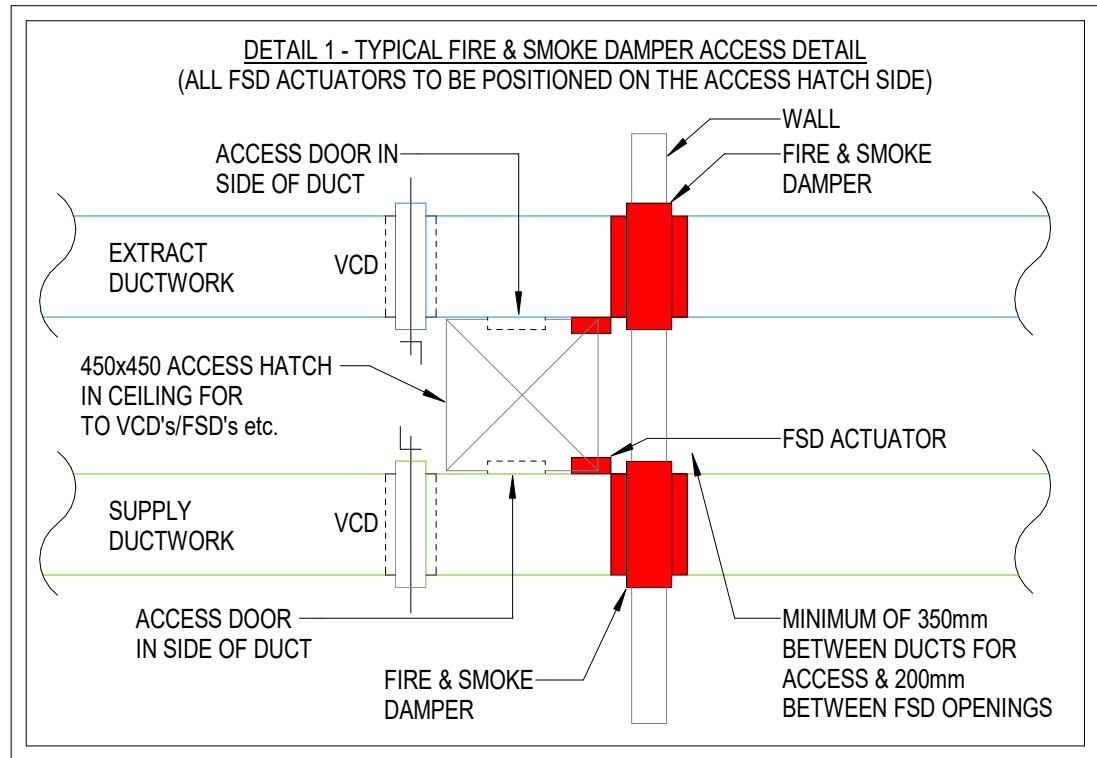

REFER TO CONTINUATION DRAWING 2537-HCL-ZZ-XX-DR-M-2021

- NOTES:
- THIS DRAWING SHALL BE READ IN CONJUNCTION WITH ANY RELEVANT STRUCTURAL ARCHITECTURAL & CONSULTANTS DRAWINGS/SPECIFICATIONS.
 - THIS DRAWING IS NOT TO BE SCALED
 - ALL DIMENSIONS STATED IN mm.
 - FSDs/FSOs/FSWFCs ARE PROVIDED WHERE SHOWN ON DRAWINGS & ALSO WHERE DUCTWORK PENETRATES THROUGH FIRE BARRIERS INDICATED ON FIRE STRATEGY DRAWINGS. WHERE FC IS DETAILED A FIRE COLLAR HAS BEEN INSTALLED ON EITHER SIDE OF STUD WALL.
 - THE DUCTWORK INSTALLATION HAS BEEN IN ACCORDANCE WITH DW144 & THE MECHANICAL SERVICES SPECIFICATION.
 - THE DUCTWORK SHALL BE INSULATED IN LINE WITH THE MEP SPECIFICATION.
 - VCDs, FSDs & FDS ARE POSITIONED TO ENSURE ACCESS HATCHES/DUMMY GRILLES WILL BE IN "BACK OF HOUSE" AREAS WHEREVER POSSIBLE.
 - ALL FIRE & FIRE SMOKE DAMPERS MUST HAVE AN ACCESS DOOR IN DUCTWORK AND FIXED TO STRUCTURE USING NON-COMBUSTIBLE FIXINGS. ALL FDS AND FSDS ARE TO BE MADE ACCESSIBLE ON SITE.
 - DIRTY EXTRACT DUCTWORK SHALL BE INSTALLED USING PLASTIC INTERNALLY & GALVANISED EXTERNALLY.
 - ALL WEATHERING OF PENETRATIONS THROUGH THE ROOF SHALL BE CONFIRMED & INSTALLED BY MAIN CONTRACTOR.
 - AREAS SERVED VIA LOCAL EXTRACT VENTILATION SHALL BE PROVIDED WITH UNDERCUT DOORS (BY OTHERS) FOR MAKE-UP AIR.
 - ROOMS NOTED AS NATURAL VENTILATION SHALL BE PROVIDED WITH OPENABLE WINDOWS AND BACKGROUND TRICKLE VENTS IN ACCORDANCE WITH AD PART F.
 - GRILLE, FAN AND ACCESS LOCATIONS ARE SHOWN INDICATIVELY. FOR FINAL LOCATIONS & SETTING OUT REFER TO THE ARCHITECT'S 1:20 ROOM LAYOUT DRAWINGS.

LEGEND:

AH	ACCESS HATCH
AHU	AIR HANDLING UNIT
ATT	ATTENUATOR
CEF	CROSS-TALK ATTENUATOR
CE	DIRTY EXTRACT DUCT
DG	DUMMY GRILLE W/ REMOVABLE CORE
DTG	DOOR TRANSFER GRILLE
E	EXTRACT DUCT
EF	EXTRACT FAN
EG	EXTRACT GRILLE
FD	FIRE DAMPER
FS	FIRE STOPPING DEVICE BY OTHERS
FSD	FIRE SMOKE DAMPER
HRU	HEAT RECOVERY UNIT
NV	NATURAL VENTILATION
OBD	OPPOSED BLADE DAMPER
PEPS	PLAN/ROOM EXTRACT / SUPPLY
PC	ROOF COIL
S	SUPPLY DUCT
SG	SUPPLY GRILLE
TG	AIR TRANSFER GRILLE
VAV	VARIABLE AIR VOLUME CONTROLLER
VCD	VOLUME CONTROL DAMPER
FAPB	FROM ABOVE / FROM BELOW
YATB	TO ABOVE / TO BELOW

--- FIRE RATED DUCTWORK
--- 60-MIN COMPARTMENT LINE
--- 120-MIN COMPARTMENT LINE
--- 30-MIN CAVITY BARRIER IN VOID

C06	26.11.25	[DRAWING UPDATED AS CLOUDED]	SG
C05	06.11.25	[DRAWING UPDATED TO ALIGN WITH RCP LAYOUTS AS CLOUDED]	SG
C04	15.10.25	[DRAWING UPDATED AS CLOUDED]	SG
C03	13.10.25	[DRAWING UPDATED AS CLOUDED]	SG
C02	08.10.25	REVISED AS CLOUDED	SG
C01	19.08.25	UPDATED AS CLOUDED & ISSUED FOR CONSTRUCTION	SG
P02	02.06.25	AMENDED FOR COORDINATION	CP
P01	23.05.25	ISSUED FOR COMMENT	CP
REV	DATE	DETAILS OF REVISION	BY

HARNISS
1 Weekley Wood Avenue,
Kettering, Northants, NN14 1JQ
Tel: 01933 656850
Email: info@harniss.co.uk

CLIENT
HORIZON
(BARCHESTER HEALTHCARE LTD)


PROJECT
PROPOSED CARE HOME
TURNERS HILL ROAD
COPTHORNE, WEST SUSSEX

DRAWING TITLE

**SECOND FLOOR
VENTILATION LAYOUT
SHEET 3 OF 3**

Issue Status

FOR CONSTRUCTION			
Original Size	Scale	Drawn	
A0	1:50	CP	
HCL Project No.	Suitability	Checked	
2537	-	SG	
Project	Original	Volume	Level
2537 - HCL - ZZ - XX - DR - M - 2022			

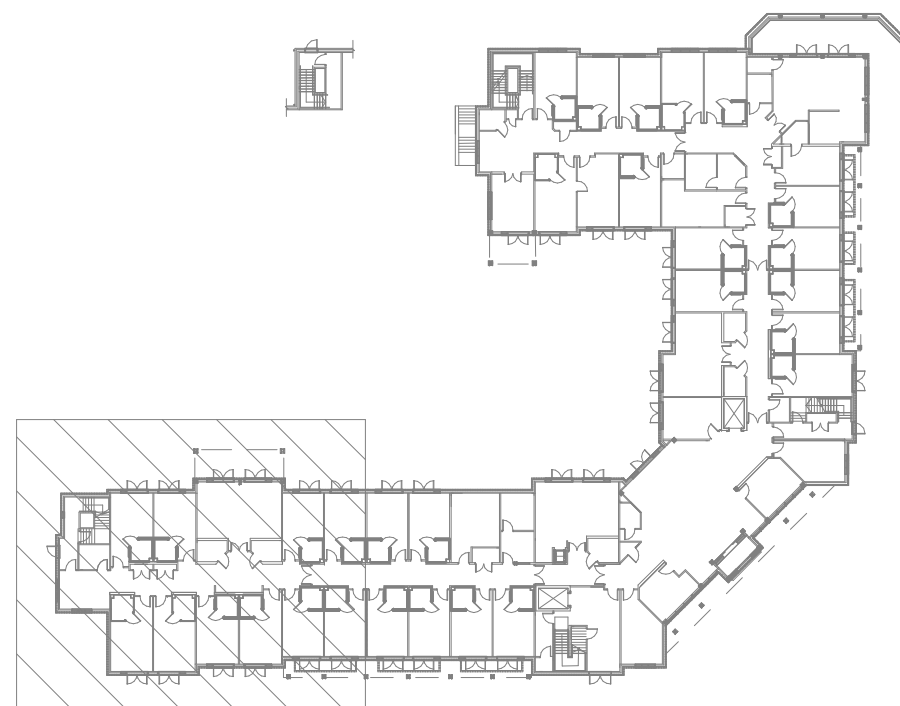

KEYPLAN