





BASEMENT PLAN
scale 1:200

HOLLYROOD HOUSE


FIRST FLOOR PLAN
scale 1:200

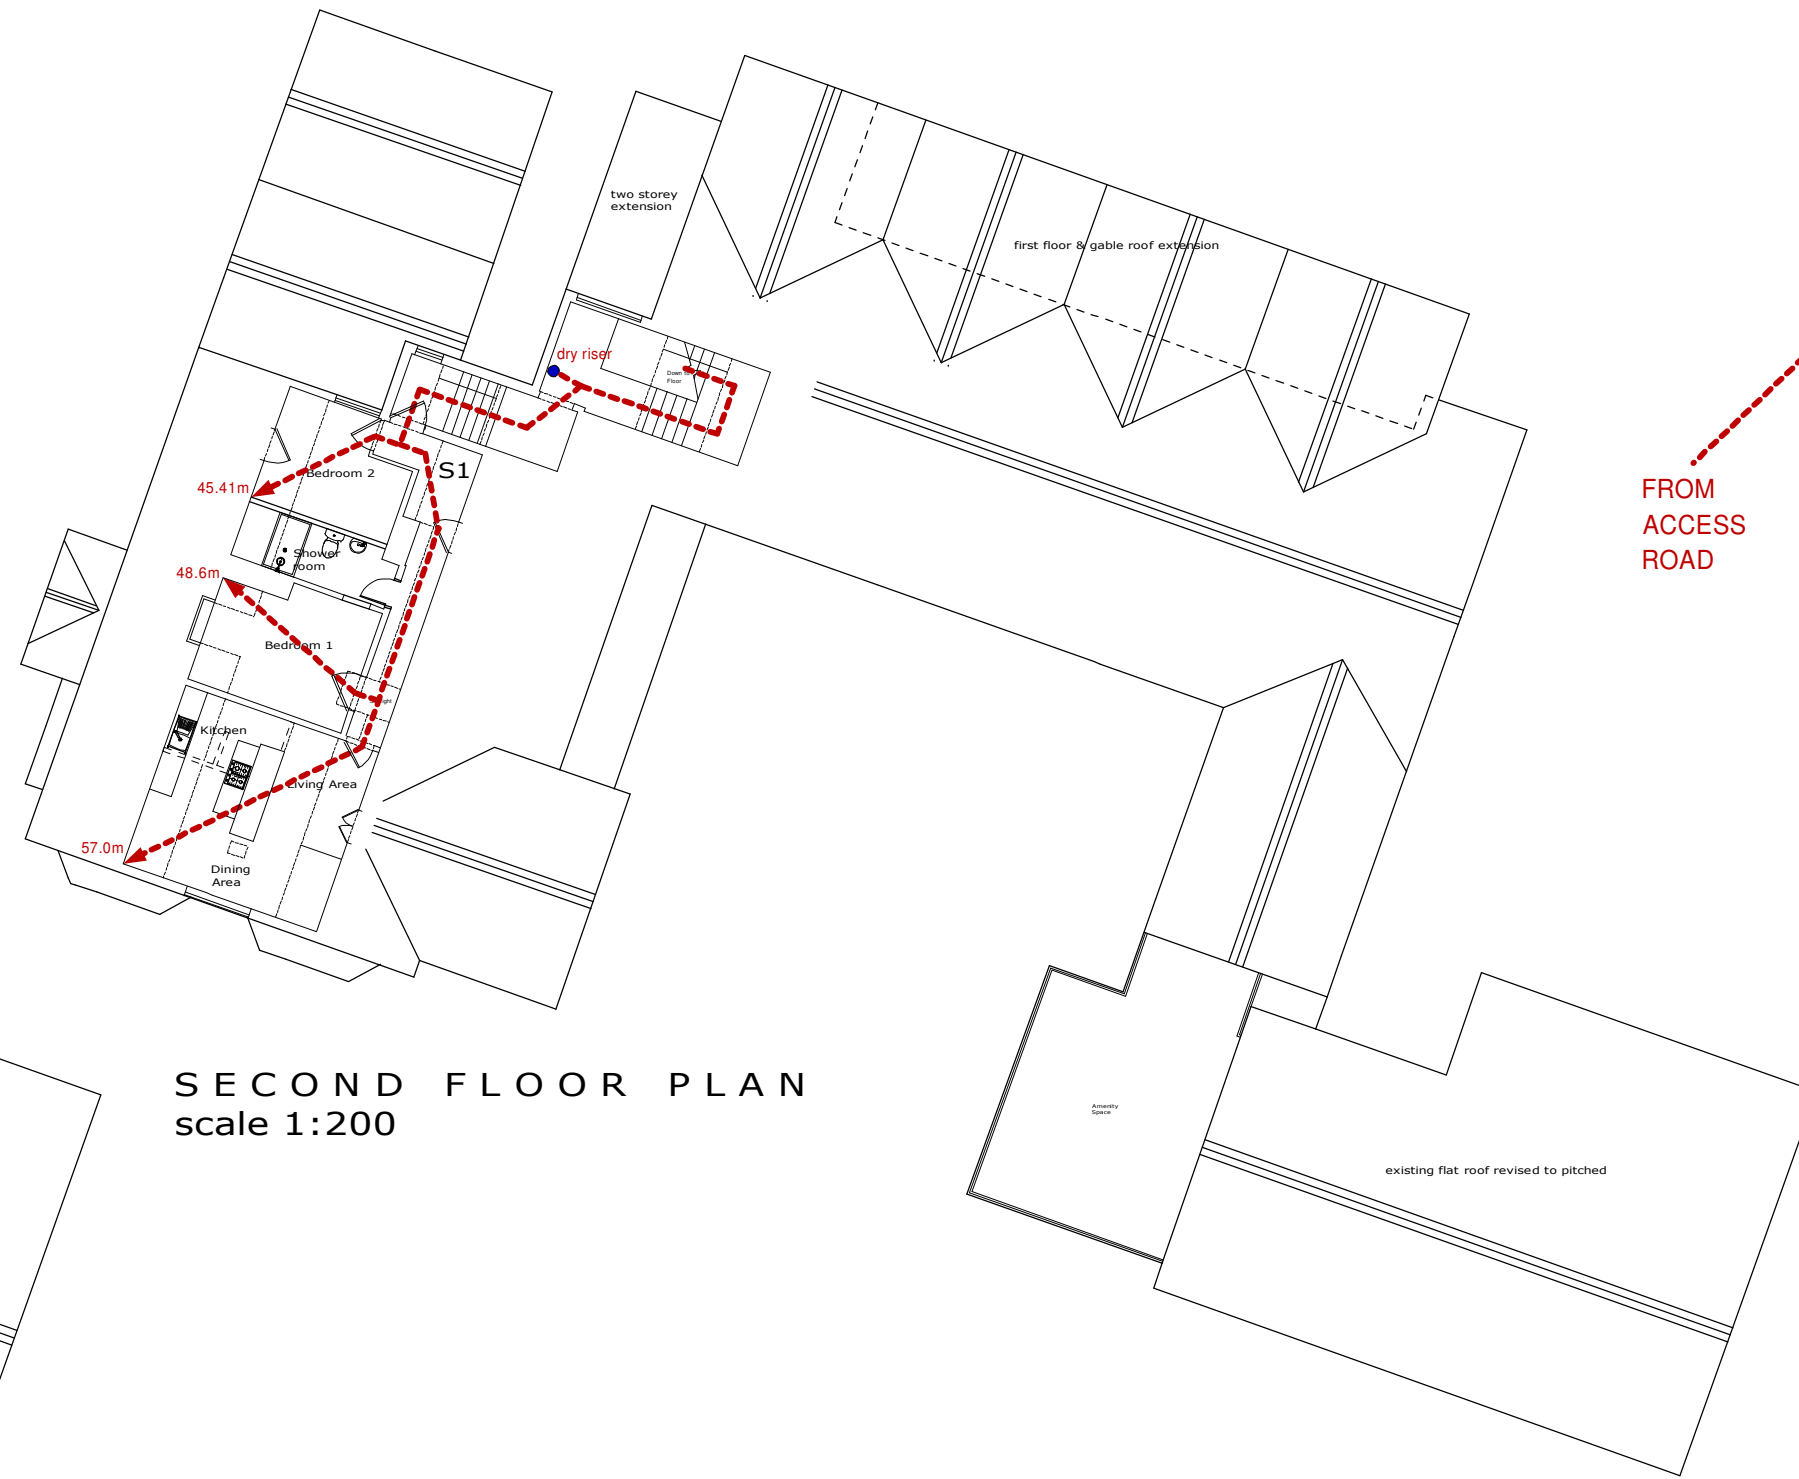

SECOND FLOOR PLAN
scale 1:200

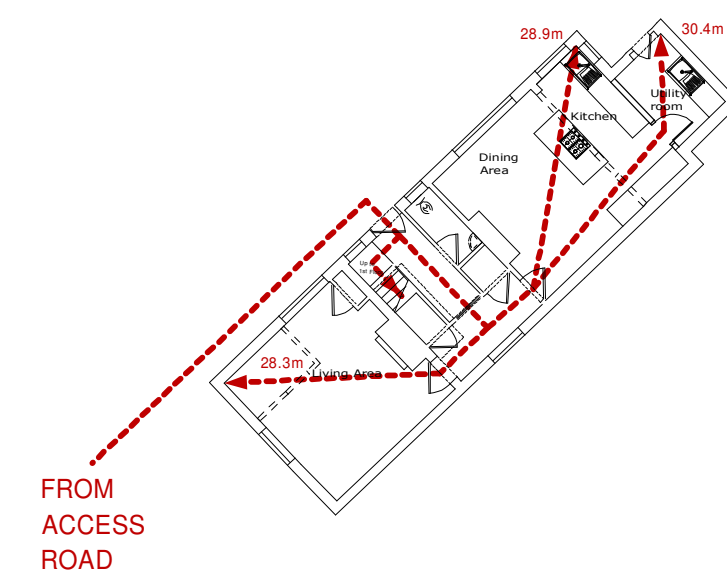


GROUND FLOOR PLAN
scale 1:200

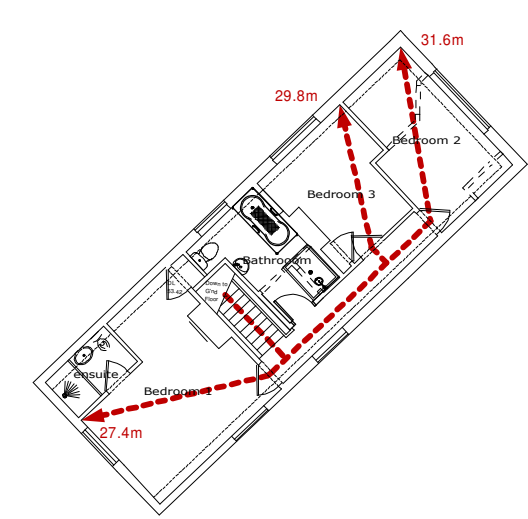

FIRST FLOOR PLAN
scale 1:200

HOLLYROOD COTTAGE

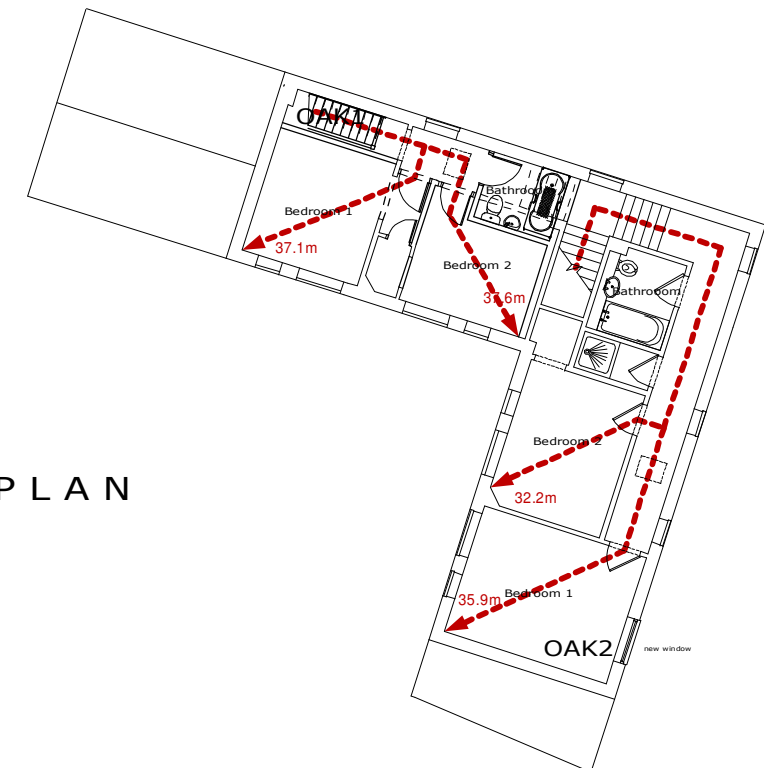

FIRST FLOOR PLAN
scale 1:200

OAKWOOD

SITE LAYOUT &
GROUND
FLOOR PLAN
scale 1:200

FIRE FIGHTING KEY

- Fire Fighter Hose Route and length
- Fire appliance Parking location - 10.5 x 2.5m
- Fire evacuation assembly point
- Dry Riser Position

