
 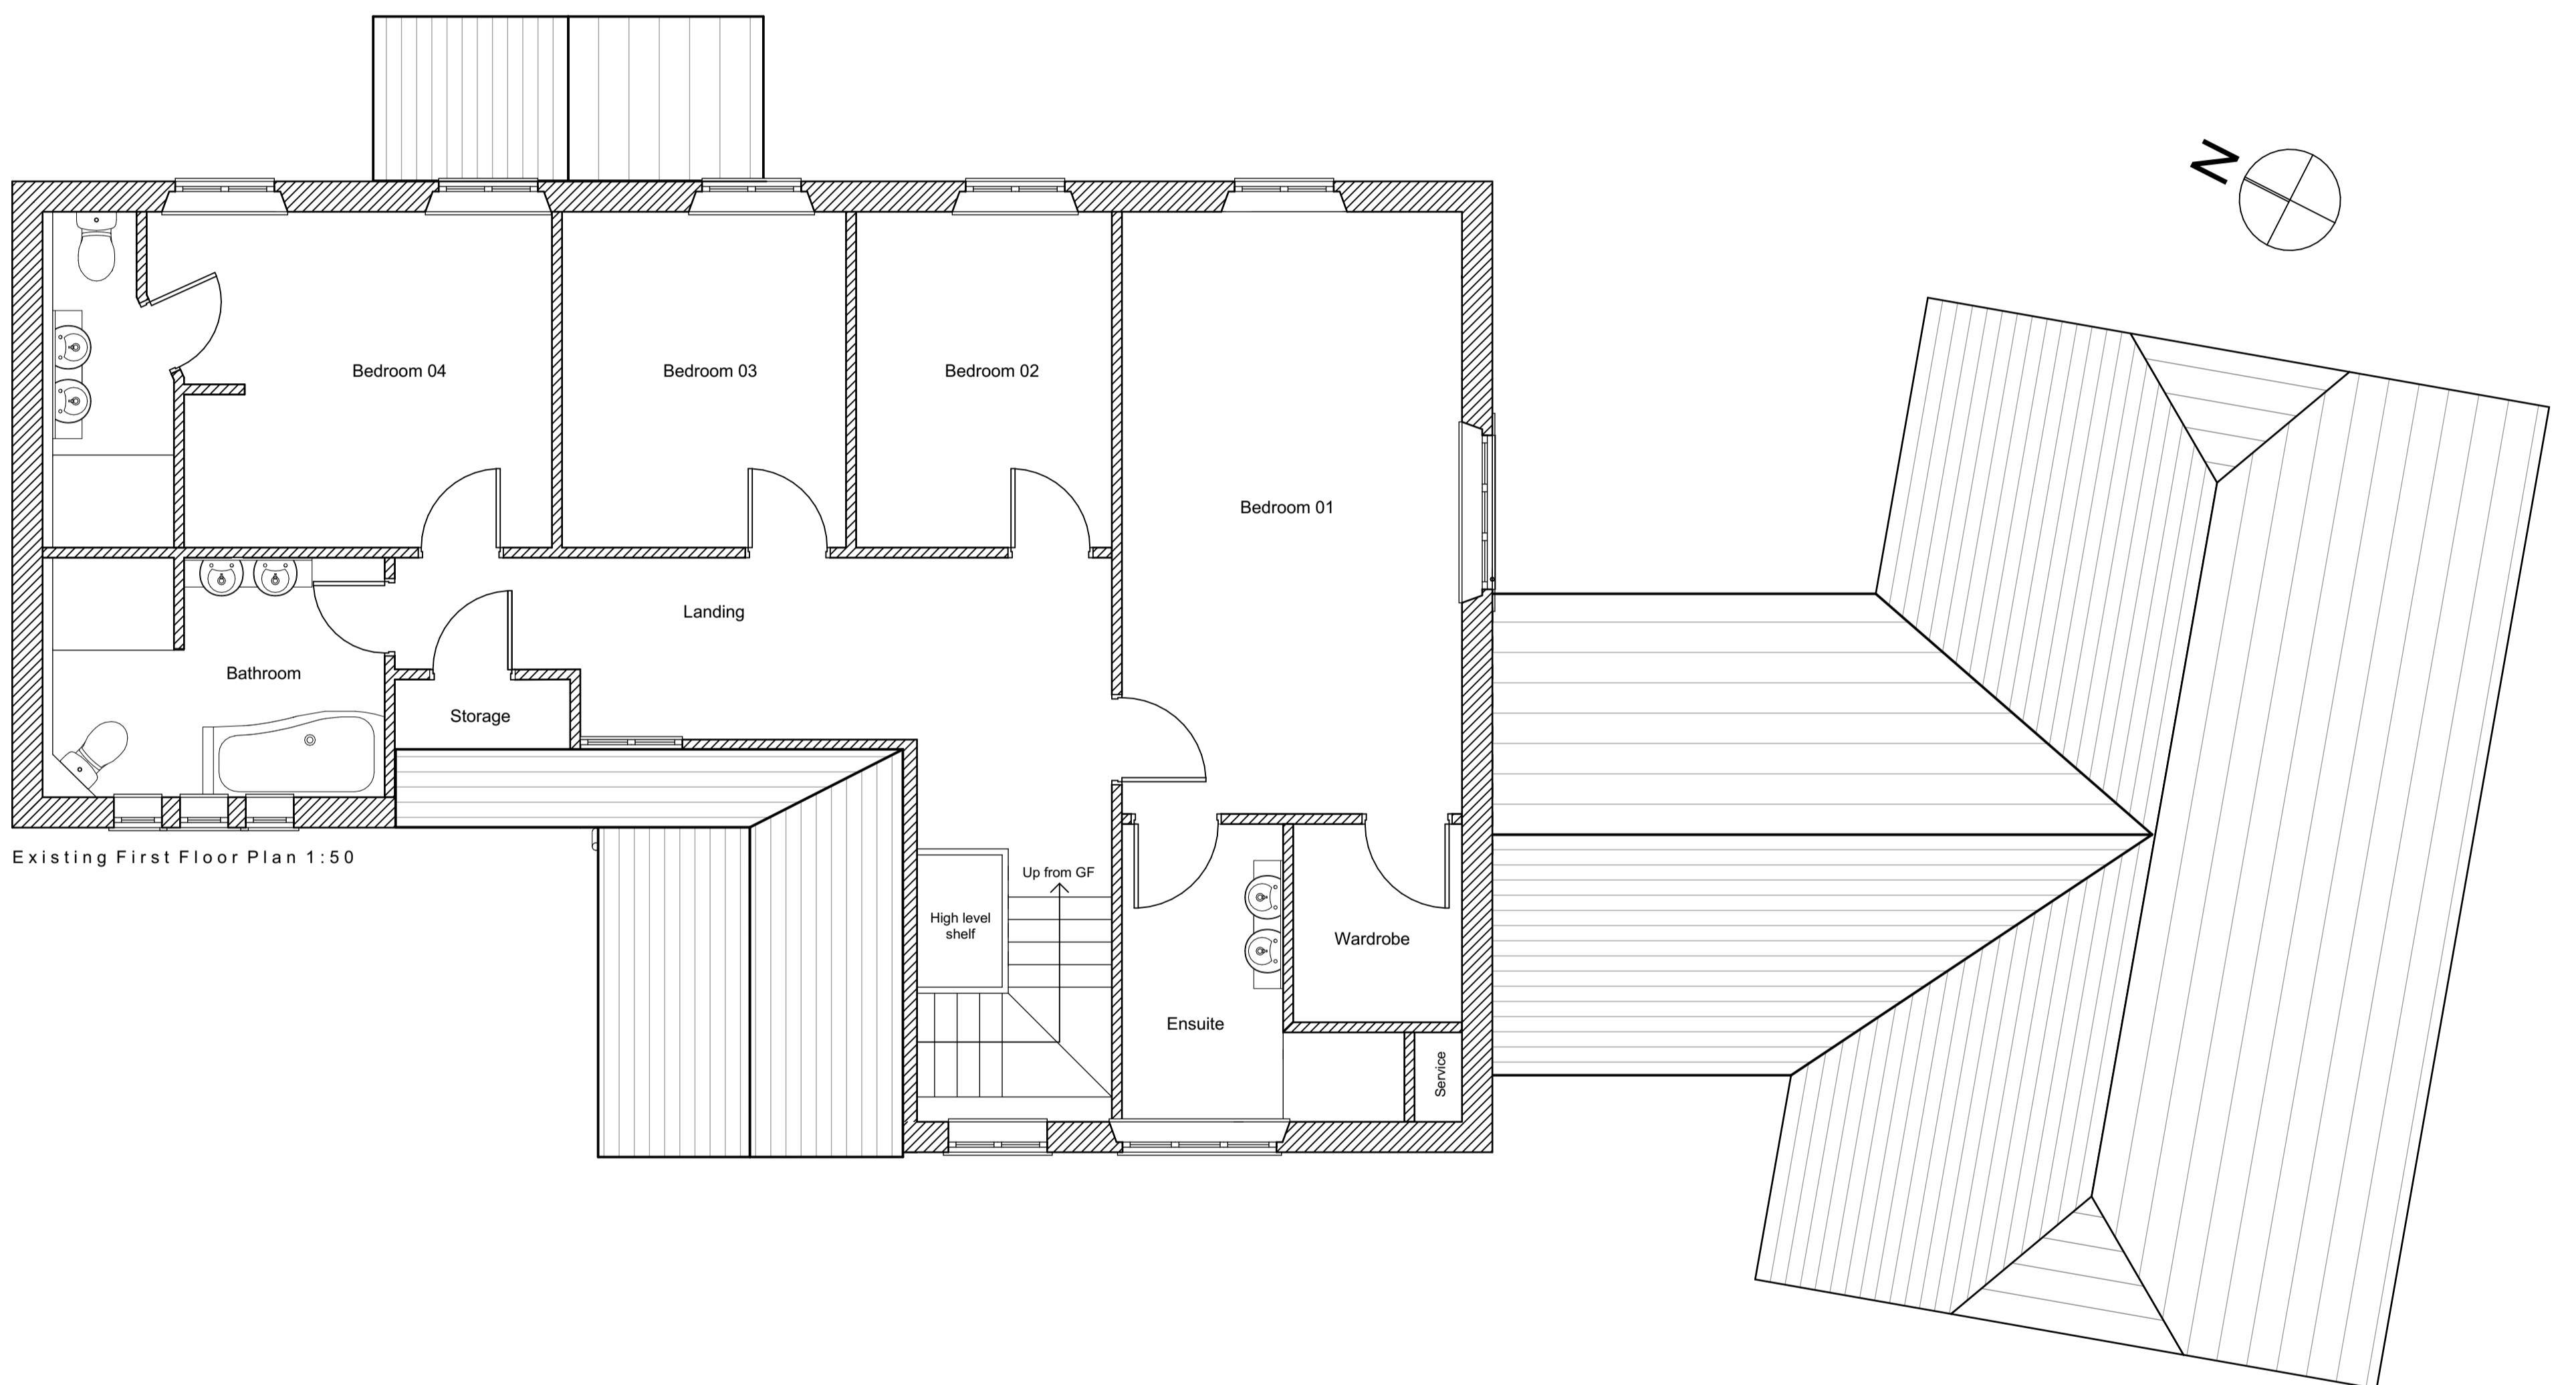


Contractor must verify all dimensions on site before commencing any work or shop drawings. If this drawing exceeds the quantities taken in any way, the building designers are to be informed before the work is initiated. Only figured dimensions to be taken from this drawing. Do not scale off this drawing. Drawing based on Ordnance Survey and/or existing record drawings - design and drawing content subject to Site Survey, Structural Survey, Site Investigations, Planning and Statutory Requirements and Approvals. All drainage layouts are schematic and invert levels must be established prior to construction.



Project Status: PLANNING ONLY

Transform
ARCHITECTS

4 Rushmead Court, Ossett, WF5 0NZ
tel: 01924 275 594
web: www.transformarchitects.co.uk email: info@transformarchitects.co.uk

Project Address:	The Coach House, Hooklands Farm, Lewes Road, Haywards Heath, RH17 7NG
Client:	Mr & Mrs Thickett
Drawing Title:	Existing First Floor Plan A1
Scale:	1:50
Date:	04.12.2025
Drawn By:	MNB
Drawing Number:	T1290 - PL07
Revision:	Nil