


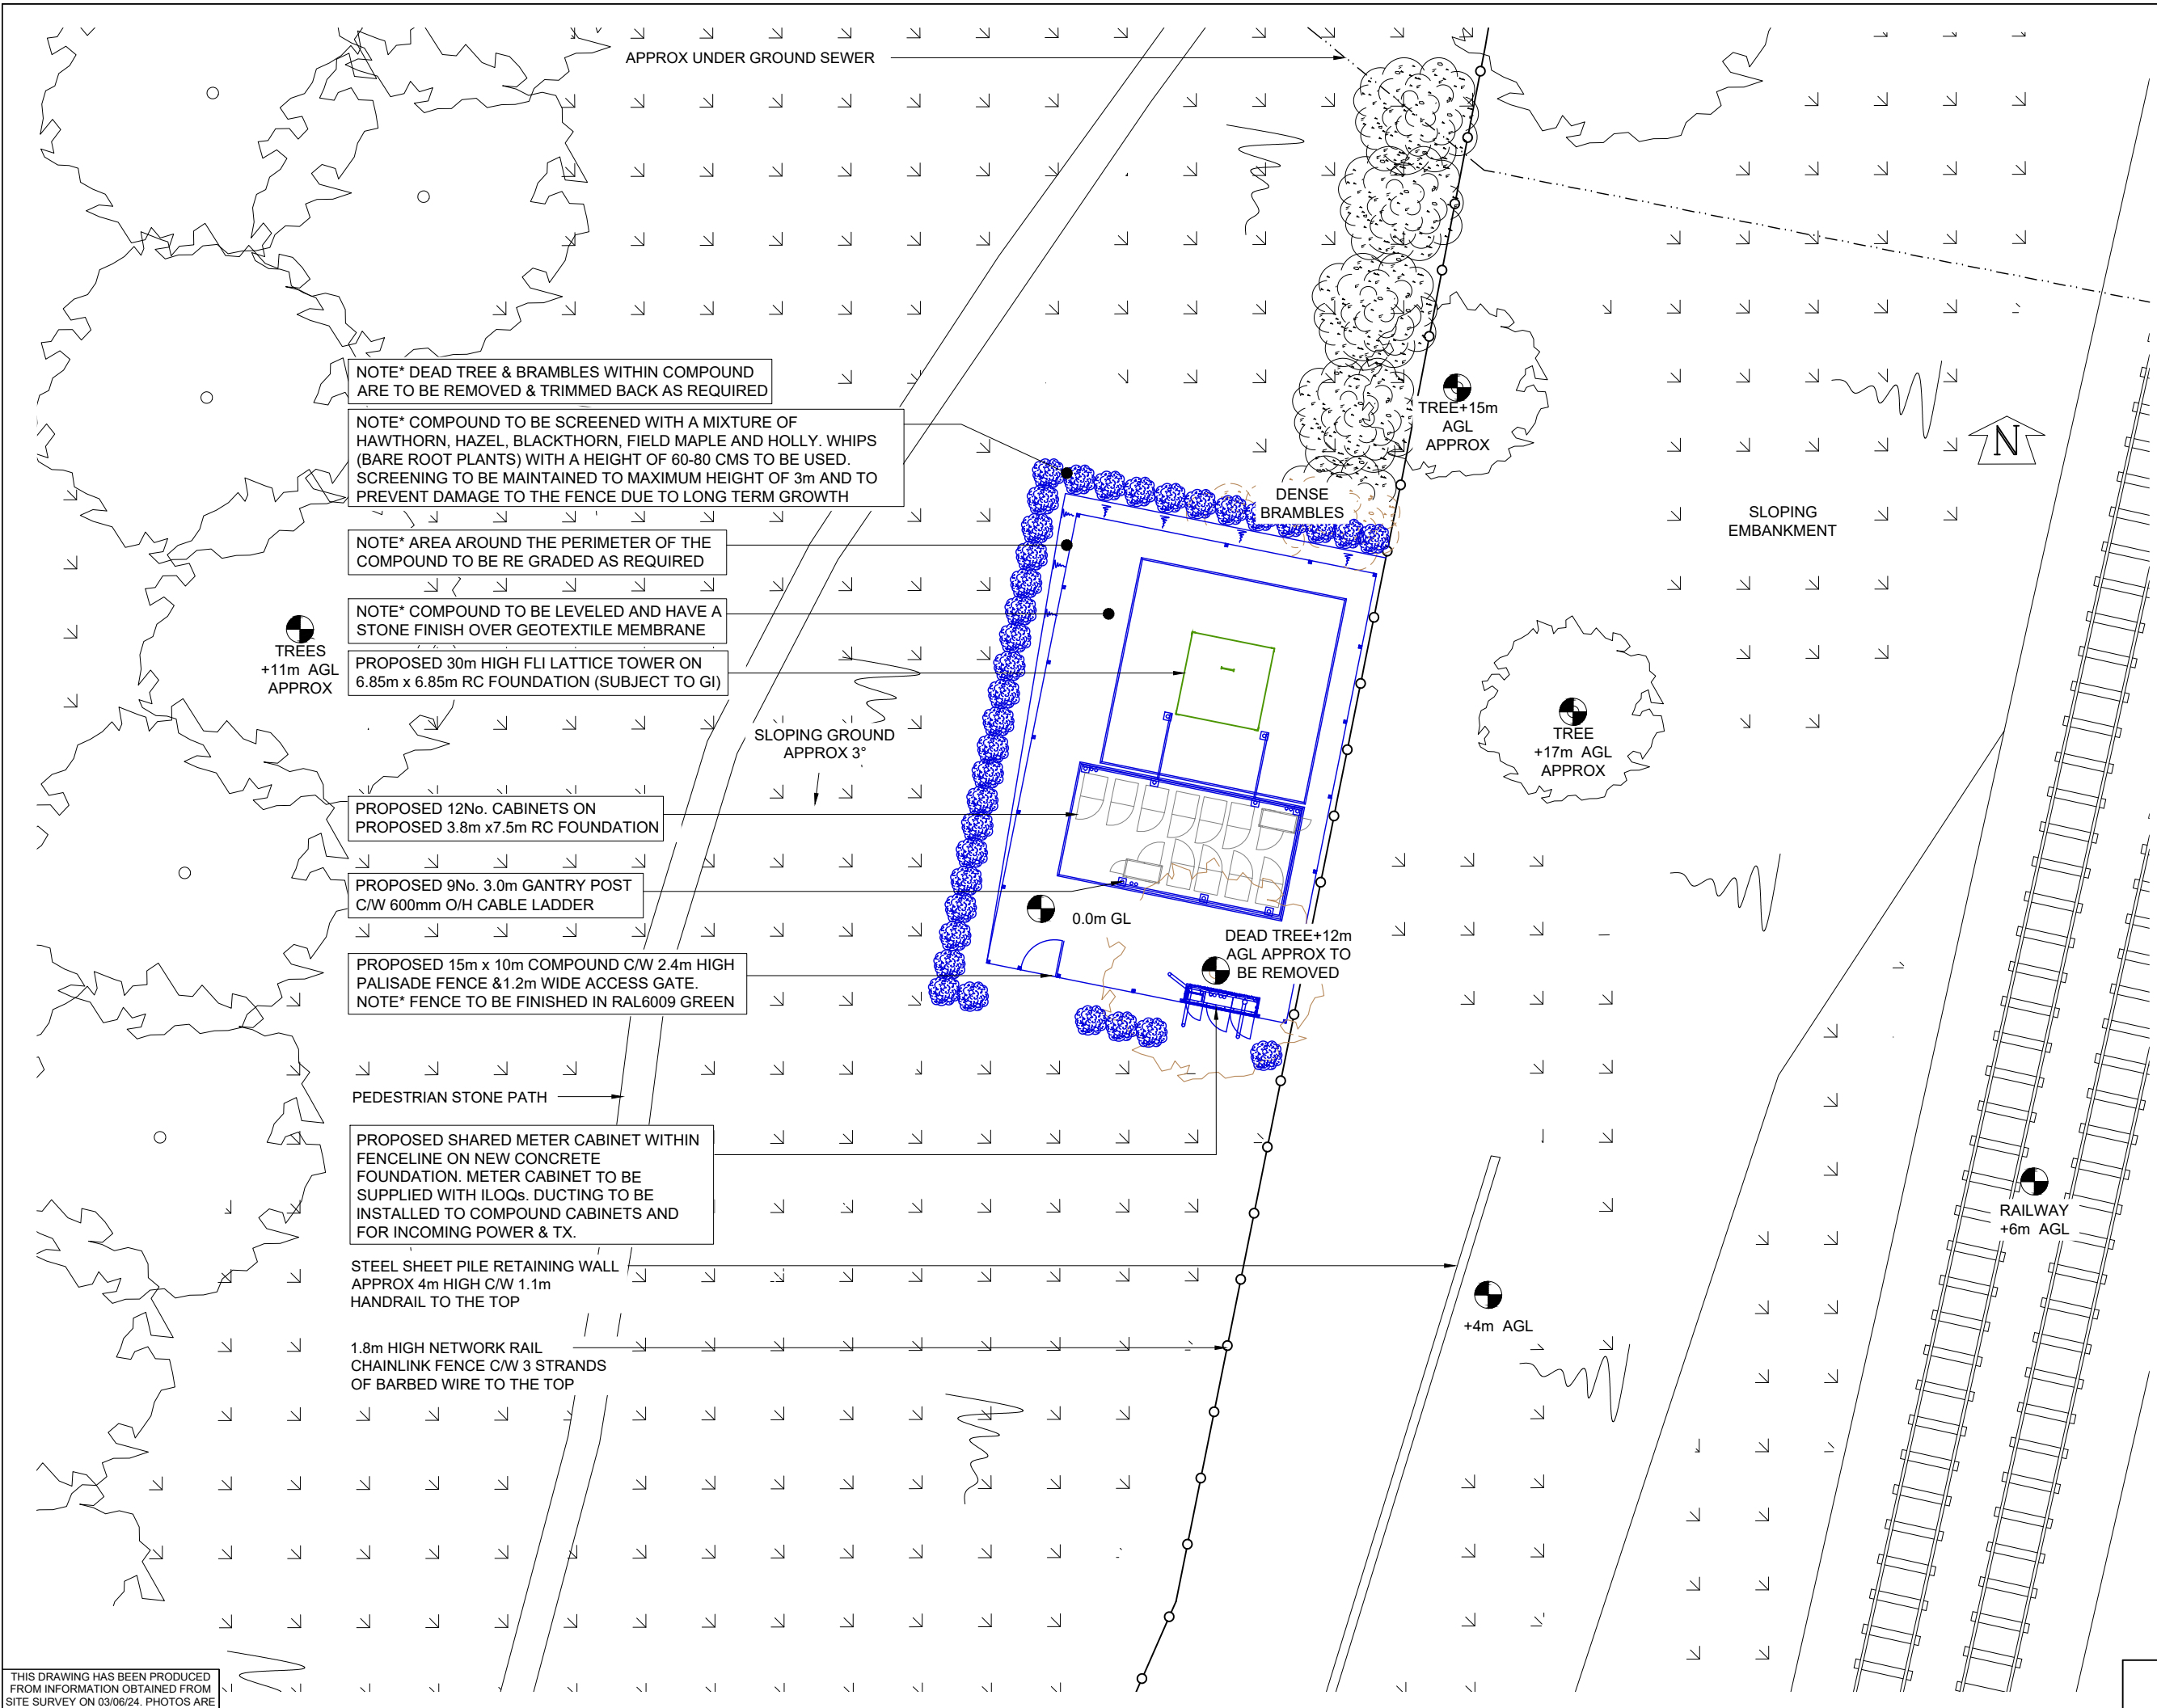

©2020 Cellnex

All rights reserved. No part of this publication may be reproduced, stored in a retrieval system or transmitted in any form or by any means (Electronic, Mechanical, Photocopying, Recording or otherwise), without the prior written consent of the Company.

NOTES

UNDERGROUND SERVICES

UNDERGROUND SERVICES ARE INDICATIVE ONLY. POSITIONS SHOULD BE CONFIRMED ON SITE PRIOR TO ANY DEVELOPMENT

DRAINAGE
DUCTS
FEEDERS
FENCE PLAN
GAS
LIGHTNING PROTECTION - EARTHING

POWER
SERVICES UNKNOWN
TELECOMS
WATER

ACCESS ARRANGEMENTS

KEYS:-

ARQIVA GATE KEY

B KEY

C KEY

LEGGE KEY

SURVEY REQUIRED TO CONFIRM ACCESS KEYS FOR REMAINING ROOMS AND SITE ENTRANCE

NOTE* CABINETS & COMPOUND FENCE TO BE FINISHED GREEN RAL6009

3.A	REDUCED HEADFRAME 2 MNO			CIR
3	ACCESS ROUTE CHANGE	14/01/25	ST	CIR
2	FENCE CHANGED	13/12/24	ST	CIR
1	PLANNING AMENDS	25/11/24	ST	CIR
ISS	REVISION	DATE	DRN	APP

cellnex
driving telecom connectivity

CELLNEX UK
R4, 4TH FLOOR, 2 BLA GRAVE STREET, READING, RG1 1AZ
Tel. 020 4526 8553

SITE No **S5-13A**

LAND TO THE NORTH OF LEYLAND GRANGE CLOSE

WORLD'S END

BURGESS HILL

WEST SUSSEX

RH15 0RZ

NGR **TQ 32106 20277**

OS GRID **532106,120277**

TITLE
**SITE PLAN
PROPOSED
BML**

SCALE **1:200**

DRAWN	KG	20/06/24
APPROVED	CIR	14/01/25

DRG No. **S5-13A-00-001-MD003**

Sheet 1 of 1

Rev **3.A**

THIS DRAWING HAS BEEN PRODUCED FROM INFORMATION OBTAINED FROM SITE SURVEY ON 03/06/24. PHOTOS ARE AVAILABLE.

A3