



 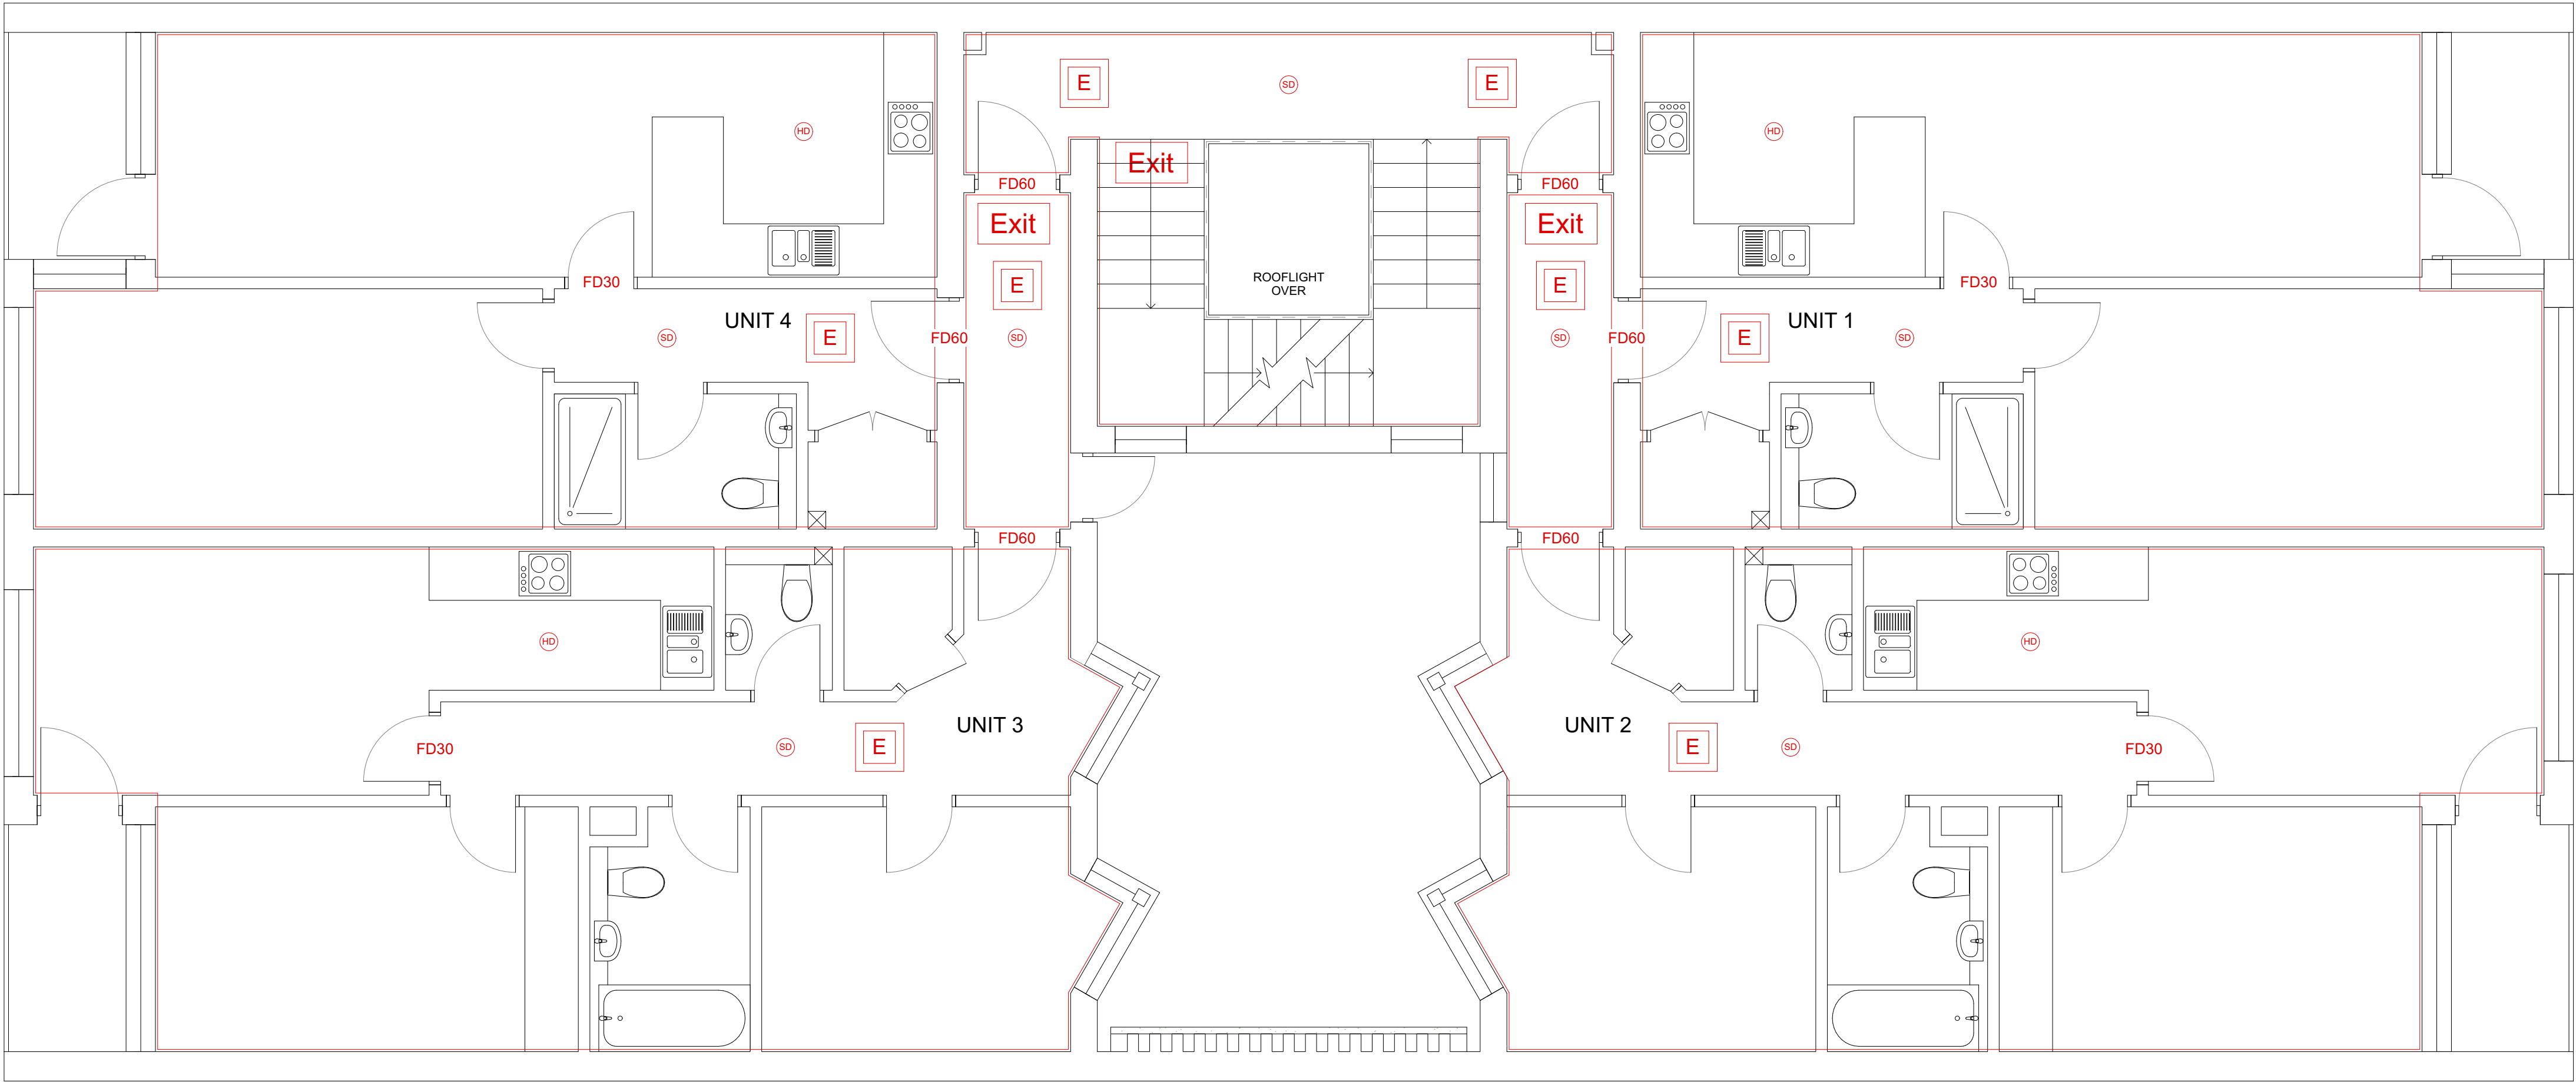


- E** Emergency version of light fitting
- 1 hour fire separation**
- FD30** 30 minutes fire door
- FD60** 60 minutes fire door
- Exit** Fire Exit signs: Illuminate / photoluminescent + emergency lighting
- SD** Smoke Detector
- HD** Heat Detector

Proposed First Floor Plan 1:50

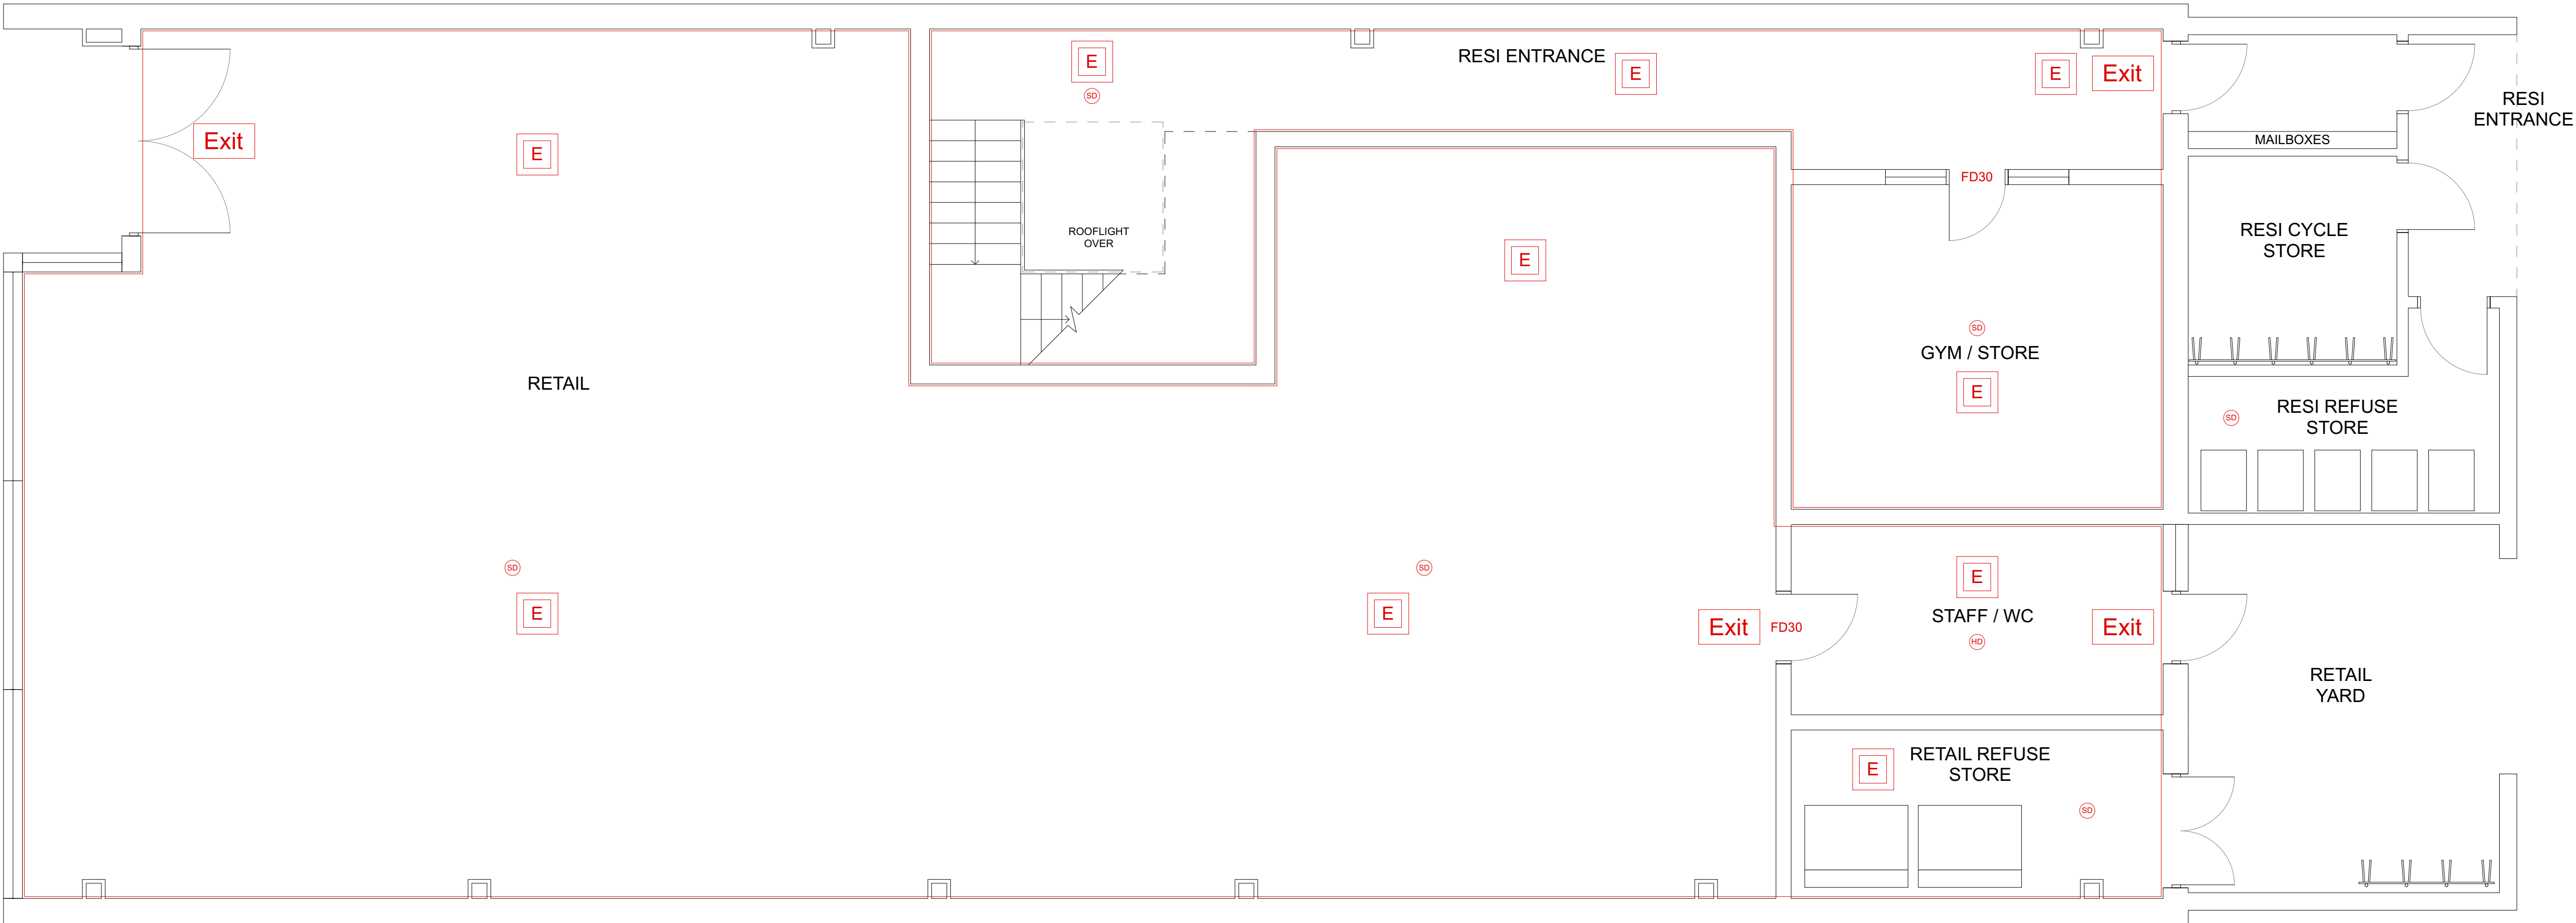

Proposed Ground Floor Plan 1:50



SURVEY DRAWING		
NOTES: - © Copyright of this drawing remains the property of Buchan Rum Architects Ltd and should not be reproduced in full or parts or re-issued without written permission from Buchan Rum Architects Ltd - These drawings must be read in conjunction with the structural engineers drawings & details, and with all other consultants, sub-contractor and specialist's drawings & details. - All dimensions are in millimetres, unless stated otherwise. - All goods materials workmanship to conform with current building regulations BBS and COP's. - All dimensions must be checked on site, and any discrepancies verified with the architect. - Do not scale from the drawing. - Any discrepancies between the drawings, details and specification must be reported to the architect immediately before work is put in hand. - All works to be carried out in full accordance with current Building Regulations, British Standards and all Health & Safety Regulations. - If in doubt please ask.		
REV	DATE	COMMENT
Client		
Site address		
68-70 Church Walk Burgess Hill		
Job Title		
M&Co		
Drawing Title		
PROPOSED GROUND & FIRST FLOOR FIRE STRATEGY PLANS		
buchan rum 9 SAVILL ROAD LINDFIELD WEST SUSSEX RH162NY E : info@buchanrumarchitects.co.uk		
Scale	Size	
1:50	A1	
Date	Dn By	
06/2023	BRA	
Drawing number:	Rev.	
PL_500_00	04	