


Existing Site Location Plan 1:1250

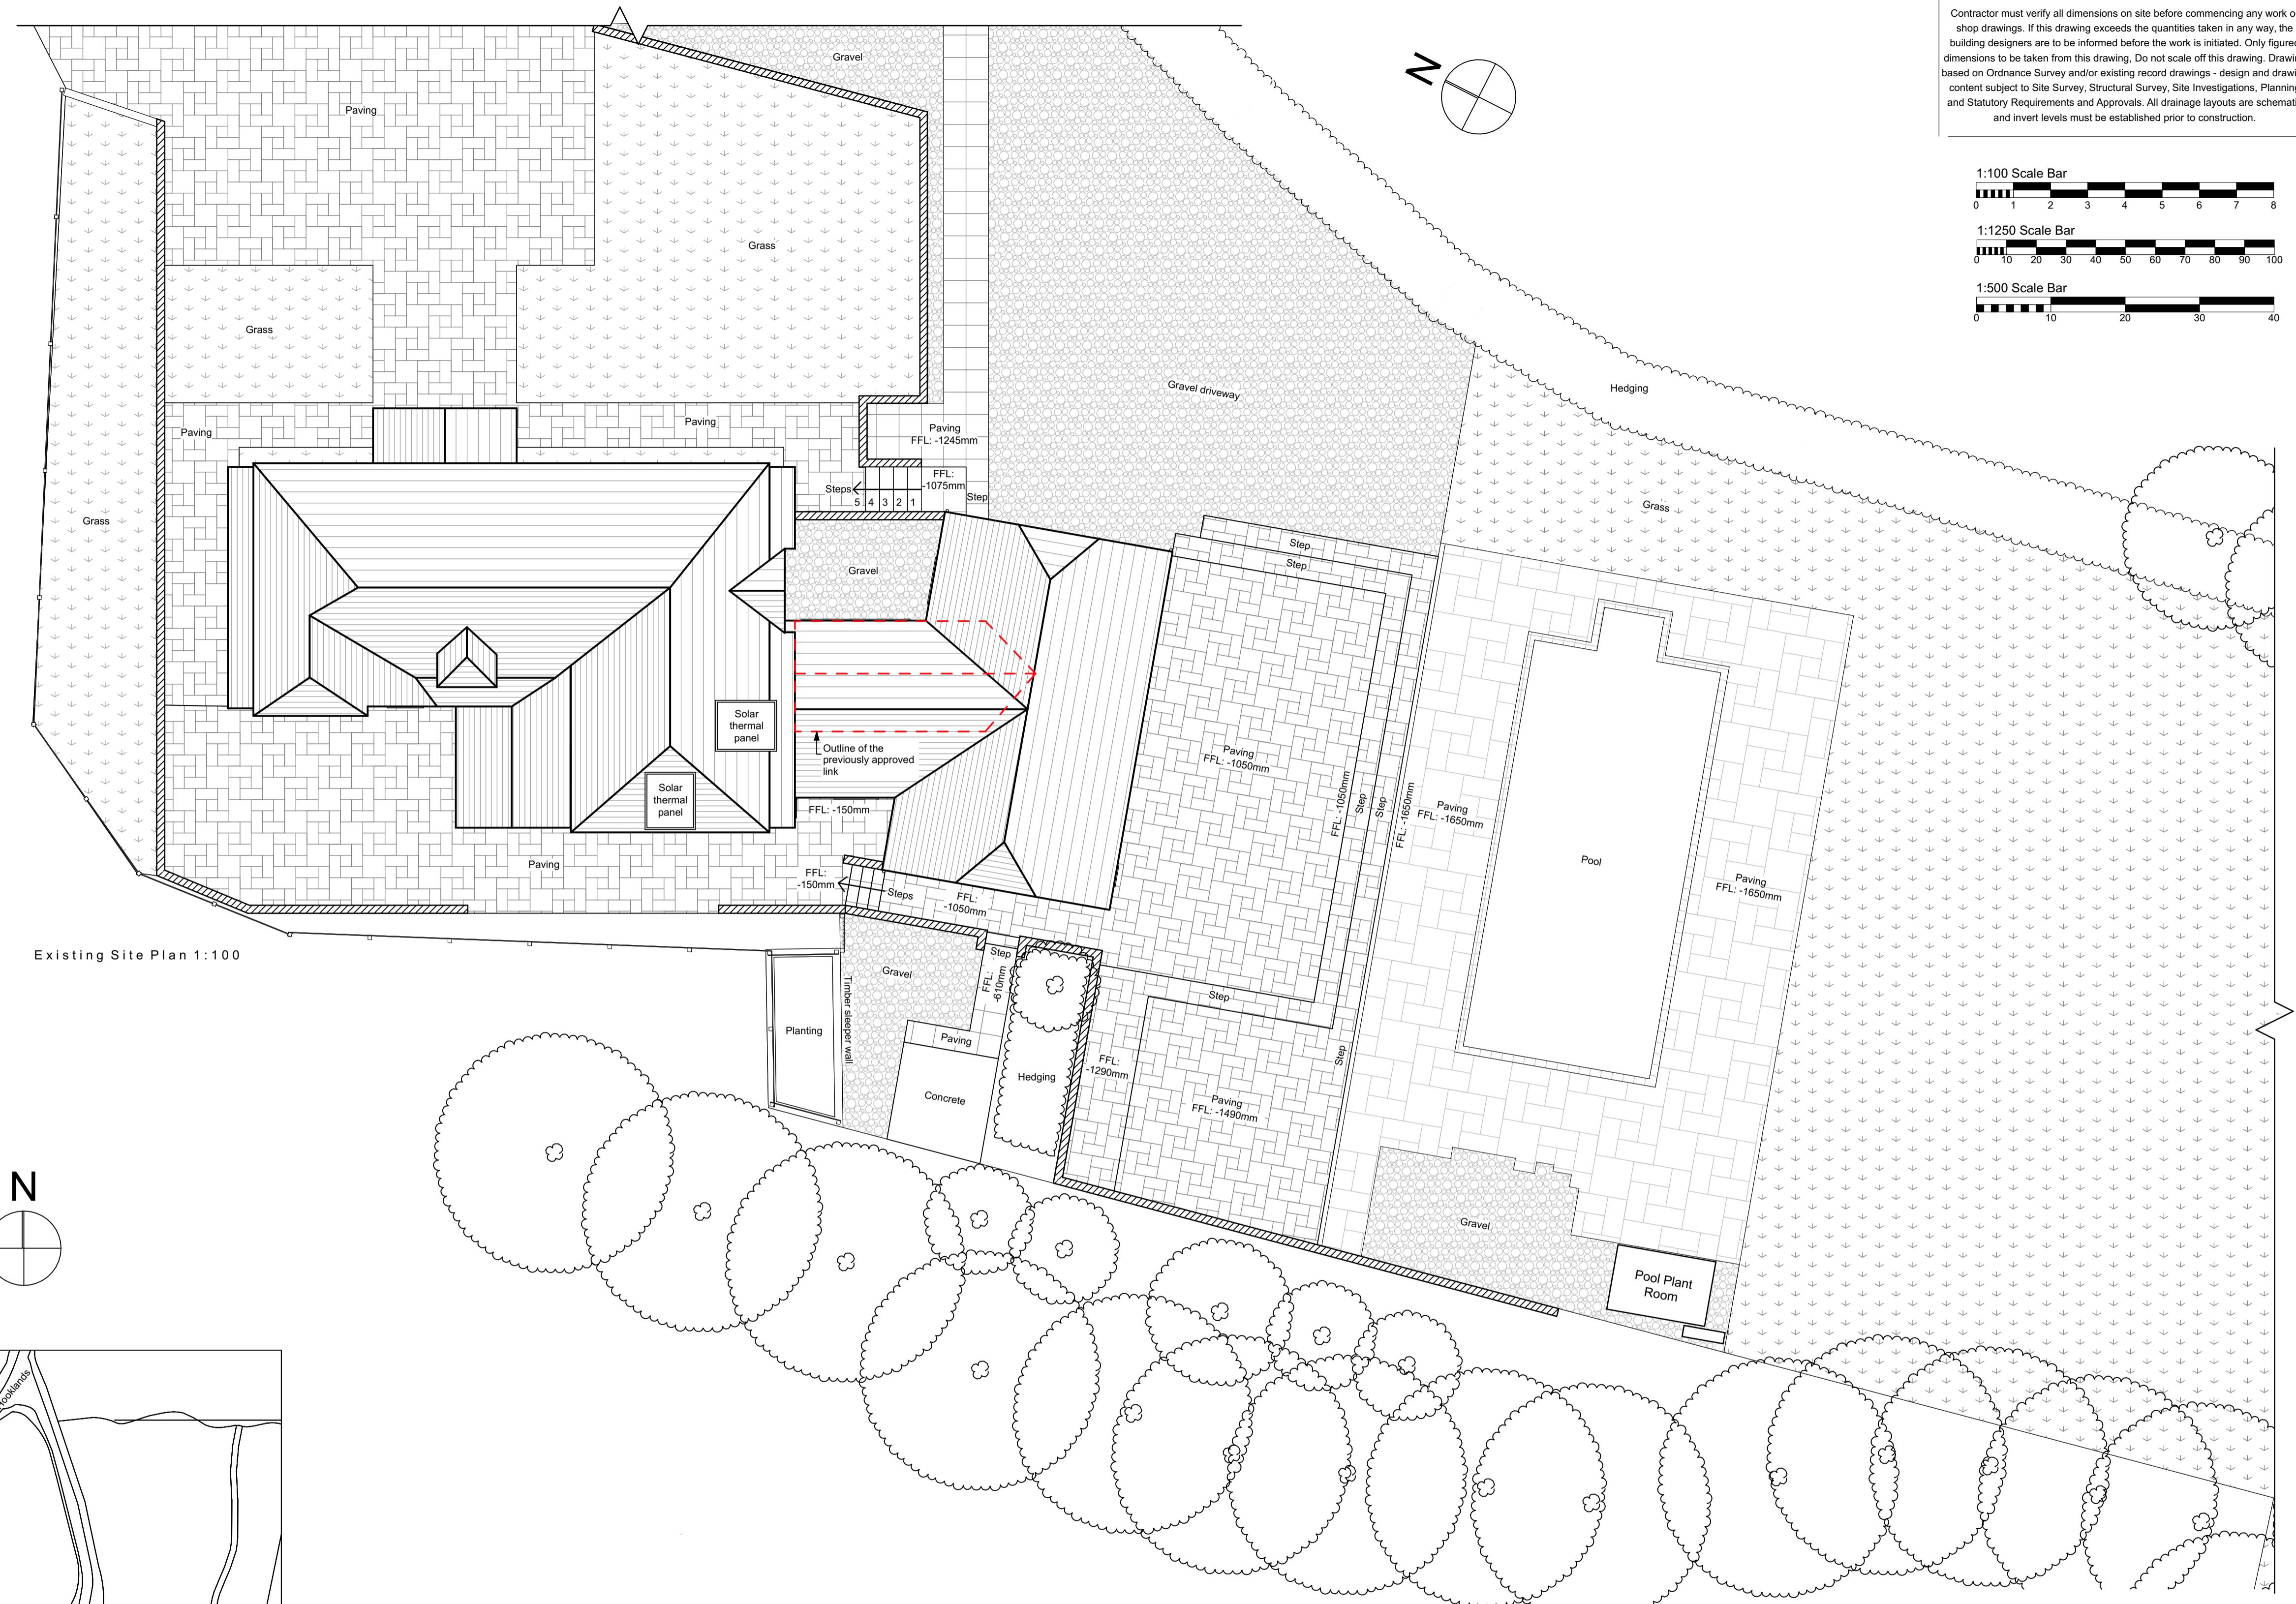

Contractor must verify all dimensions on site before commencing any work or shop drawings. If this drawing exceeds the quantities taken in any way, the building designers are to be informed before the work is initiated. Only figured dimensions to be taken from this drawing. Do not scale off this drawing. Drawing based on Ordnance Survey and/or existing record drawings - design and drawing content subject to Site Survey, Structural Survey, Site Investigations, Planning and Statutory Requirements and Approvals. All drainage layouts are schematic and invert levels must be established prior to construction.

1:100 Scale Bar

0 1 2 3 4 5 6 7 8

1:1250 Scale Bar

0 10 20 30 40 50 60 70 80 90 100

1:500 Scale Bar

0 10 20 30 40

Project Status: PLANNING ONLY

Transform
ARCHITECTS

4 Rushmead Court, Ossett, WF5 0NZ
tel: 01924 275 594
web: www.transformarchitects.co.uk email: info@transformarchitects.co.uk

Project Address: The Coach House, Hocklands Farm, Lewes Road, Haywards Heath, RH17 7NG

Client: Mr & Mrs Thickett

Drawing Title: Existing Site Plan A1

Scale: 1:100, 1:1250, 1:500
Date: 24.11.2025

Drawn By: MNB

Drawing Number: T1290 - PL01

Revision: Nil