

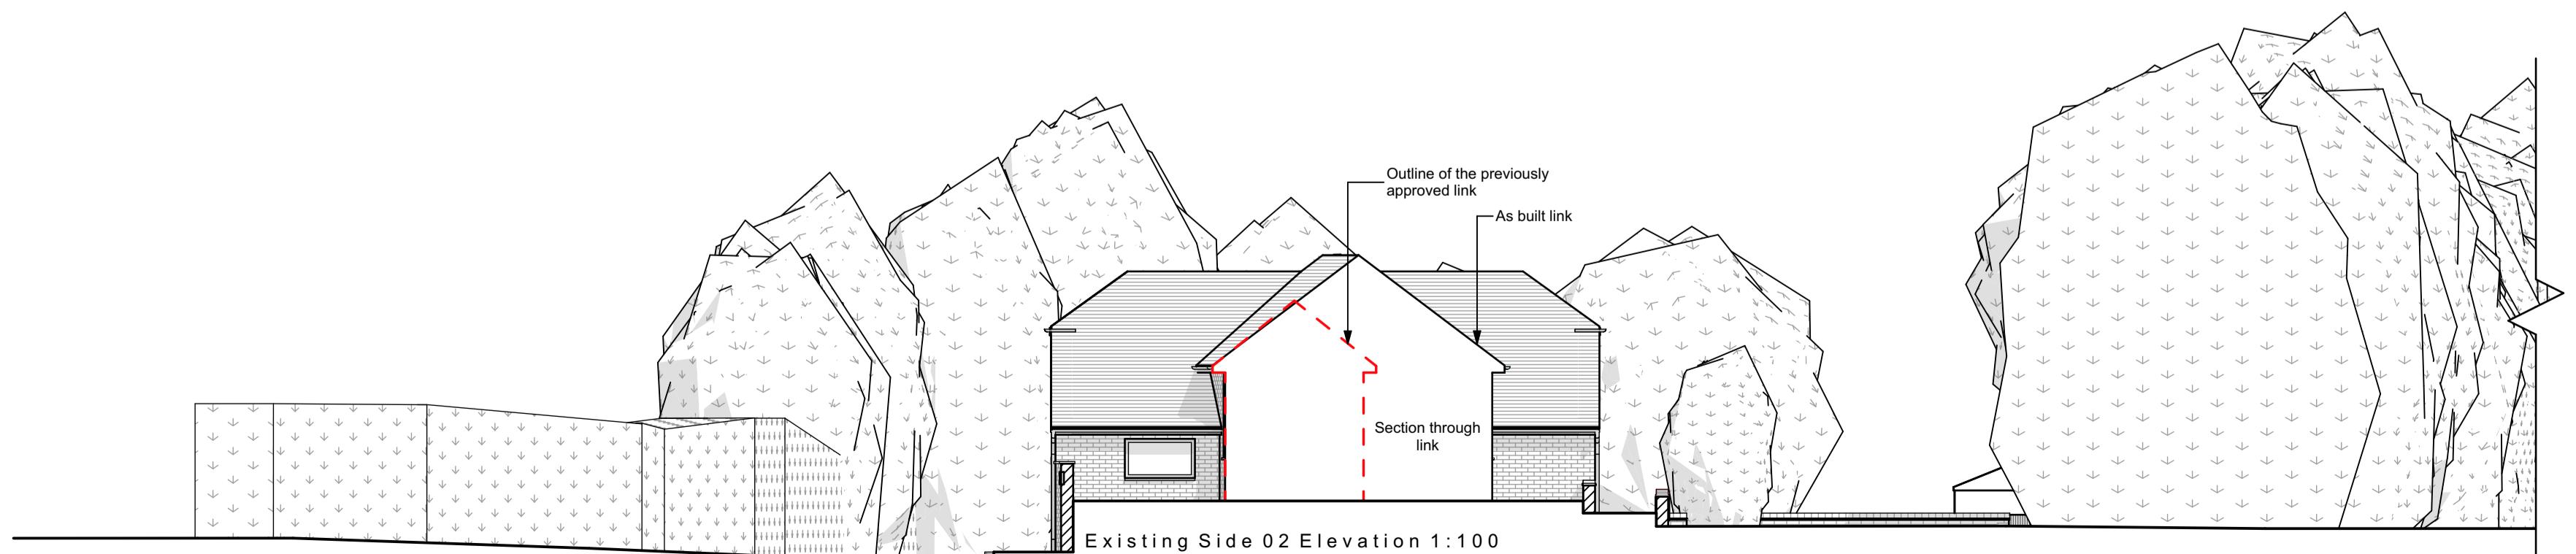
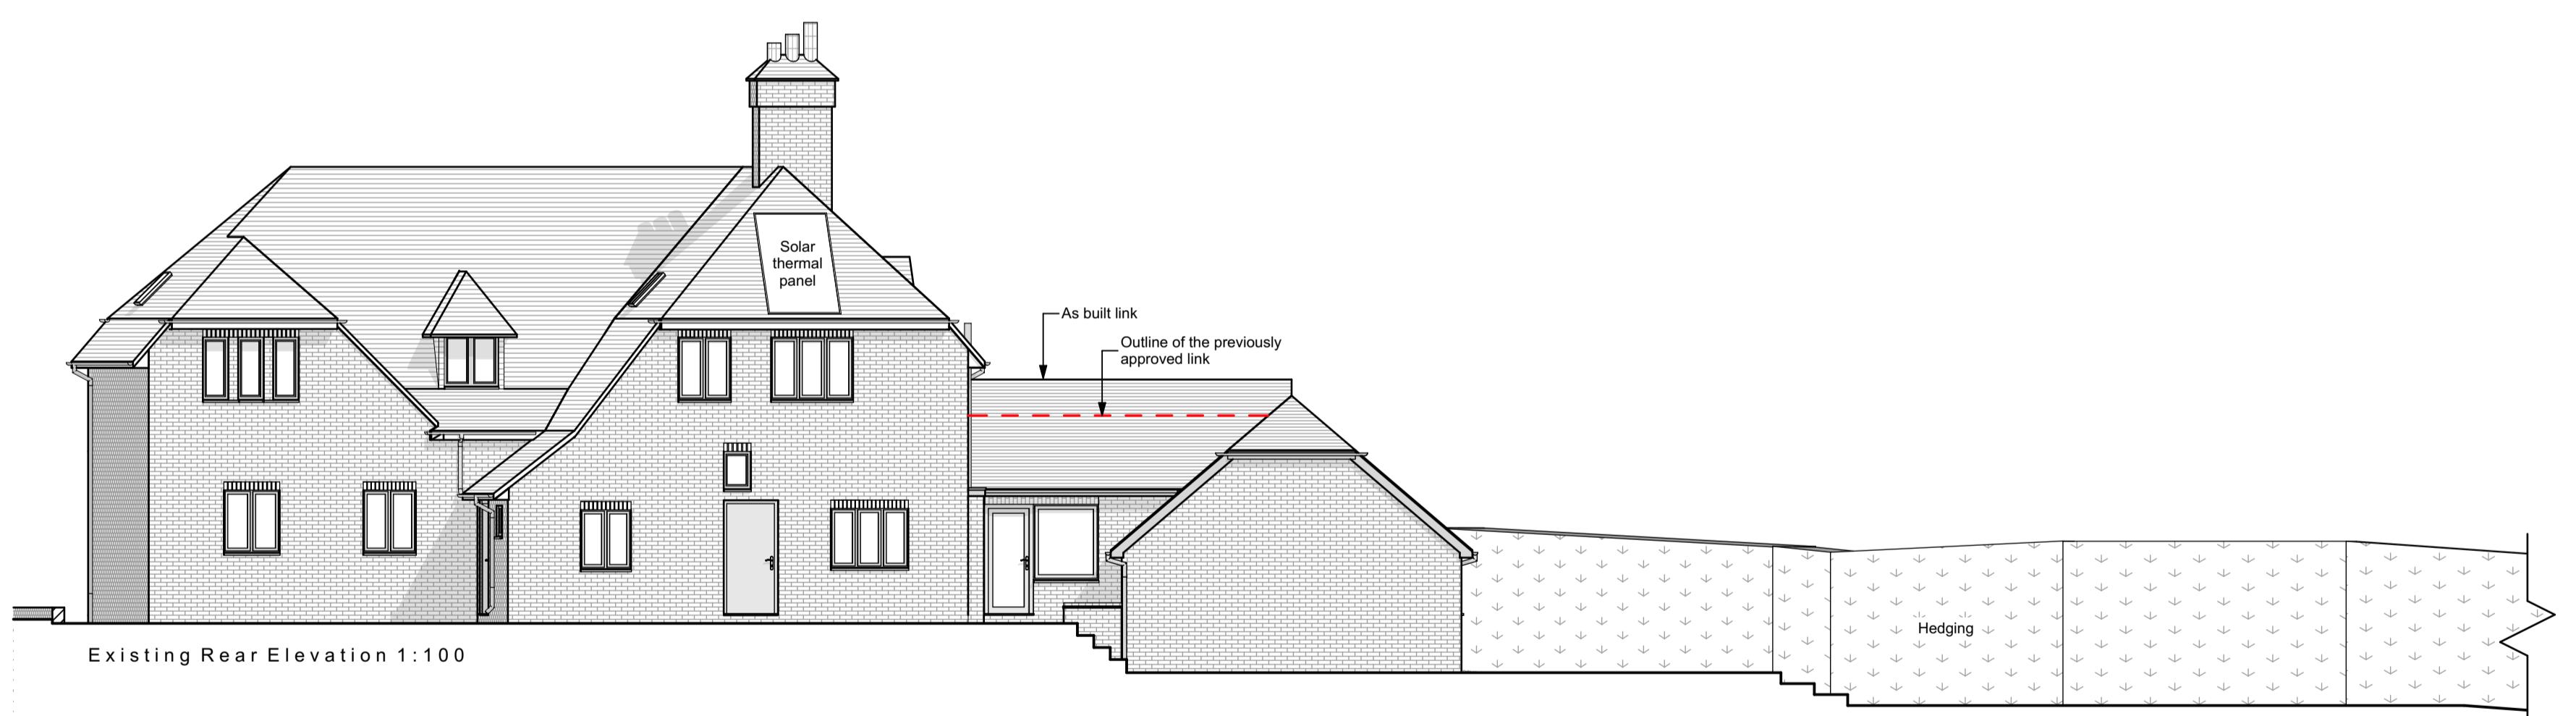


Contractor must verify all dimensions on site before commencing any work or shop drawings. If this drawing exceeds the quantities taken in any way, the building designers are to be informed before the work is initiated. Only figured dimensions to be taken from this drawing. Do not scale off this drawing. Drawing based on Ordnance Survey and/or existing record drawings - design and drawing content subject to Site Survey, Structural Survey, Site Investigations, Planning and Statutory Requirements and Approvals. All drainage layouts are schematic and invert levels must be established prior to construction.

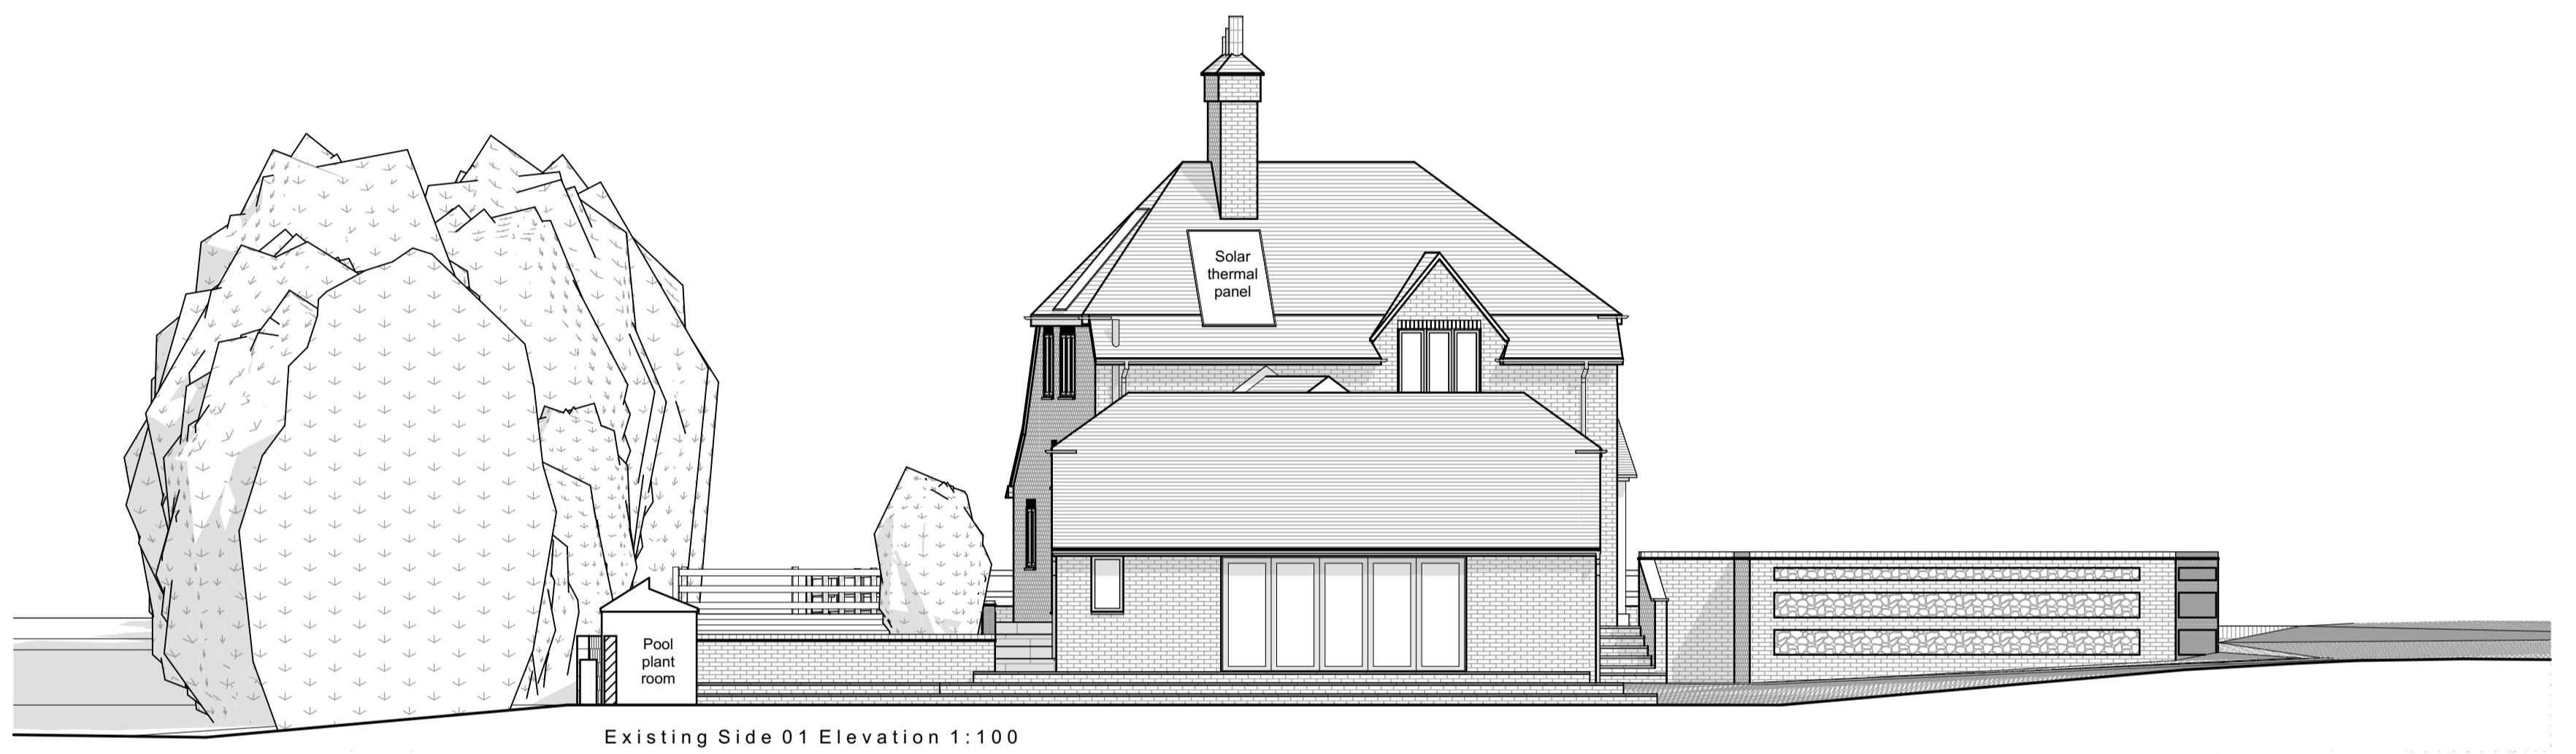

Elevation Material Key:	
	Brown Brickwork.
	Flint Stonework.
	Red Roof Tiles.

Note:
All black fascias and soffits.
All black gutters and downpipes.
All black windows and doors,
Unless otherwise stated.

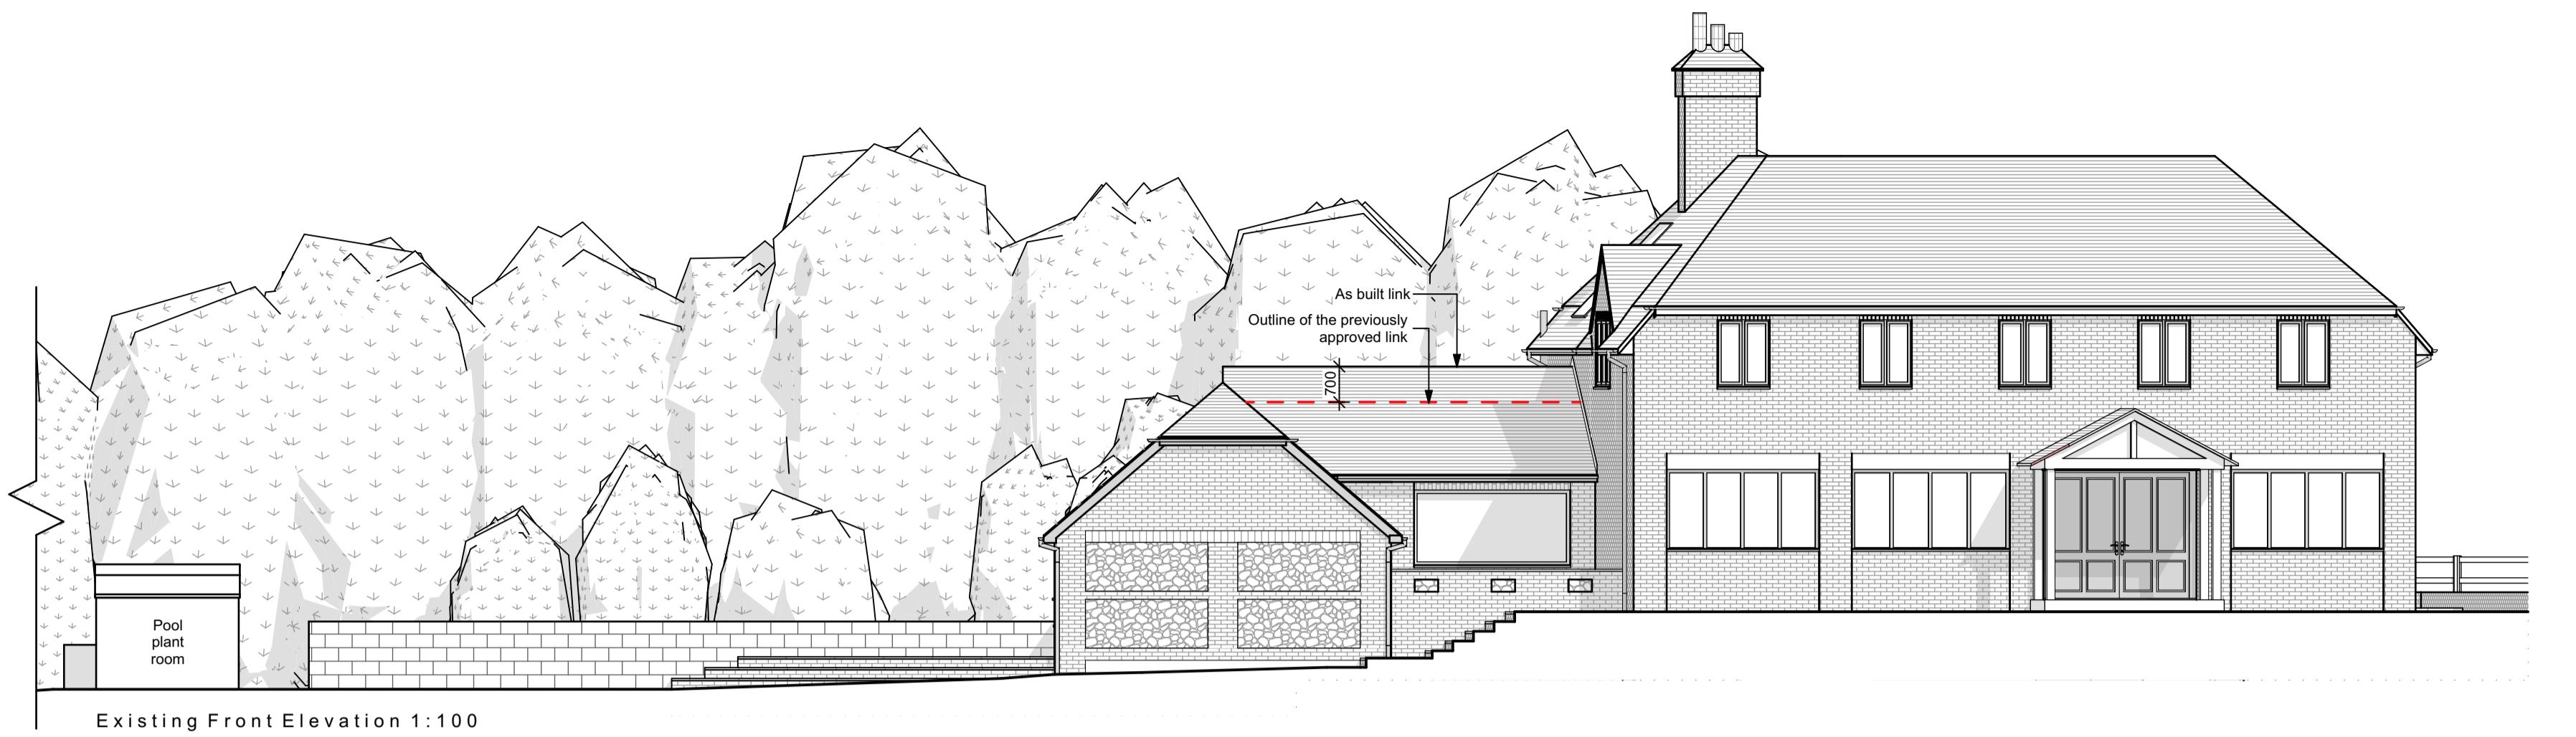

Project Status: PLANNING ONLY

Transform
ARCHITECTS

4 Rushmead Court, Ossett, WF5 0NZ
tel: 01924 275 594
web: www.transformarchitects.co.uk email: info@transformarchitects.co.uk

Project Address:	The Coach House, Hooklands Farm, Lewes Road, Haywards Heath, RH17 7NG
Client:	Mr & Mrs Thickett
Drawing Title:	Existing E elevations A1
Scale:	1:100
Date:	24.11.2025
Drawn By:	MNB
Drawing Number:	T1290 - PL03
Revision:	Nil