


Contractor must verify all dimensions on site before commencing any work or shop drawings. If this drawing exceeds the quantities taken in any way, the building designers are to be informed before the work is initiated. Only figured dimensions to be taken from this drawing, Do not scale off this drawing. Drawing based on Ordnance Survey and/or existing record drawings - design and drawing content subject to Site Survey, Structural Survey, Site Investigations, Planning and Statutory Requirements and Approvals. All drainage layouts are schematic and invert levels must be established prior to construction.

1:50 Scale Bar

A scale bar with a total length of 4 units. The first unit is divided into 10 smaller segments, with the first 9 labeled '1' and the last labeled '2'. The remaining 3 units are each divided into 5 smaller segments, with the first 4 labeled '3' and the last labeled '4'. The first segment of each unit is black, while the others are white. The text '1:50 Scale Bar' is positioned above the scale bar.

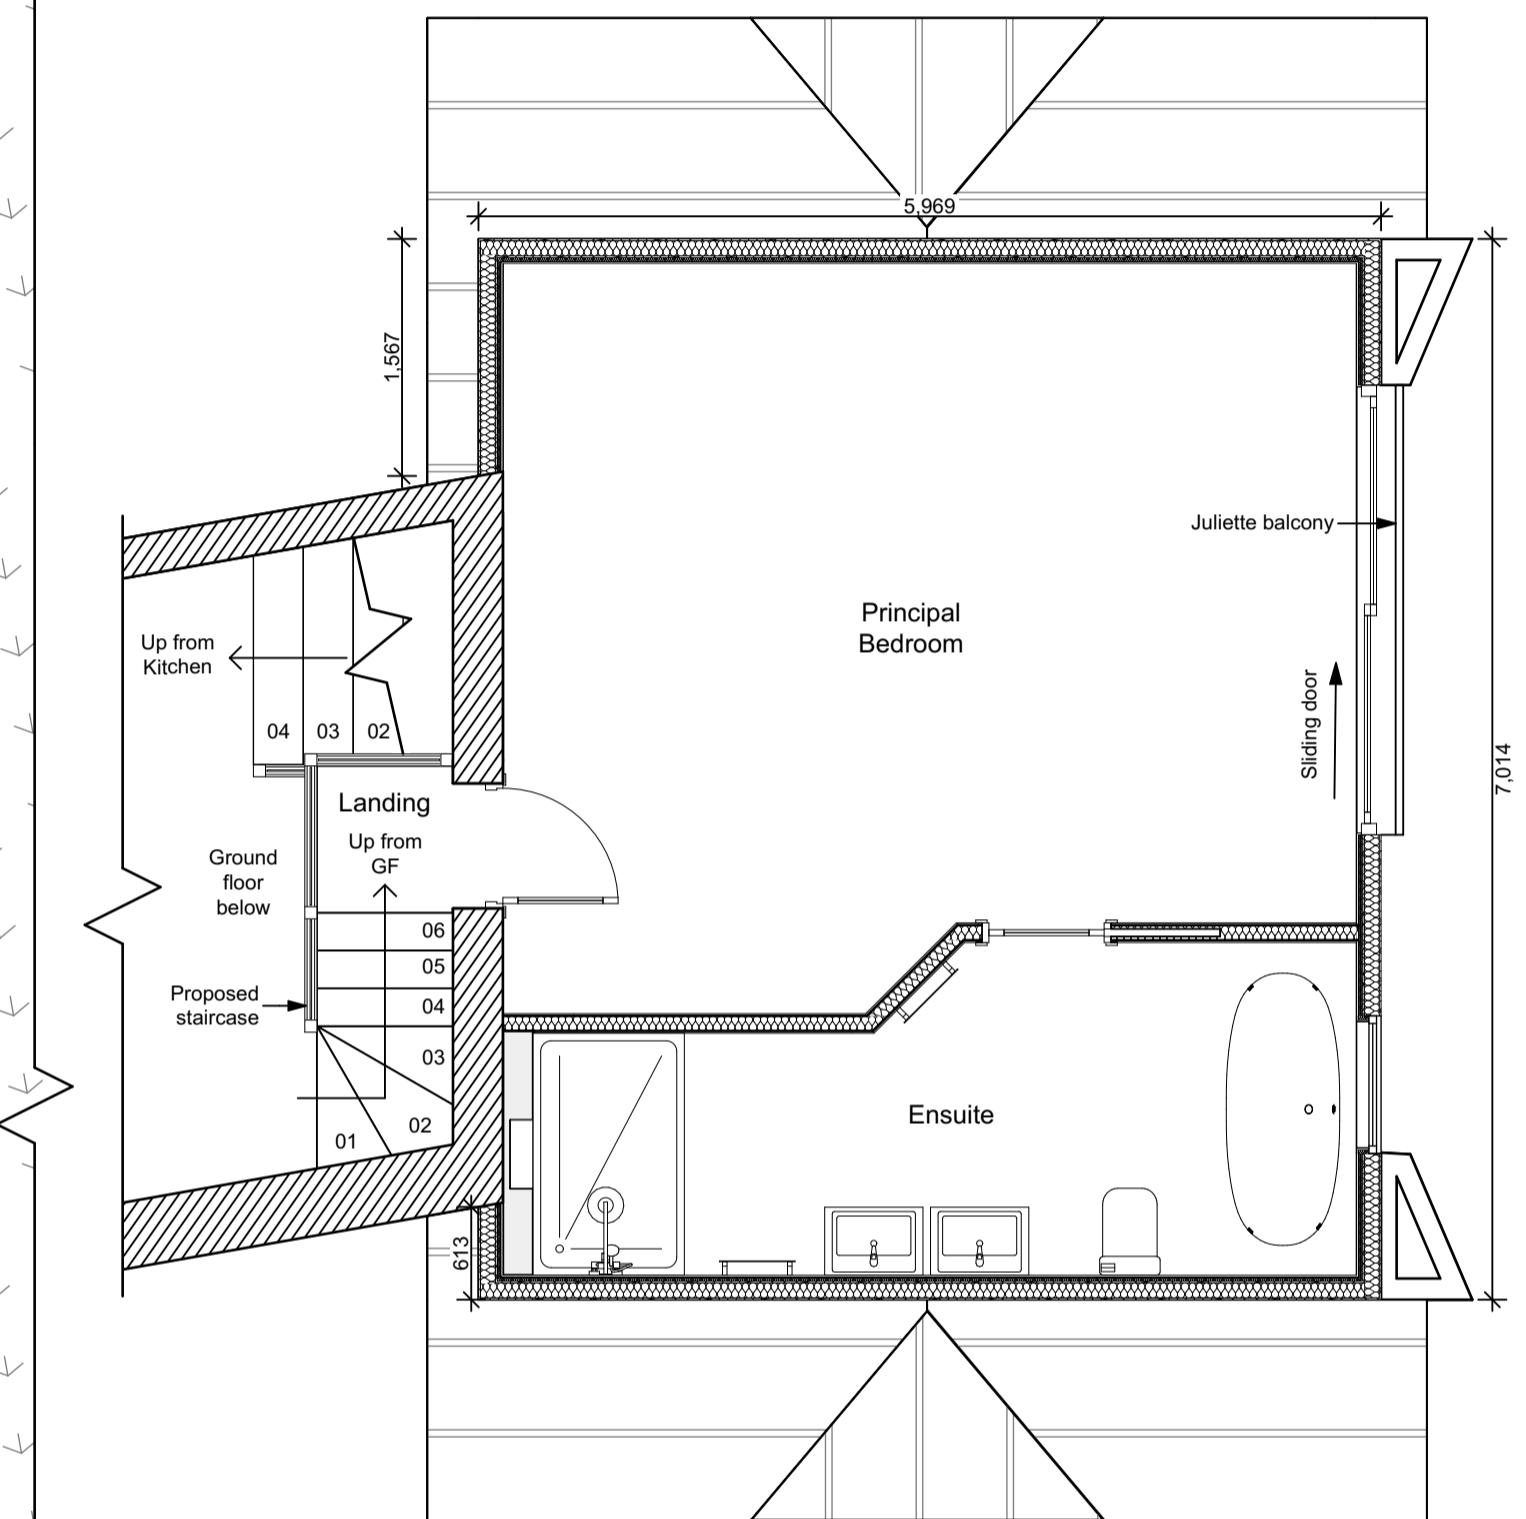

Proposed First Floor Dormer Extension Plan 1:50

Project Status: **PLANNING ONLY**

4 Rushmead Court, Ossett, WF5 0NZ
tel: 01924 275 594

4 Rushmead Court, Ossett, WF5 0NZ
tel: 01924 275 594
web: www.transformarchitects.co.uk email: info@transformarchitects.co.uk

Project Address:	The Coach House, Hooklands Farm, Lewes Road, Haywards Heath, RH17 7NG
Client:	Mr & Mrs Thickett
Drawing Title:	Proposed Floor Plans A1
Scale:	1:50
Date:	24.11.2025
Drawn By:	MNB
Drawing Number:	T1290 - PL05
Revision:	Nil