


• THIS DOCUMENT IS COPYRIGHT OF THE ORIGINATOR AND MUST BE TREATED AS CONFIDENTIAL.
• THIS DOCUMENT MUST NOT BE ALTERED, REPRODUCED OR DISTRIBUTED WITHOUT PRIOR WRITTEN CONSENT OF THE ORIGINATOR.
• DO NOT SCALE THIS DOCUMENT. ALL DIMENSIONS MUST BE CHECKED ON SITE PRIOR TO COMMENCEMENT OF ANY RELATED WORKS.
• THIS DOCUMENT MUST BE READ IN CONJUNCTION WITH ALL SUPPORTING DOCUMENTS PRODUCED BY THE ORIGINATOR.
• USERS OF THIS DOCUMENT ARE RESPONSIBLE FOR CHECKING WHICH REVISION IS CURRENT.

Notes & Symbols:

KEY	
	Single switched socket
	Twin switched socket
	CAT6 data outlet. Number represents gangs
	Floor box - 2 x DSSO, 4 x CAT6 data
	Switched fused spur
	20A single phase isolator
	32A three phase isolator
	Fan isolator
	Distribution board
	Wireless access point

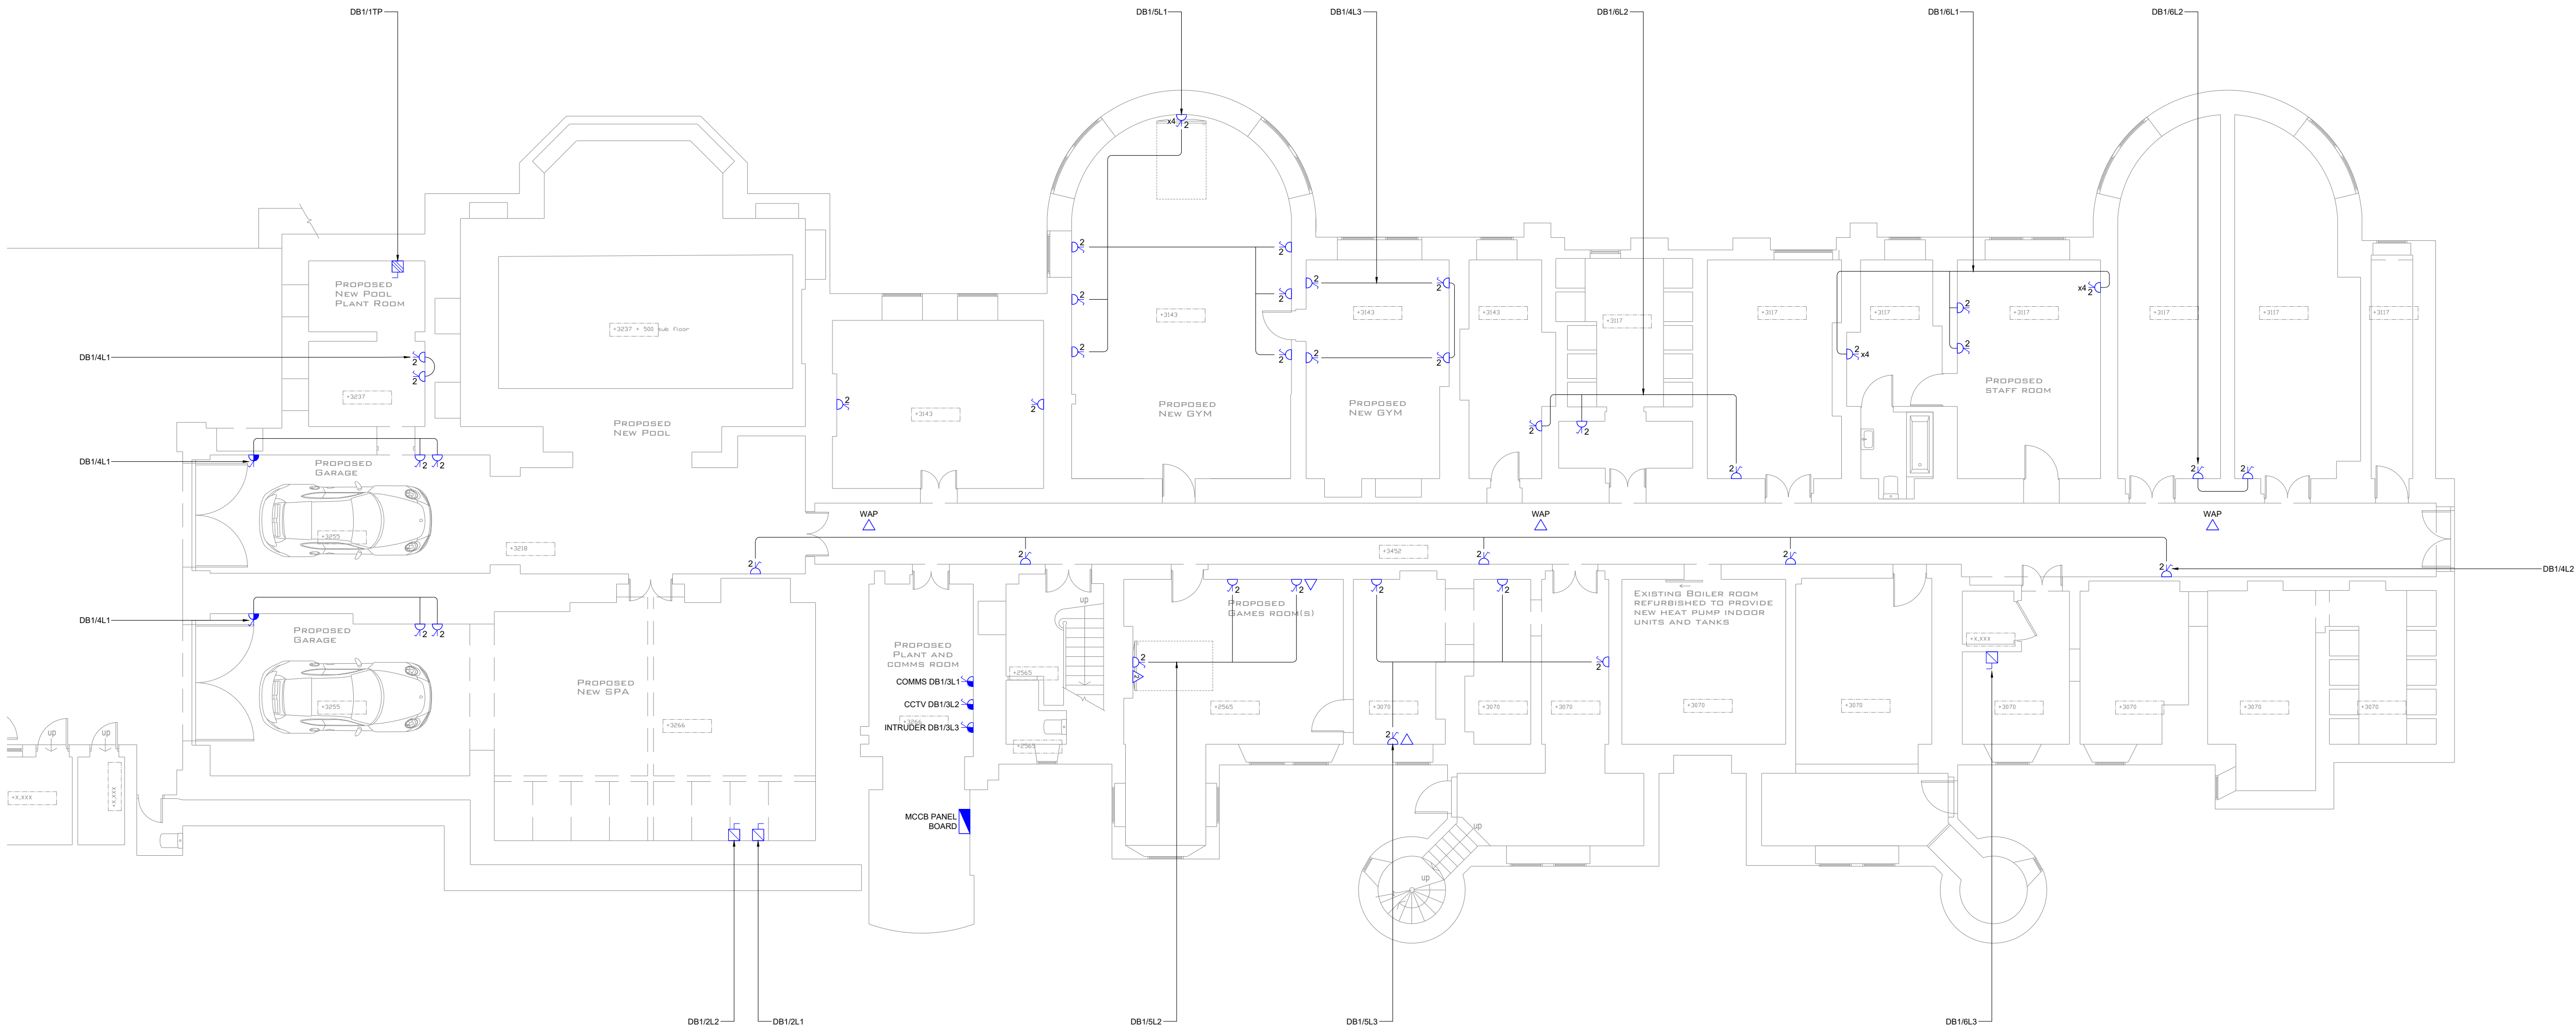

Rev.	Date.	Description.
------	-------	--------------



Project:
WYKEHURST PLACE

Drawing Title:
BASEMENT
SMALL POWER LAYOUT

Scale: 1:100@A1	Date: 14/04/25
--------------------	-------------------

Drawing Status:
PROPOSED

Drawing No. 02	Revision:
-------------------	-----------