


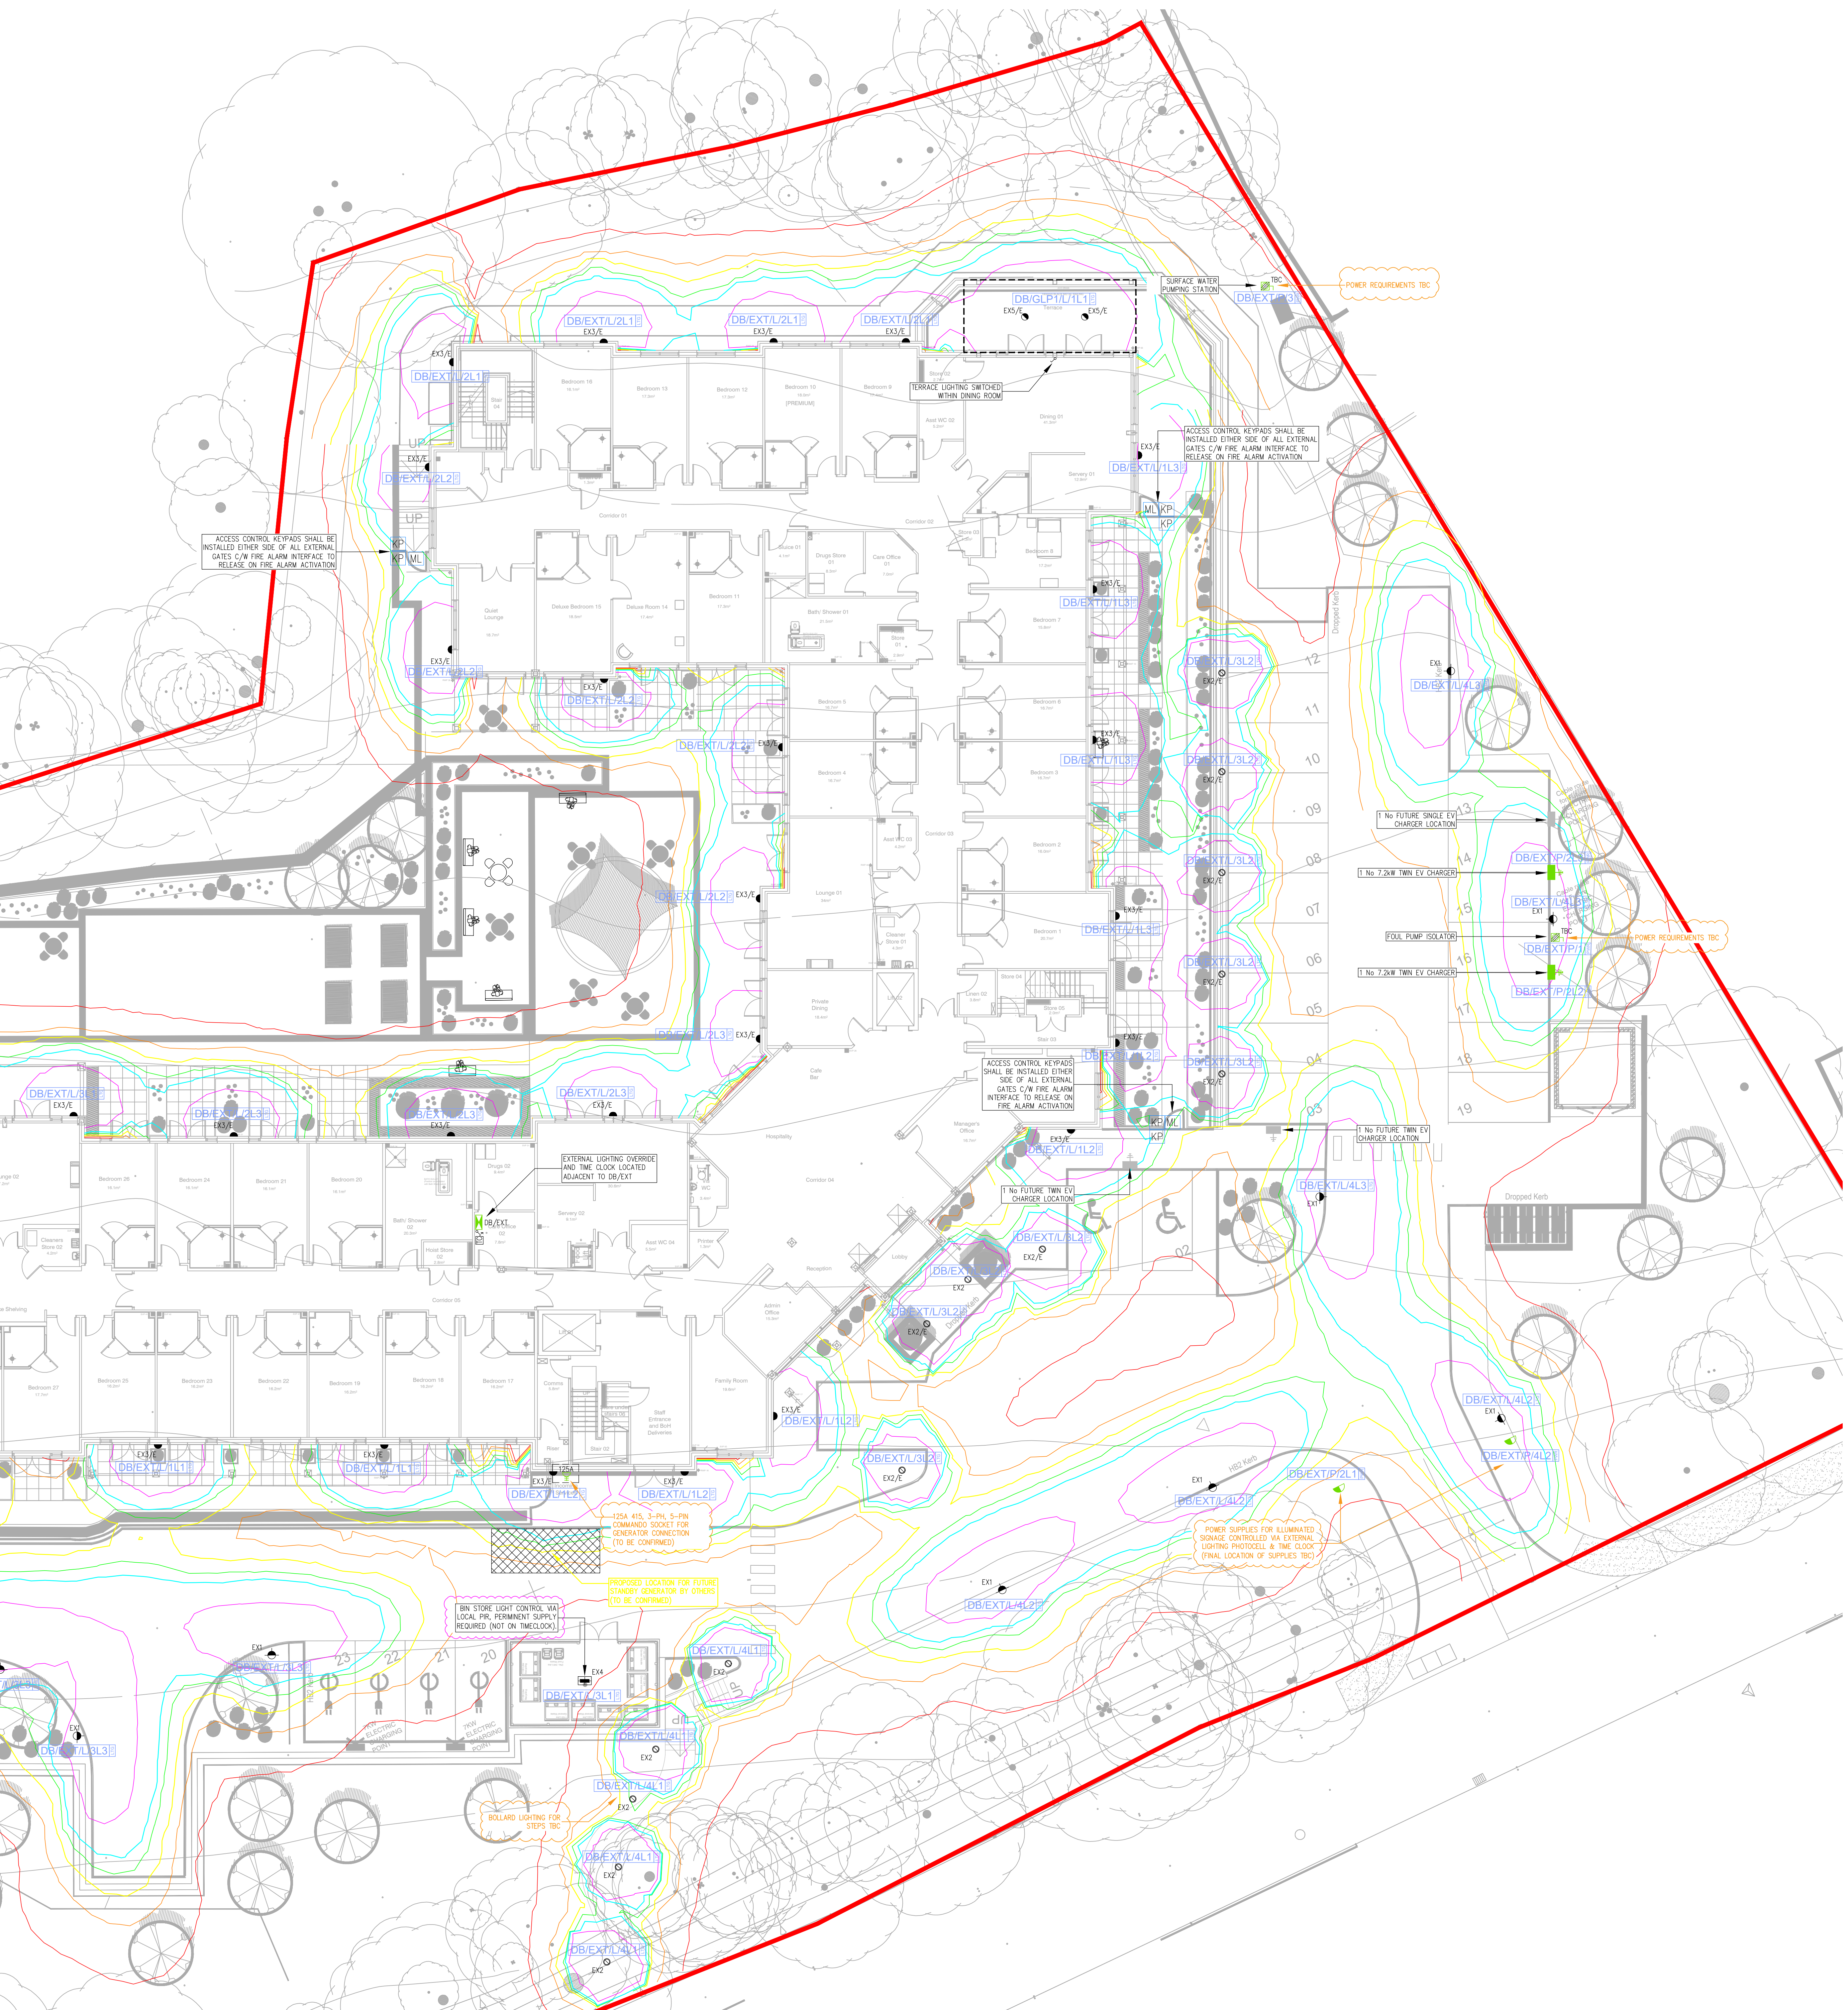

- NOTES
1. THIS DRAWING ILLUSTRATES OUTLINE DESIGN INTENT ONLY AND IS SUBJECT TO DESIGN DEVELOPMENT & COORDINATION.
 2. THIS DRAWING IS NOT TO BE SCALED.
 3. ALL DIMENSIONS STATED IN mm.
 4. FINAL LOCATION OF COLUMNS TO BE CO-ORDINATED WITH EXTERNAL FINISHES.
 5. FINAL SETTING OUT DETAILS TO BE ADVISED BY ARCHITECT/LANDSCAPE ARCHITECT.
 6. FOR DETAILS OF CABLEING / DUCTING REFER TO DRAWING No. 2537-HCL-ZZ-XX-DR-ME-6000.
 7. LUMINAIRES SHALL BE CONTROLLED VIA A COMBINATION OF PHOTOCELL, TIME CLOCK & PIR CONTROLS. THE TIME CLOCK SHALL SWITCH OFF THE LIGHTS BETWEEN 23:00 & 06:00. OVERRIDE SWITCHES TO BE PROVIDED AS DETAILED ON THE DRAWING.

C01	04/09/25	ISSUED FOR CONSTRUCTION	JR
P02	08/08/25	INTERNAL COMMENTS INCLUDED	JR
P01	18/03/25	ISSUED FOR COMMENT	JR
REV	DATE	DETAILS OF REVISION	BY

HARNISS
1 Weekley Wood Avenue,
Kettering, Northants, NN14 1UQ
Tel: 01933 656850
Email: info@harniss.co.uk

CLIENT
HORIZON CONSTRUCTION
(BARCHESTER HEALTHCARE)

PROJECT
PROPOSED CARE HOME
TURNERS HILL ROAD
COPTHORNE, WEST SUSSEX

DRAWING TITLE
ELECTRICAL SERVICES
EXTERNAL ELECTRICAL LAYOUT

Issue Status			
FOR CONSTRUCTION			
Original Size	Scale	Drawn	
A0	1:125	JR	
HCL Project No.	Suitability	Checked	
2537	-	TB	
Project	Originator	Volume	Leaf
2537 - HCL - ZZ - XX - DR - E - 6000			