


Sheet Size A2


All dimensions in millimetres

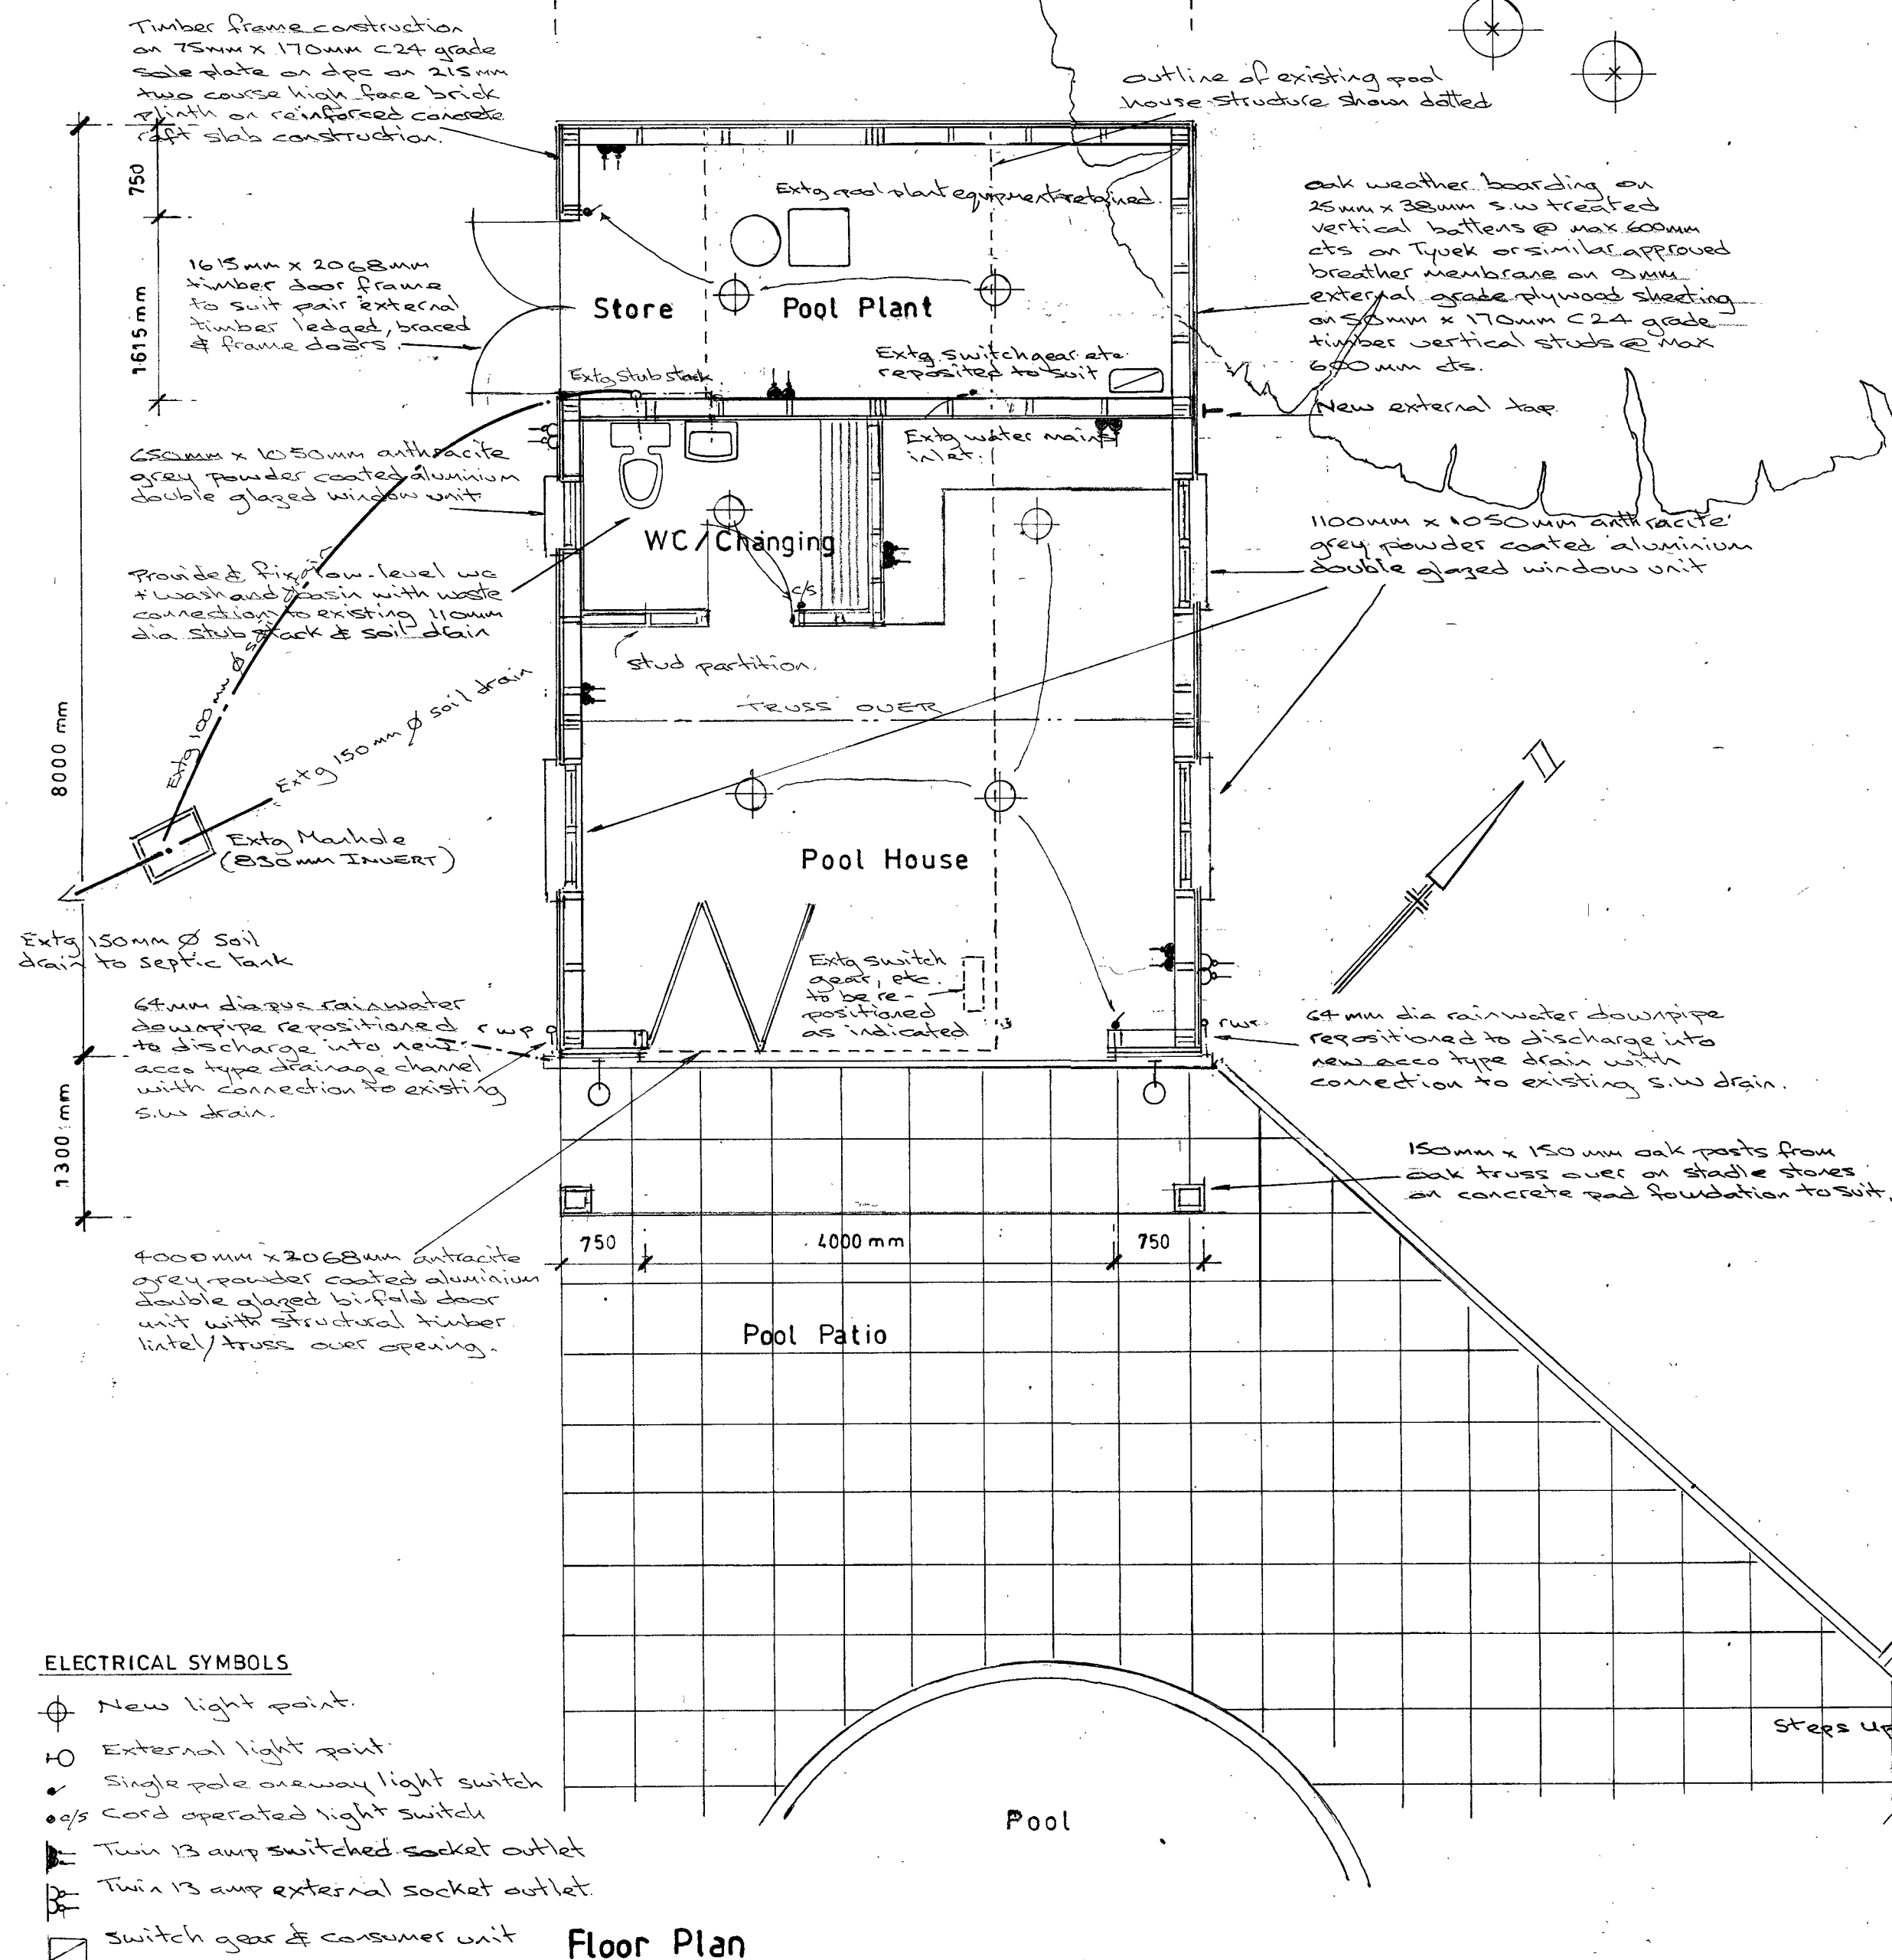


ELECTRICAL SYMBOLS

- ⊕ New light point.
- ⊕ External light point.
- Single pole oneway light switch
- Cord operated light switch
- ⚡ Twin 13 amp switched socket outlet
- ⚡ Twin 13 amp external socket outlet
- ⊞ Switch gear & consumer unit


Floor Plan

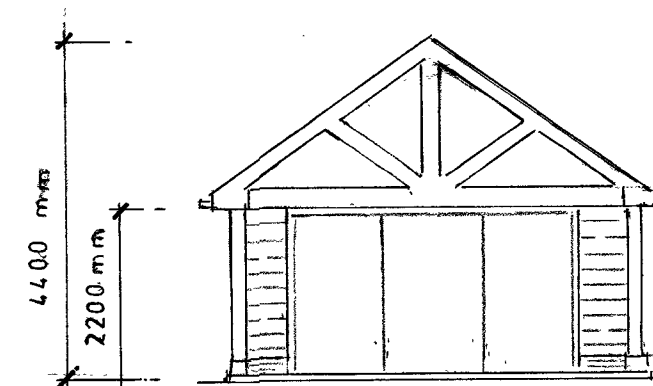


South Elevation

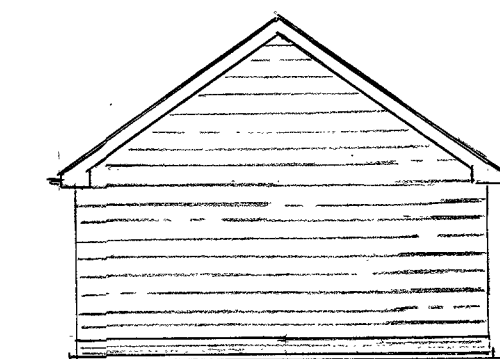


North Elevation

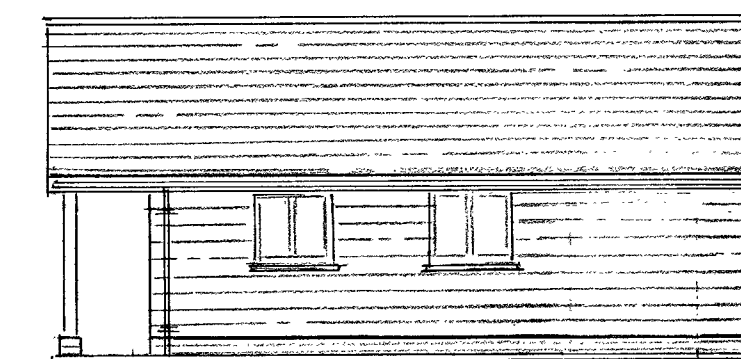

East Elevation

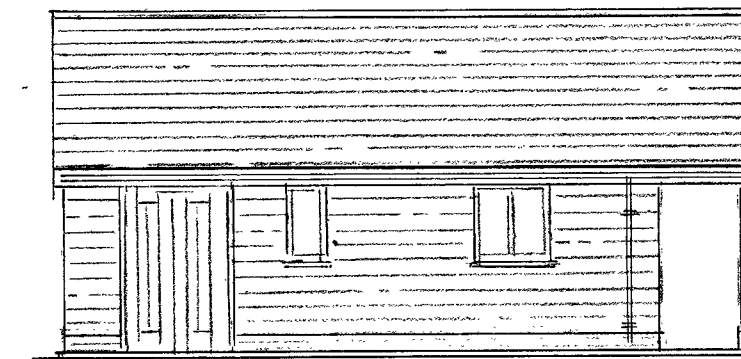

West Elevation

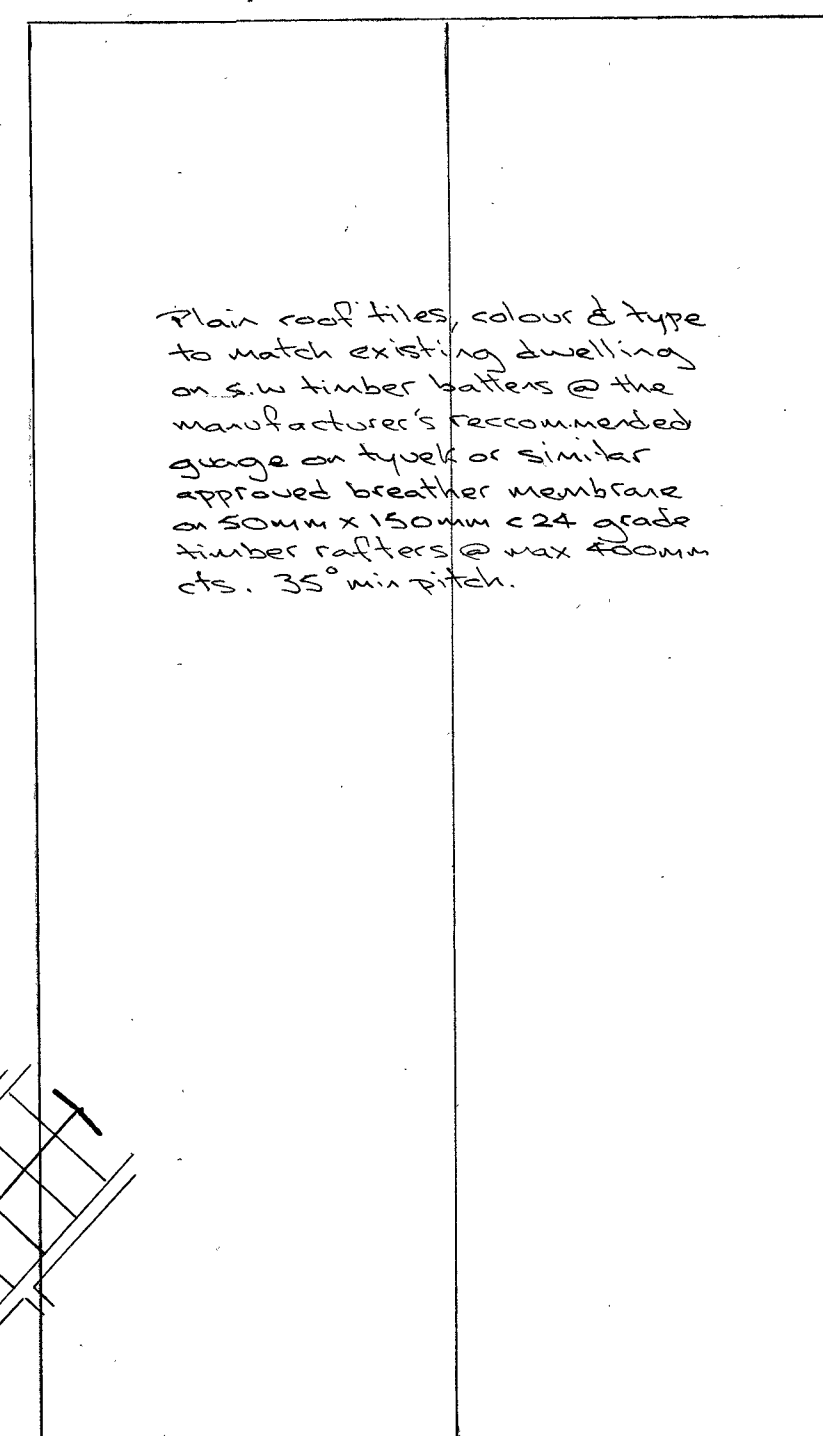

Roof Plan

Glebe House
Church Hill
West Hoathly
West Sussex

Replacement Pool House
Floor Plan and Elevations
as Proposed



A.D. WALSH DEVELOPMENTS

Architectural Consultants

Alescroft,
Lewes Road, Seaford, West Sussex BN1 1PG

tel: (01444) 831777

Scale: 1:50 & 1:100
@ A2

Date: March 2025

Drawn: A.D. Walsh

Drawing No:

123/755/15