


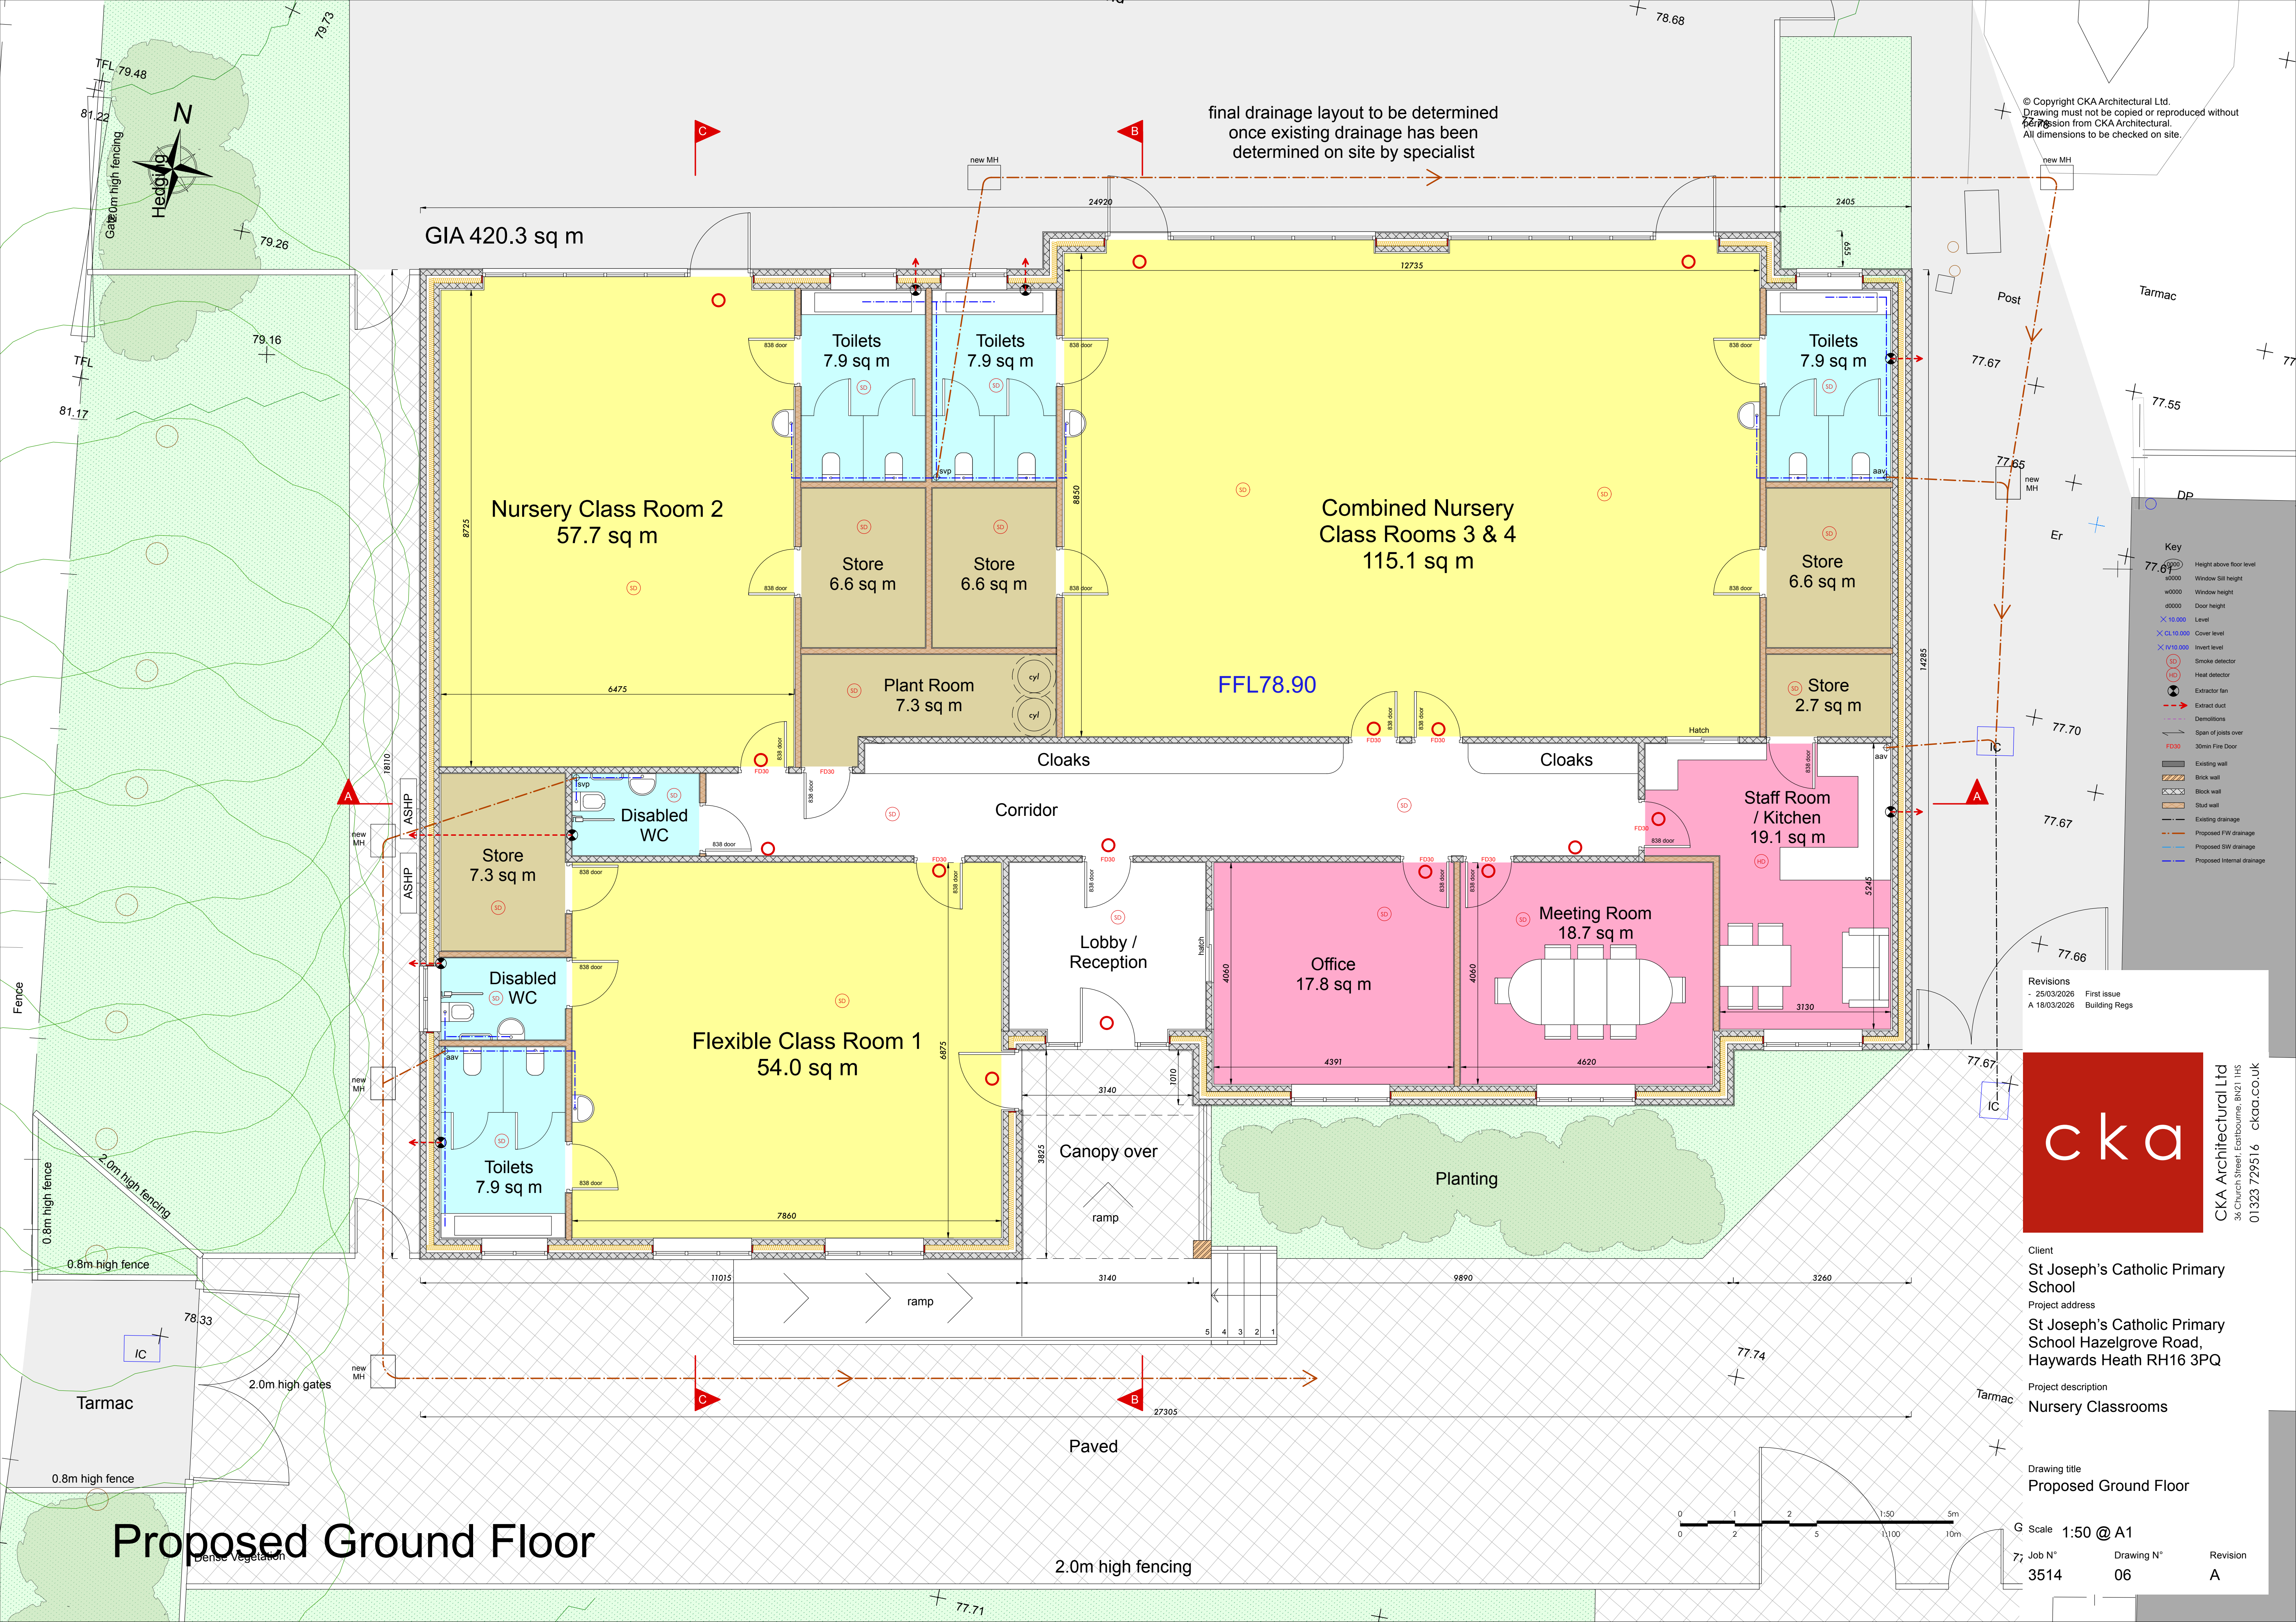

Proposed Ground Floor

final drainage layout to be determined
once existing drainage has been
determined on site by specialist

© Copyright CKA Architectural Ltd.
Drawing must not be copied or reproduced without
permission from CKA Architectural.
All dimensions to be checked on site.

- Key**
- Height above floor level
 - Window Sill height
 - Window height
 - Door height
 - Level
 - Cover level
 - Invert level
 - Smoke detector
 - Heat detector
 - Extract fan
 - Extract duct
 - Demolitions
 - Span of joists over
 - 30min Fire Door
 - Existing wall
 - Brick wall
 - Block wall
 - Stud wall
 - Existing drainage
 - Proposed FW drainage
 - Proposed SW drainage
 - Proposed internal drainage

Revisions	
- 25/03/2025	First issue
A 18/03/2026	Building Regs

cka

CKA Architectural Ltd
36 Church Street, Eastbourne, BN21 1HS
01323 729516 cka.co.uk

Client
St Joseph's Catholic Primary School
Project address
St Joseph's Catholic Primary School Hazelgrove Road, Haywards Heath RH16 3PQ
Project description
Nursery Classrooms

Drawing title
Proposed Ground Floor
G Scale 1:50 @ A1
Job N° 3514
Drawing N° 06
Revision A