





DIRECTION
OF NORTH

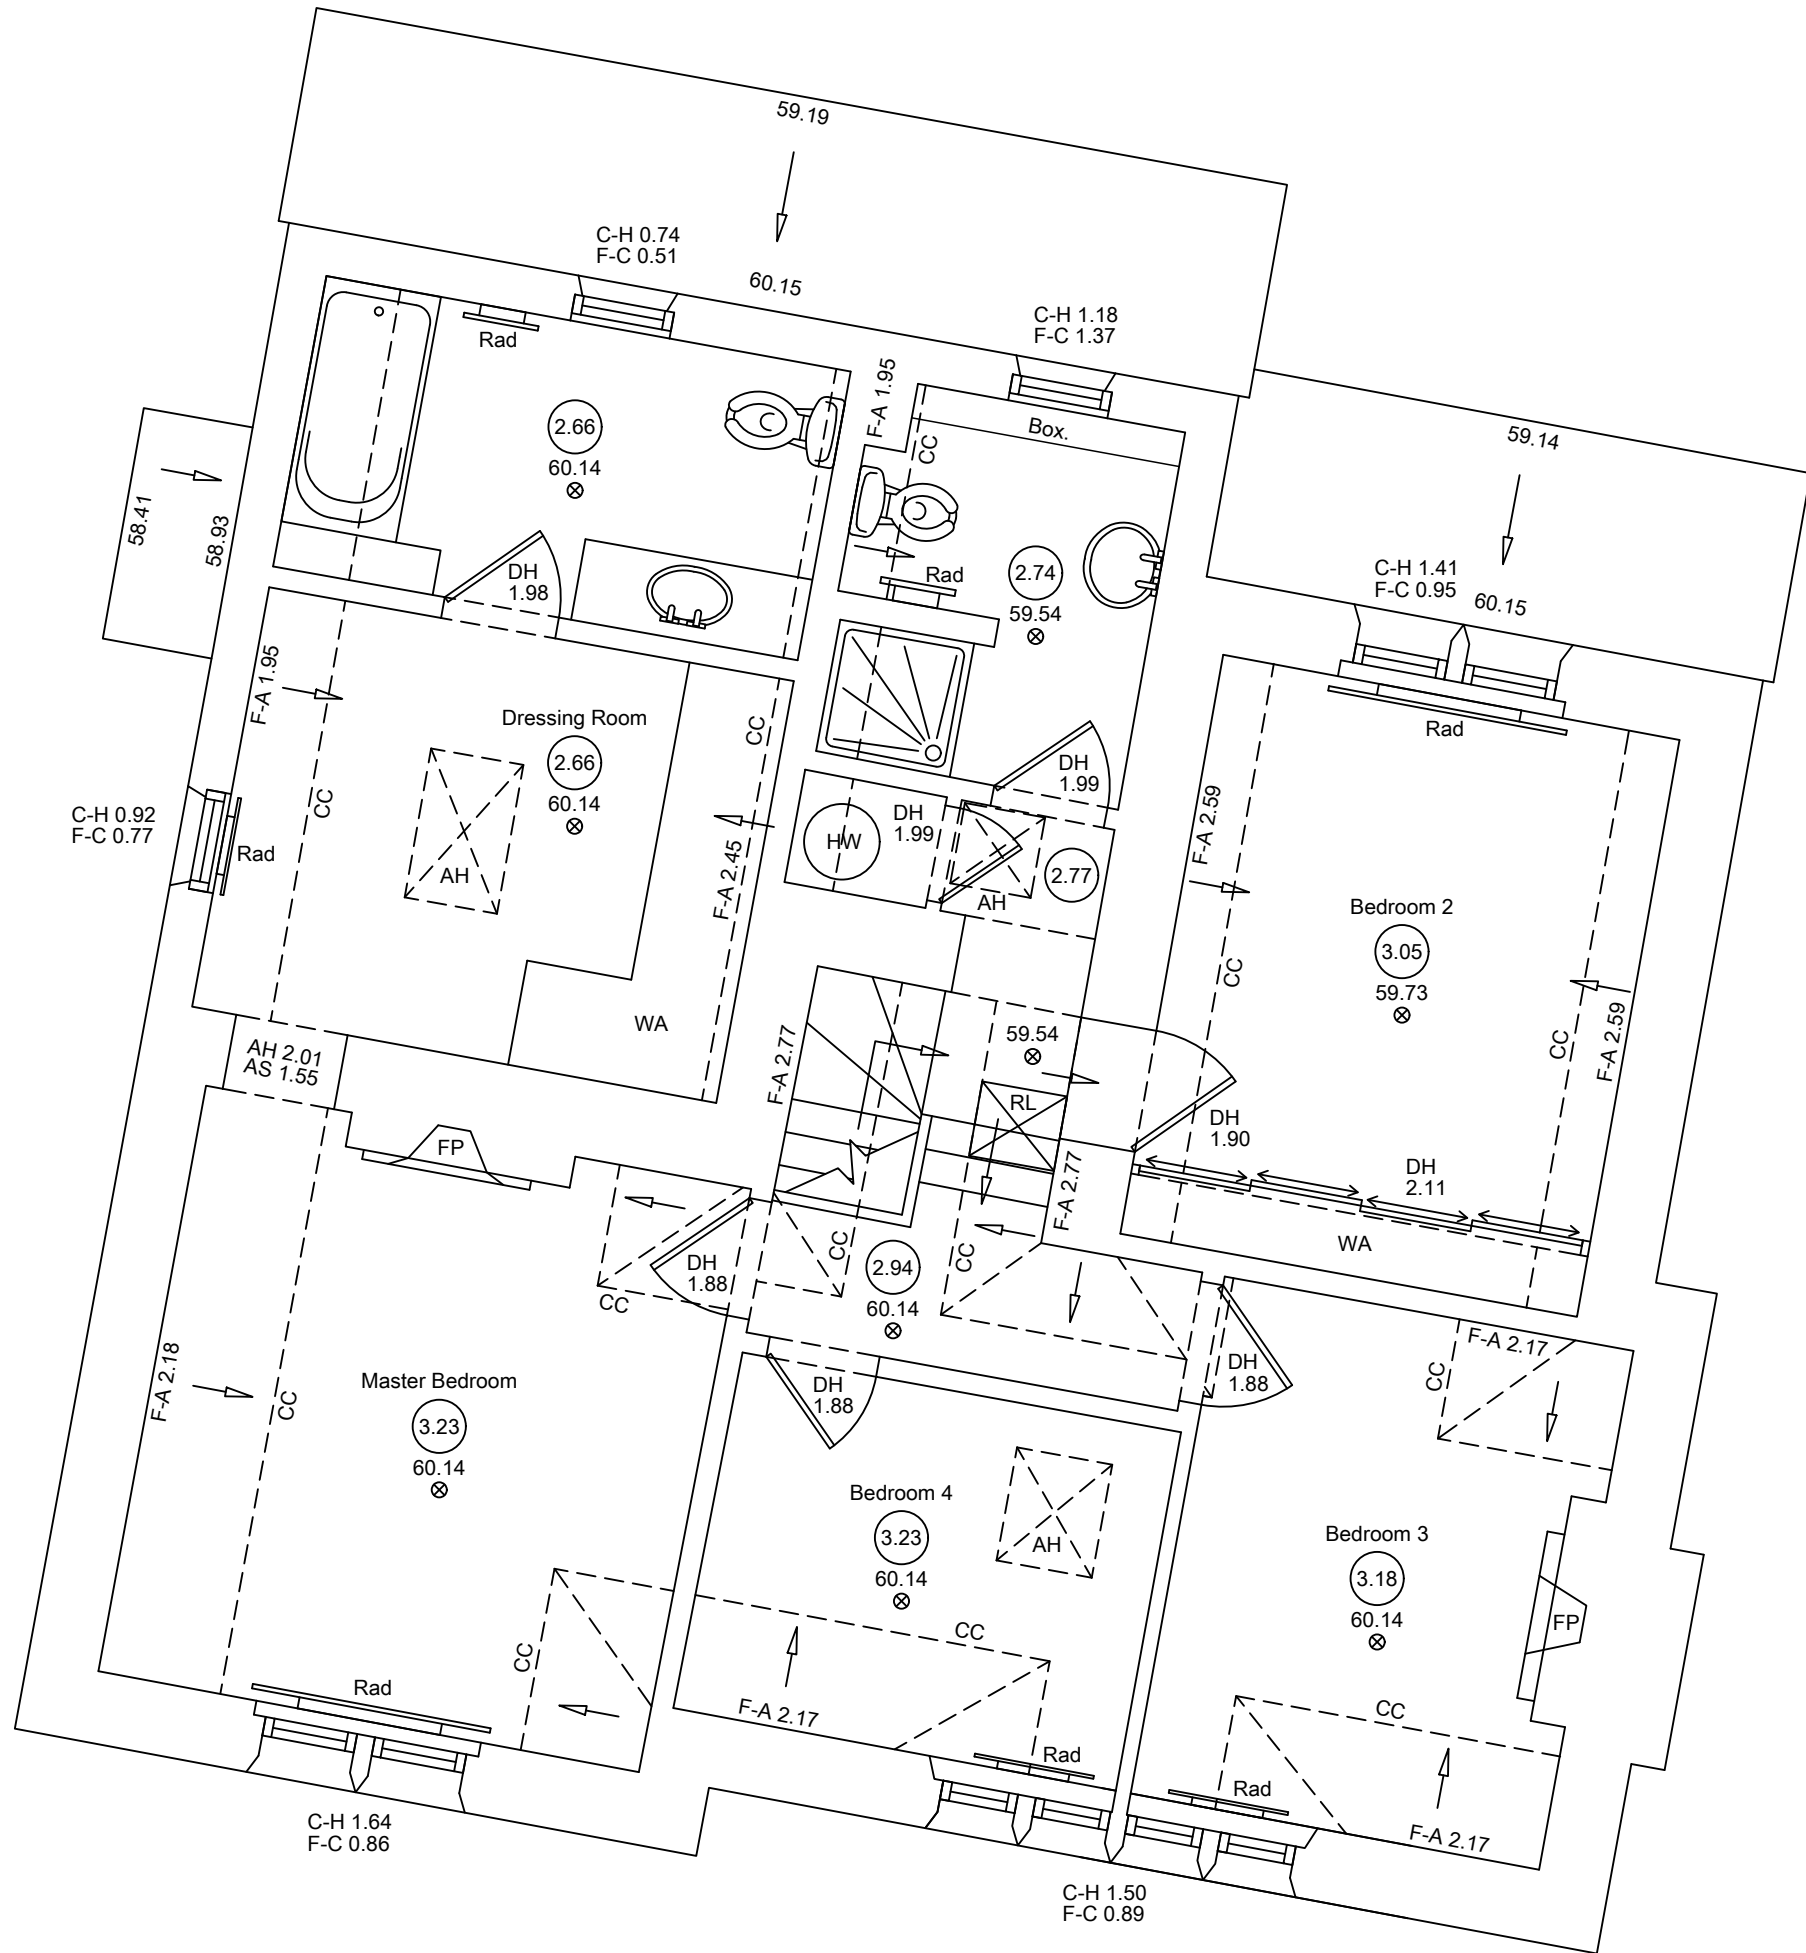

534831 681 E
125930 289 N
56.861 L

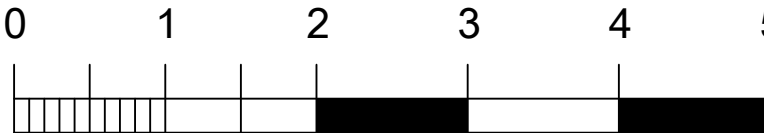

Metres

SHEET SIZE A2

copyright

Copyright of this drawing is retained by City Geomatics Ltd. Any discrepancies between this drawing and any other information should be reported to City Geomatics Ltd.

Drawing Naming Convention:

Job No/Dwg type/Location/Ref

Dwg Type:	B = Building	E = Elevation
	S = Section	T = Topographical
Location:	B = Basement	C = Ceiling Plan
	E = External	F = Front
	C = Ground	S = Side
	1 = First	R = Rear
	R = Roof	GA = General Layout
	M = Mezzanine	AA = Section A-A

Ref: Ref to individual dwg I.D. (e.g. Revision)

Standard Abbreviations (where applicable):

Building Survey	Land Survey
AB AIR BRICK	B BOLLARD
ACU AIR CONDITIONING UNIT	BB BELISHA BEACON
AH ACCESS HATCH	BT B.T. COVER
AP ACCESS PANEL	CAM CAMERA
AV AIR VALVE	CATV CABLE TV COVER
BH BEAM HT	CL COVER LEVEL
BR BOILER	ELEC ELECTRIC COVER
BSL BEAM SOFFIT LEVEL	EP ELECTRIC POLE
CB CURB/BOARD	ER EARTH ROD
CC CEILING CHANGE	FP FLAG POLE
CH CLEAR INTERNAL HT	FW FOUL WATER
C-A CILL TO APEX HT	GU GULLY
C-H CILL TO HEAD HT	GV GAS VALVE
C-S CILL TO SPRING HT	FH FIRE HYDRANT
DB DOOR BASE HT	IC INSPECTION COVER
DH DOOR HEAD HT	IL INVERT LEVEL
DR DRAIN	LP LAMP POST
EXP EXTRACTOR FAN	MH MANHOLE
FA FIRE ALARM	OHT OVERHEAD TELECOM
F-A FLOOR TO APEX HT	P POST
F-C FLOOR TO CILL HT	PM PARKING METER
F-H FLOOR TO HEAD HT	PI PIPE
F-S FLOOR TO SPRING HT	RD RODDING EYE
GEA GROSS EXTERNAL AREA	RS ROAD SIGN
GIA GROSS INTERNAL AREA	RTW RETAINING WALL
GU GULLY	RWP RAIN WATER PIPE
HT HEATER	SA SITE AREA
HW HOT WATER TANK	SI SINK
NIA NET INTERNAL AREA	SL SOFFIT LEVEL
NTS NOT TO SCALE	SV STOP VALVE
RAD RADIATOR	SVP SOIL VENT PIPE
RE RECESS HEAD HEIGHT	SW STORM WATER
RFV RAISED FLOOR VOID	TCF TOP OF FENCE
RL ROOF LIGHT	TOW TOP OF WALL
RSH ROLLER SHUTTER	TP TELEGRAPH POLE
RWP RAIN WATER PIPE	UTL UNABLE TO LIFT
SVP SOIL VENT PIPE	VP VENT PIPE
V VENT	WM WATER METER
WA WARDROBE	WT WATER TAP

Symbols (where applicable):

SWITCHED	FUSED SPUR	FIRE DETECTOR	PLUG SOCKET	LIGHT SWITCH
			2 = NO. OF SOCKETS	1 = NO. OF SWITCHES
WALL LIGHT	PENDANT LIGHT	SPOT LIGHT	FLOOR TO STRUCTURAL CEILING HT	FLOOR LEVEL RELATIVE TO DATUM

Notes:

The Survey has been computed on the OS grid.
All Levels are in metres and relate to OS datum.
All direction arrows indicate UP unless otherwise stated.
Drainage pipe sizes (where shown) have been gauged from the surface (for safety reasons) and should be regarded as approximate only.
Visible features in the vicinity of any boundaries, as shown on this survey, may not represent the extent of legally conveyed ownership.
Whilst every effort has been made to determine wall materials, no guarantee is given. Materials should be regarded as assumed unless verified by a qualified third party.
Tree spread and height are approximate. Species should be regarded as assumed unless verified by a qualified third party.

Sheet Layout:

Rev	Date	By	Description
-----	------	----	-------------

Land & Measured Building Surveyors

Horsham, West Sussex RH12 3QJ
t. 01403 268469
www.citygeomatics.co.uk
enquiries@citygeomatics.co.uk

Client: Gould Baxter

Project: St. John's Lodge
151 High Street
Lindfield RH16

Drawing Title: Existing First Floor Plan				
Date: Jan - 25	Scale: 1:50	Surveyor: RD	Drawn: BP	Checked: CGL
Job No: 25/237	Drawing No: 25237 - B - 1	Sheet No: 1 of 1	Rev: -	