

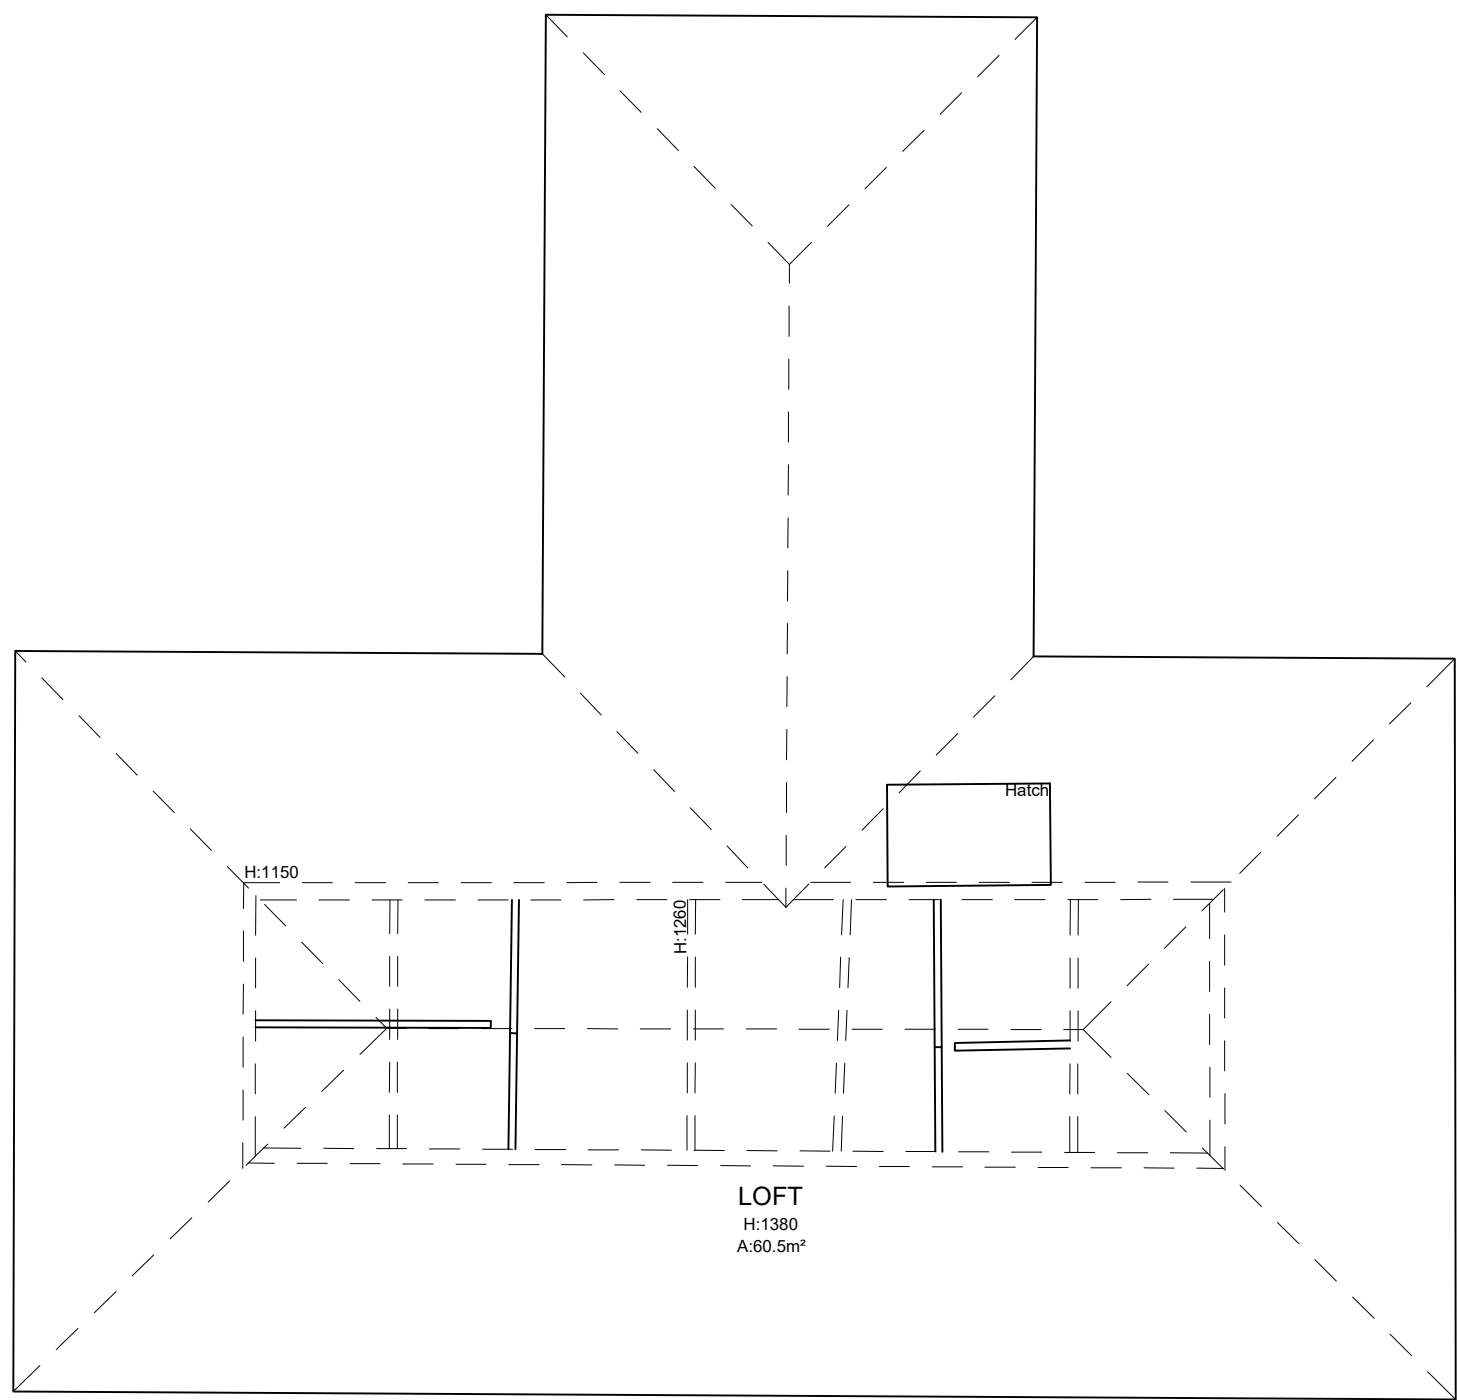


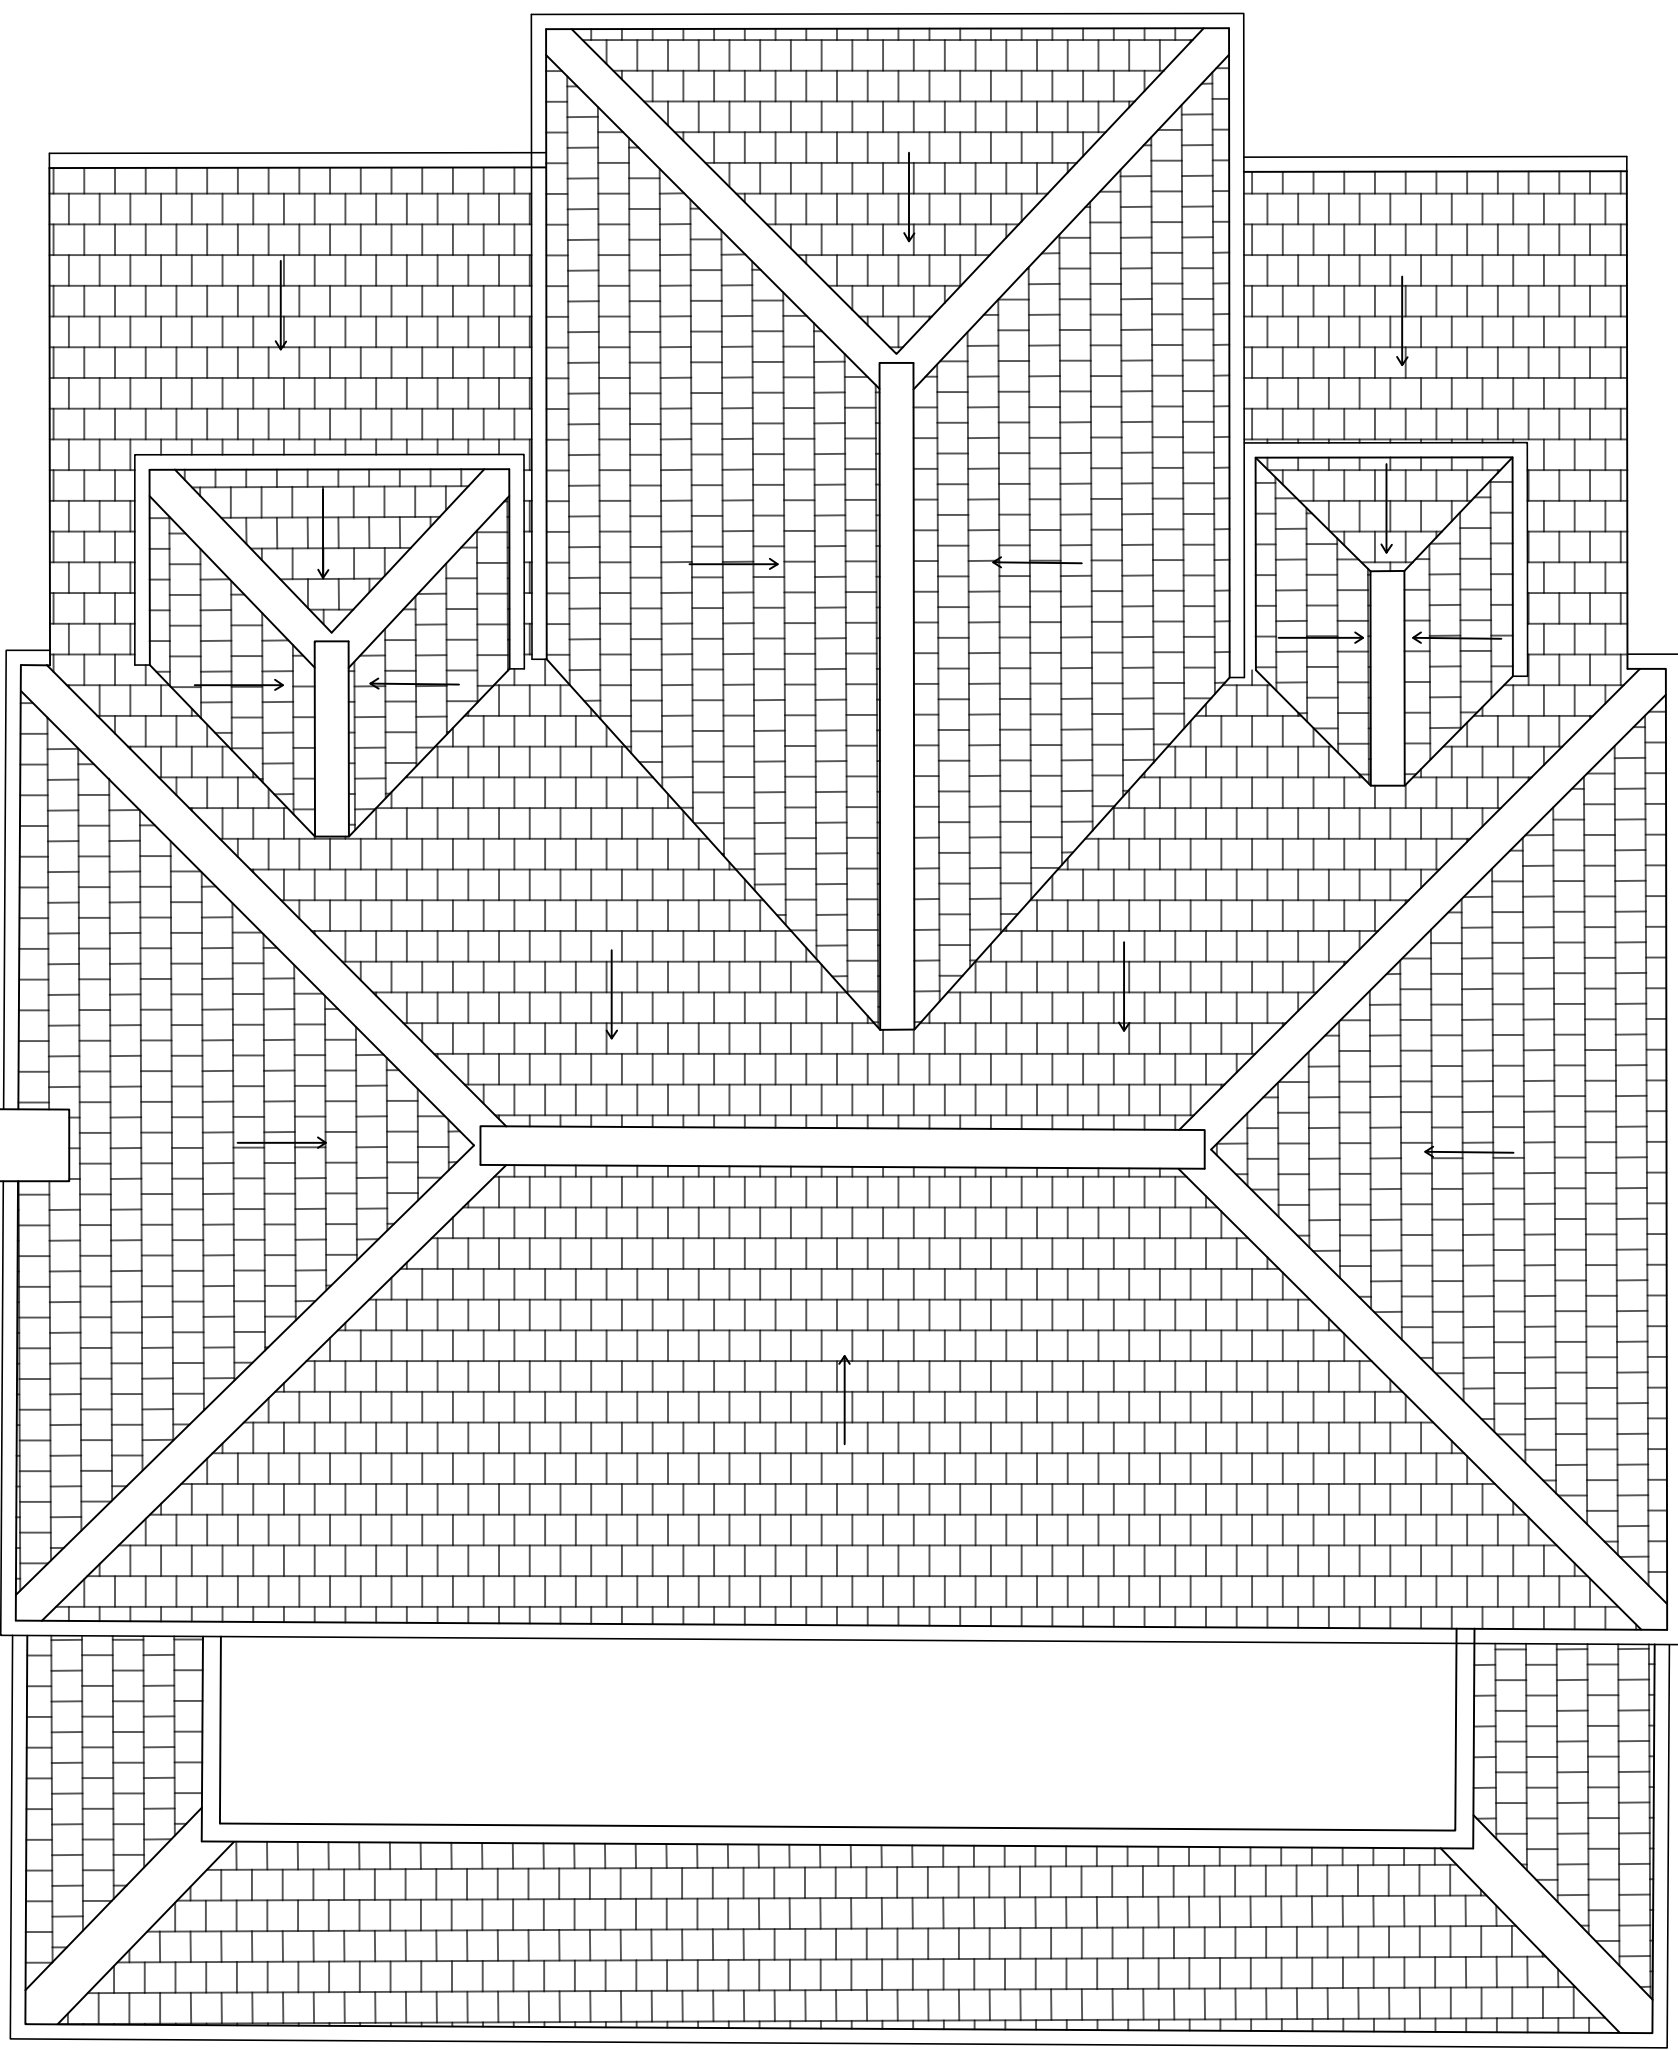

AS EXISTING LOFT FLOOR PLAN 1:50 @ A1

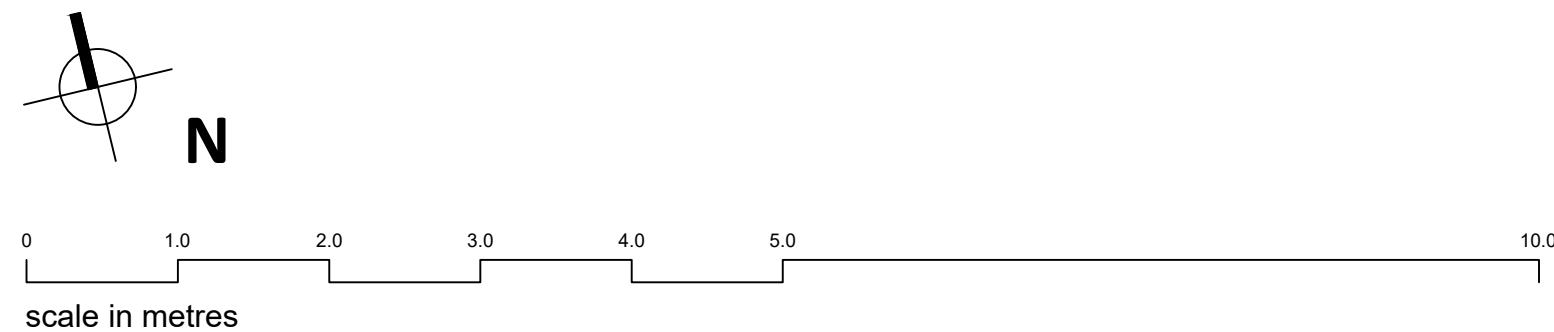

AS EXISTING ROOF PLAN 1:50 @ A1

Notes
Do not scale directly from drawing, all measurements are to be taken from site prior to the commencement of works.
It is the contractors responsibility to ensure compliance with Building Regulations.

LEGEND

	GAS METERS
	ELECTRICAL METERS
	BOILER
	CONSUMER UNIT
	MEGAFLOW UNIT
	RADIATOR
	HEATED TOWEL RAIL
	DIRECTION OF ROOF FALL
	INSPECTION CHAMBER
	SOIL VENTILATION STACK
	STUB STACK
	RAINWATER PIPE
	GULLY
	WATER FEED OR TAPS
	PENDANT LIGHT FITTING
	WALL MOUNTED LIGHT FITTING
	SPOT/ DOWN LIGHT FITTING
	UP LIGHT FITTING
	EXTERNAL LIGHT FITTING
	CEILING FAN
	30MIN FIRE RATED DOOR
	SMOKE DETECTOR
	HEAT DETECTOR
	CARBON MONOXIDE DETECTOR
	TOUGHENED SAFETY GLASS
	OBSCURE GLAZING
	30L/S MECHANICAL VENTILATION
	60L/S MECHANICAL VENTILATION
	BESPOKE MECHANICAL VENTILATION
	KITCHEN VENTILATION FLUE
	BATHROOM VENTILATION FLUE
	UTILITY ROOM VENTILATION FLUE
	BOILER VENTILATION FLUE
	TUMBLE DRYER VENTILATION

ELECTRICAL

	WALL MOUNTED LIGHT FITTING
	SPOT/ DOWN LIGHT FITTING
	UP LIGHT FITTING
	EXTERNAL LIGHT FITTING
	P.I.R. EXTERNAL LIGHT
	FLUORESCENT STRIP LIGHT
	ELECTRICAL SUPPLY
	GAS SUPPLY
	WATER SUPPLY
	ELECTRICAL SOCKET
	ELECTRICAL DOUBLE SOCKET
	SPECIAL GRADE SOCKET
	ELECTRICAL SOCKET (ABOVE WORK TOP LEVEL)
	ELECTRICAL DOUBLE SOCKET (ABOVE WORK TOP LEVEL)
	ELECTRIC SWITCHED FUSED SPUR AT HIGH LEVEL FOR EXTRACTION
	COOKER SWITCH
	MECHANICAL EXTRACTION SWITCH
	SOCKET SWITCH
	TWO WAY SOCKET SWITCH
	MULTI SOCKET SWITCH
	DIMMER SWITCH
	DOOR BELL
	MOTION SENSOR
	PHONE CONNECTION
	CAT 5 or 6 DATA CONNECTION
	CABLE/ TV DIGITAL SOCKET
	USB CONNECTION
	SHAVER POINT
	AUDIO SPEAKER
	CEILING FAN
	UNDERFLOOR HEATING

LIFE
SIZE

01273 686 744
studio@lifesizearchitecture.co.uk
www.lifesizearchitecture.co.uk

description: date: revision:

EXISTING LOFT & ROOF PLANS

project no: 24032DA drawing no: EX03

drawing status: PLANNING

client: SUSAN ROOTS & TIM GORDON

project: 82 DALE AVENUE, KEYMER, BN6 8LS
CONVERSION WORKS

date: 10/07/25 scale: 1:50 @ A1 drawn: CB checked: RB