


Notes
Do not scale directly from drawing, all measurements are to be taken from site prior to the commencement of works.
It is the contractors responsibility to ensure compliance with Building Regulations.


LEGEND

	GAS METERS		WALL MOUNTED LIGHT FITTING
	ELECTRICAL METERS		SPOT/ DOWN LIGHT FITTING
	BOILER		UP LIGHT FITTING
	CONSUMER UNIT		EXTERNAL LIGHT FITTING
	MEGAFLOW UNIT		FLUORESCENT STRIP LIGHT
	RADIATOR		ELECTRICAL SUPPLY
	HEATED TOWEL RAIL		WATER SUPPLY
	DIRECTION OF ROOF FALL		ELECTRICAL SOCKET
	INSPECTION CHAMBER		ELECTRICAL DOUBLE SOCKET
	SOIL VENTILATION STACK		SPECIAL GRADE SOCKET
	STUB STACK		ELECTRICAL SOCKET (ABOVE WORK TOP LEVEL)
	GULLY		ELECTRICAL DOUBLE SOCKET (ABOVE WORK TOP LEVEL)
	WATER FEED/ TAPS		ELECTRIC SWITCHED FUSED SPUR AT HIGH LEVEL FOR EXTRACTION
	PENDANT LIGHT FITTING		COOKER SWITCH
	WALL MOUNTED LIGHT FITTING		MECHANICAL EXTRACTION SWITCH
	SPOT/ DOWN LIGHT FITTING		SOCKET SWITCH
	UP LIGHT FITTING		TWO WAY SOCKET SWITCH
	EXTERNAL LIGHT FITTING		MULTI SOCKET SWITCH
	CEILING FAN		DIMMER SWITCH
	30MIN FIRE RATED DOOR		DOOR BELL
	SMOKE DETECTOR		MOTION SENSOR
	HEAT DETECTOR		PHONE CONNECTION
	CARBON MONOXIDE DETECTOR		CAT 5 or 6 DATA CONNECTION
	TOUGHENED SAFETY GLASS		CABLE/ TV DIGITAL SOCKET
	OBSOURE GLAZING		USB CONNECTION
	30L/S MECHANICAL VENTILATION		SHAVER POINT
	60L/S MECHANICAL VENTILATION		AUDIO SPEAKER
	BESPOKE MECHANICAL VENTILATION		CEILING FAN
	KITCHEN VENTILATION FLUE		UNDERFLOOR HEATING
	BATHROOM VENTILATION FLUE		
	UTILITY ROOM VENTILATION FLUE		
	BOILER VENTILATION FLUE		
	TUMBLE DRYER VENTILATION		

ELECTRICAL

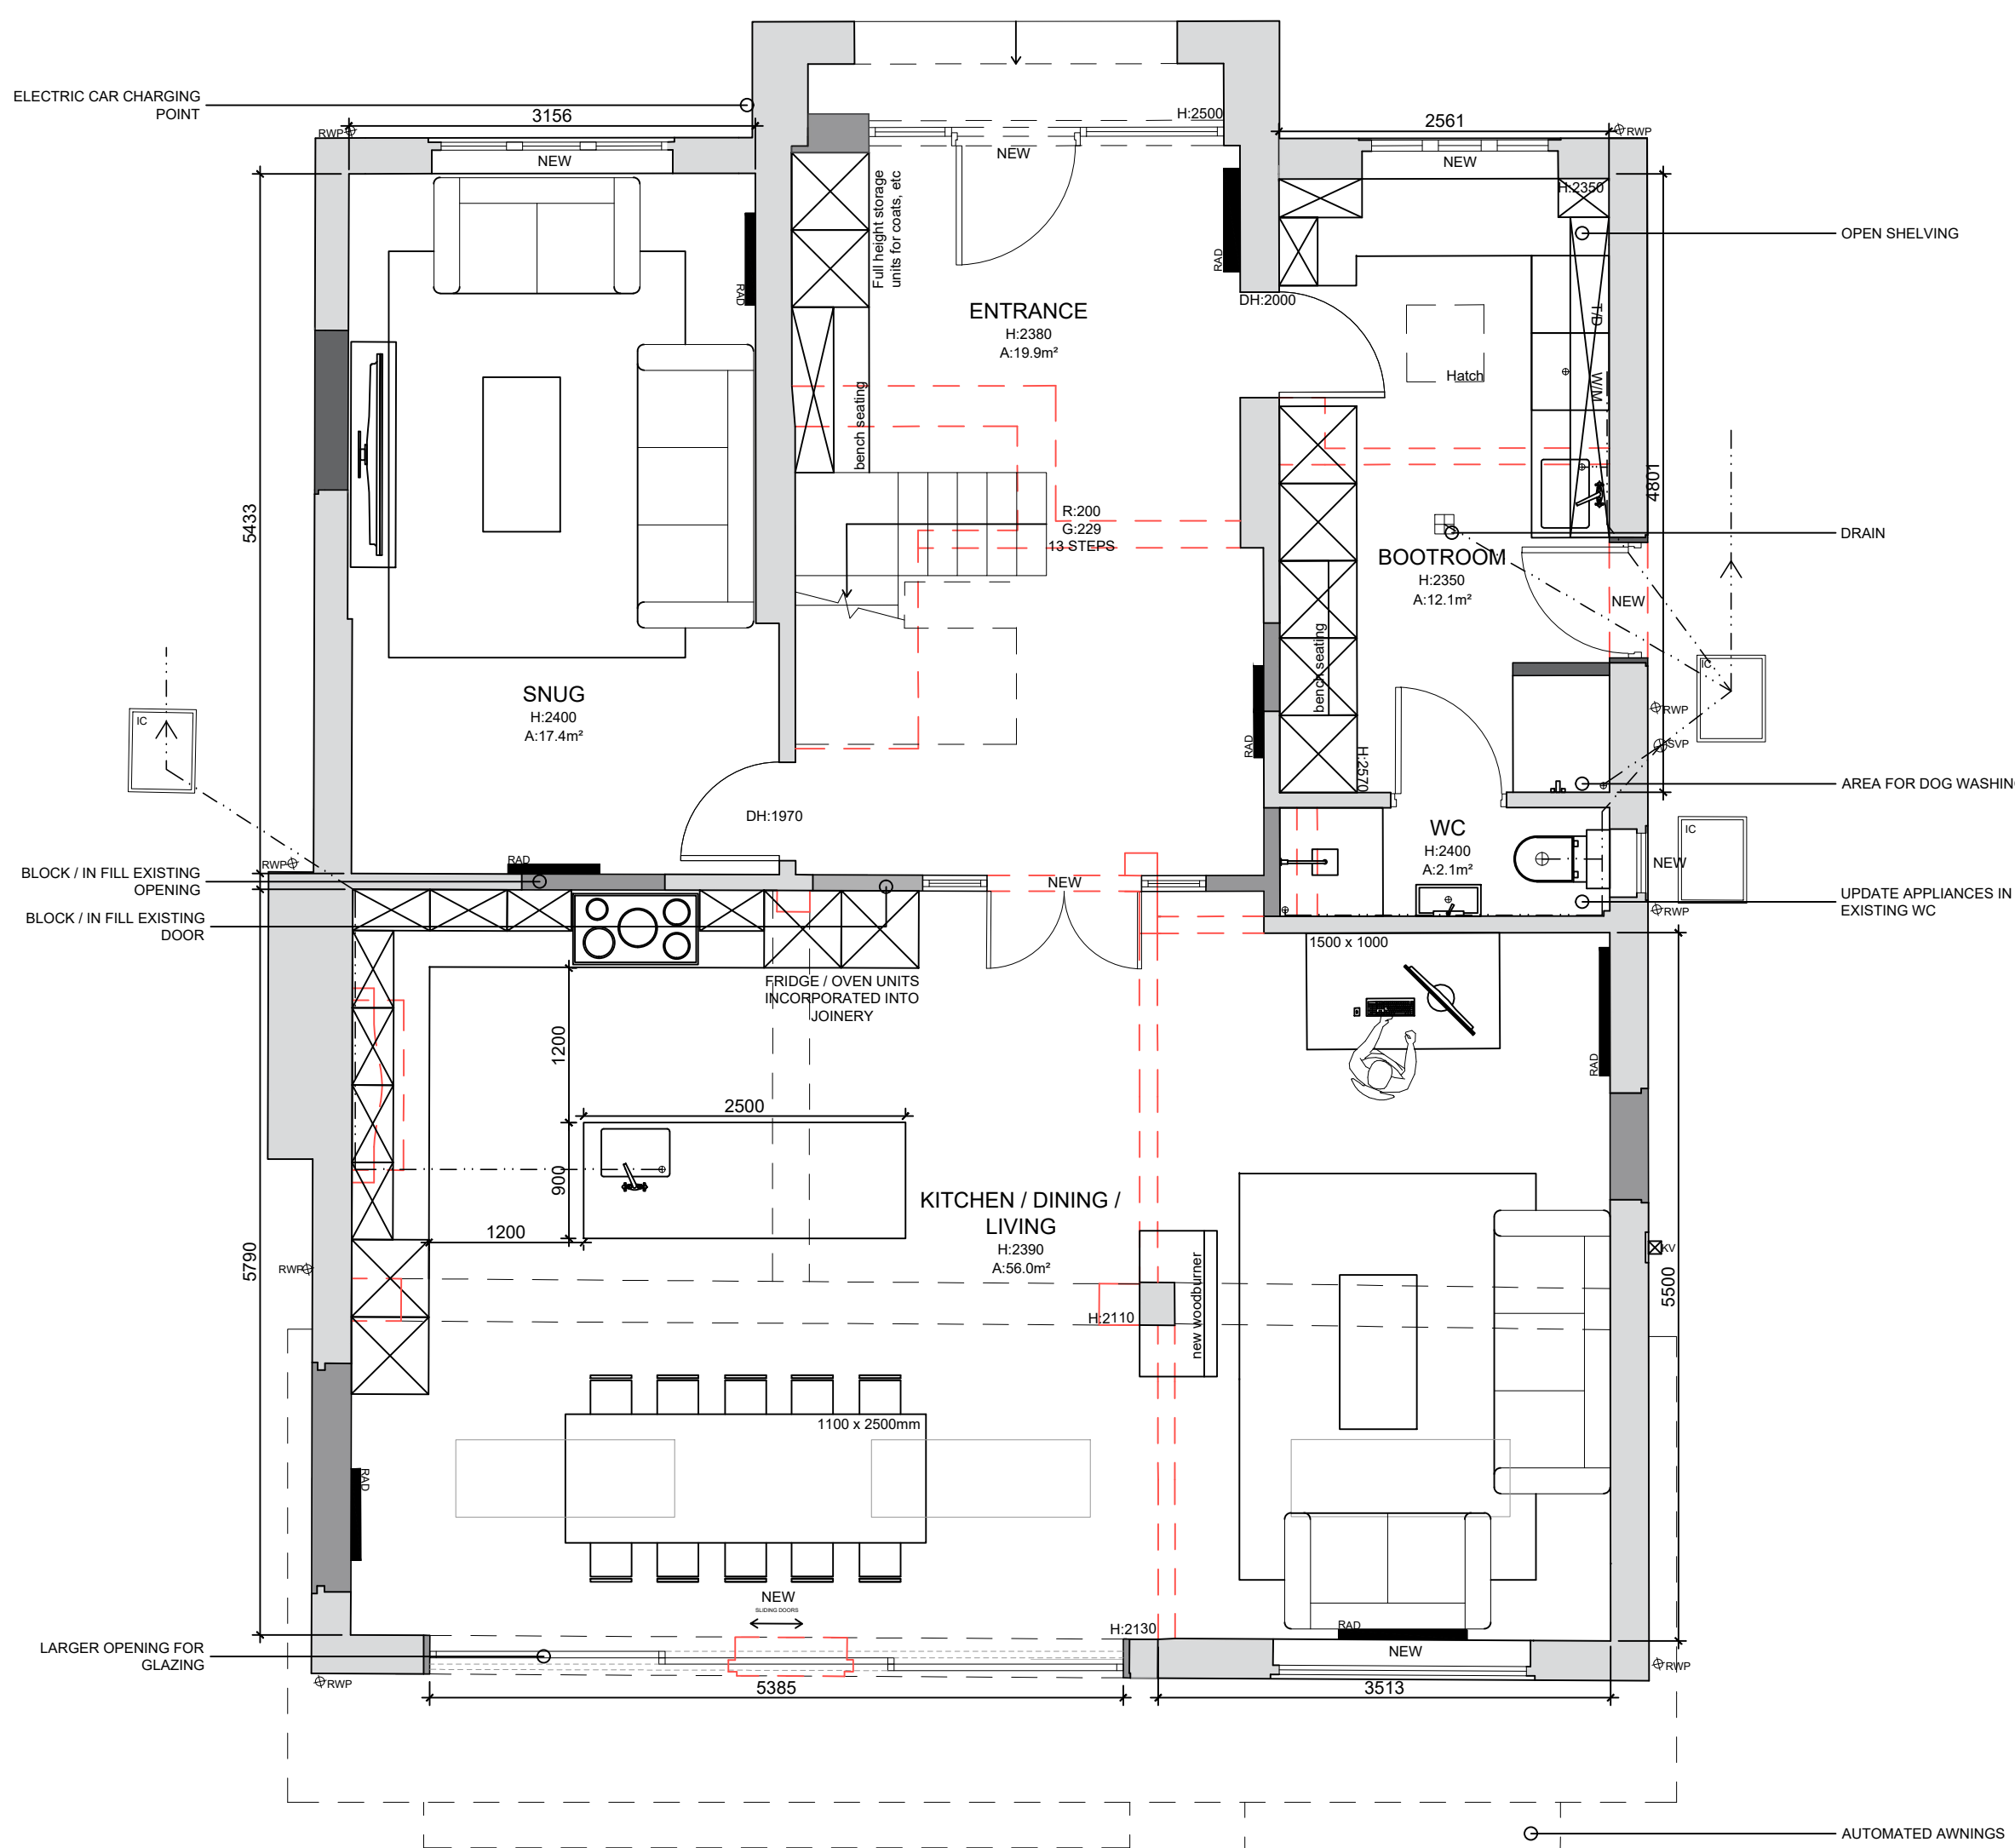

PROPOSED GROUND FLOOR PLAN 1:50 @ A1

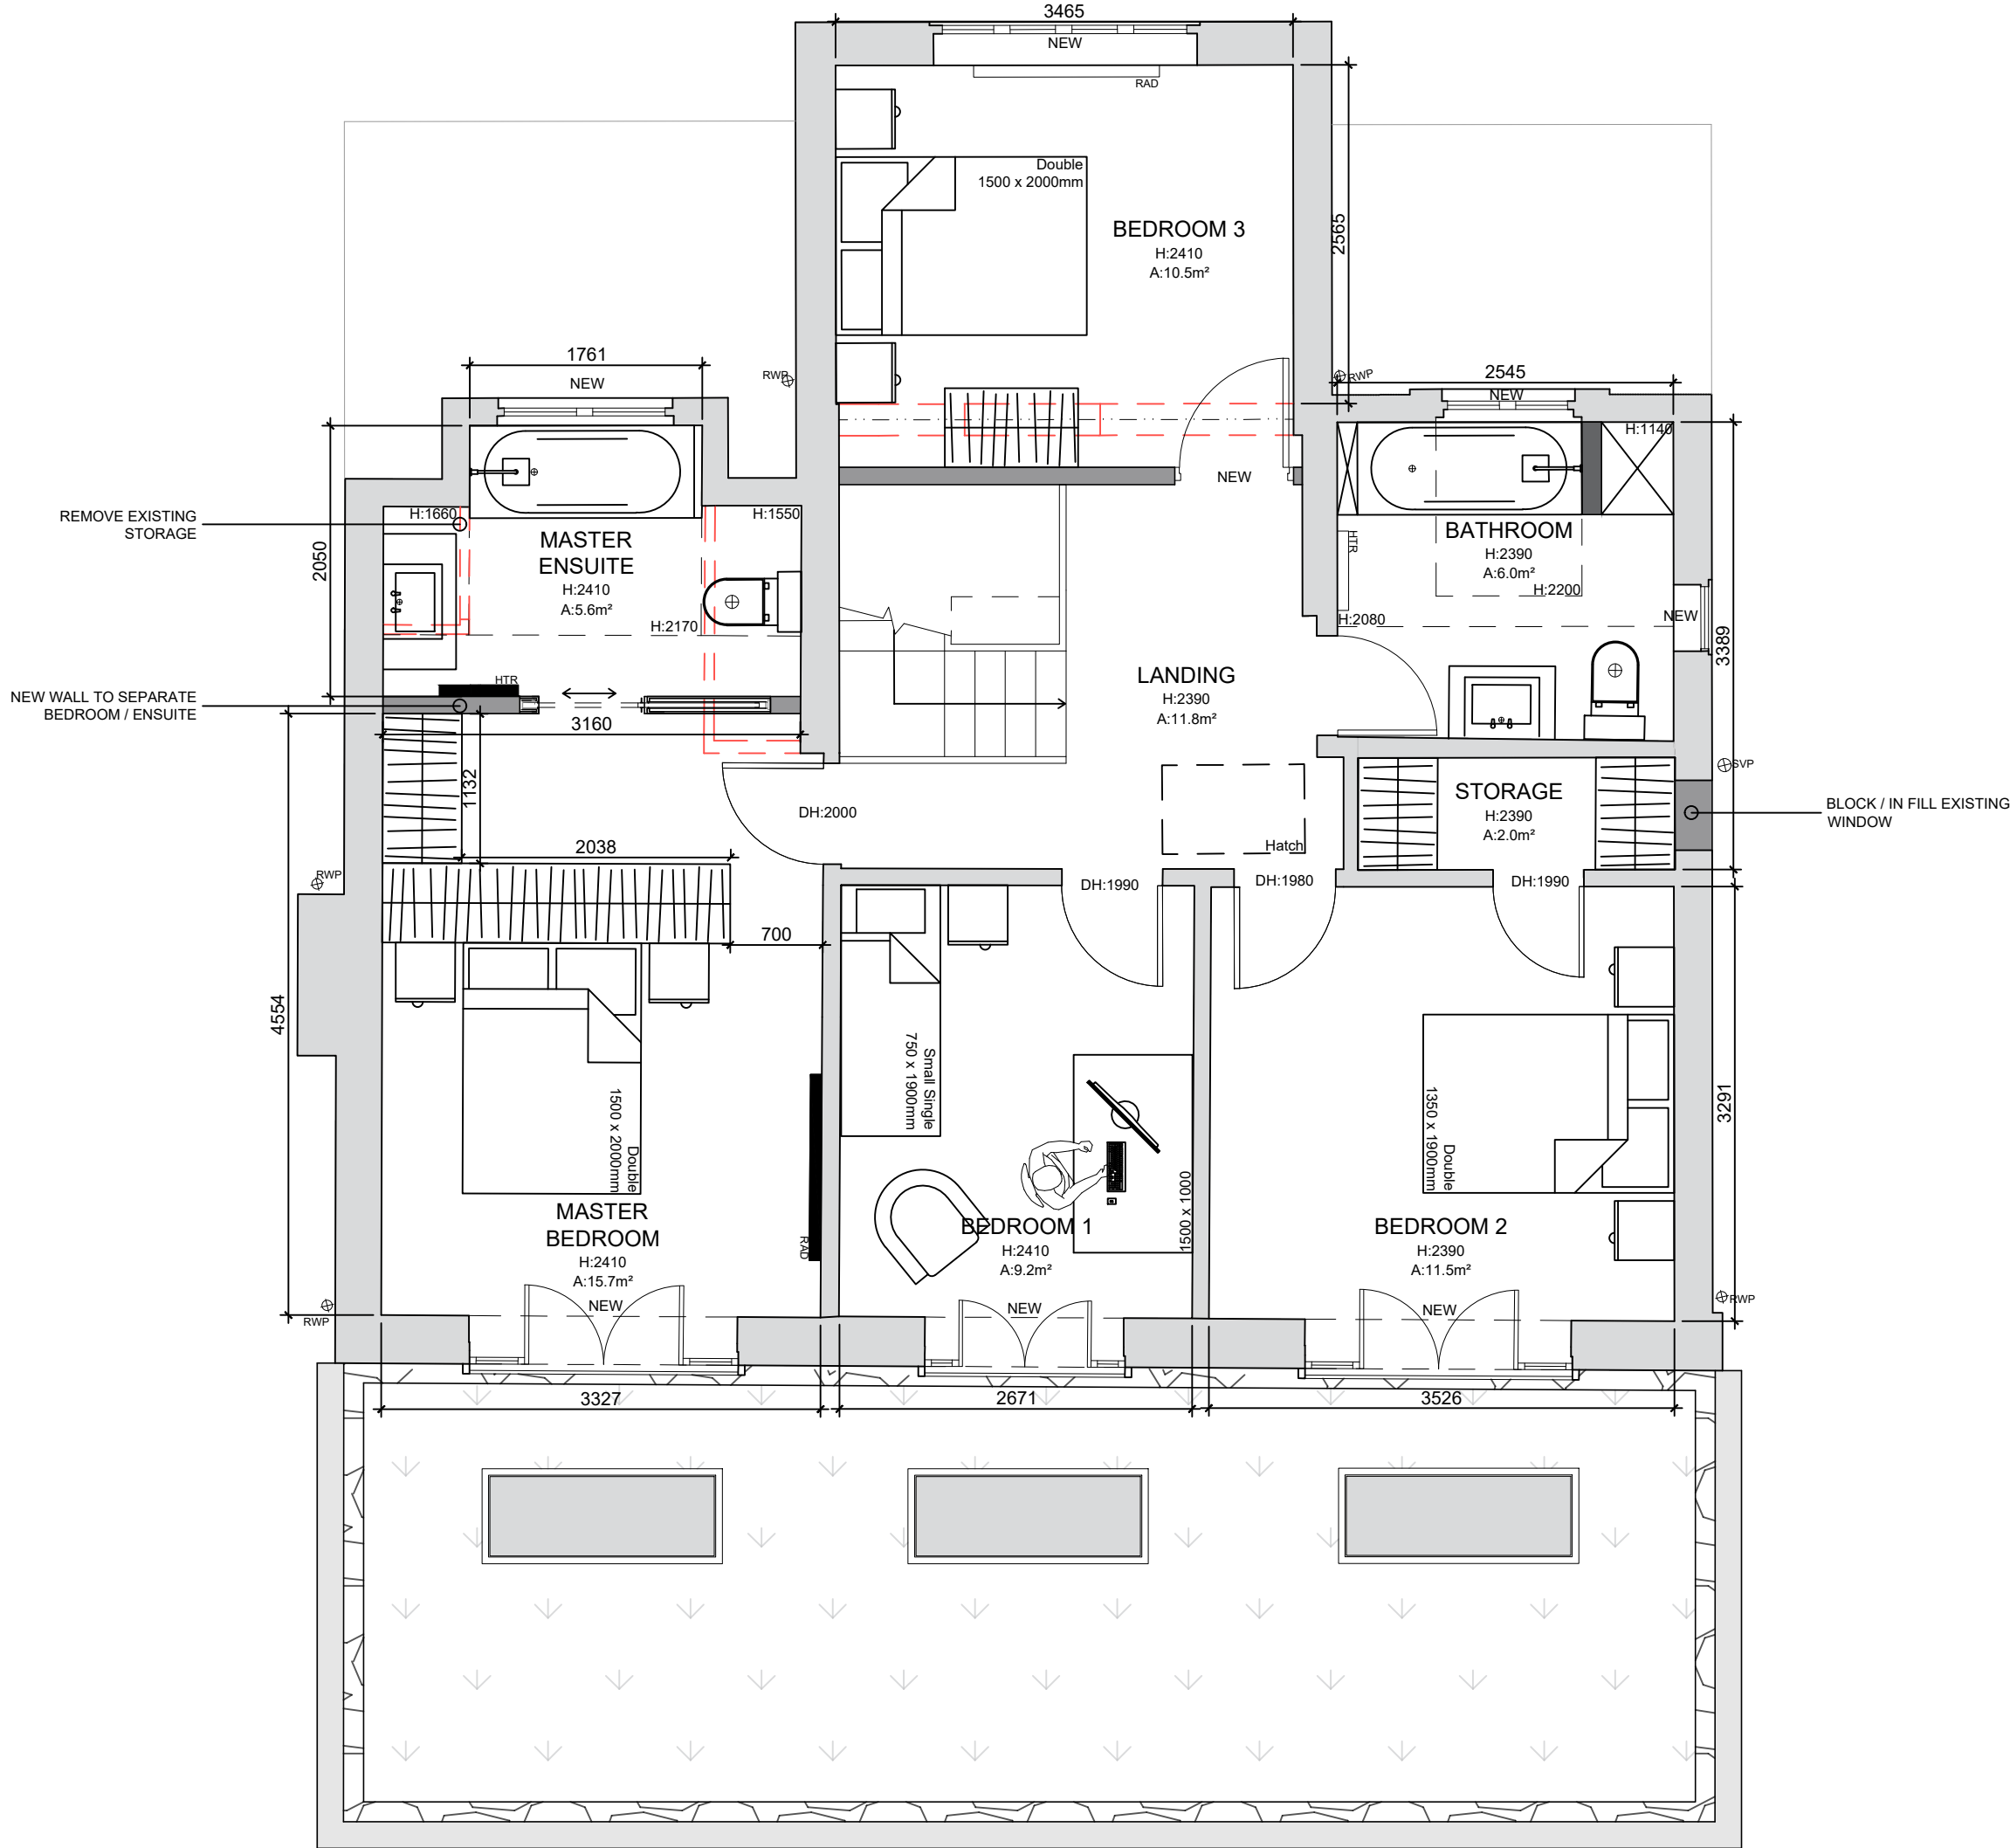

PROPOSED FIRST FLOOR PLAN 1:50 @ A1

LIFE
SIZE

01273 686 744
studio@lifesizearchitecture.co.uk
www.lifesizearchitecture.co.uk

description: date: revision:

PROPOSED GROUND & FIRST FLOOR PLAN


project no: 24032DA drawing no: PR02

drawing status: PLANNING

client: SUSAN ROOTS & TIM GORDON

project: 82 DALE AVENUE, KEYMER, BN6 8LS
CONVERSION WORKS

date: 10/07/25 scale: 1:50 @ A1 drawn: CB checked: RB

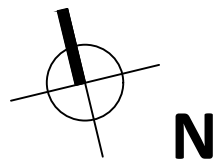

scale in metres
0 1.0 2.0 3.0 4.0 5.0 10.0