



 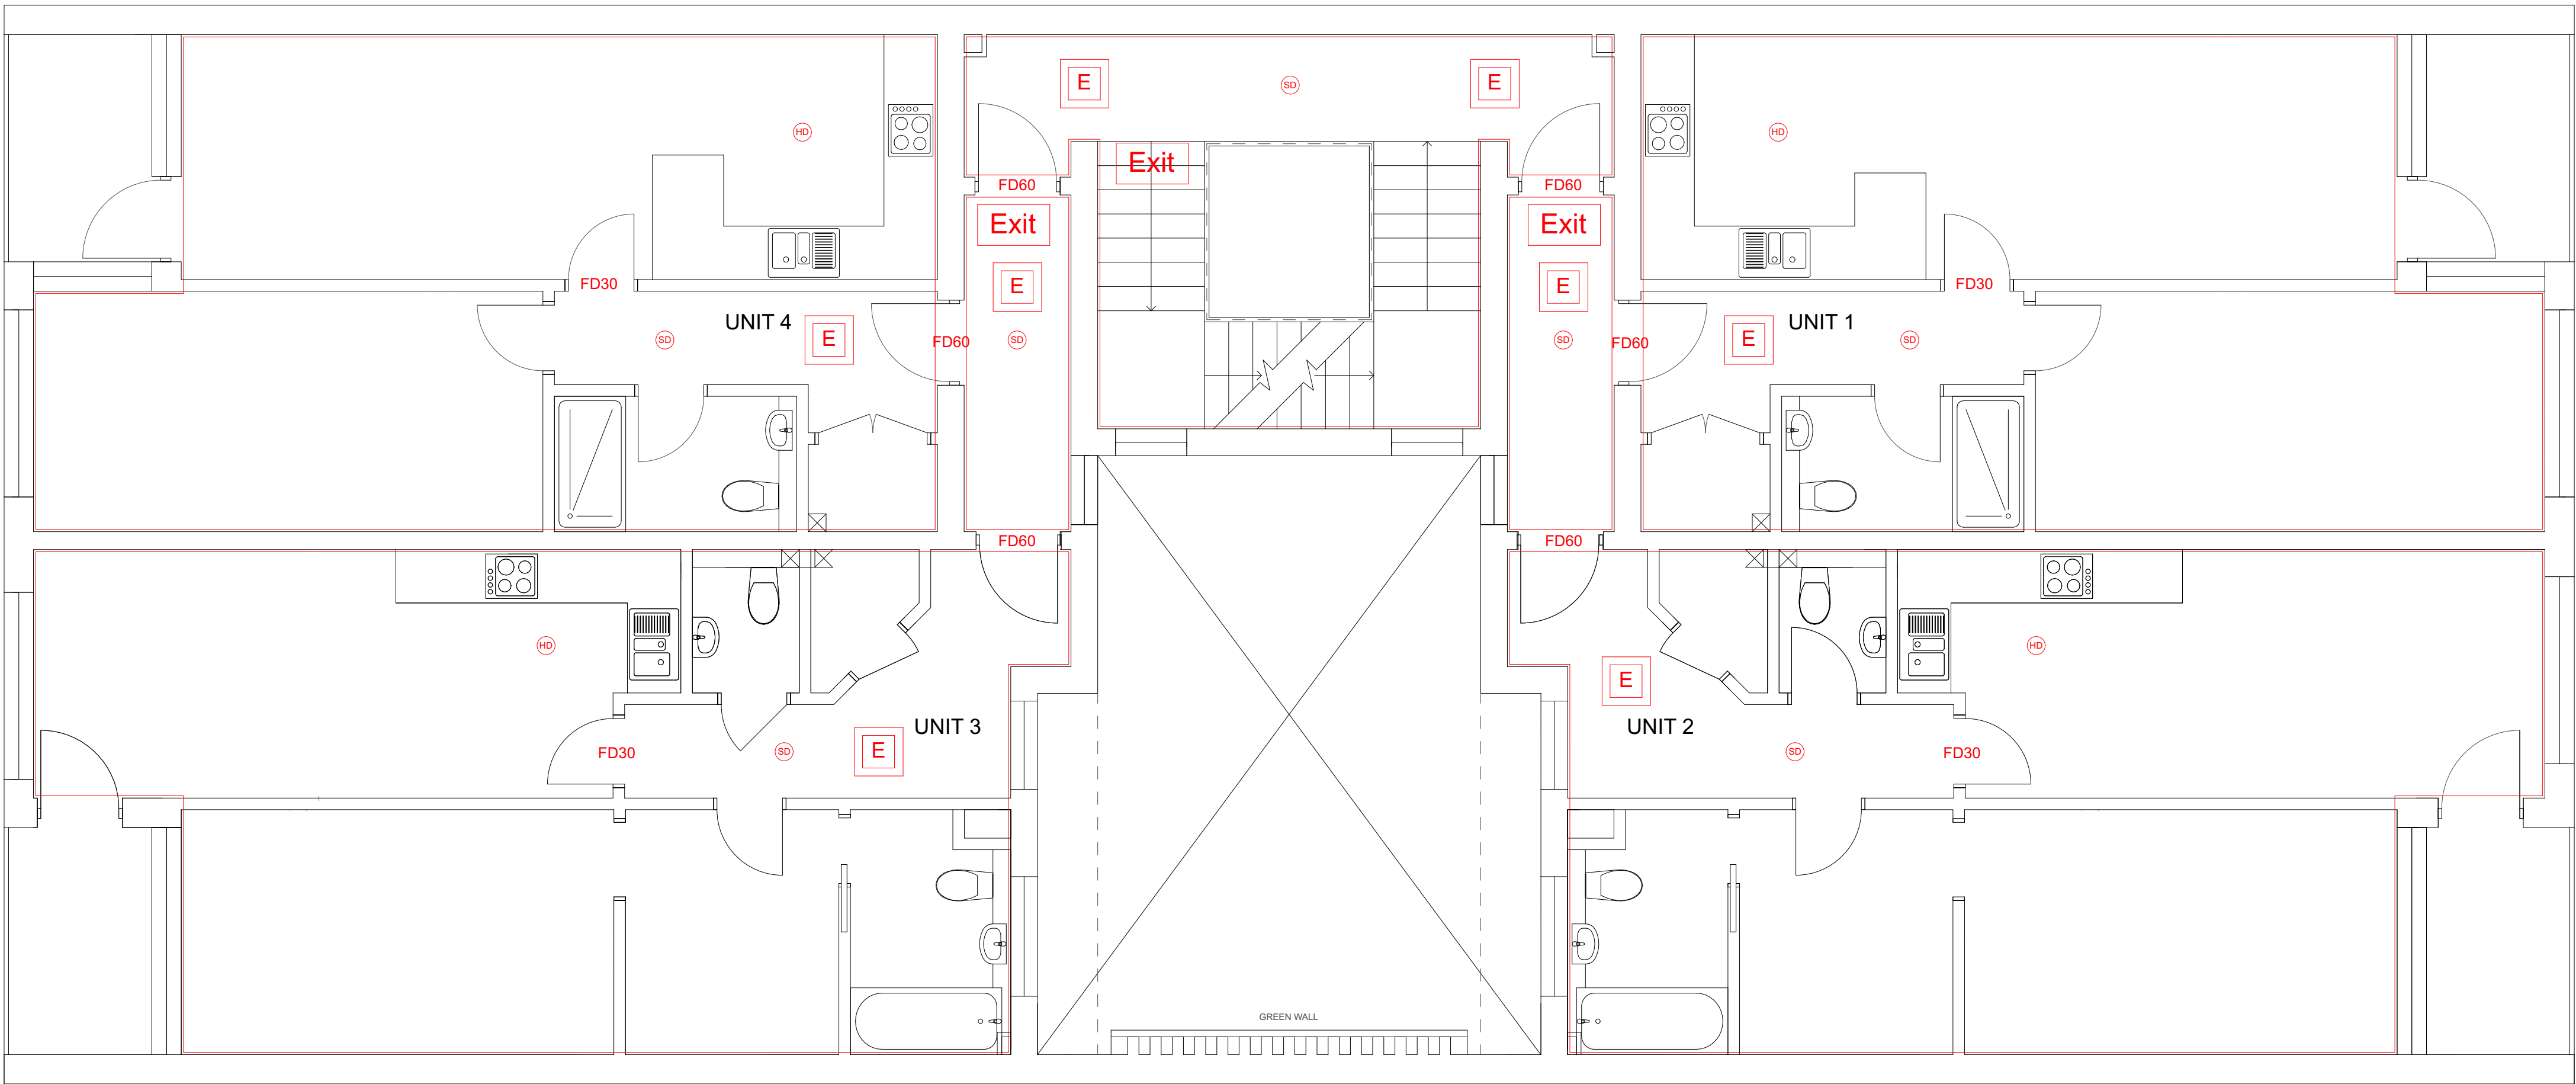


Proposed First Floor Plan 1:50

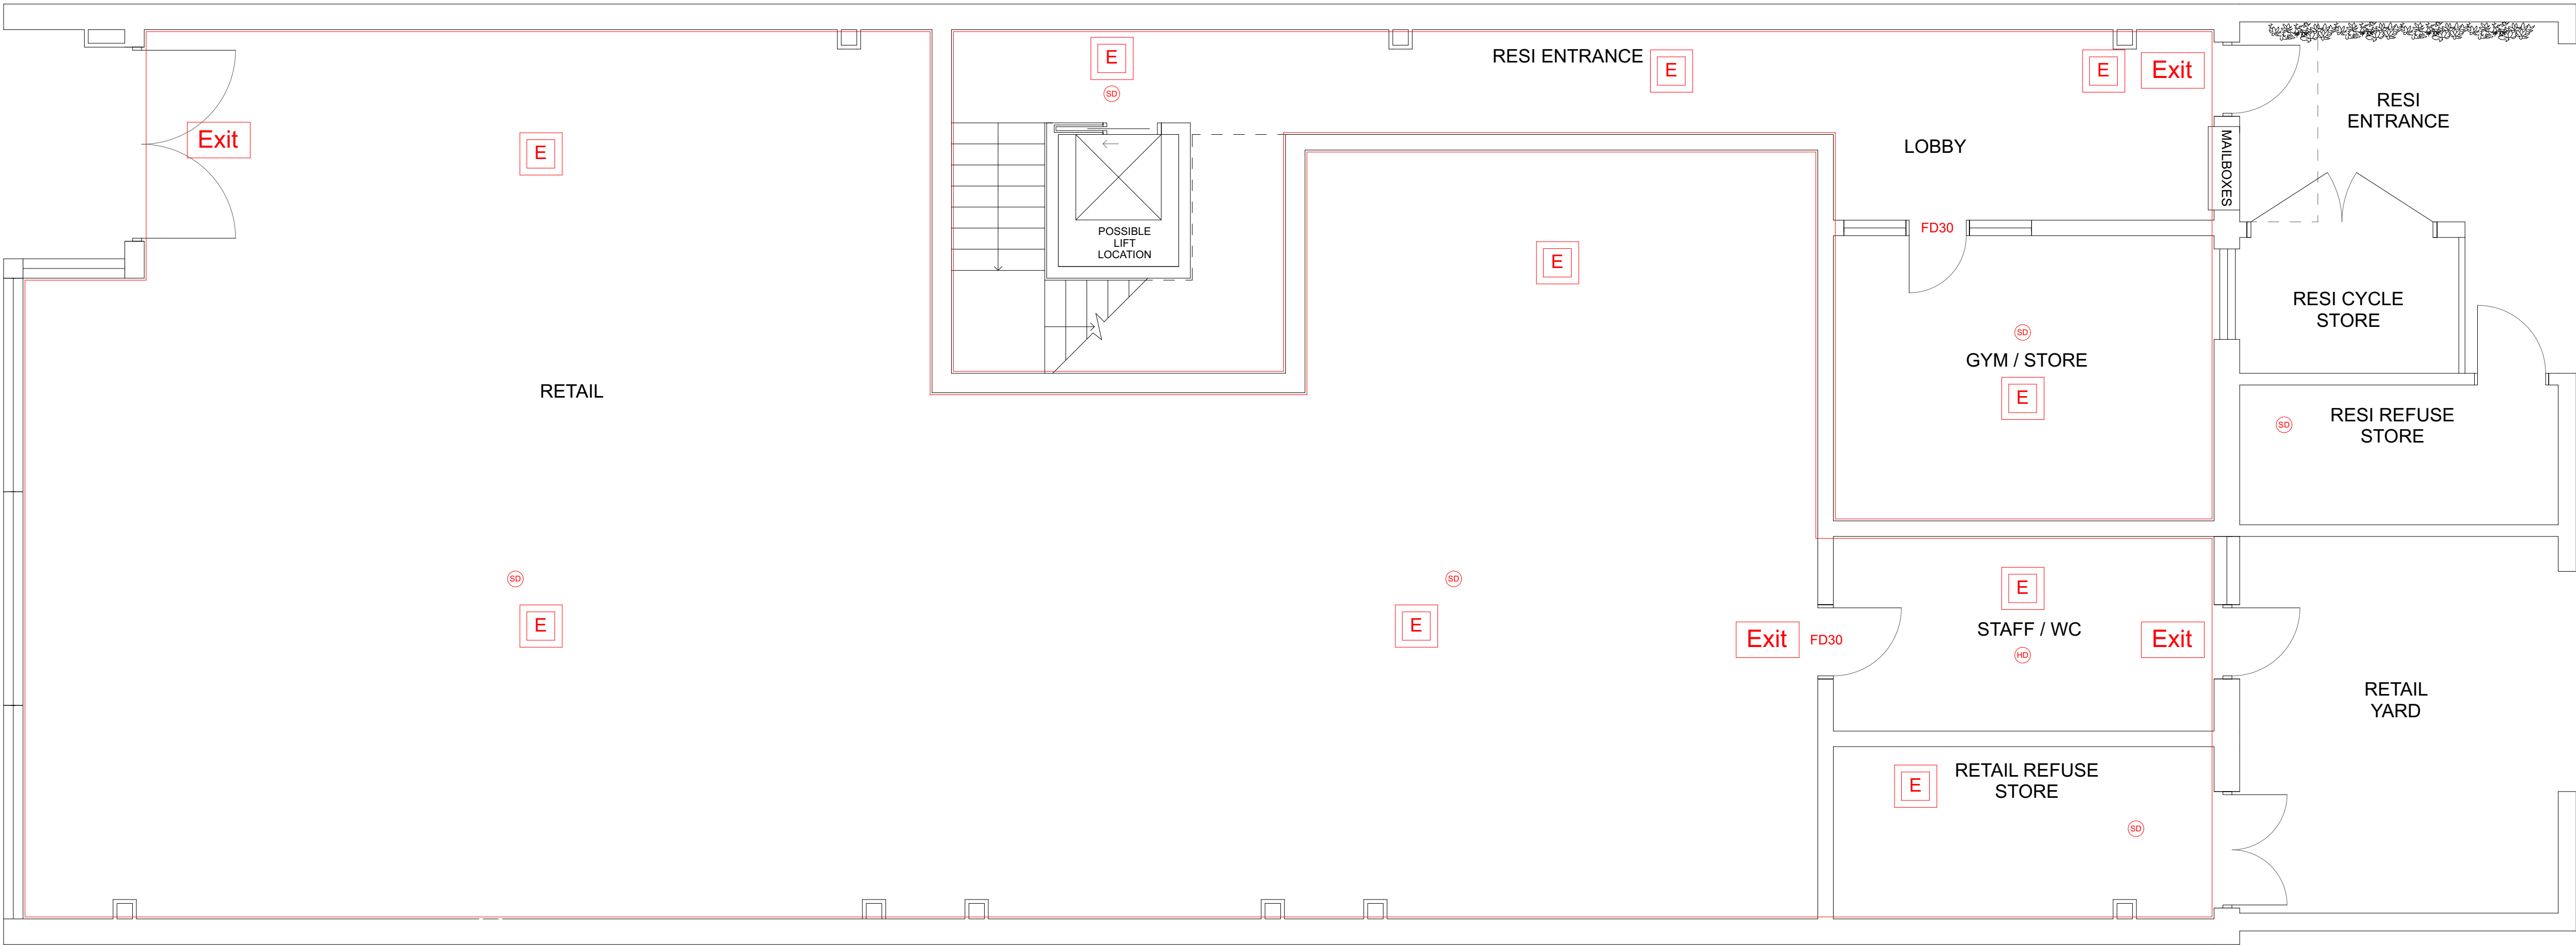

Proposed Ground Floor Plan 1:50

- E** Emergency version of light fitting
- 1 hour fire separation**
- FD30** 30 minutes fire door
- FD60** 60 minutes fire door
- Exit** Fire Exit signs: Illuminate / photoluminescent + emergency lighting
- SD** Smoke Detector
- HD** Heat Detector



SURVEY
DRAWING

- NOTES:
- © Copyright of this drawing remains the property of Buchan Rum Architects Ltd and should not be reproduced in full or parts or re-issued without written permission from Buchan Rum Architects Ltd
 - These drawings must be read in conjunction with the structural engineers drawings & details, and with all other consultants, sub-contractor and specialist's drawings & details.
 - All dimensions are in millimetres, unless stated otherwise.
 - All goods materials workmanship to conform with current building regulations BSS and COP's.
 - All dimensions must be checked on site, and any discrepancies verified with the architect.
 - Do not scale from the drawing.
 - Any discrepancies between the drawings, details and specification must be reported to the architect immediately before work is put in hand.
 - All works to be carried out in full accordance with current Building Regulations, British Standards and all Health & Safety Regulations.
 - If in doubt please ask.

REV	DATE	COMMENT

Client

Site address

68-70 Church Walk
Burgess Hill

Job Title
M&Co

Drawing Title
PROPOSED GROUND & FIRST FLOOR
FIRE STRATEGY PLANS

buchan rum
9 SAVILL ROAD
LINDFIELD
WEST SUSSEX RH162NY
E : info@buchanrumarchitects.co.uk

Scale	Size
1:50	A1
Date	Des By
04/2024	BRA
Drawing number	Rev.
PL_500_00	05

