
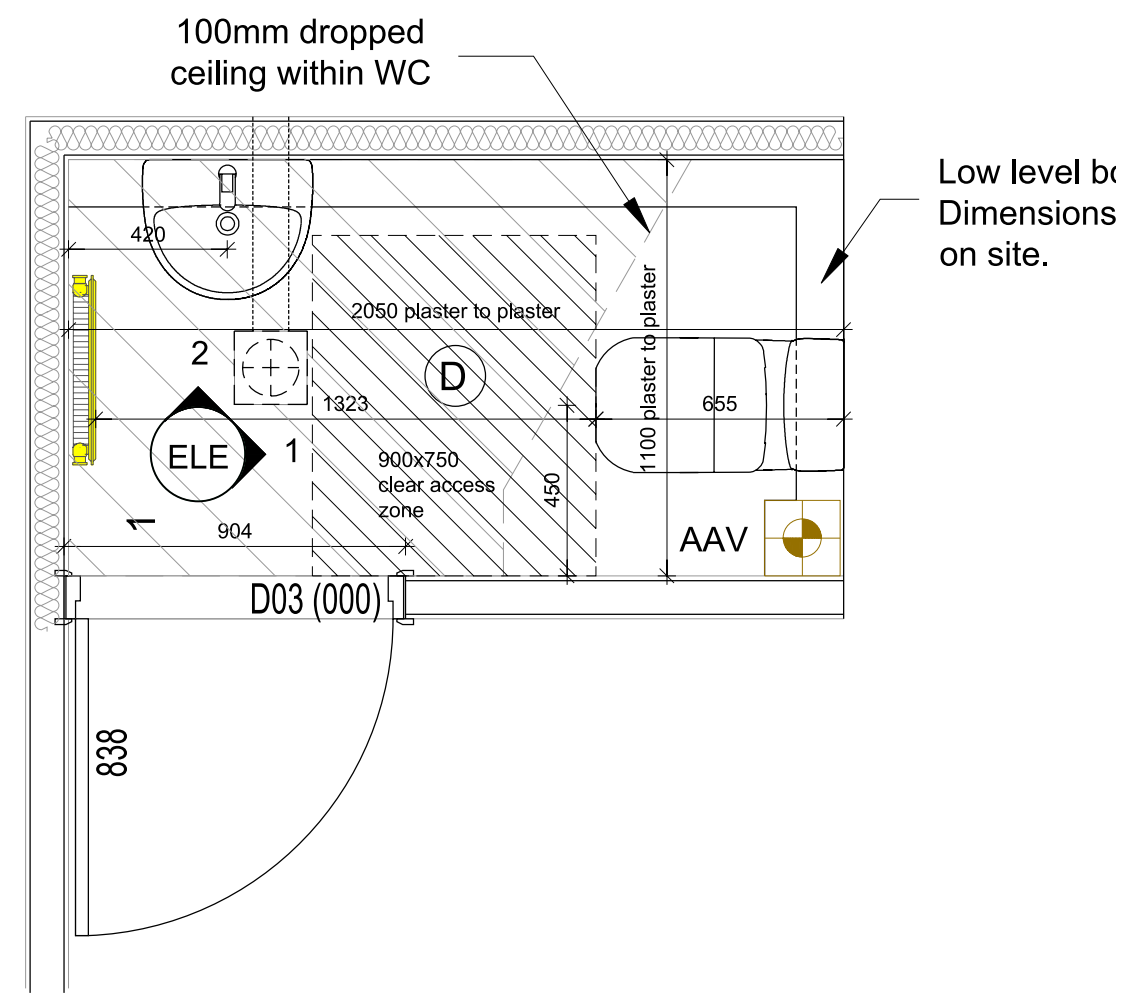
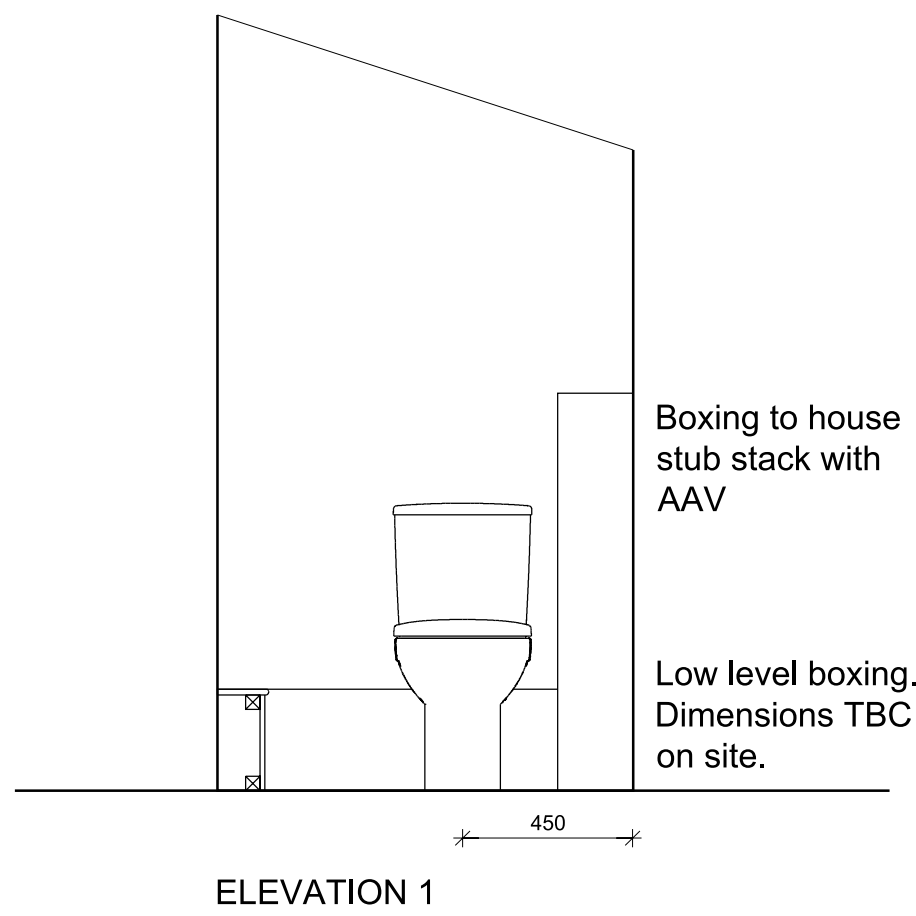


HOLT, THETFORD, ROCKINGHAM HOUSE TYPE
CLOAKROOM LAYOUT

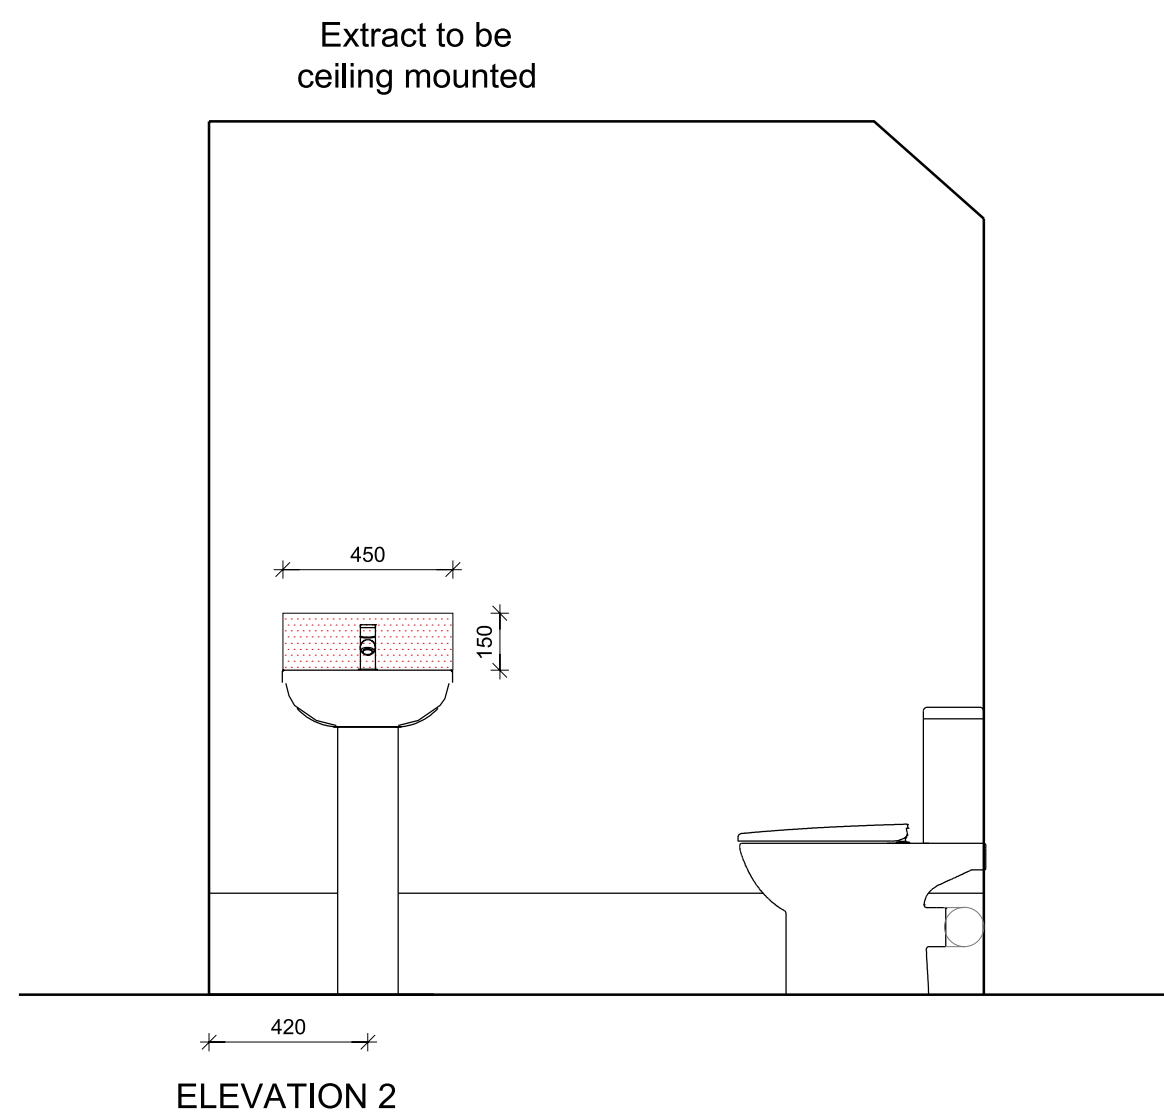




M4(2) COMPLIANCE. HOLT HOUSE TYPE ONLY

NOT ALL PLOTS OF THIS HOUSE TYPE ARE REQUIRED TO MEET M4(2) COMPLIANCE.

PLEASE REFER TO TECHNICAL SITE PLAN WHICH IDENTIFIES PLOTS THAT ARE TO ACHIEVE M4(2) COMPLIANCE

All walls, ducts and boxings to the WC/cloakroom, bathroom and shower room should be strong enough to support grab rails, seats and other adaptations that could impose a load of up to 1.5kN/m². Additional sanitary facilities beyond those required to comply with this guidance need not have strengthened walls. This can be achieved by the addition of plywood pattressing & timber noggin supports fixed within studs to ensure the pattress finishes flush with studwork allowing finished plasterboard to plasterboard dimensions remain.

NOTE - The loading for strengthened walls is considered suitable for many types of adaptations but additional localised strengthening maybe required of adaptations are fitted that impose high point loads.

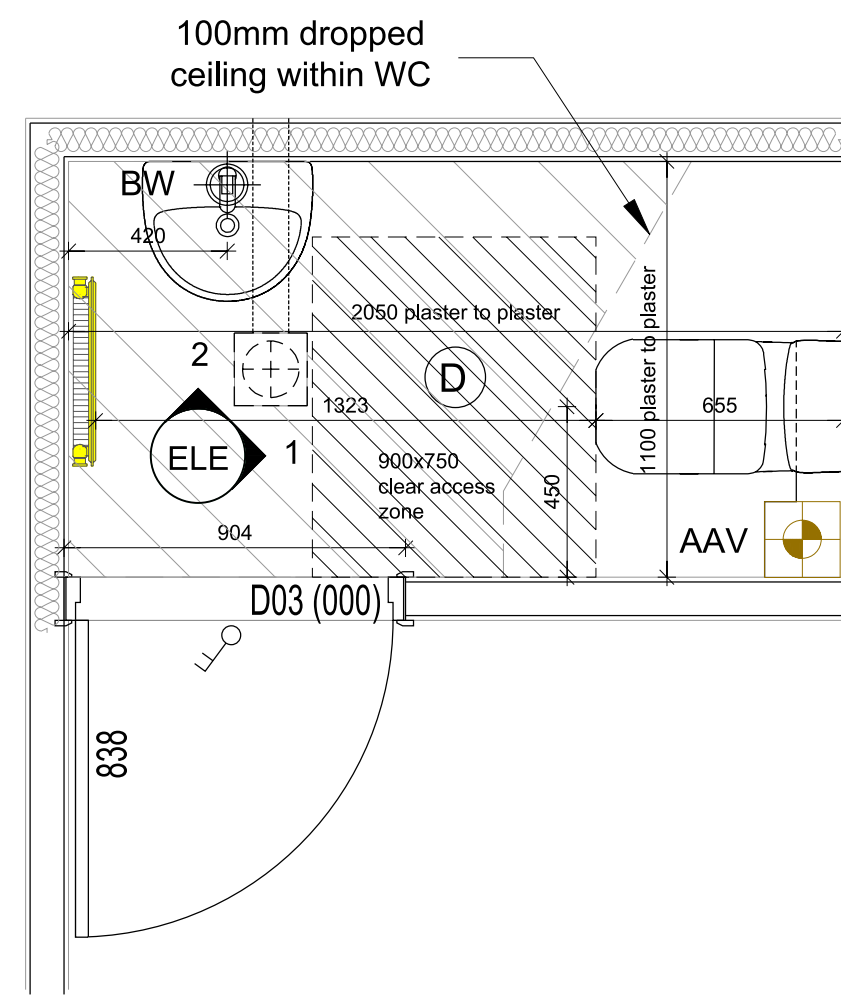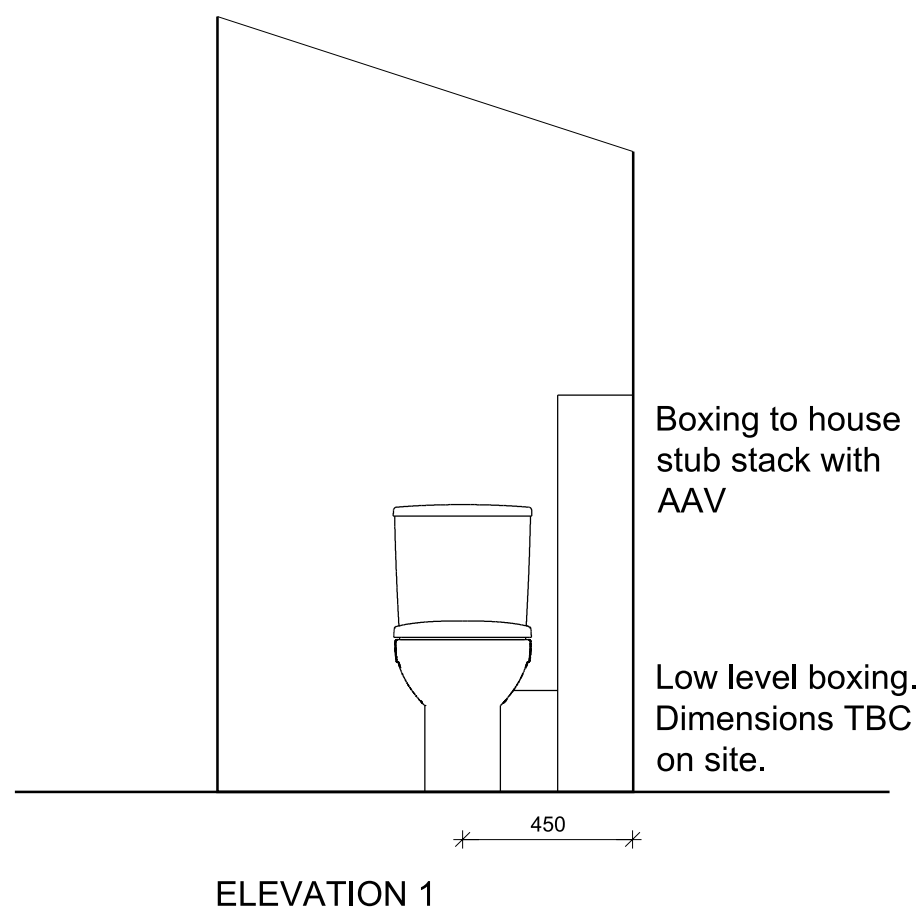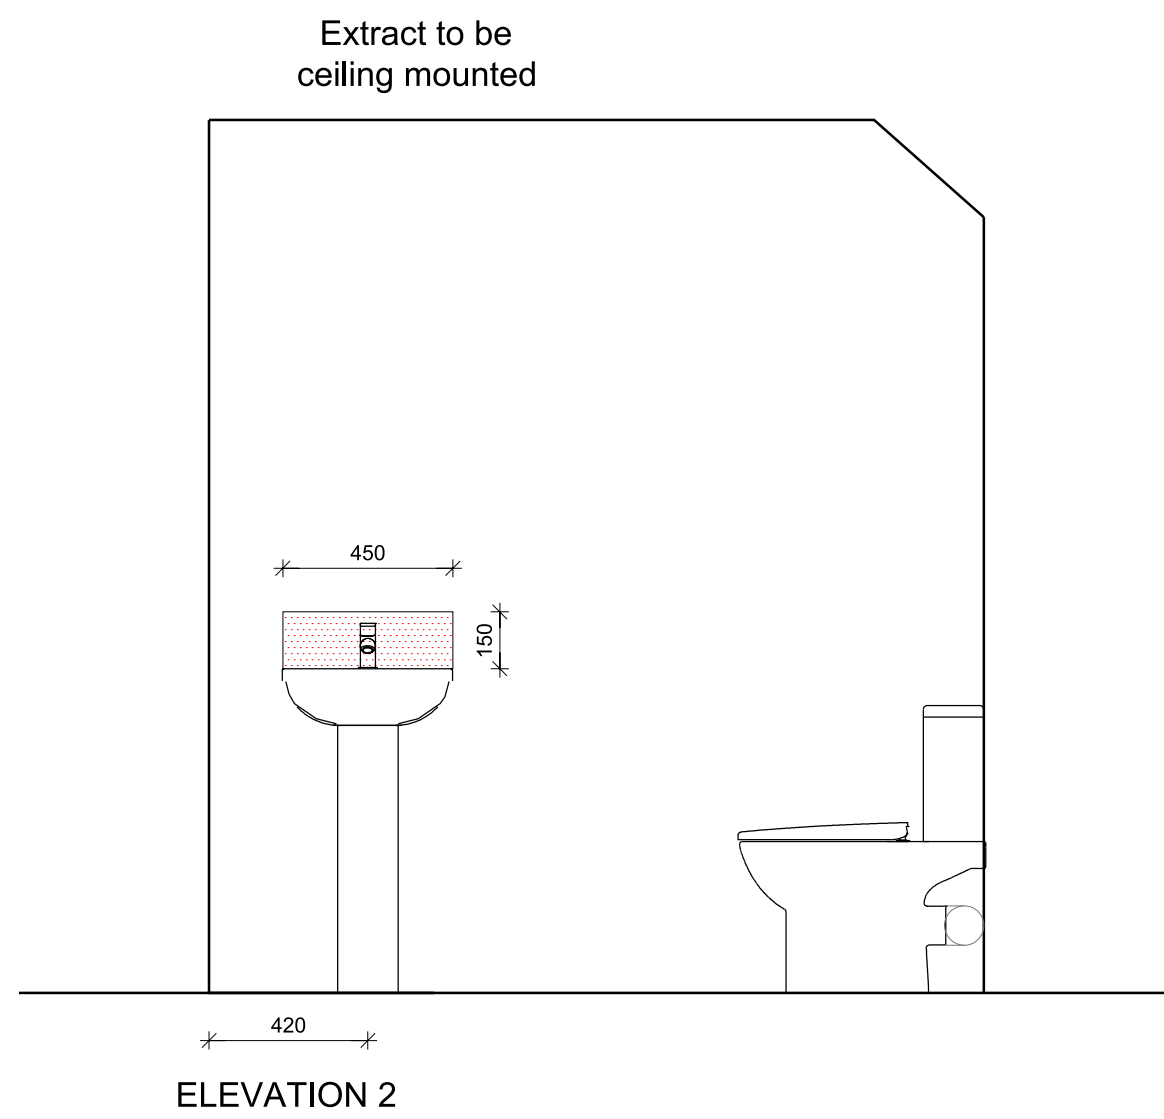

DIRECT DRAINAGE CONNECTION

ALL DIMENSIONS ARE TAKEN FROM INTERNAL PLASTER, TO CENTER LINE OF APPLIANCE

ALL DRAINAGE IN CLOAKROOM TO BE INSTALLED ABOVE FFL AND DISCHARGE INTO SVP

PLEASE REFER TO BLOCK PLANS FOR PLOTS WHICH REQUIRE ADDITIONAL BASIN POP-UP.

KEY

Tiling area (Specification TBC by client)

- THIS DRAWING MUST NOT BE SCALED.
- THIS DRAWING IS TO BE READ IN CONJUNCTION WITH ALL OTHER PROJECT DRAWINGS
- ALL DETAILS AND DRAWINGS MUST BE READ IN CONJUNCTION WITH THE PROJECT SPECIFIC CONSTRUCTION SPECIFICATION.
- BEAM AND BLOCK / RAFT FOUNDATIONS TO STRUCTURAL ENGINEER / SPECIALIST DESIGN.
- FOR DETAILS OF CAST INSITU POWERFLOATED SUSPENDED GROUND FLOOR SLAB, SEE SPECIALIST DRAWINGS.
- DATUM 1 (MASONRY CONSTRUCTION ONLY) = FINISHED FLOOR LEVEL, TOP OF FLOATING SLAB, SUSPENDED SLAB AND RAFT FOUNDATION TO BE LEVEL WITH DPC (INSULATION POSITIONED UNDER SLABS).

ABBREVIATIONS CME = CEILING MOUNTED EXTRACT FAN WME = WALL MOUNTED EXTRACT FAN G = GAS METER SVP = SOIL VENT PIPE AAV = AIR ADMITTANCE VALVE	BR = BOILER E = ELECTRIC METER GP = GAS RISER PIPE RWP = RAIN WATER PIPE
APPROVED DOCUMENT PART G (2009 EDITION) REQUIREMENTS: a) THERMOSTATIC MIXING VALVE DEVICE TO BE FITTED TO BATH IN ACCORDANCE WITH APPROVED DOCUMENT G (Apr 2010) b) WATER USAGE SHALL NOT EXCEED 125 LITRES PER PERSON PER DAY TO COMPLY WITH APPROVED DOCUMENT G (Apr 2010)	
VENTILATION REQUIREMENTS SYSTEM 3 TO BE VIA DECENTRALISED CONTINUOUS MECHANICAL EXTRACT FANS TO COMPLY WITH APPROVED DOCUMENT F, TABLE 5.1b, AIR LEAKAGE RATES TO BE SET AT A DEFAULT OF 5m³/h/m² GPa. NOTE: WC & BATHROOMS (SUITE (no window) - BOOST VIA LIGHT SWITCH WITH BUILT IN HUMIDISTAT & TIMER WC & BATHROOMS (SUITE (with window) - BOOST VIA BUILT IN HUMIDISTAT & TIMER PLUS MANUAL BOOST SWITCH (NOT LIGHT SWITCH)	

CO-ALARM, TO BE MOUNTED BETWEEN 1-3m FROM THE EDGE OF THE FUEL BURNING APPLIANCE. ALARM NOT TO BE FITTED IN A STORE/CLOSET, DIRECTLY ABOVE A SINK/COOKER OR NEXT TO A DOOR/WINDOW OR ANYWHERE THAT COULD BE AFFECTED BY DRAUGHTS. NOTE: IN ALL CASES LOCATIONS TO BE AGREED WITH THE GAS SAFE REGISTERED ENGINEER.

Notes – Copyright in this drawing remains the property of BM3 Architecture Limited. – Do not scale this drawing. Work to figured dimensions only. – Contractors and consultants are to advise BM3 Architecture Limited of any discrepancies. IMPORTANT NOTE FACADE TREATMENT INDICATED ON THIS DRAWING IS INDICATIVE ONLY. PLEASE REFER TO PLOT SPECIFIC BLOCK PLANS AND BLOCK ELEVATIONS FOR EXTERNAL WALL TREATMENTS / MATERIALS																							
<table><tr><th>Revision</th><th>Date</th><th>By</th><th>Chkd</th></tr><tr><td>P1</td><td>14.01.25</td><td>DA</td><td>CF</td></tr><tr><td colspan="4">Preliminary first issue.</td></tr><tr><td>P2</td><td>14.01.26</td><td>CF</td><td>JJ</td></tr><tr><td colspan="4">M4(2) compliance notes added</td></tr></table>				Revision	Date	By	Chkd	P1	14.01.25	DA	CF	Preliminary first issue.				P2	14.01.26	CF	JJ	M4(2) compliance notes added			
Revision	Date	By	Chkd																				
P1	14.01.25	DA	CF																				
Preliminary first issue.																							
P2	14.01.26	CF	JJ																				
M4(2) compliance notes added																							
PRELIMINARY																							
Client 																							
Project BURGESS HILL FAIRBRIDGE WAY																							
C/Site Element																							
Drawing HOLT, THETFORD, ROCKINGHAM HOUSE TYPE CLOAKROOM LAYOUT																							
Drawn by DA		Checked CF																					
Scale 1:20@A1		Dated 14.01.25																					
Job No. 71978	Drawing No. CLOAK-150	Revision P2																					
Birmingham Office 28 Pickford Street, Digbeth, Birmingham, B5 5QH T: 0121 633 0000 F: 0121 633 0300 E: design@bm3.co.uk																							
BM3																							