

El
Sub Sta


Mascotte

The Gables

Garage

Chelsea Cottage

B2028 TURNERS

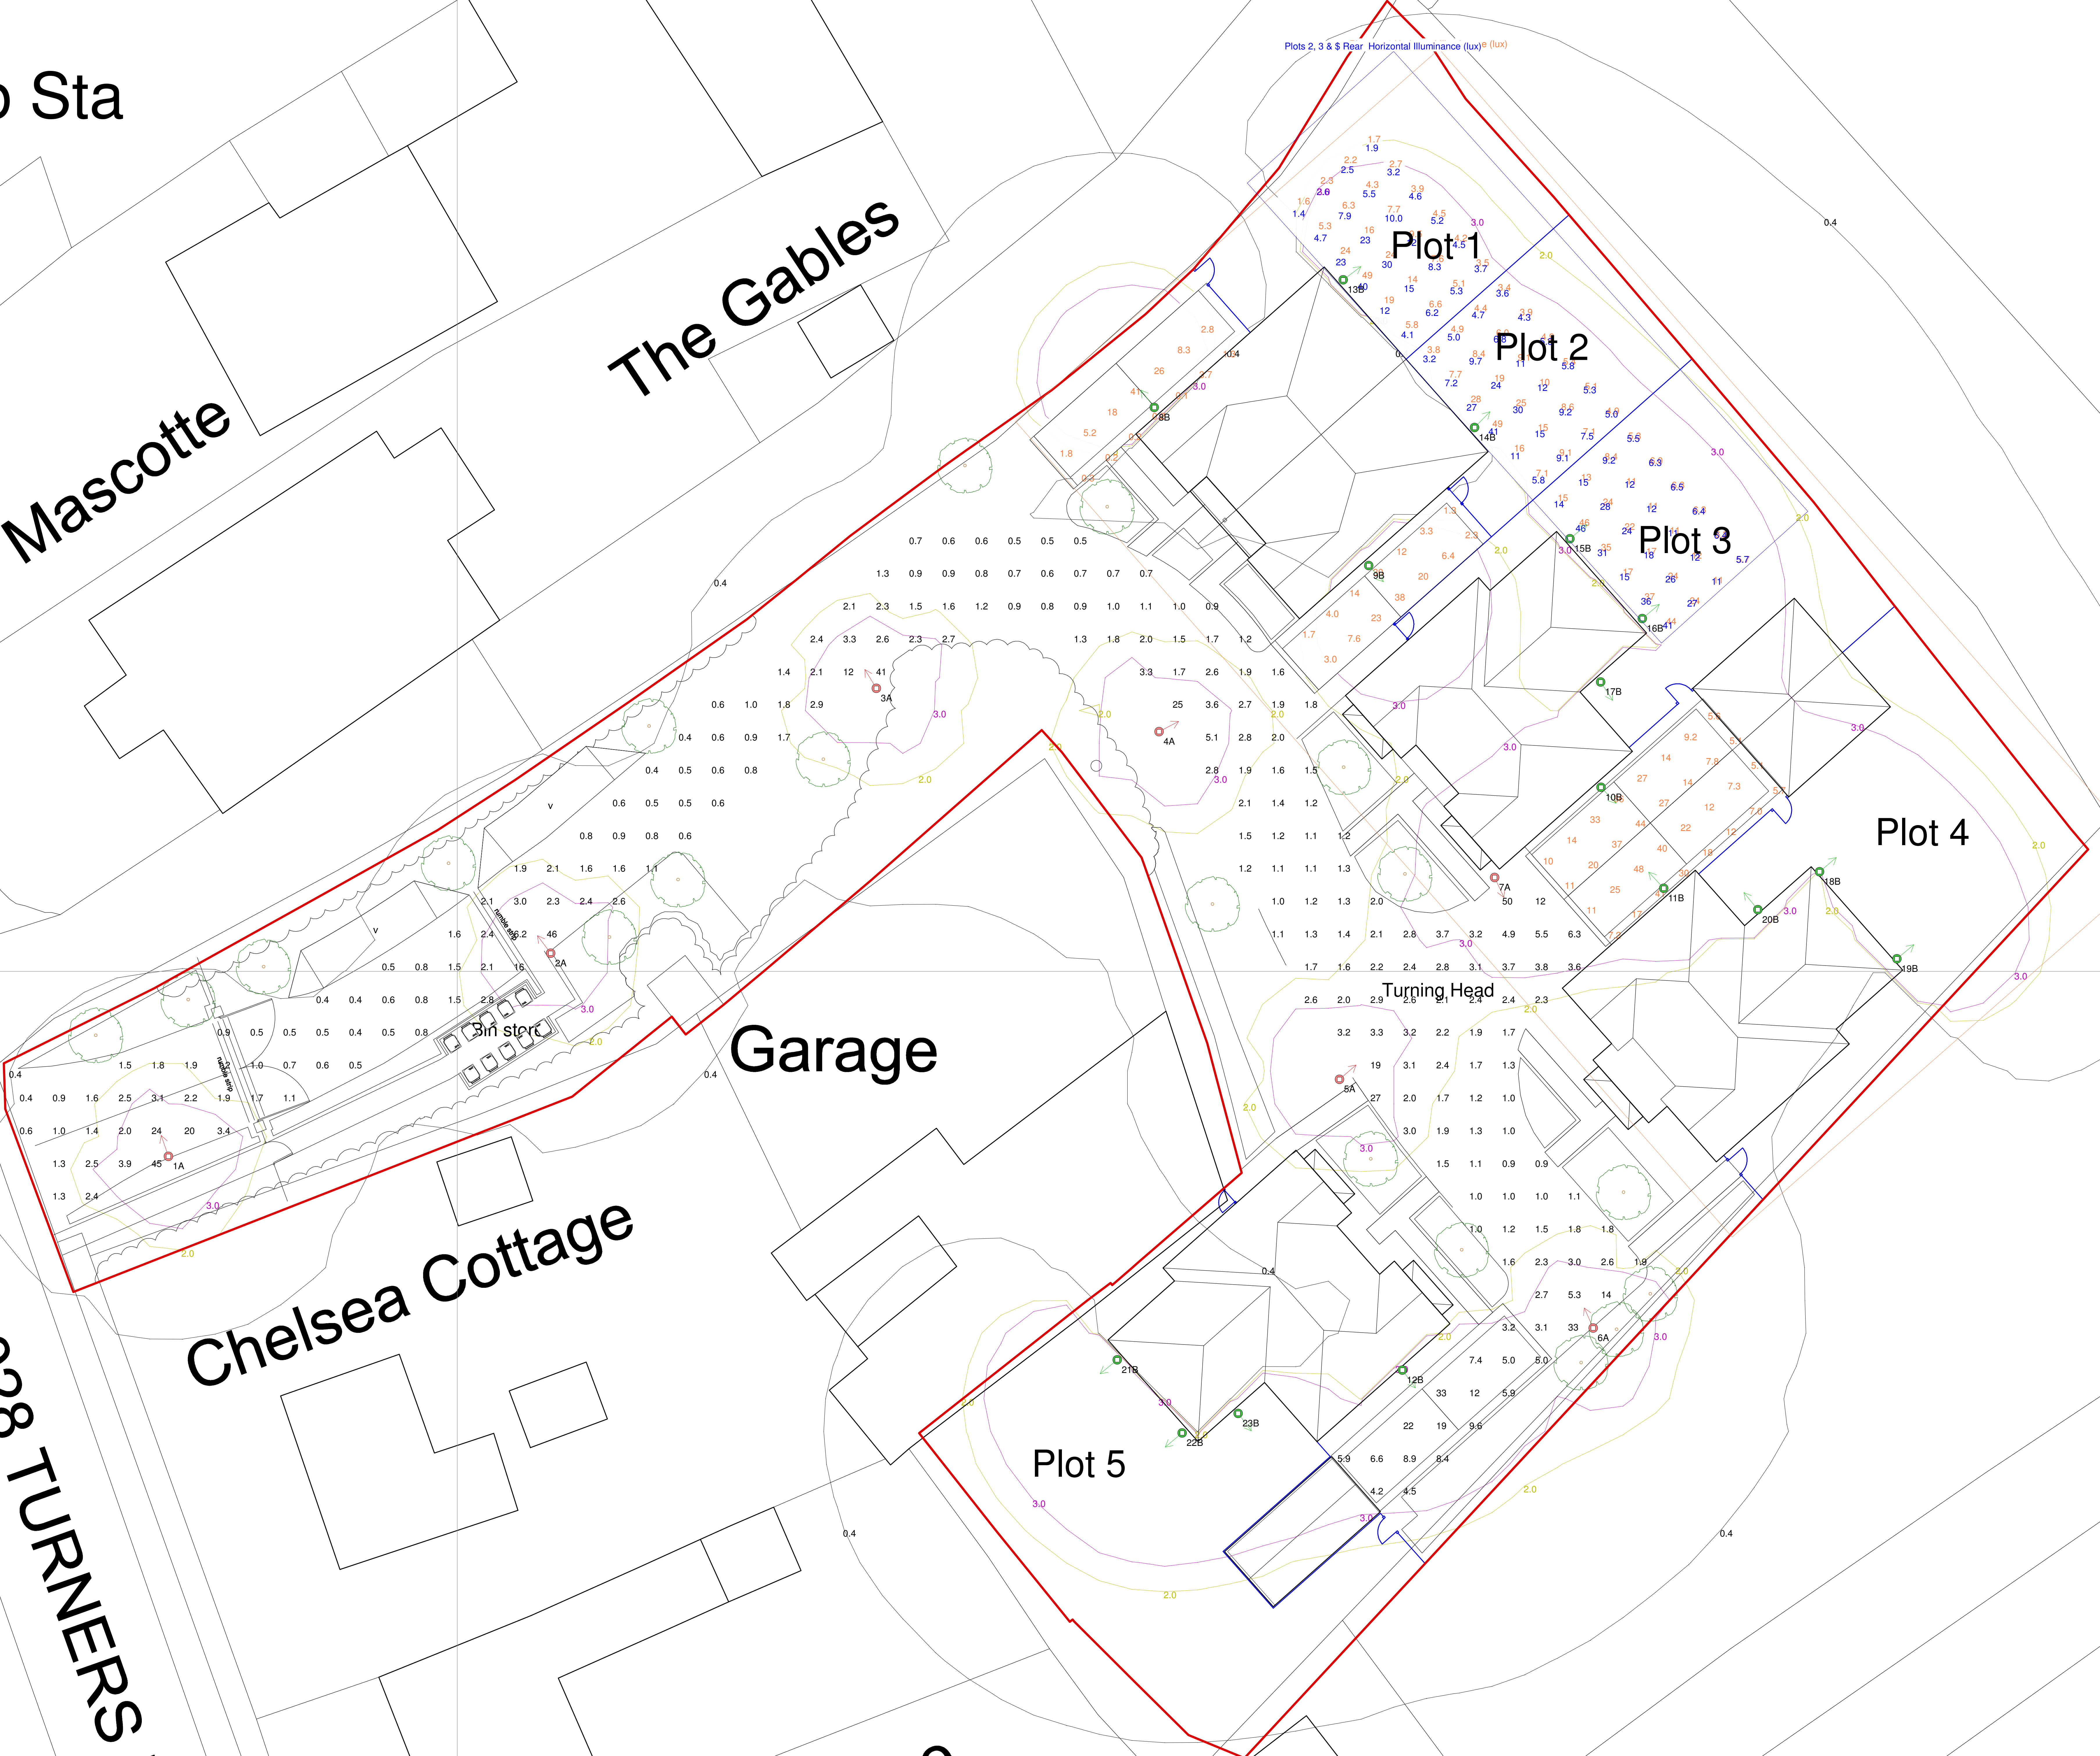

gemma lighting	
PROJECT NAME: Wheelwrights Place, Crawley Down	
PROJECT No: ZT170326-1 v2	
SCALE: 1:100	DATE: 9 April 2026
CALCULATION: Horizontal Illuminance (lux)	
DESIGNER: Lucien McQueen	
PREPARED BY:	
FILE NAME: K:\A - QUOTATIONS LIVE\JW Straton\Lighting Plan\Wheelwrights Place\wheelwrights v2.rvt	
Results Site	
Eav	3.75
Emin	0.39
Emax	50.48
Emin/Emax	0.01
Emin/Eav	0.10
Results Access Road	
Eav	3.84
Emin	0.41
Emax	49.65
Emin/Emax	0.01
Emin/Eav	0.11
Results Plot 1 - 2	
Eav	15.89
Emin	0.14
Emax	50.25
Emin/Emax	0.00
Emin/Eav	0.01
Results Plot 2, 3 & 5 Floor	
Eav	12.83
Emin	1.41
Emax	45.74
Emin/Emax	0.03
Emin/Eav	0.11