


NOTES:
ALL LEVELS, ANGLES AND DIMENSIONS TO BE CHECKED
ON SITE PRIOR TO COMMENCEMENT OF WORKS.


THIS DRAWING IS TO BE READ IN CONJUNCTION WITH
ALL RELEVANT STRUCTURAL ENGINEERS AND
MECHANICAL AND ELECTRICAL ENGINEERS DRAWINGS,
DETAILS AND SPECIFICATIONS.




Image to proposed location, adjacent to plant room
and Sub Station

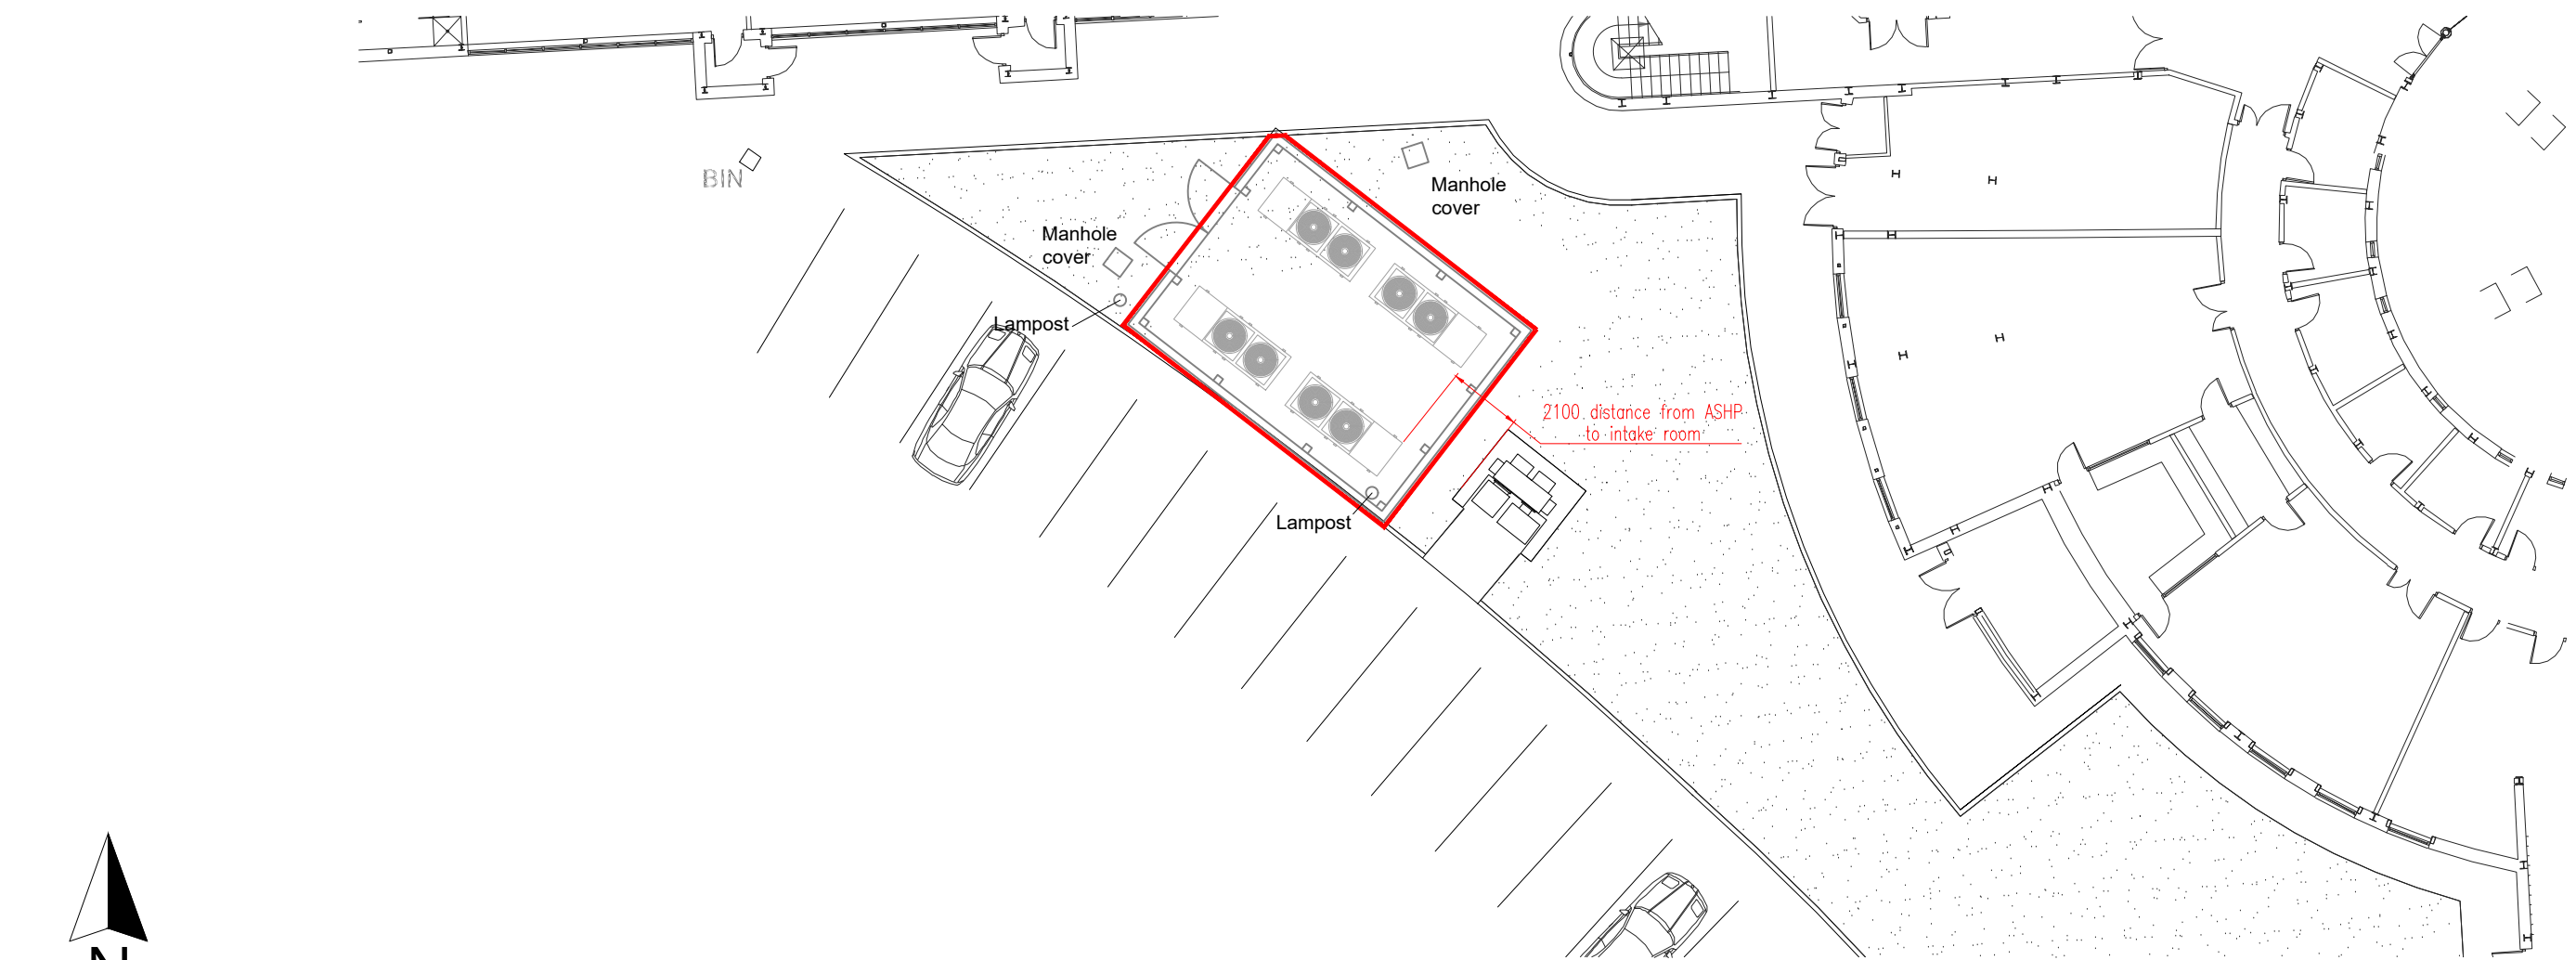


PROPOSED ASHP INSTALLATION - PARTIAL BLOCK PLAN
SCALE 1:200
NOTE: APPLICATION AREA OUTLINED IN RED
Scale 1:200
20 (metres)

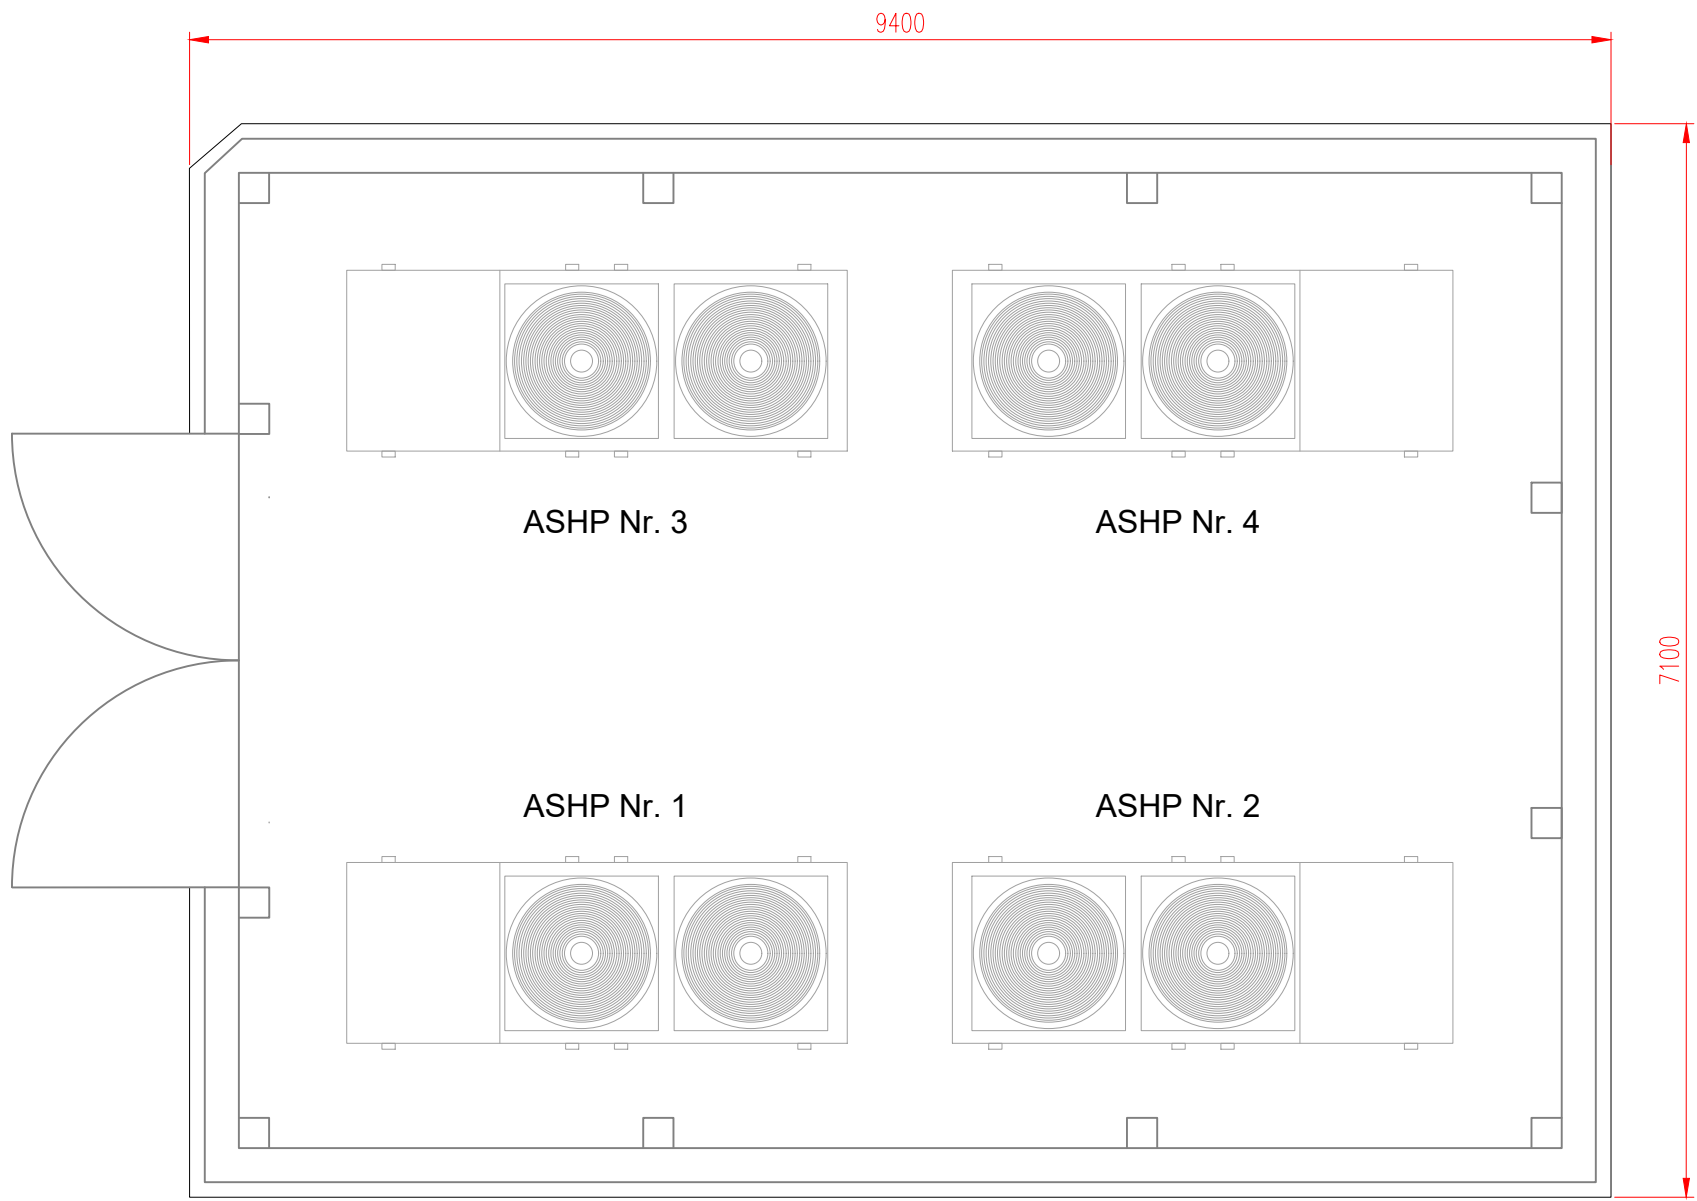


ASHP Enclosure - Plan, enclosing 4Nr. ASHPS positioned as shown.

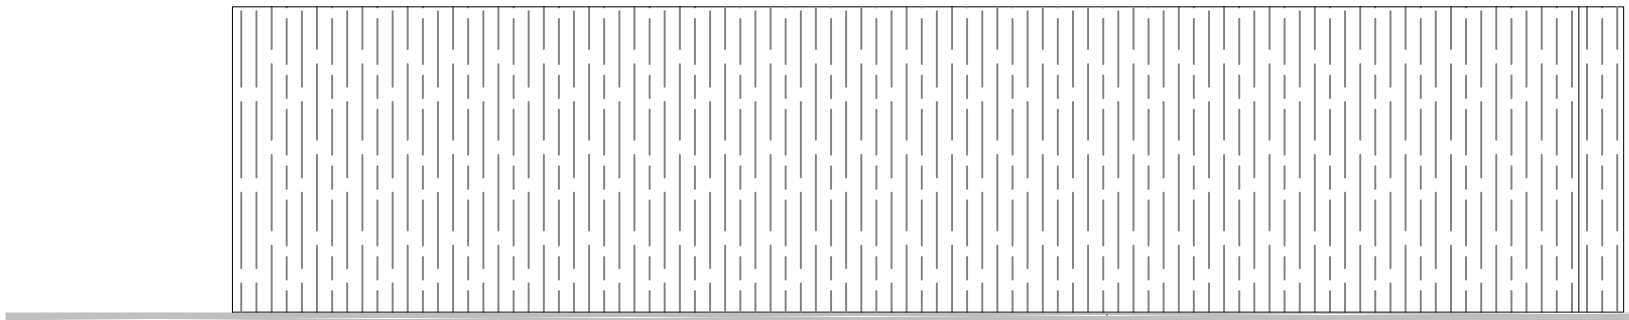


North Elevation

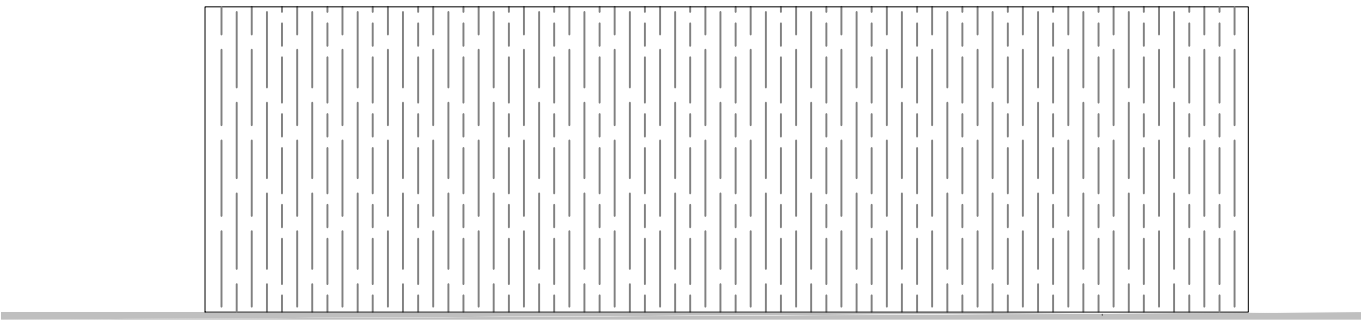


East Elevation

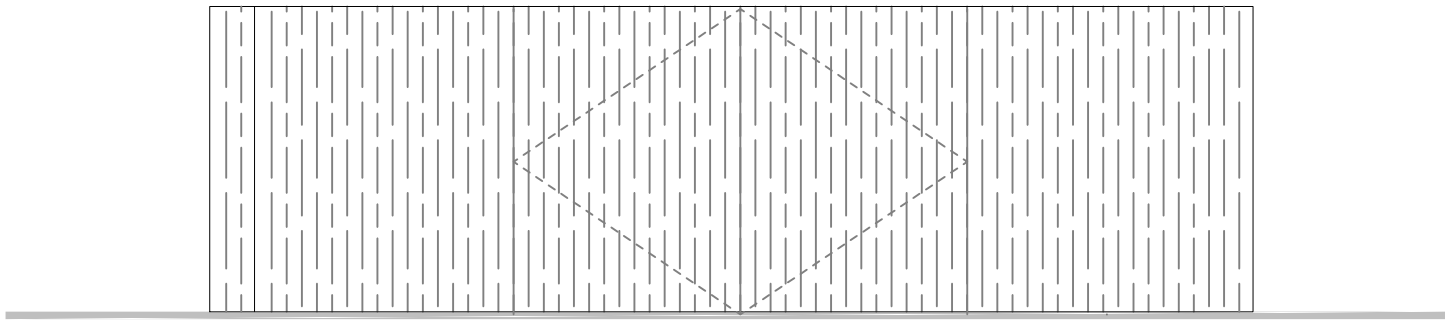


West Elevation

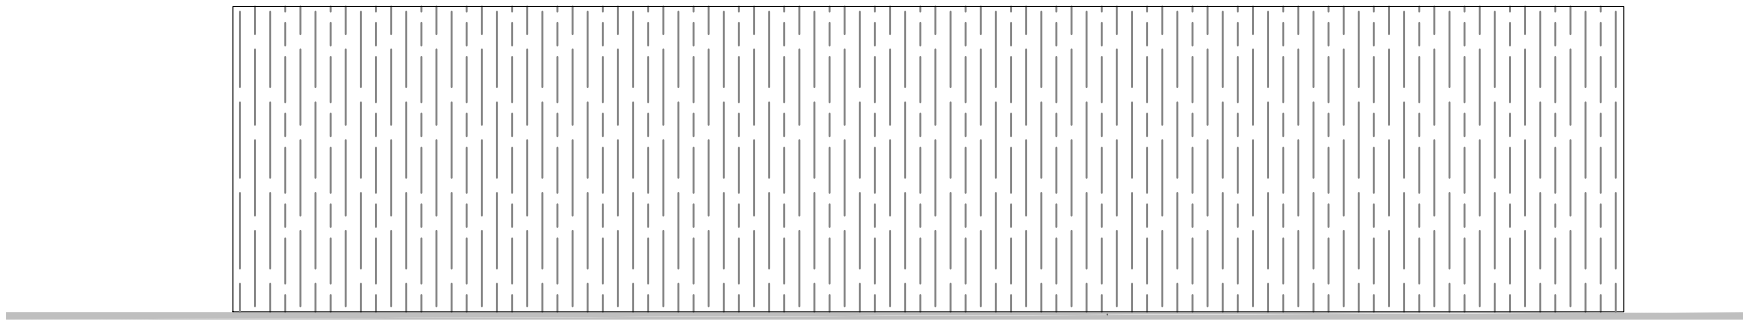

South Elevation

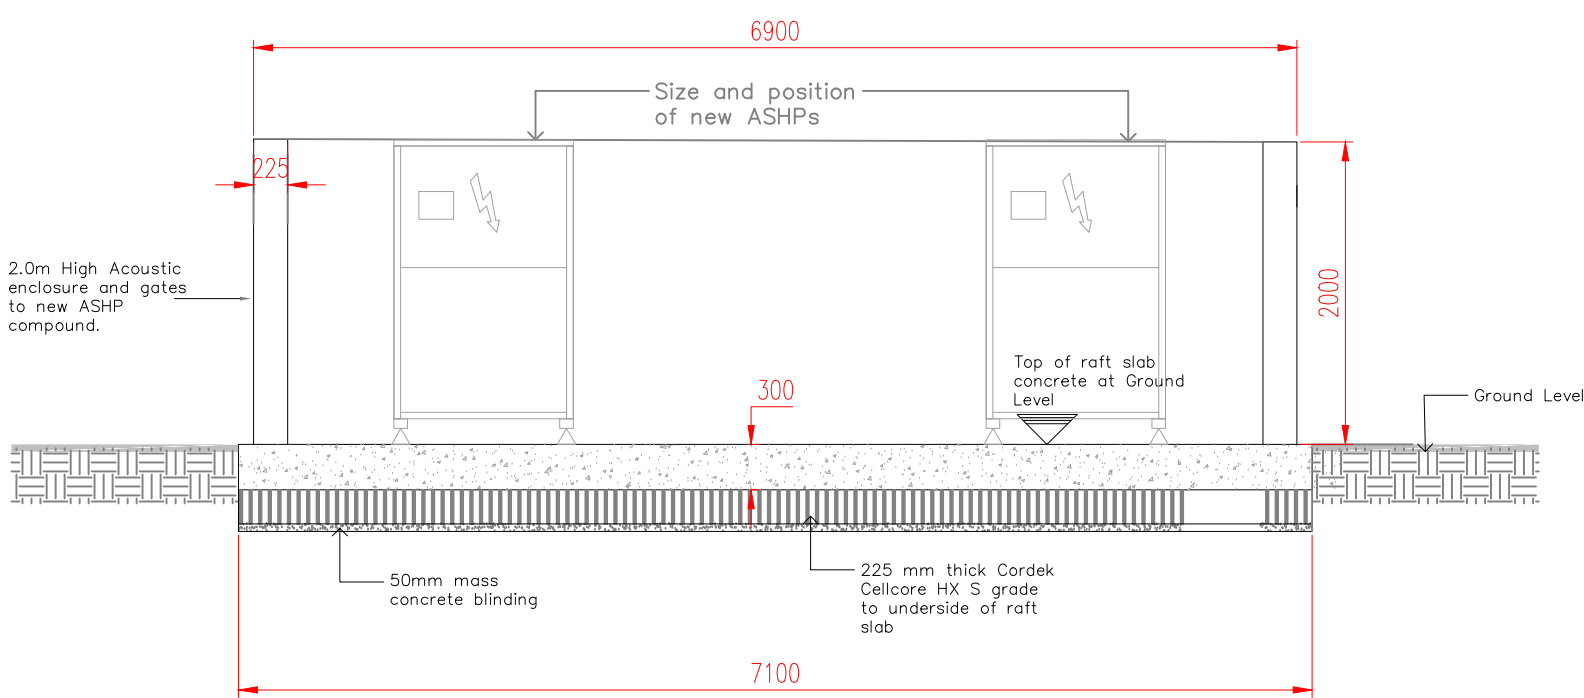

Acoustic Enclosure Typical Section

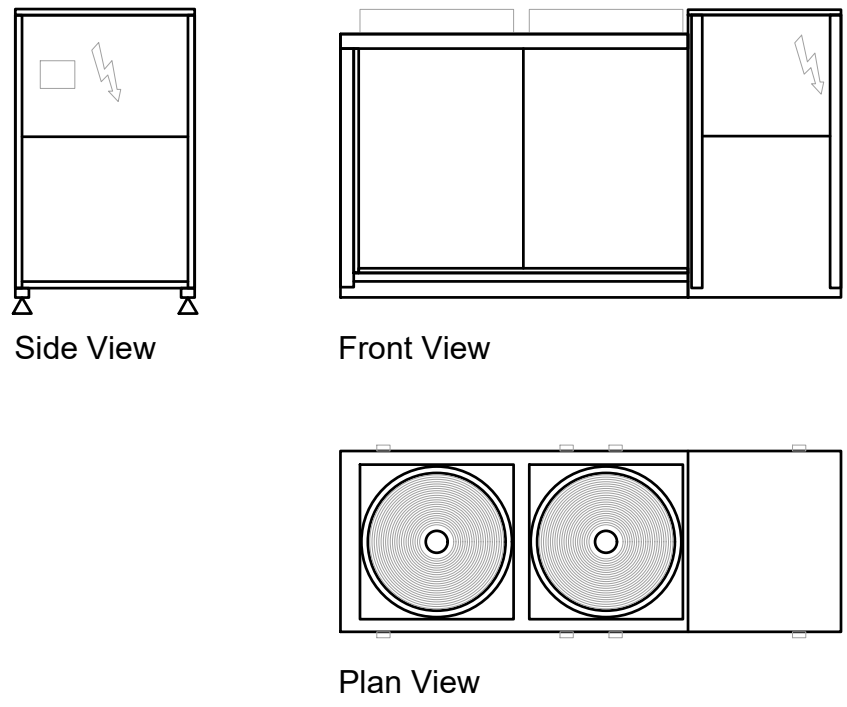

Detailed views of ASHP units.

PROPOSED ASHP INSTALLATION
SCALE 1:50

Scale 1:50
5 (metres)

PLANNING

PL1 ISSUED FOR PLANNING 24/09/24 JM

Rev	Description	Date	By
-----	-------------	------	----

MAJESTY HOUSE, AVENUE WEST
SKYLINE 120, BRAINTREE
ESSEX, CM77 7AA
T: 01279 647111
W: www.barker-associates.co.uk
E: mail@barker-associates.co.uk

Client
The Headteacher & Governors St Paul's Catholic College

Project Title
AIR SOURCE HEAT PUMP INSTALLATION at
ST PAUL'S CATHOLIC COLLEGE
JANE MURRAY WAY, BURGESS HILL,
RH15 8GA

Drawing Title
PROPOSED ASHP INSTALLATION

Drawn	Checked	Scale	Date
JM	CO	1:50 @ A1	24/09/24

ARCHITECTURAL

Drawing Number		Status	Revision
P231441-BA-A1-XX-DR-A-2002		S4	PL1