


 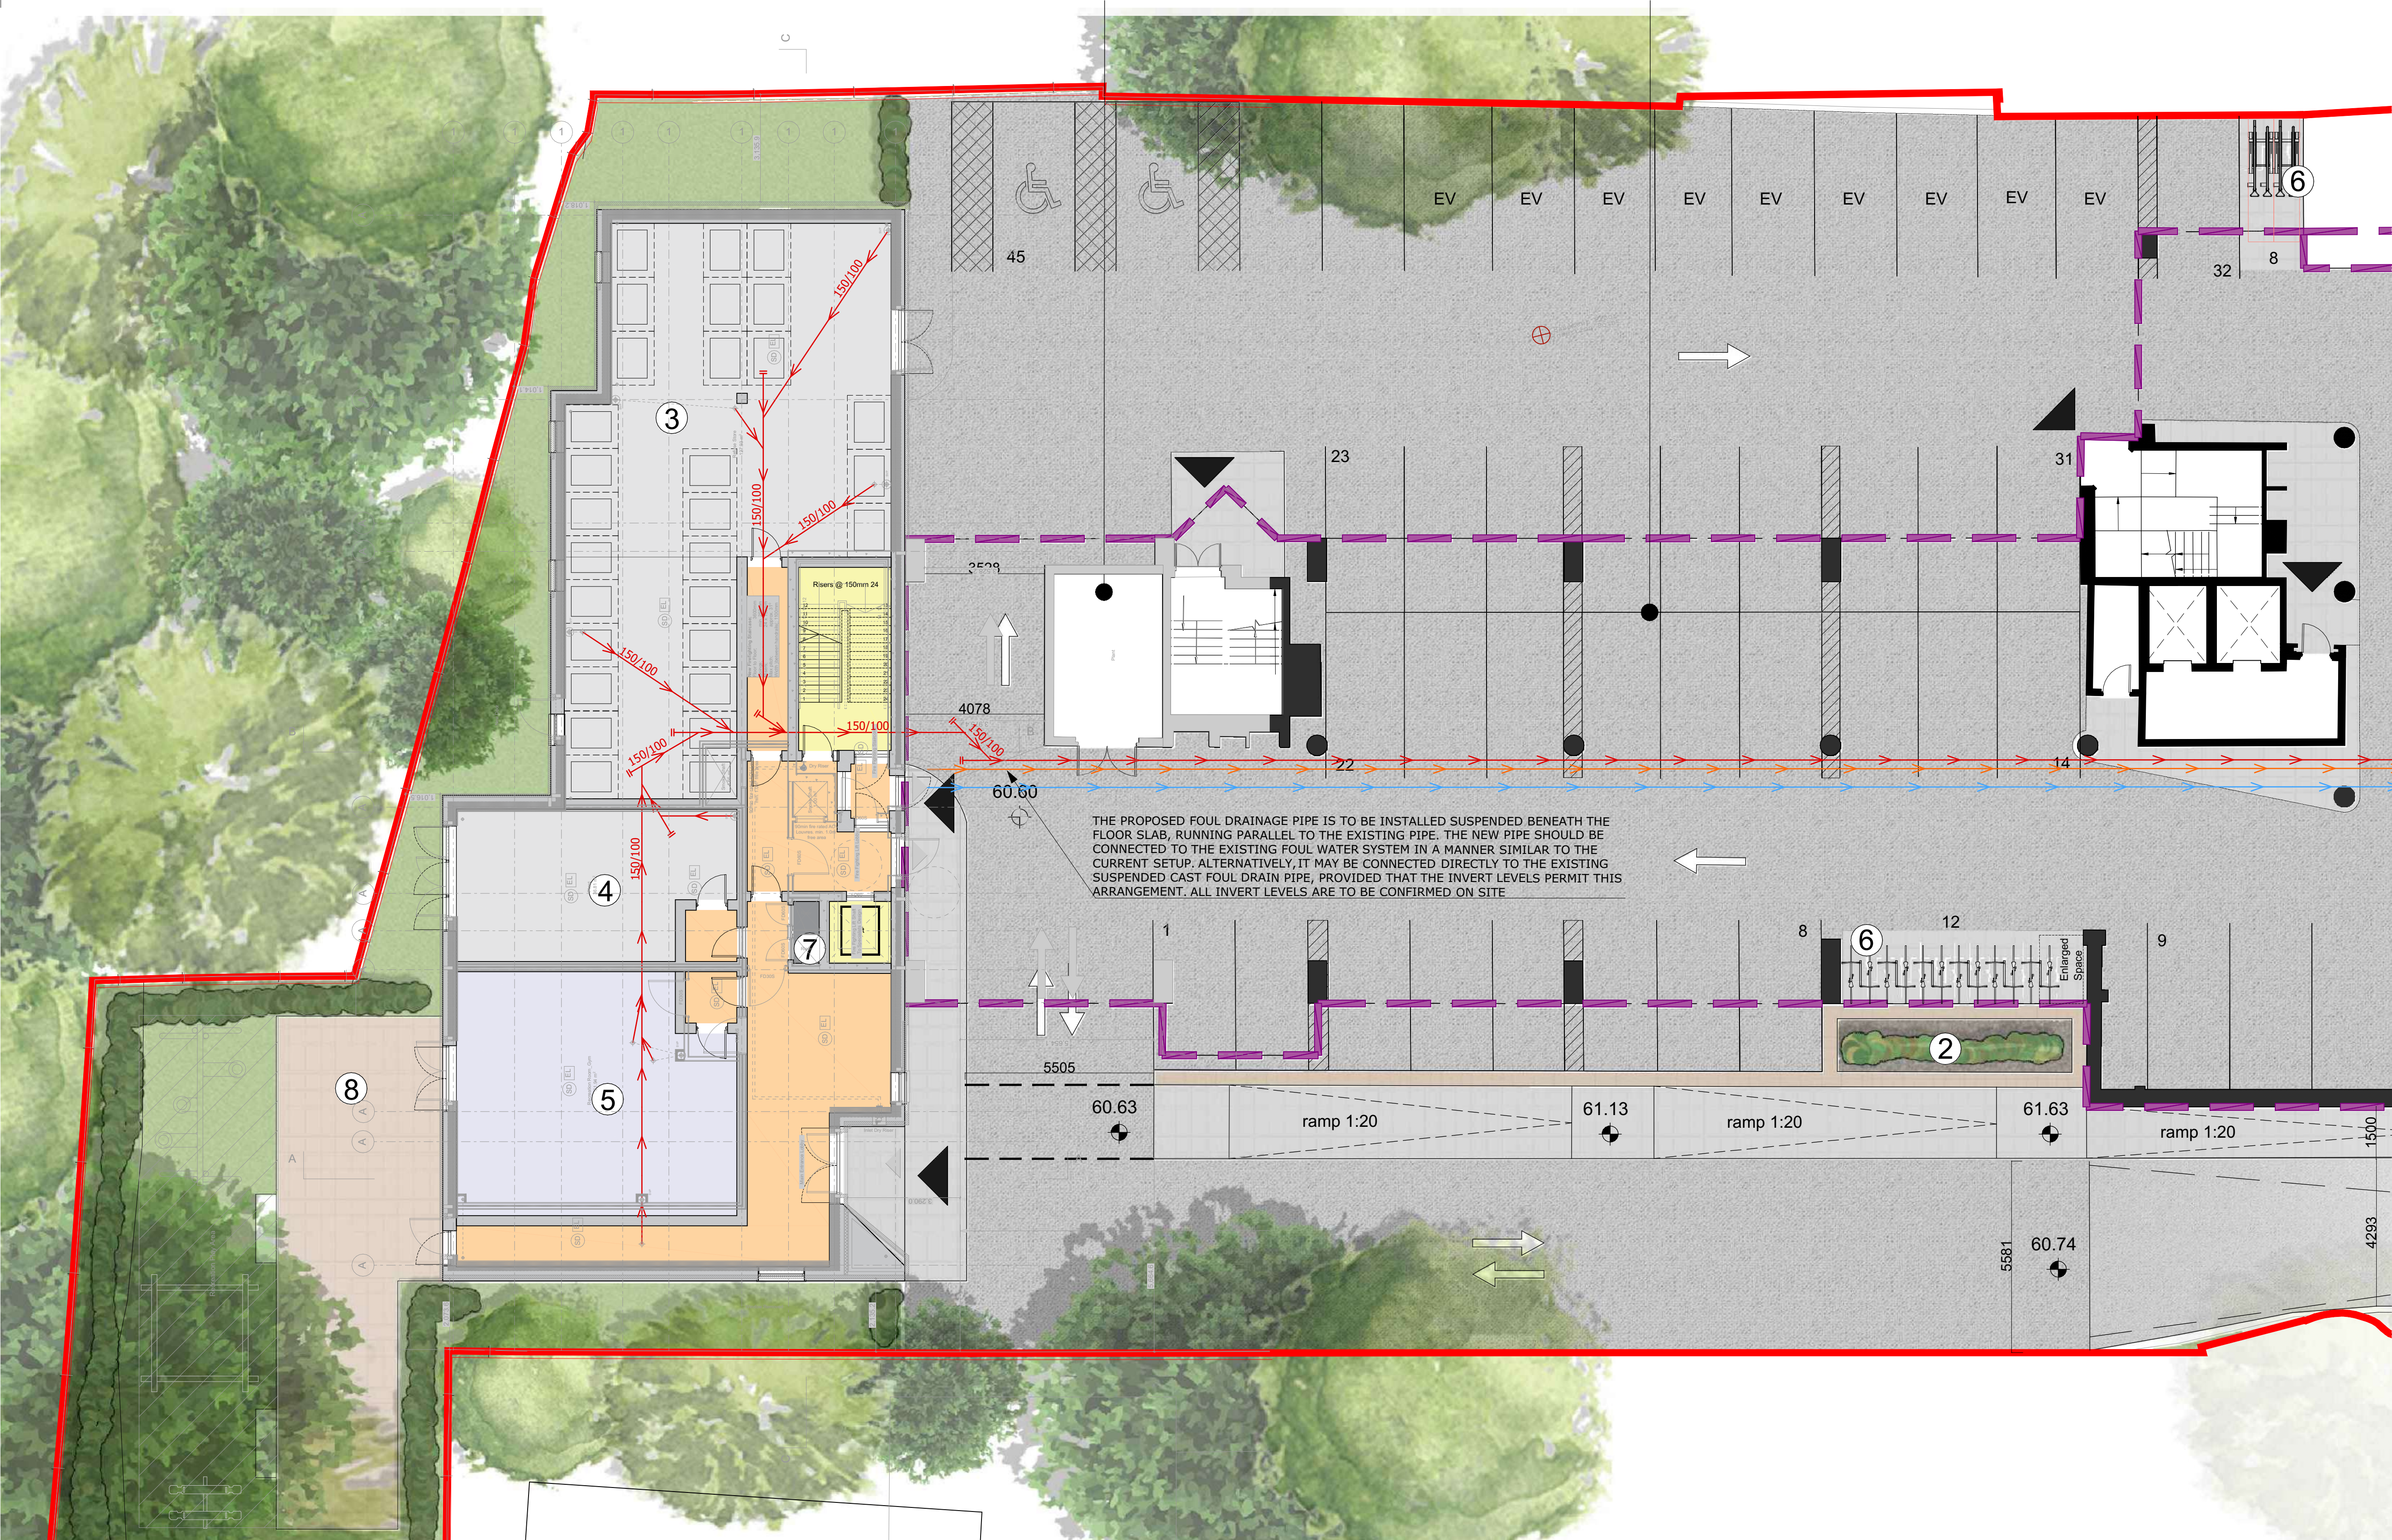


Existing Substation  
to be retained

Parking spaces  
to remain as existing

PROPOSED SUSPENDED CAST (ABOVE GROUND) DRAINAGE PLAN 1/2

1:100



7687-AA-XX-XX-DC-E-0403-PROPOSED SUSPENDED CAST DRAINAGE PLAN 2/2



Construction Risks Maintenance/Cleaning Risks Demolition/Adaptation Risks

In addition to the hazards/risks normally associated with the types of work detailed on this drawing take note of the above. It is assumed that all works on this drawing will be carried out by a competent contractor working, where appropriate, to an appropriate method statement.

Safety Health and Environmental Information Box

Notes:  
This document and its design content are copyright ©. It shall be read in conjunction with all other associated project information including models, specifications, schedules, and related consultants documents. Do not scale from documents. All dimensions are to be checked on site immediately report any discrepancies, errors, or omissions on this document to the Originator. Adkins accepts no liability for the accuracy of the survey and proposed layout information supplied by others. If in doubt, ASK.

LEGEND

- EXISTING BELOW GROUND SURFACE WATER DRAIN
- EXISTING BELOW GROUND FOUL WATER SWE
- PROPOSED BELOW GROUND SURFACE WATER DRAIN
- PROPOSED BELOW GROUND FOUL WATER SWE
- PROPOSED BELOW GROUND COMBINED SWE
- PROPOSED SUSPENDED CAST SURFACE WATER DRAIN
- PROPOSED SUSPENDED CAST FOUL WATER SWE
- EXISTING SUSPENDED CAST SURFACE WATER DRAIN
- EXISTING SUSPENDED CAST FOUL WATER SWE
- EXISTING PUBLIC MANHOLE
- EXISTING FOUL WATER MANHOLE
- EXISTING SURFACE INSPECTION CHAMBER
- PROPOSED FOUL WATER TYPE 3 INSPECTION CHAMBER
- PROPOSED SURFACE WATER TYPE 3 INSPECTION CHAMBER
- SURFACE WATER CATCHPIT MANHOLE
- FLOW CONTROL CHAMBER WITH HYDRO-BRAKE
- BACK DROP
- EXISTING SURFACE WATER DRAINAGE TO BE DEMOLISHED
- EXISTING ROAD GULLEY
- PROPOSED ROAD GULLEY
- PROPOSED LINEAR DRAIN - LOAD CLASS B125 FOR FOOTPATH - LOAD CLASS D400 FOR CAR PARK
- INTERNAL RAINWATER PIPE
- FLOOR GULLEY(FG)
- SOIL / WASTE PIPE
- PROPOSED ATTENUATION TANK

|             |                |             |            |             |
|-------------|----------------|-------------|------------|-------------|
| P01         | FOR APPROVAL   | 09/03/2026  | Issue      | MBM         |
| RevD        | Layout Comment | Issue Date  | Issue/Info | Approved by |
| Scales @ A1 | Issuing Office | Project No. |            |             |
| 1:100       | Kent           | 0226CD7687  |            |             |

Client Approval

A - Approved

B - Approved with Comments

C - Do Not Use

Status

S3 FOR APPROVAL

Originator

Adkins Consultants Ltd  
130 Ashford Rd, Bearsted, Maidstone ME14 4AF

Project

31-33 PERRYMOUNT ROAD  
HAYWARD HEATH

Layout Title

PROPOSED SUSPENDED CAST  
DRAINAGE PLAN 1/2

Client

WE-BUILD UK

Drawing Number

| project | originator | volume | level | type | role | number | rev |
|---------|------------|--------|-------|------|------|--------|-----|
| 7687    | AA         | XX     | XX    | DC   | E    | 0402   | P01 |